
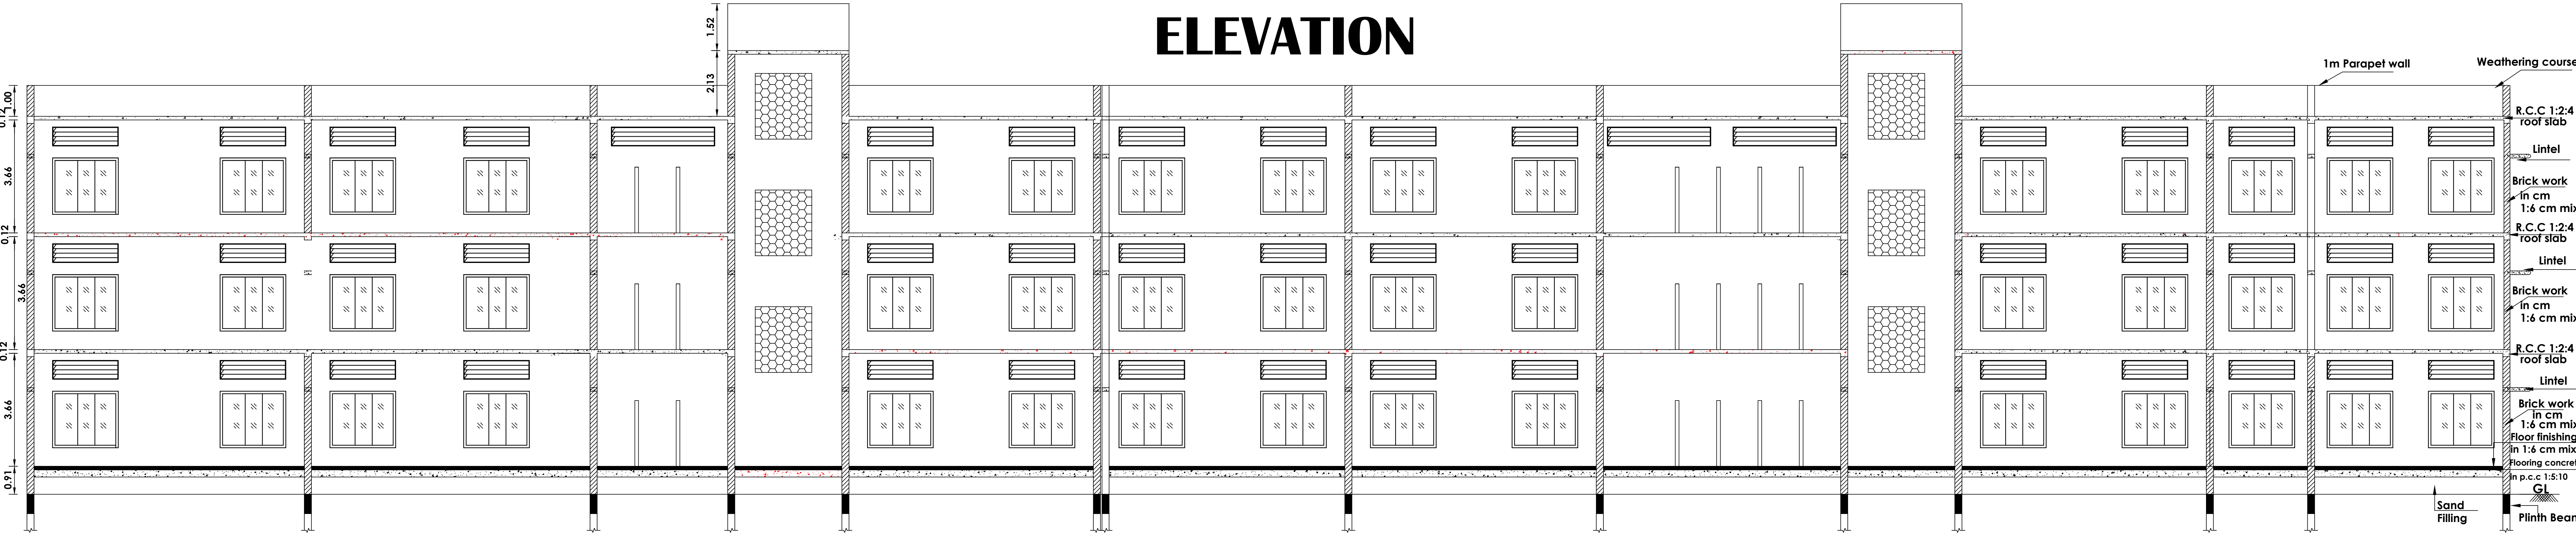


PLAN SHOWING THE RCC ROOF PROPOSED CONSTRUCTION OF SCHOOL BUILDING FOR " M/S JAYAPRIYA VIDYALAYA MATRIC.HIGHER SECONDARY SCHOOL " AT OLD R.S.NO. 47/1H1C, NEW S.F.NO:47/24, 47/25 IN VADAKUTHU VILLAGE, KURINJIPADI PANCHAYAT UNION, KURINJIPADI TALUK, CUDDALORE DISTRICT.


APPLICANT NAME: JAYAPRIYA EDUCATIONAL TRUST.

ALL DIMENSIONS ARE IN METER


SCALE 1:100

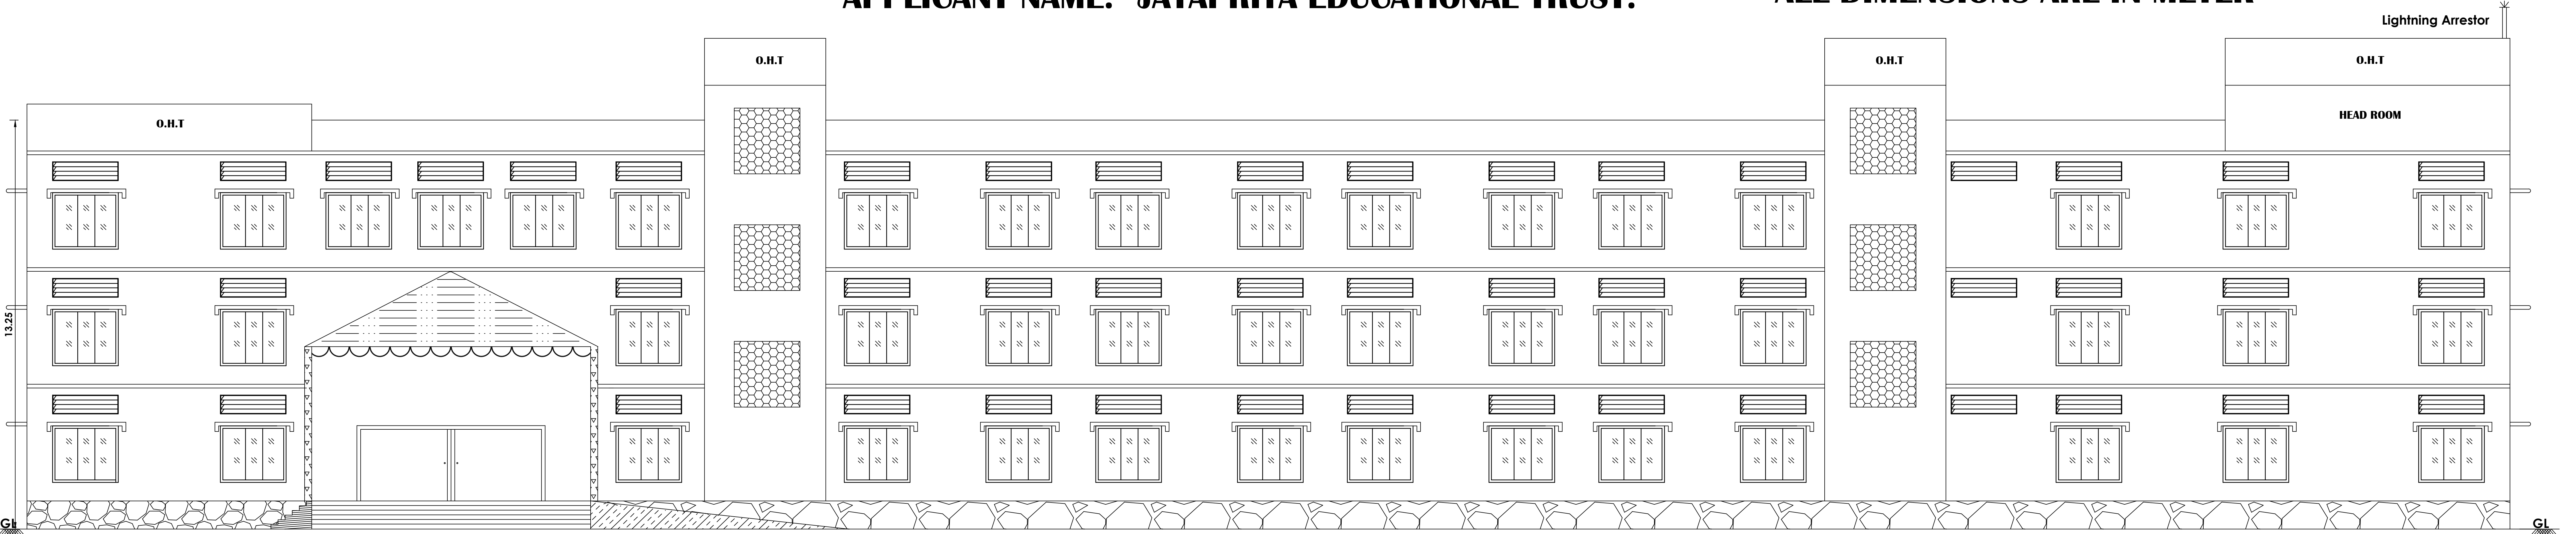


JOINERY DETAILS		
V1	VENTILATOR	3.35 x 0.61
MD	MAIN DOOR	6.10 x 2.44
D	DOOR	1.22 x 2.44
D1	DOOR -1	0.91 x 2.44
D2	DOOR -2	0.76 x 2.13
W	WINDOW	2.13 x 1.83
V	VENTILATOR	2.13 x 0.61
V1	VENTILATOR	3.35 x 0.61
V2	VENTILATOR	2.44 x 0.61
JW	JOLLY WORK	2.13 x 2.44
FA	▽ FIRE ALARM	
FE	△ FIRE EXTINGUISHERS.	
FHR	○ Fire Hose Reel	
EF	⊗ Exhaust Fan With 0.46 Dia	

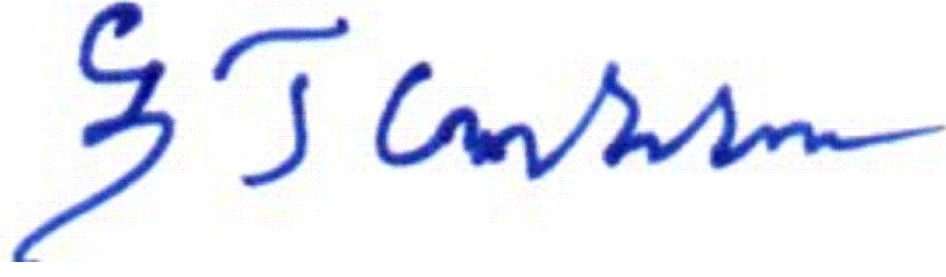

APPLICANT

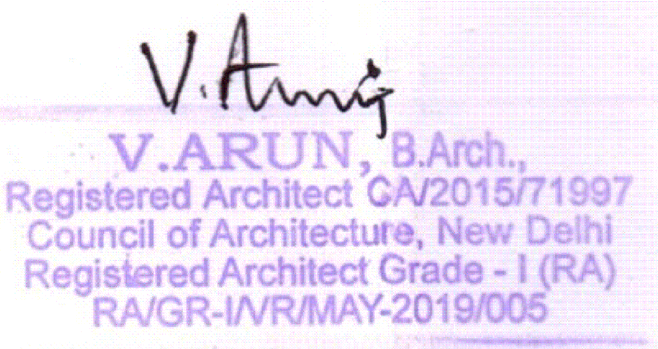

ARCHITECT

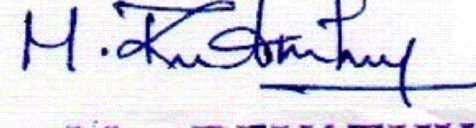


ENGINEER



ENGINEER



STRUCTURAL

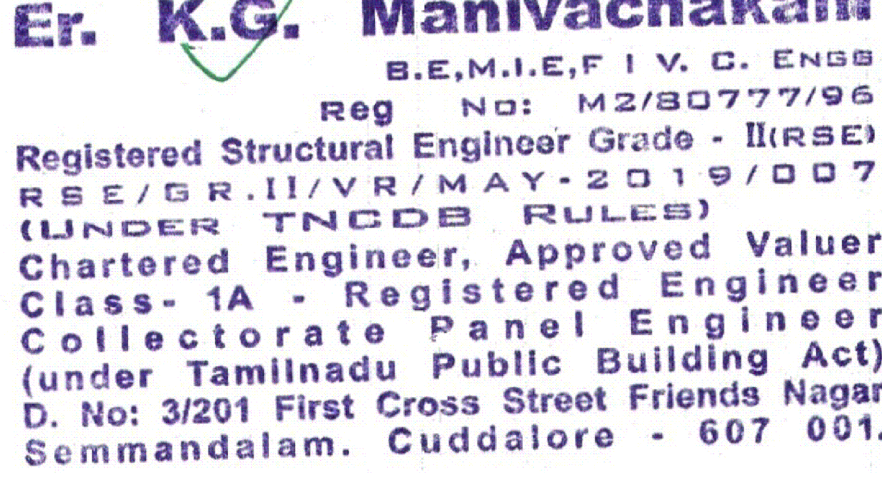

STRUCTURAL



B.P/DTCP NO: 454/ 2023

OFFICE USE

JOINERY DETAILS

Pro. Staircase Head Area - 181.36 Sq.m

SCALE 1:100

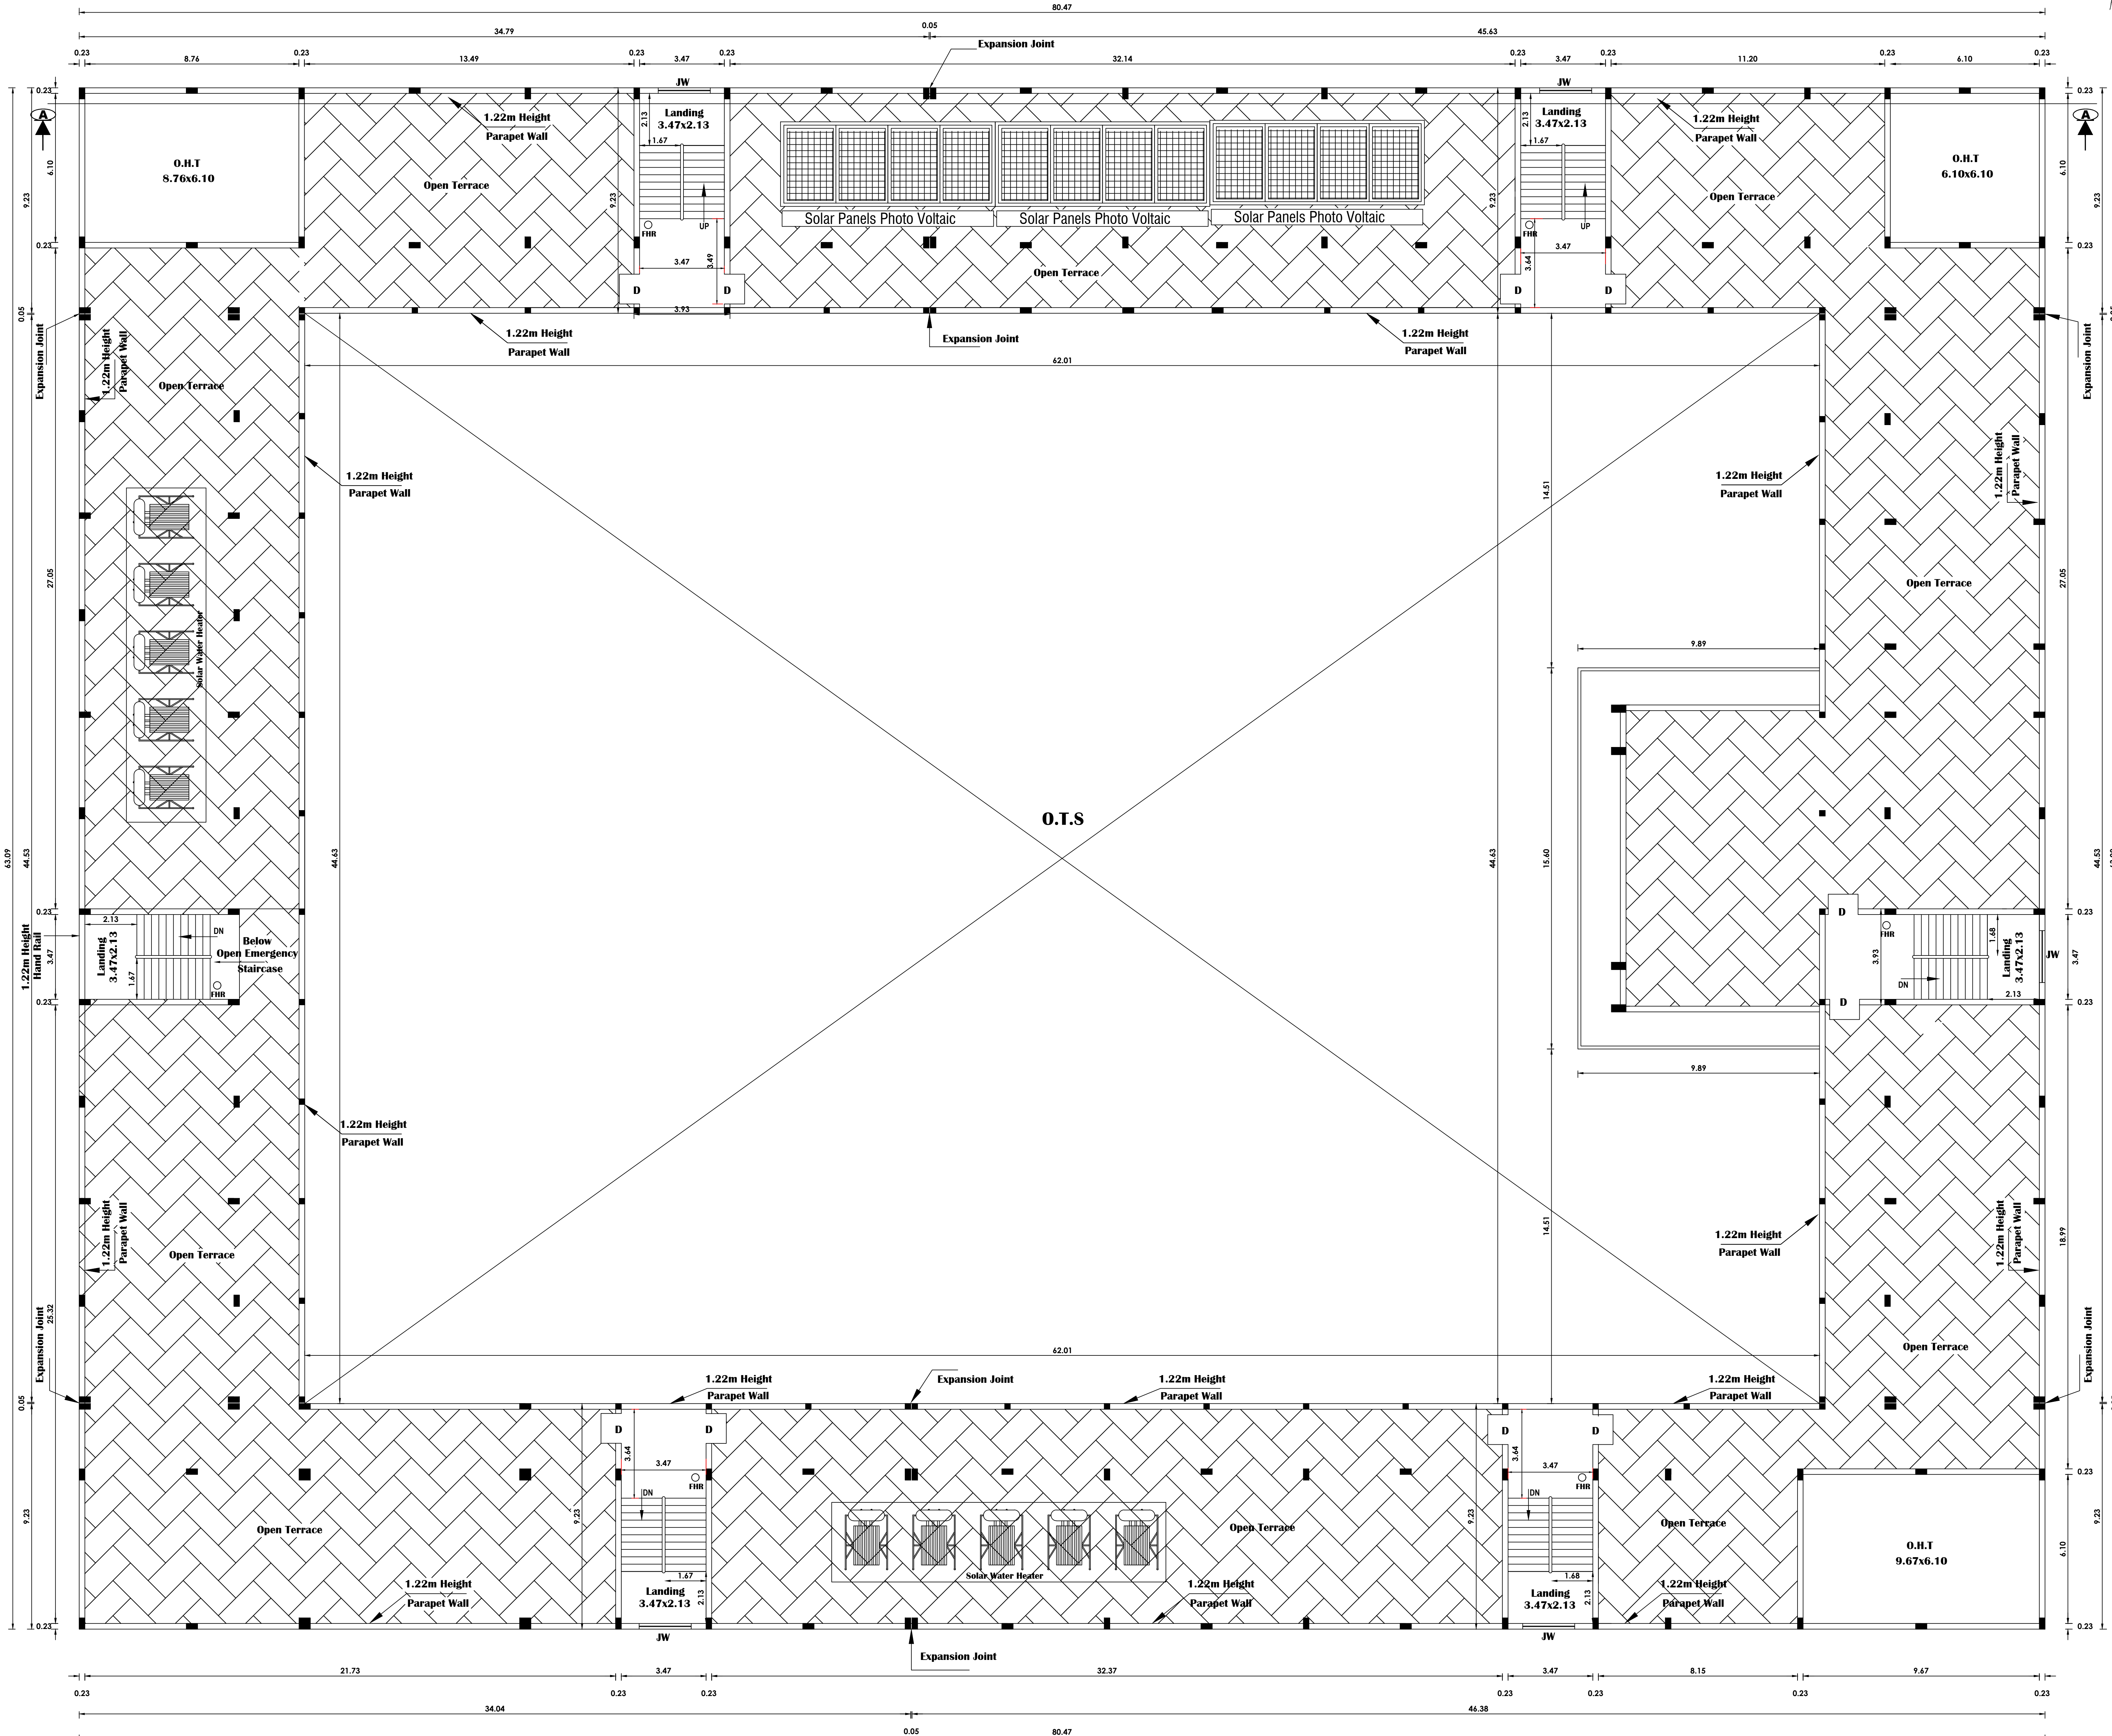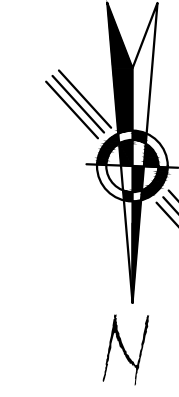

TERRACE FLOOR PLAN

MD	MAIN DOOR	6.10 x 2.44
D	DOOR	1.22 x 2.44
D1	DOOR -1	0.91 x 2.44
D2	DOOR -2	0.76 x 2.13
W	WINDOW	2.13 x 1.83
V	VENTILATOR	2.13 x 0.61
V1	VENTILATOR	3.35 x 0.61
V2	VENTILATOR	2.44 x 0.61
JW	JOLLY WORK	2.13 x 2.44
SD	SLIDE DOOR	1.00 x 2.44
FA	 FIRE ALARM	
FE	 FIRE EXTINGUISHERS.	
FHR	 Fire Hose Reel	
EF	 Exhaust Fan With 0.46 Dia	
PCP	-PHYSICALLY CHALLENGED	

APPLICANT

V. Arun
V. ARUN, B.Arch.,
Registered Architect CA/2015/71997
Council of Architecture, New Delhi
Registered Architect Grade - I (RA)
RA/GR-IVR/MAY-2019/005

ARCHITECT

PCP -PHYSICALLY CHALLENGED PERSON

Er. M. REVATHY, B.E.,
Regd.Engineer Grade-II(RE)
DTCP Reg.No. RE/GR.II/YD/AUGUST-2022/062
RE/GR.II/YD/AUGUST-2022/062
No.47, Ground Floor,Guber Plaza, Trichy Main Road,
Villupuram - 605 602. Ph:96777 43344.

ENGINEER

Er. K.G. Manivachakam
B.E., M.I.E, F.I.V. C. ENGB
Reg No: M2/80777/96
Registered Structural Engineer Grade - II (RSE)
RSE/GR.II/VR/MAY-2019/007
(UNDER TNGDS RULES)
Chartered Engineer, Approved Valuer
Class- 1A - Registered Engineer
Collectorate Panel Engineer
(under Tamilnadu Public Building Act)
D. No: 3/201 First Cross Street Friends Nagar
Semmandalam. Cuddalore - 607 001

STRUCTURAL

B.P/DTCP NO: 454/ 2023


OFFICE USE

PLAN SHOWING THE RCC ROOF PROPOSED CONSTRUCTION OF SCHOOL BUILDING FOR " M/S JAYAPRIYA VIDYALAYA MATRIC.HIGHER SECONDARY SCHOOL " AT OLD R.S.NO. 47/1H1C, NEW S.F.NO:47/24, 47/25 IN VADAKUTHU VILLAGE, KURINJIPADI PANCHAYAT UNION, KURINJIPADI TALUK, CUDDALORE DISTRICT.

APPLICANT NAME: JAYAPRIYA EDUCATIONAL TRUST.

ALL DIMENSIONS ARE IN METER

SCALE 1:100

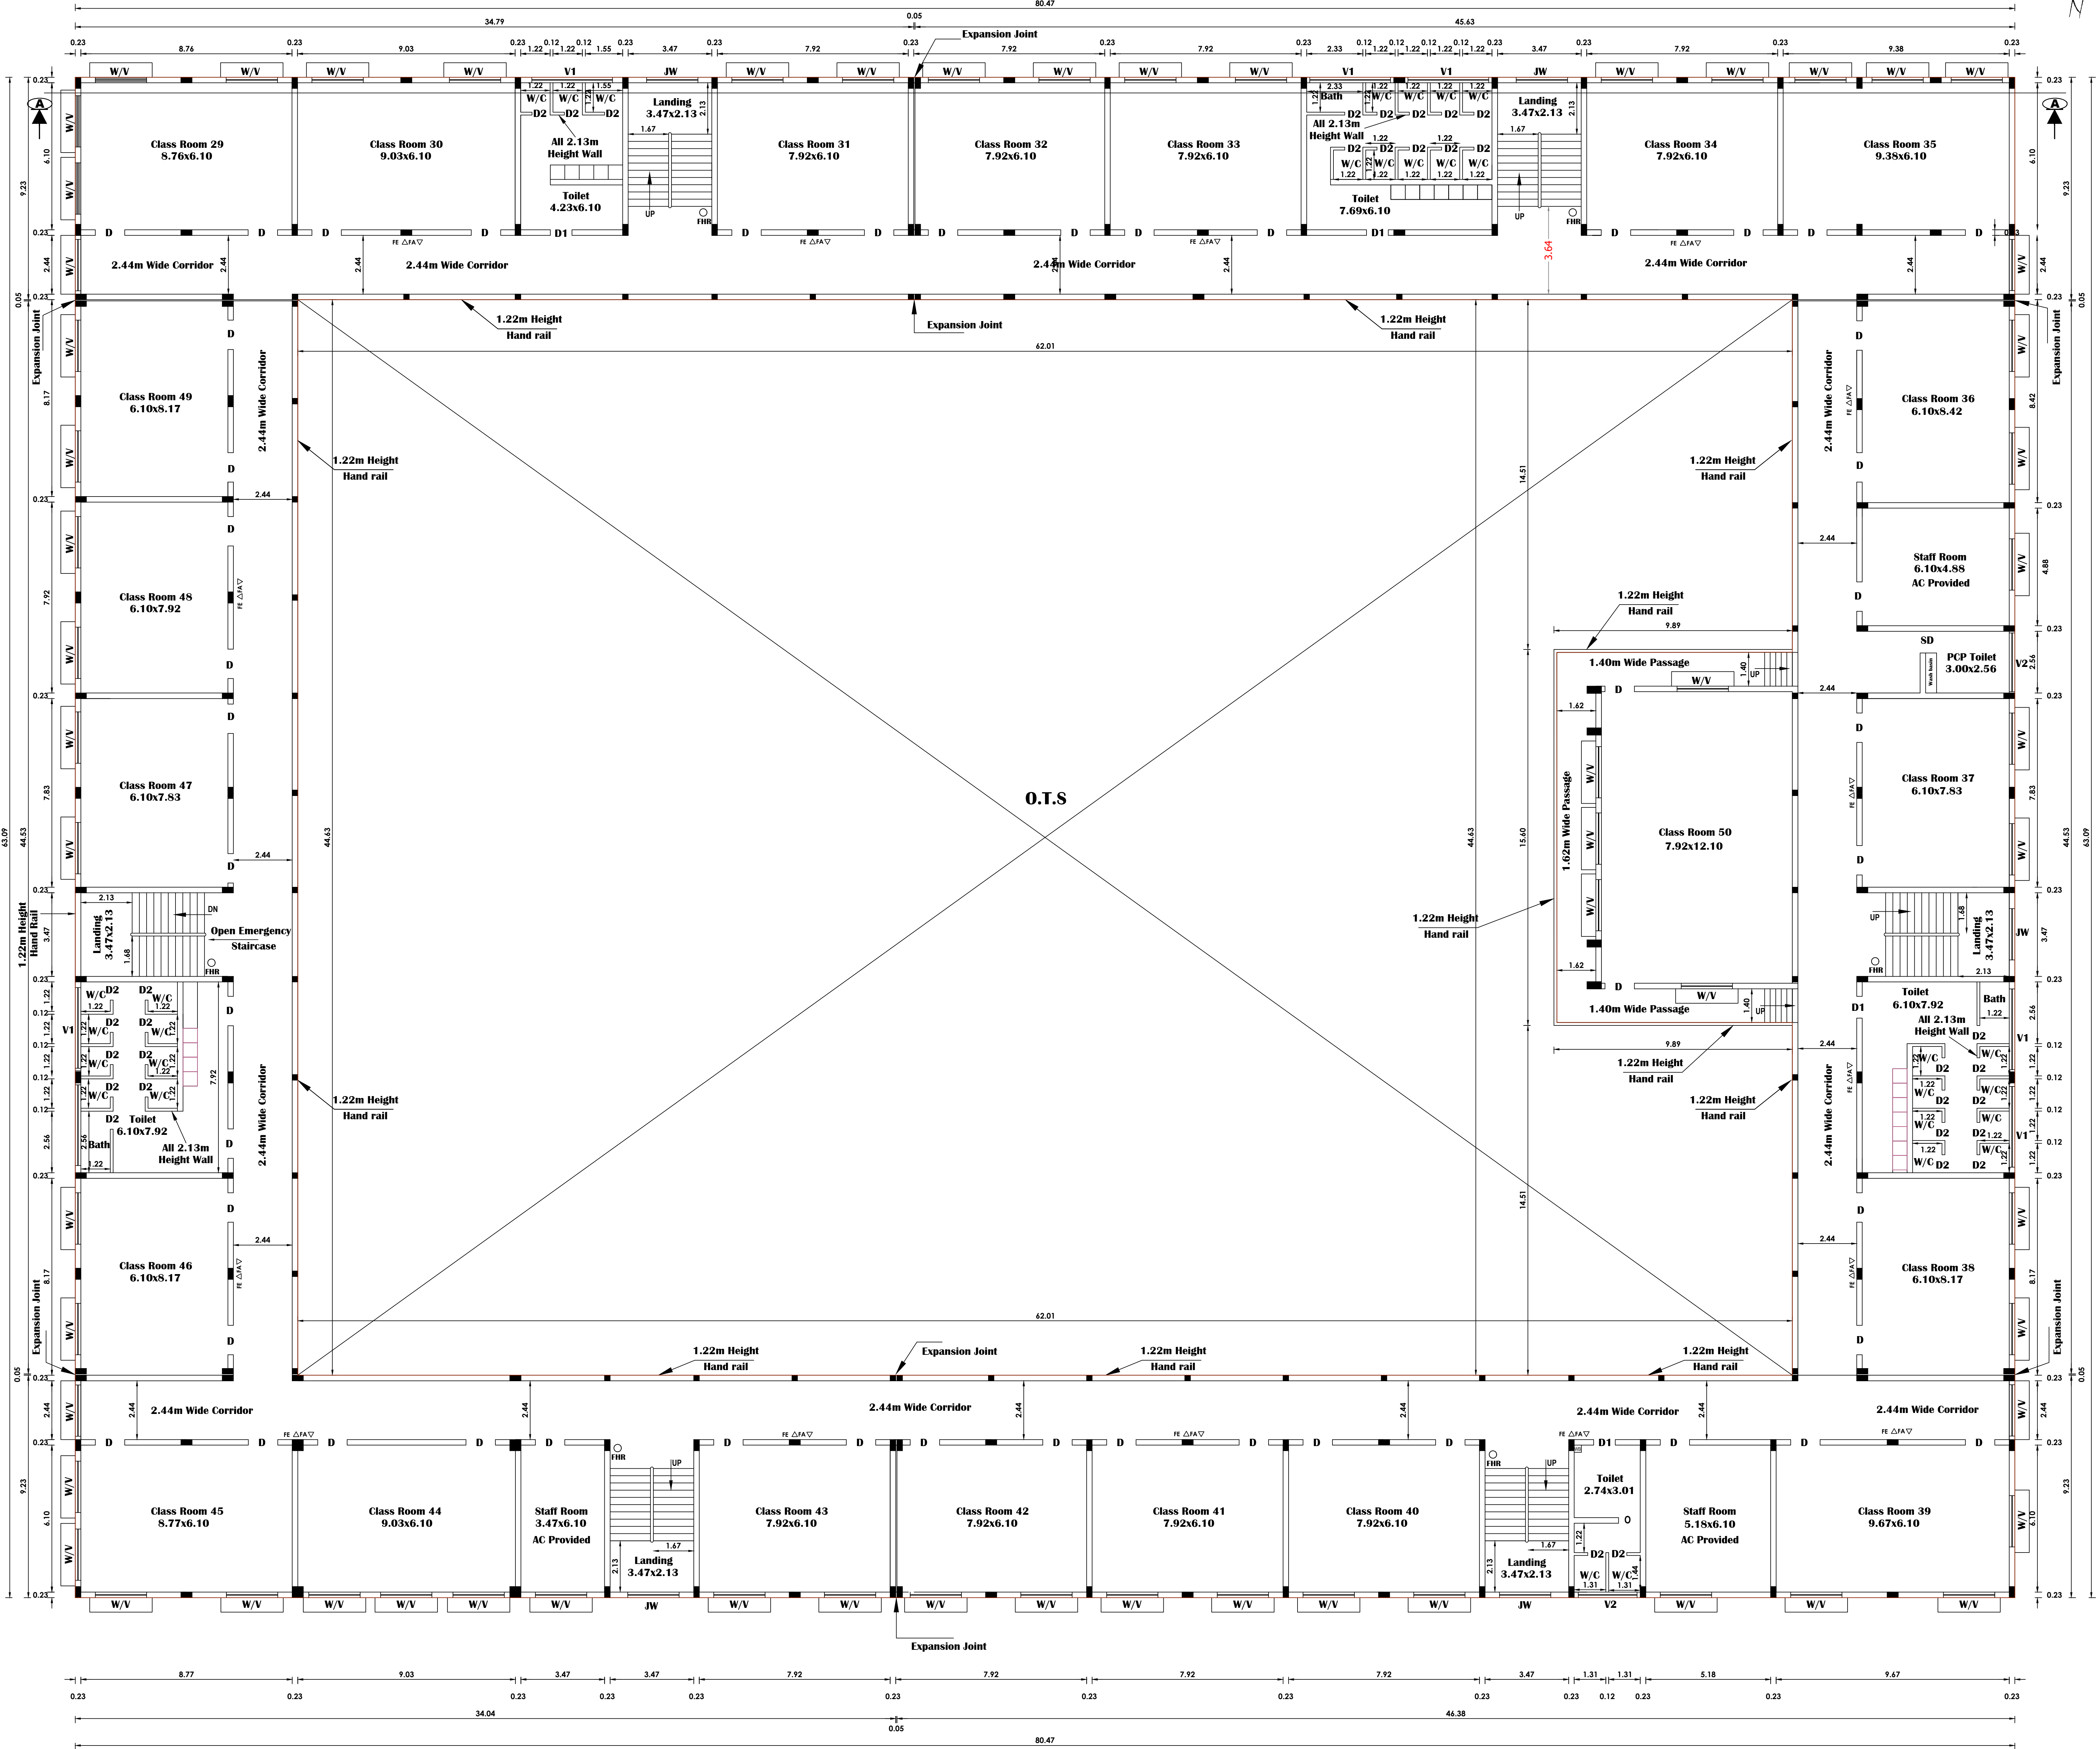

SECOND FLOOR PLAN

JOINERY DETAILS

SCALE 1:100 SHEET No. 4/6

MD	MAIN DOOR	6.10 x 2.44
D	DOOR	1.22 x 2.44
D1	DOOR -1	0.91 x 2.44
D2	DOOR -2	0.76 x 2.13
W	WINDOW	2.13 x 1.83
V	VENTILATOR	2.13 x 0.61
V1	VENTILATOR	3.35 x 0.61
V2	VENTILATOR	2.44 x 0.61
JW	JOLLY WORK	2.13 x 2.44
SD	SLIDE DOOR	1.00 x 2.44
FA	▽ FIRE ALARM	
FE	△ FIRE EXTINGUISHERS.	
FHR	Fire Hose Reel	
EF	⊗ Exhaust Fan With 0.46 Dia	
PCP	-PHYSICALLY CHALLENGED PERSON	

APPLICANT

V. Arun
V. ARUN, B.Arch.,
Registered Architect GA/2015/71997
Council of Architecture, New Delhi
Registered Architect Grade - I (RA)
RA/GR-IVR/MAY-2019/005

ARCHITECT

H. Revathy
Er. M. REVATHY, B.E.,
Regd.Engineer Grade-II(RE)
DTCP Reg.No. RE/GR.II/VD/AUGUST-2022/062
RE/GR.II/VD/AUGUST-2022/062
No.47, Ground Floor,Guber Plaza, Trichy Main Road,
Villupuram - 605 602. Ph:96777 43344.

ENGINEER

K. G. Manivachakam
B.E.,M.I.E.F I V. C. ENGB
Reg No: M2/80777/98
Registered Structural Engineer Grade - II(RSE)
RSE/GR.II/VR/MAY-2019/007
(UNDER TNCD B RULES)
Chartered Engineer, Approved Valuer
Class-1A - Registered Engineer
Collectorate Panel Building Act)
D. No: 3/201 First Cross Street Friends Nagar
Semmandalam. Cuddalore - 607 001.

STRUCTURAL

B.P/DTCP NO: 454/ 2023


OFFICE USE

PLAN SHOWING THE RCC ROOF PROPOSED CONSTRUCTION OF SCHOOL BUILDING FOR " M/S JAYAPRIYA VIDYALAYA MATRIC.HIGHER SECONDARY SCHOOL " AT OLD R.S.NO. 47/1H1C, NEW S.F.NO:47/24, 47/25 IN VADAKUTHU VILLAGE, KURINJIPADI PANCHAYAT UNION, KURINJIPADI TALUK, CUDDALORE DISTRICT.

APPLICANT NAME: JAYAPRIYA EDUCATIONAL TRUST.

ALL DIMENSIONS ARE IN METER

SCALE 1:100

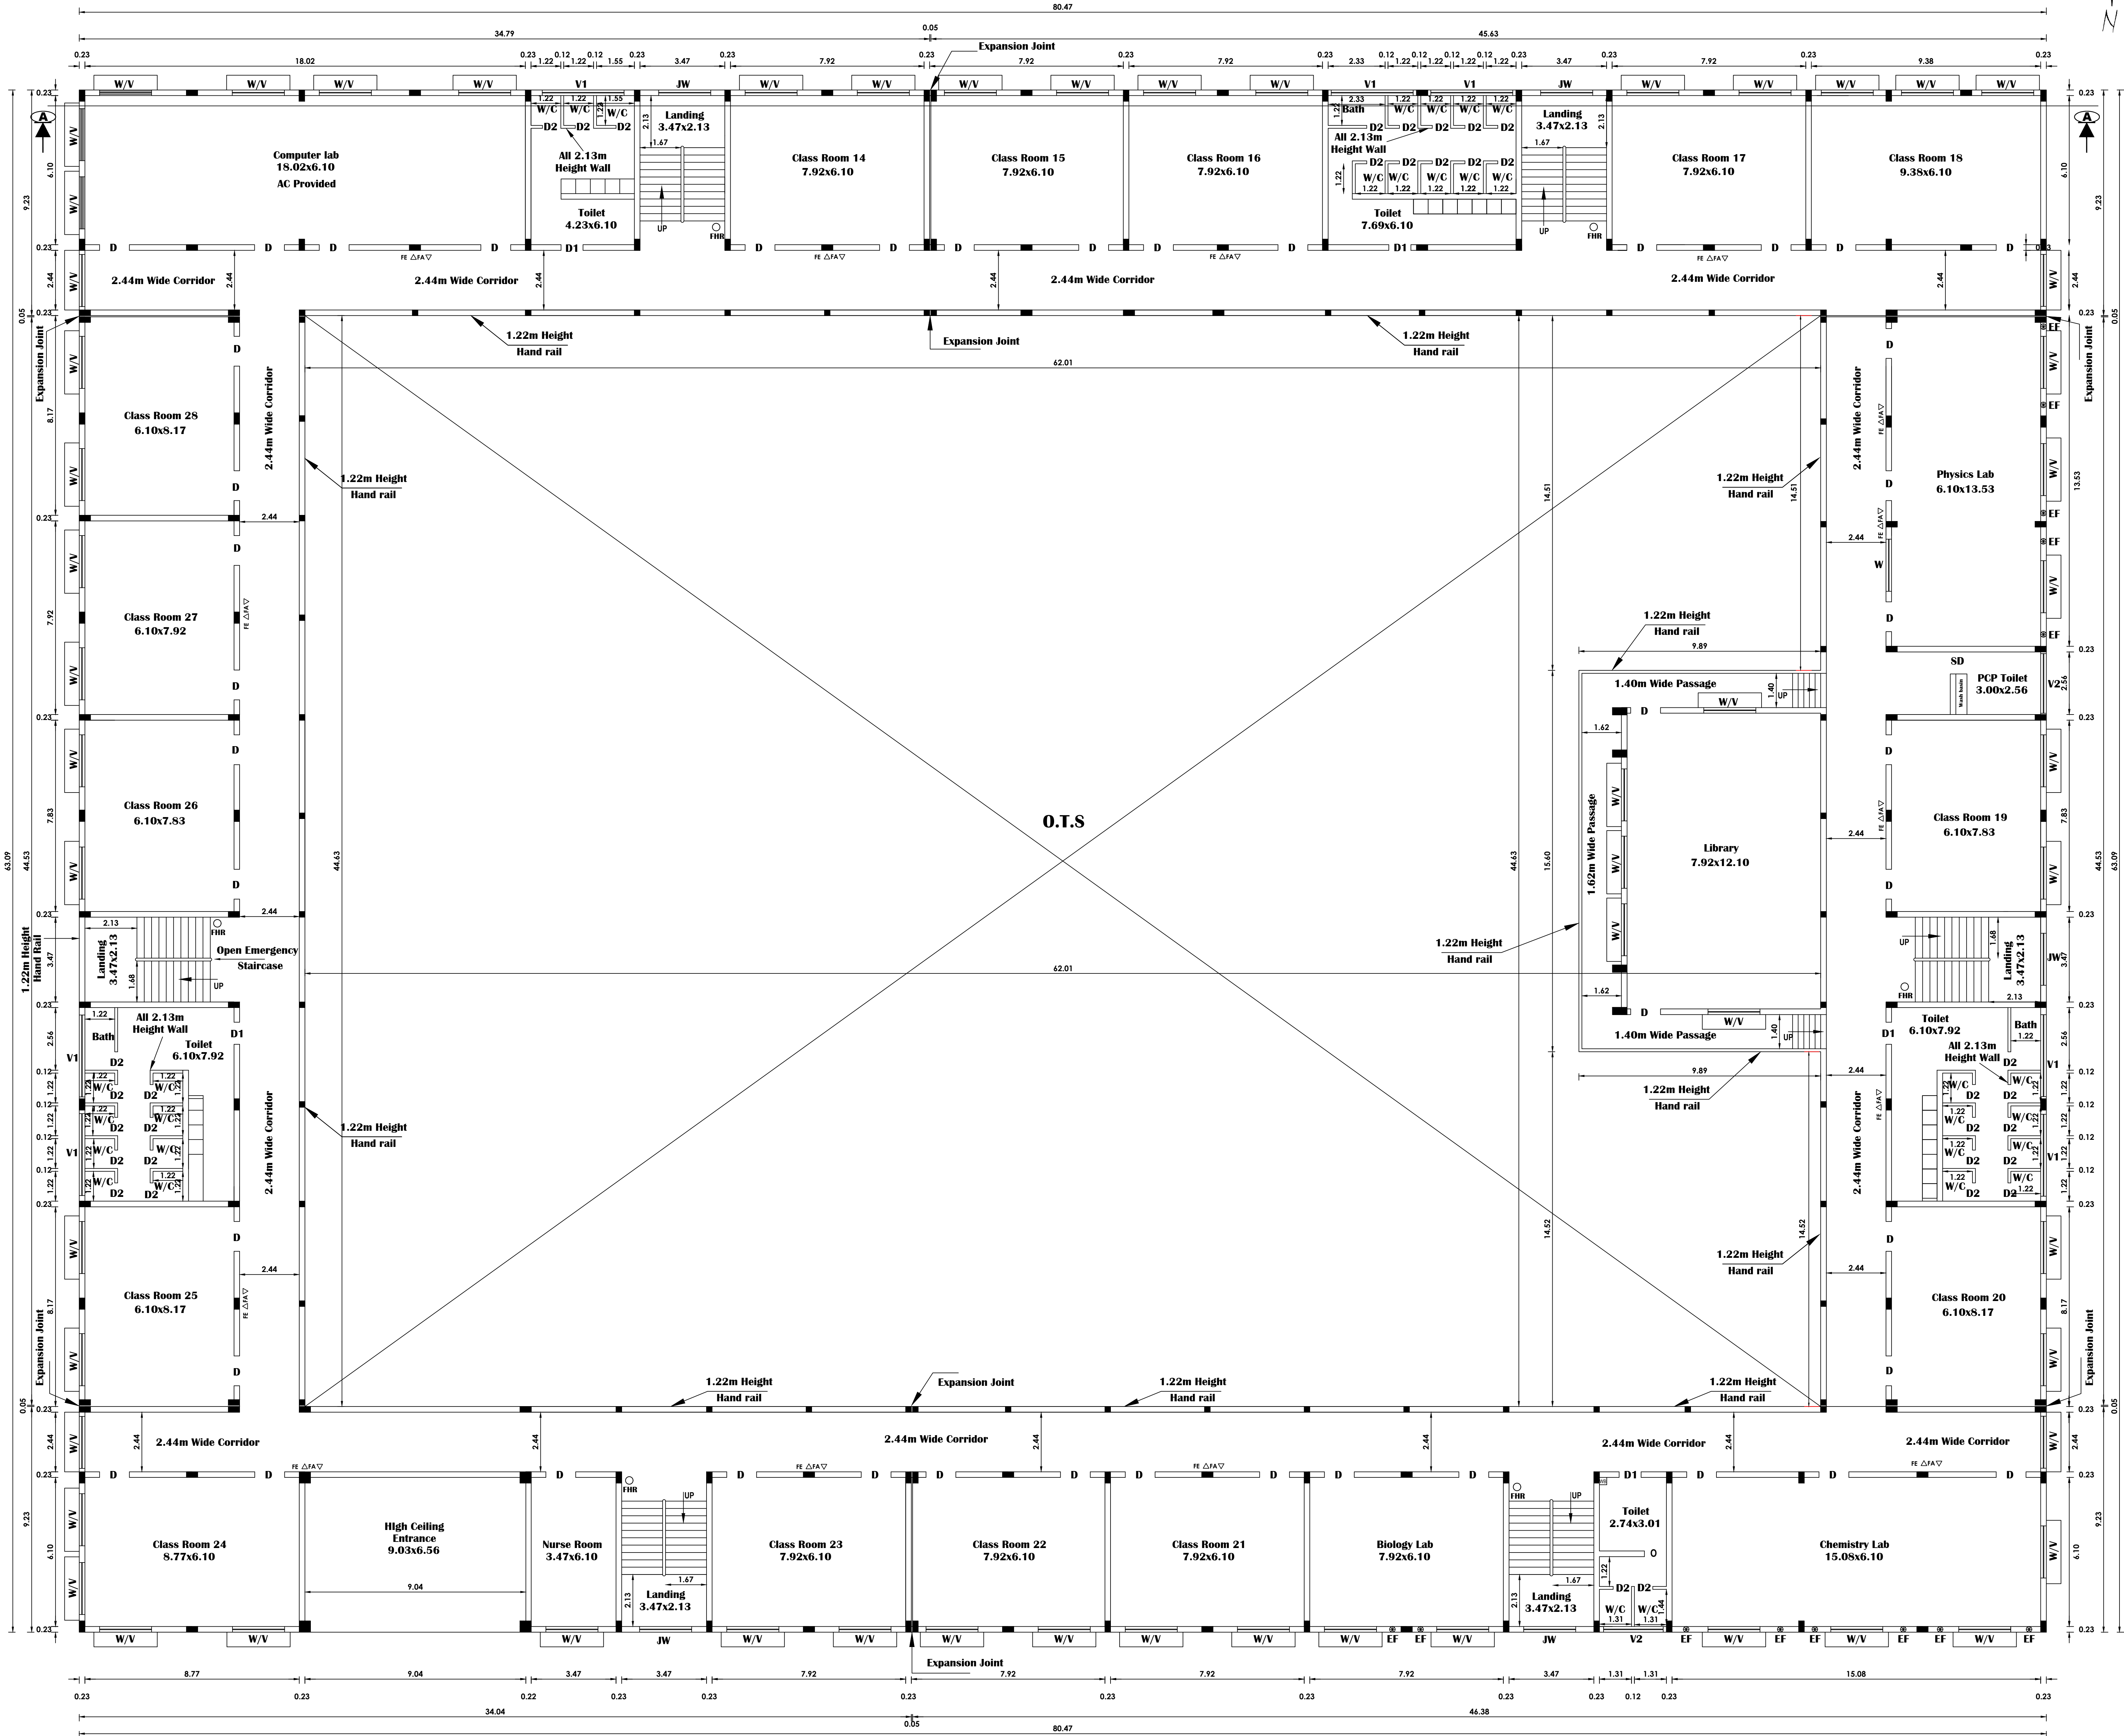

FIRST FLOOR PLAN

JOINERY DETAILS

SCALE 1:100 SHEET No. 3/6

MD	MAIN DOOR	6.10 x 2.44
D	DOOR	1.22 x 2.44
D1	DOOR -1	0.91 x 2.44
D2	DOOR -2	0.76 x 2.13
W	WINDOW	2.13 x 1.83
V	VENTILATOR	2.13 x 0.61
V1	VENTILATOR	3.35 x 0.61
V2	VENTILATOR	2.44 x 0.61
JW	JOLLY WORK	2.13 x 2.44
SD	SLIDE DOOR	1.00 x 2.44

APPLICANT

V. Arun
V. ARUN, B.Arch.,
Registered Architect GA/2015/71997
Council of Architecture, New Delhi
Registered Architect Grade - I (RA)
RA/GR-IV/RMAY-2019/005

ARCHITECT

- FA ▽ FIRE ALARM
- FE △ FIRE EXTINGUISHERS.
- FHR ○ Fire Hose Reel
- EF ⊗ Exhaust Fan With 0.46 Dia
- PCP -PHYSICALLY CHALLENGED PERSON

M. Revathy
Er. M. REVATHY, B.E.,
Regd.Engineer Grade-II(RE)
DTCP Reg.No, RE/GR.II/VD/AUGUST-2022/062
RE/GR.II/VD/AUGUST-2022/062
No.47, Ground Floor,Guber Plaza, Trichy Main Road,
Villupuram - 605 602. Ph:96777 43344.

ENGINEER

K.G. Manivachakam
Er. K.G. Manivachakam
B.E.,M.I.E.F I V. C. ENGE
Reg NO: M2/80777/96
Registered Structural Engineer Grade - II(RSE)
RSE/GR.II/VR/MAY-2019/007
(UNDER TNCD B RULES)
Chartered Engineer, Approved Valuer
Class- 1A - Registered Engineer
Collectorate Panel Engineer
(under Tamilnadu Public Building Act)
D. No: 3/201 First Cross Street Friends Nagar
Semmandalam. Cuddalore - 607 001.

STRUCTURAL

B.P/DTCP NO: 454/ 2023


OFFICE USE

PLAN SHOWING THE RCC ROOF PROPOSED CONSTRUCTION OF SCHOOL BUILDING FOR " M/S JAYAPRIYA VIDYALAYA MATRIC.HIGHER SECONDARY SCHOOL " AT OLD R.S.NO. 47/1H1C, NEW S.F.NO:47/24, 47/25 IN VADAKUTHU VILLAGE, KURINJIPADI PANCHAYAT UNION, KURINJIPADI TALUK, CUDDALORE DISTRICT.

APPLICANT NAME: JAYAPRIYA EDUCATIONAL TRUST.

ALL DIMENSIONS ARE IN METER

SCALE 1:100

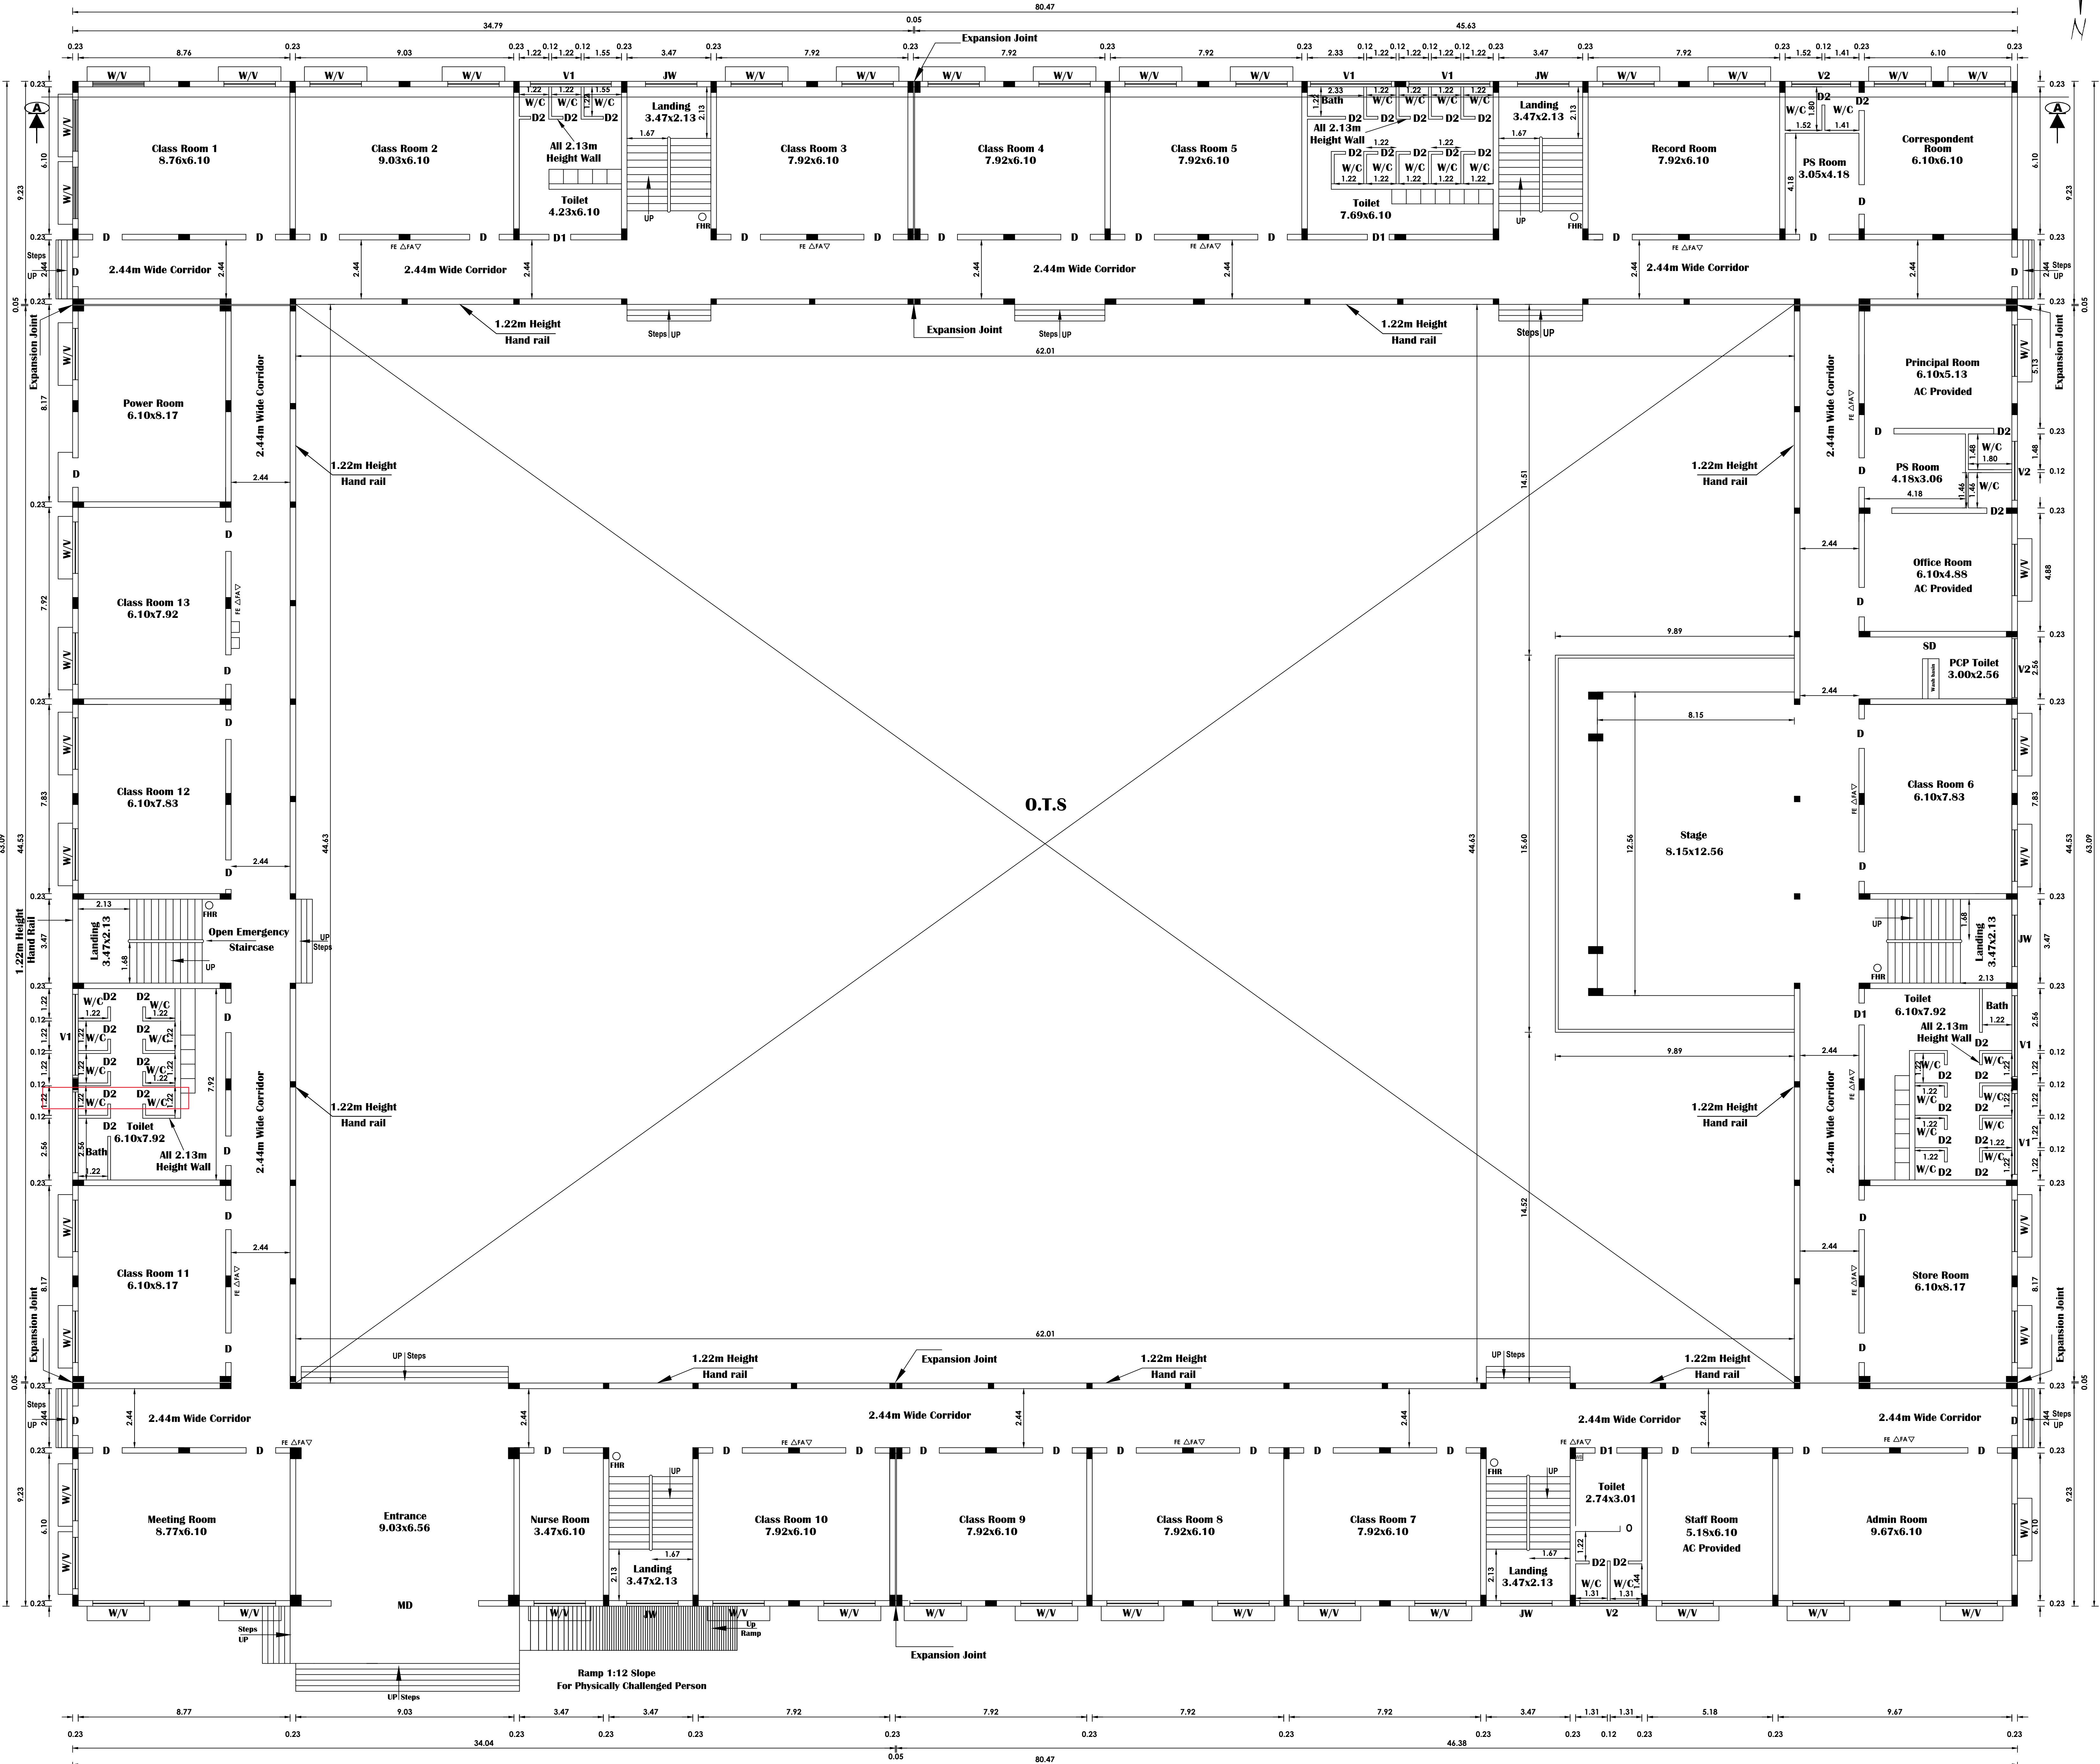


GROUND FLOOR PLAN

JOINERY DETAILS

SCALE 1:100 SHEET No. 2/6

MD	MAIN DOOR	6.10 x 2.44
D	DOOR	1.22 x 2.44
D1	DOOR -1	0.91 x 2.44
D2	DOOR -2	0.76 x 2.13
W	WINDOW	2.13 x 1.83
V	VENTILATOR	2.13 x 0.61
V1	VENTILATOR	3.35 x 0.61
V2	VENTILATOR	2.44 x 0.61
JW	JOLLY WORK	2.13 x 2.44
SD	SLIDE DOOR	1.00 x 2.44

APPLICANT

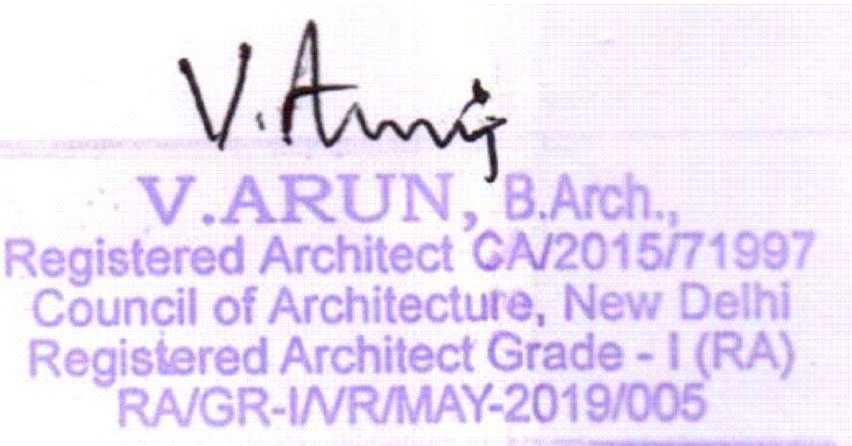

ARCHITECT

- FA ▽ FIRE ALARM
- FE △ FIRE EXTINGUISHERS.
- FHR ○ Fire Hose Reel
- EF ⊗ Exhaust Fan With 0.46 Dia

PCP -PHYSICALLY CHALLENGED PERSON

Er. M. REVATHY, B.E.,
Regd.Engineer Grade-II(RE)
DTCP Reg.No, RE/GR.II/VD/AUGUST-2022/062
RE/GR.II/VD/AUGUST-2022/062
No.47, Ground Floor,Guber Plaza, Trichy Main Road,
Villupuram - 605 602. Ph:96777 43344.

ENGINEER

Er. K.G. Manivachakam
B.E,M.I.E,F I V. C. ENGE
Reg NO: M2/80777/96
Registered Structural Engineer Grade - II(RSE)
RSE/GR.II/VR/MAY-2019/007
(UNDER TNCD B RULES)
Chartered Engineer, Approved Valuer
Class- 1A - Registered Engineer
Collectorate Panel Engineer
(under Tamilnadu Public Building Act)
D. No: 3/201 First Cross Street Friends Nagar
Semmandalam. Cuddalore - 607 001.

STRUCTURAL

B.P/DTCP NO: 454/ 2023

OFFICE USE

SITE PLAN SHOWING THE RCC ROOF PROPOSED CONSTRUCTION OF SCHOOL BUILDING FOR " M/S JAYAPRIYA VIDYALAYA MATRIC.HIGHER SECONDARY SCHOOL " AT OLD R.S.NO. 47/1H1C, NEW S.F.NO:47/24, 47/25 IN VADAKUTHU VILLAGE, KURINJIPADI PANCHAYAT UNION, KURINJIPADI TALUK, CUDDALORE DISTRICT.

JAYAPRIYA EDUCATIONAL TRUST.

SITE EXTENT		SCALE 1:400	SHEET No. 1/6
S.F. NO	Area in Sq.m	V. Arun V. ARUN, B.Arch., Registered Architect CA/2015/71997 Council of Architecture, New Delhi Registered Architect Grade - I (RA) RA/GR-IVR/MAY-2019/005	ARCHITECT
47/24	4461		
47/25	7656		
Total	12117 Sq.m		

ALL DIMENSIONS ARE IN METER

AREA DETAILS		
Total Site Area 11495.01 Sq.m As Per Super Imposed Plot area.		
Total Site Area 12117 Sq.m As Per Patta	F.S.I. Area in Sq.m.	NON - F.S.I. Area in Sq.m.
Pro. Ground Floor Area	2463.63	-
Pro. First Floor Area	2463.63	-
Pro. Second Floor Area	2463.63	-
Staircase Head Room Area	-	181.36
Total Area	7390.89	181.36


APPLICANT

Er. M. REVATHY, B.E.,
Regd.Engineer Grade-II(RE)
DTCP Reg.No. RE/GR.II/VD/AUGUST-2022/062
RE/GR.II/VD/AUGUST-2022/062
No.47, Ground Floor,Guber Plaza, Trichy Main Road,
Villupuram - 605 602. Ph:96777 43344.

ENGINEER

Er. K.G. Manivachakam
B.E.,M.I.E.F I V. C. ENGB
Reg No: M2/80777/96
Registered Structural Engineer Grade - II(RSE)
RSE/GR.II/VR/MAY-2019/007
(UNDER TNCDB RULES)
Chartered Engineer, Approved Valuer
Class-1A - Registered Engineer
Collectorate Panel Engineer
(under Tamilnadu Public Building Act)
D. No: 3/201 First Cross Street Friends Nagar
Semmandalam. Cuddalore - 607 001.






STRUCTURAL

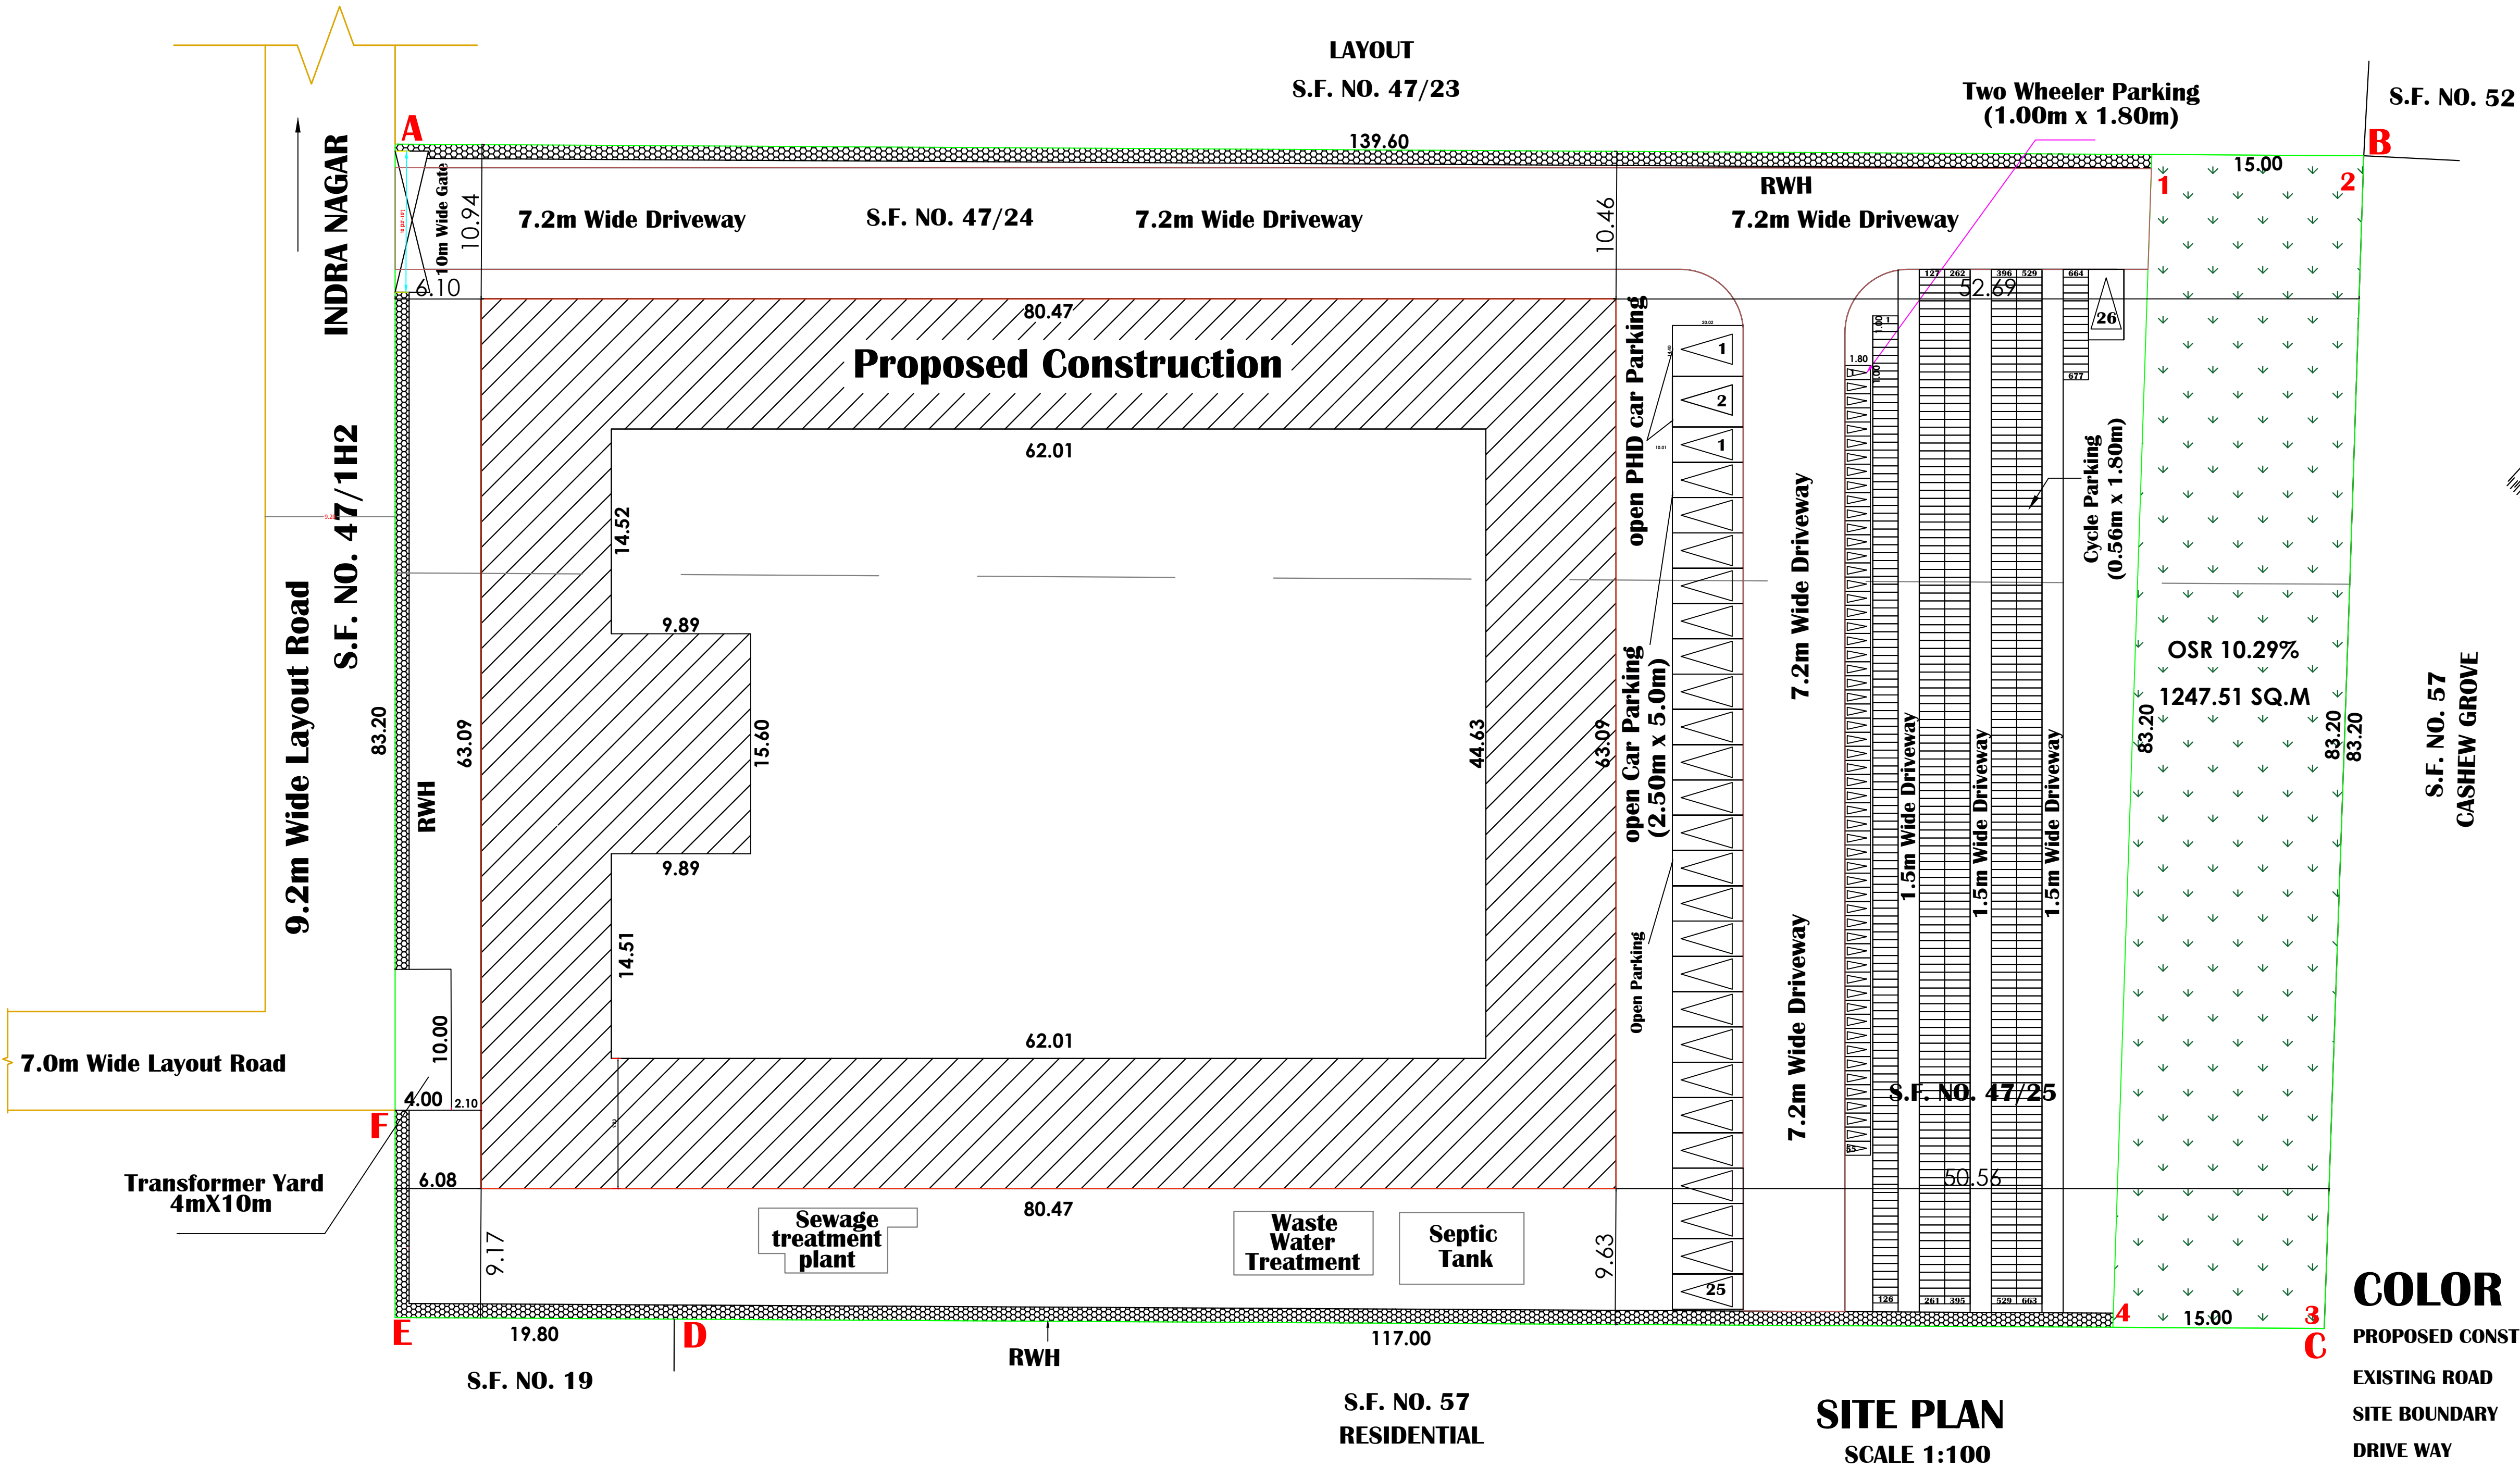





COLOR INDEX

- PROPOSED CONSTRUCTION
- EXISTING ROAD
- SITE BOUNDARY
- DRIVE WAY

B.PIDTCP NO. 454/ 2023

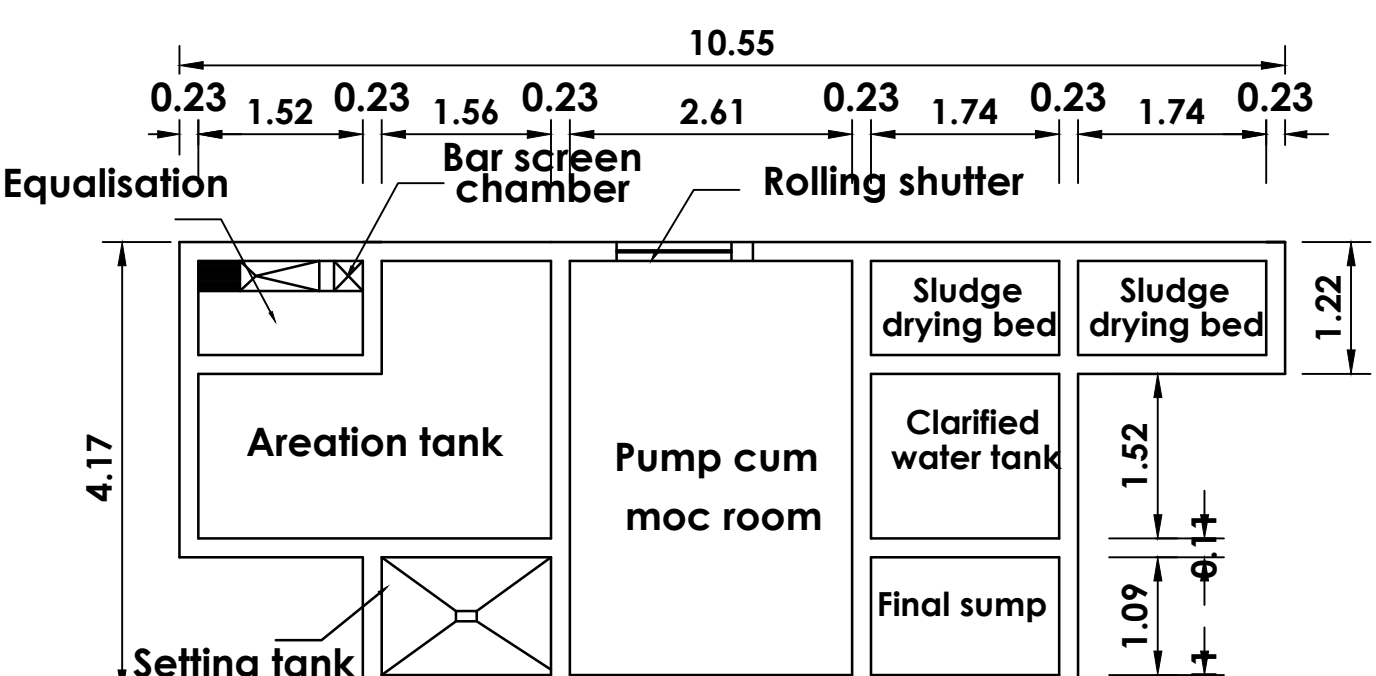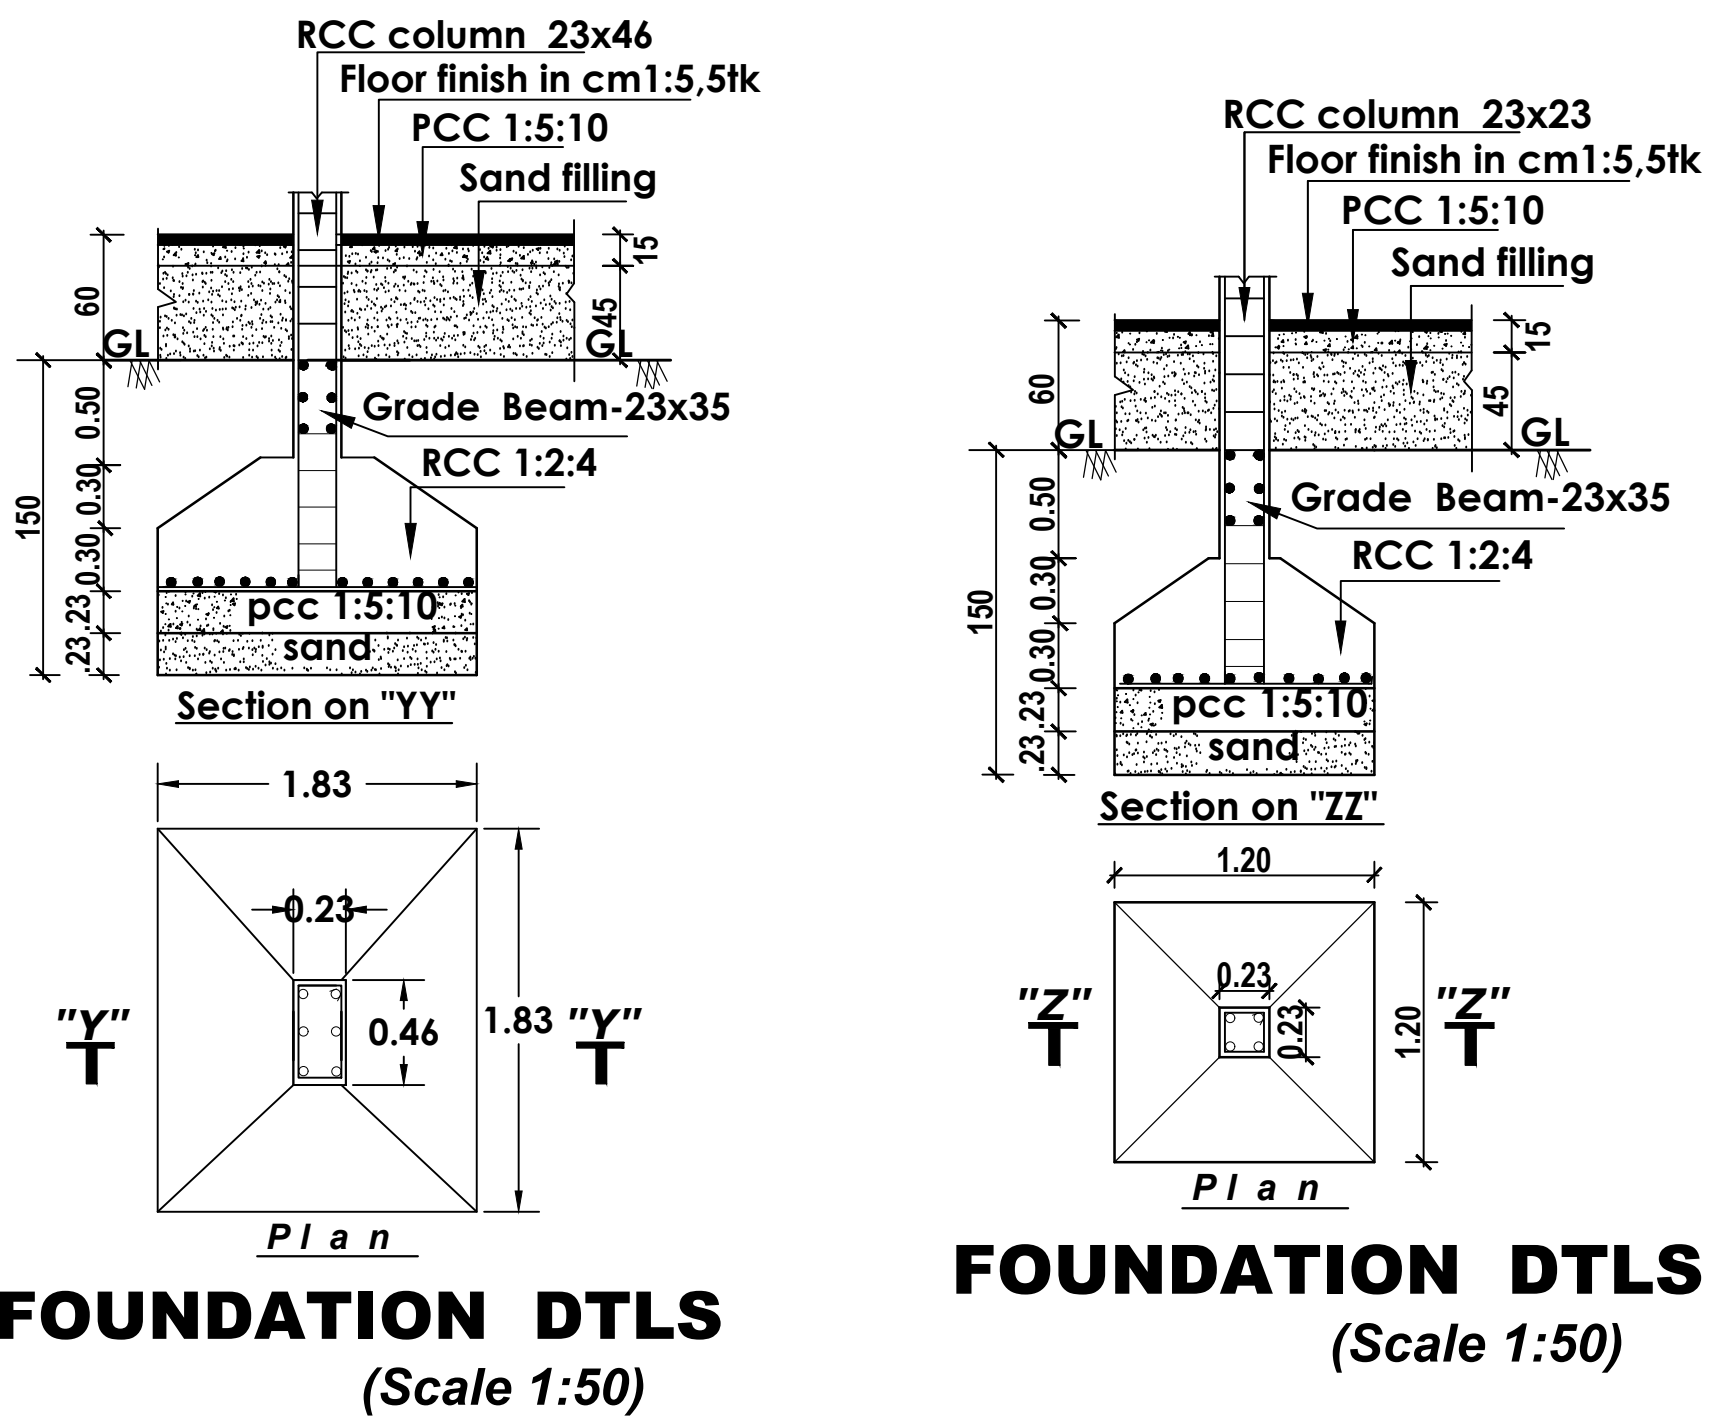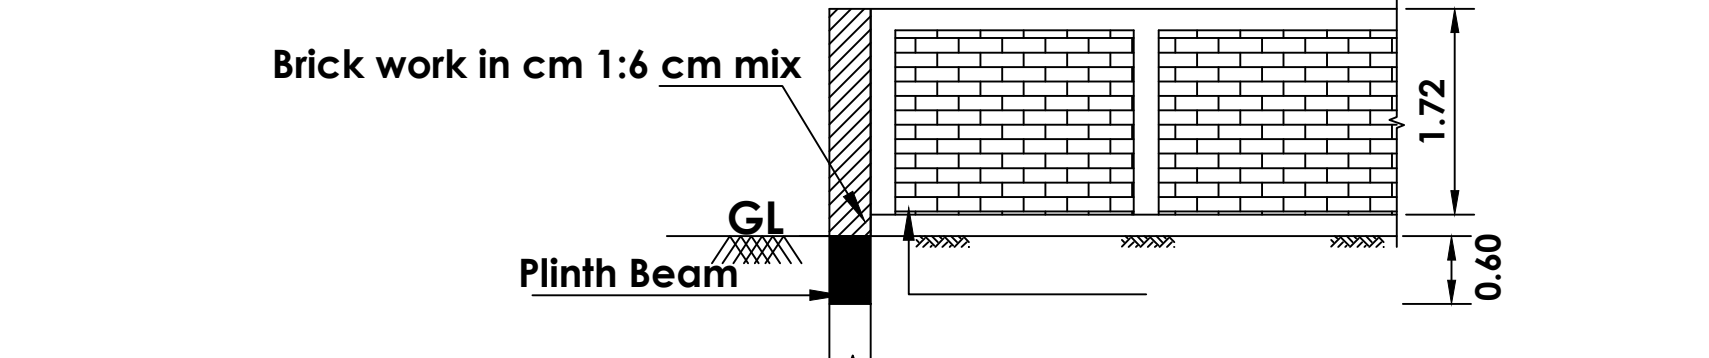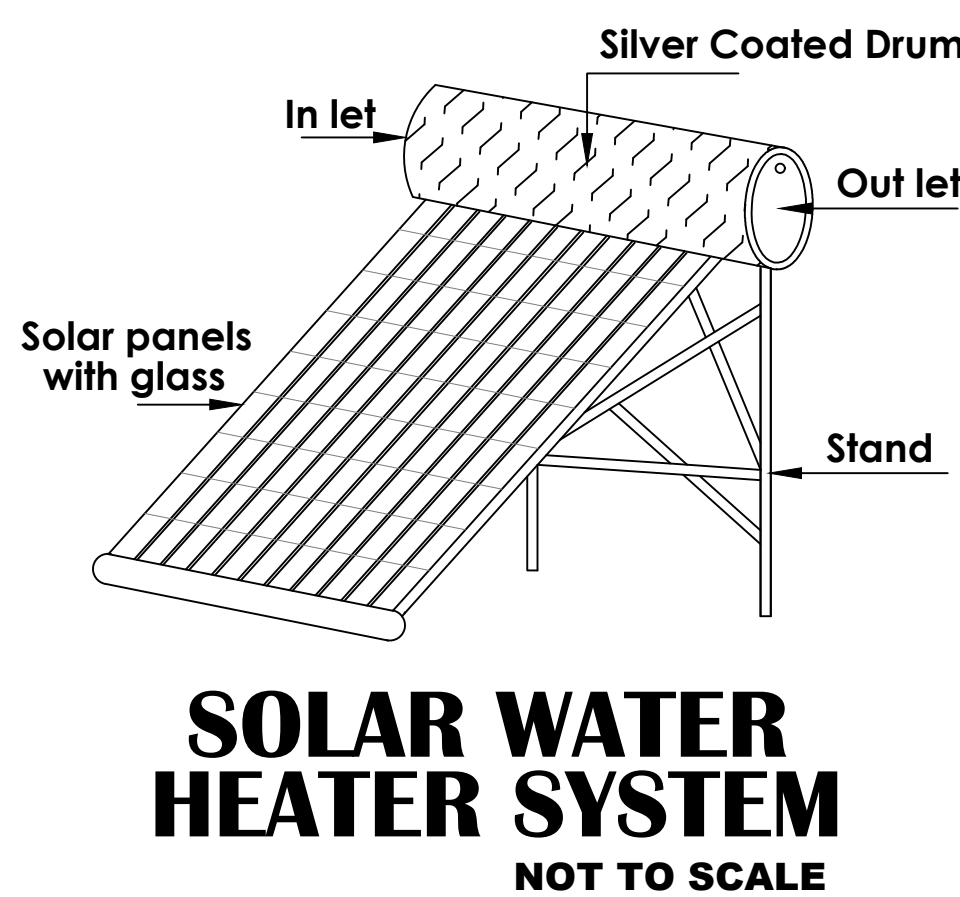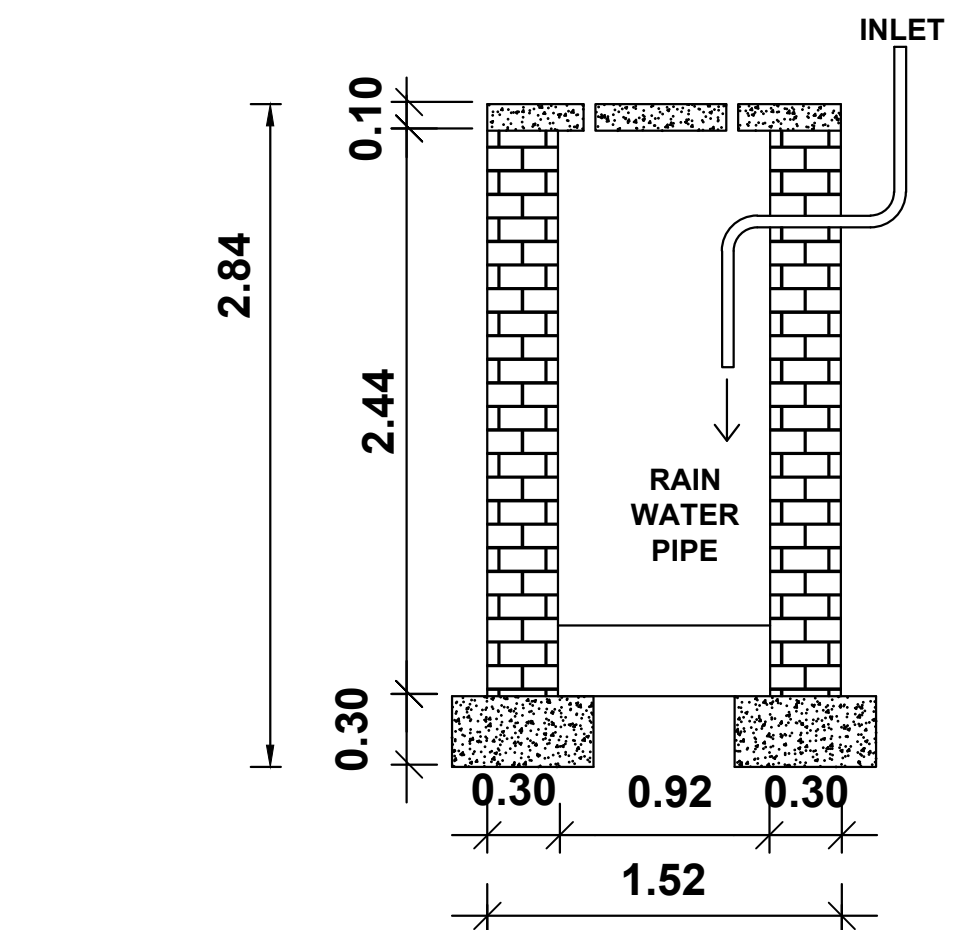

SEWAGE TREATMENT PLANT

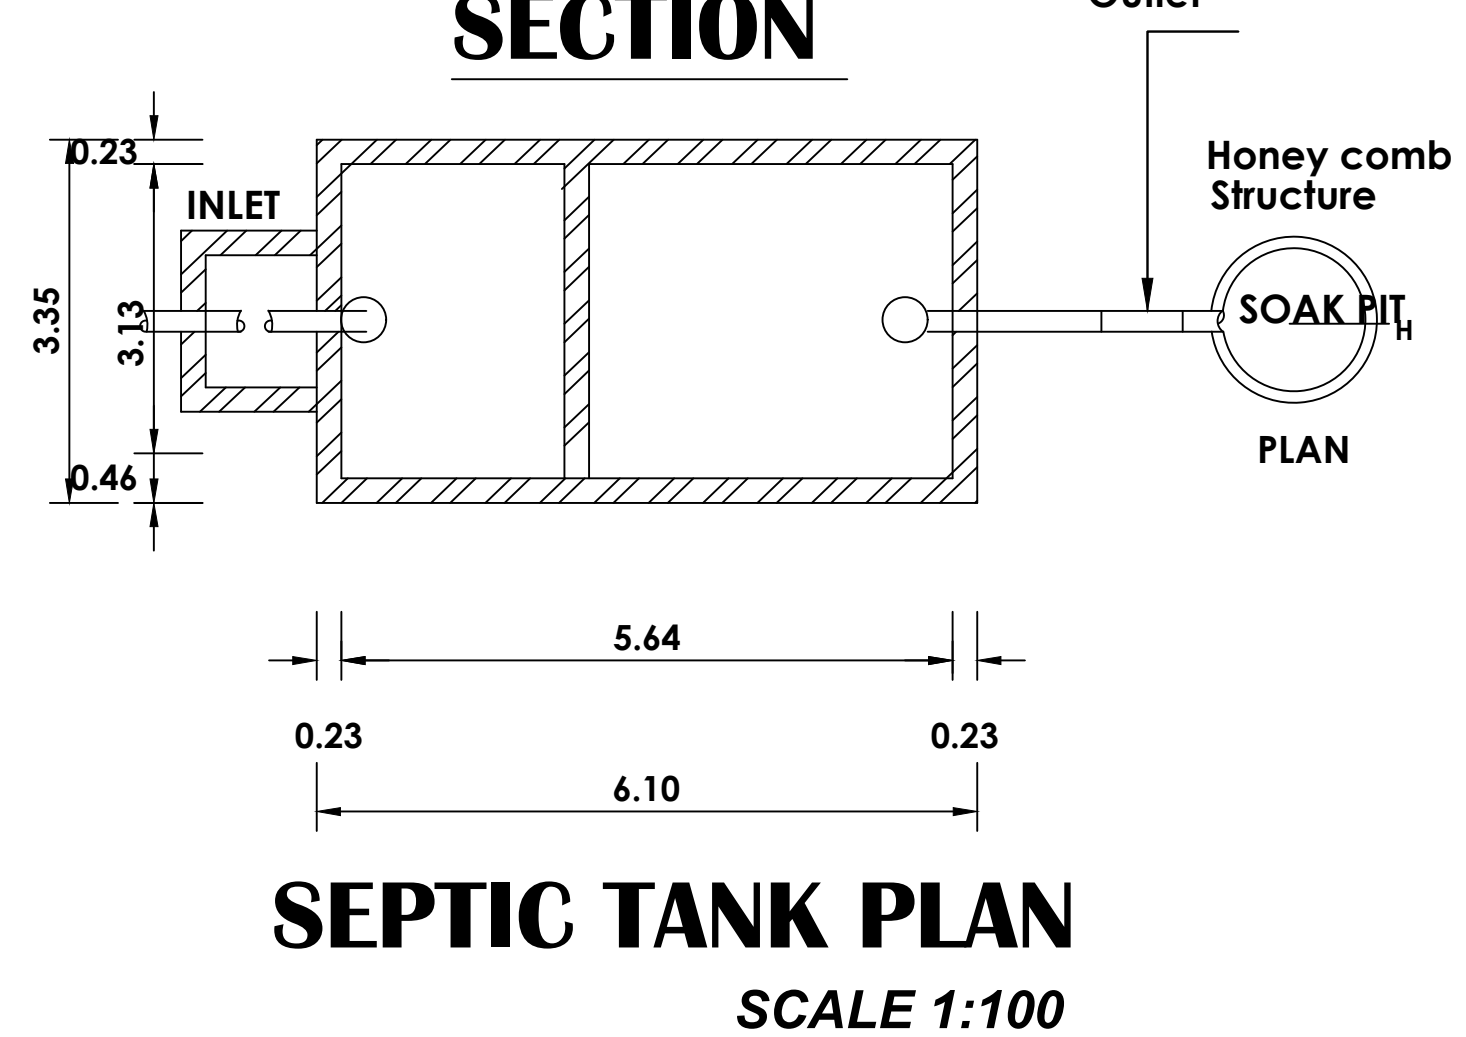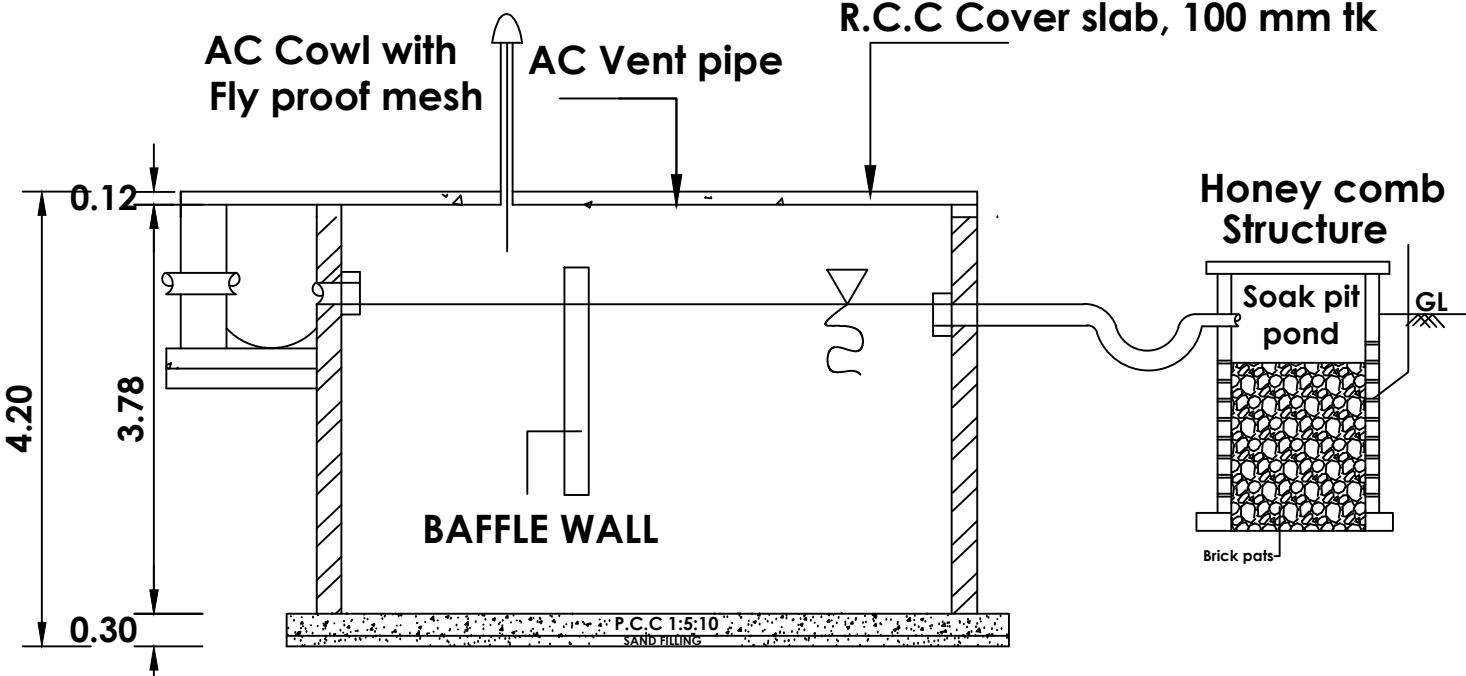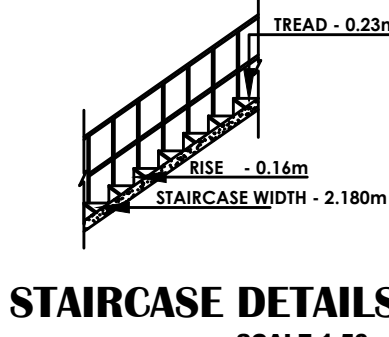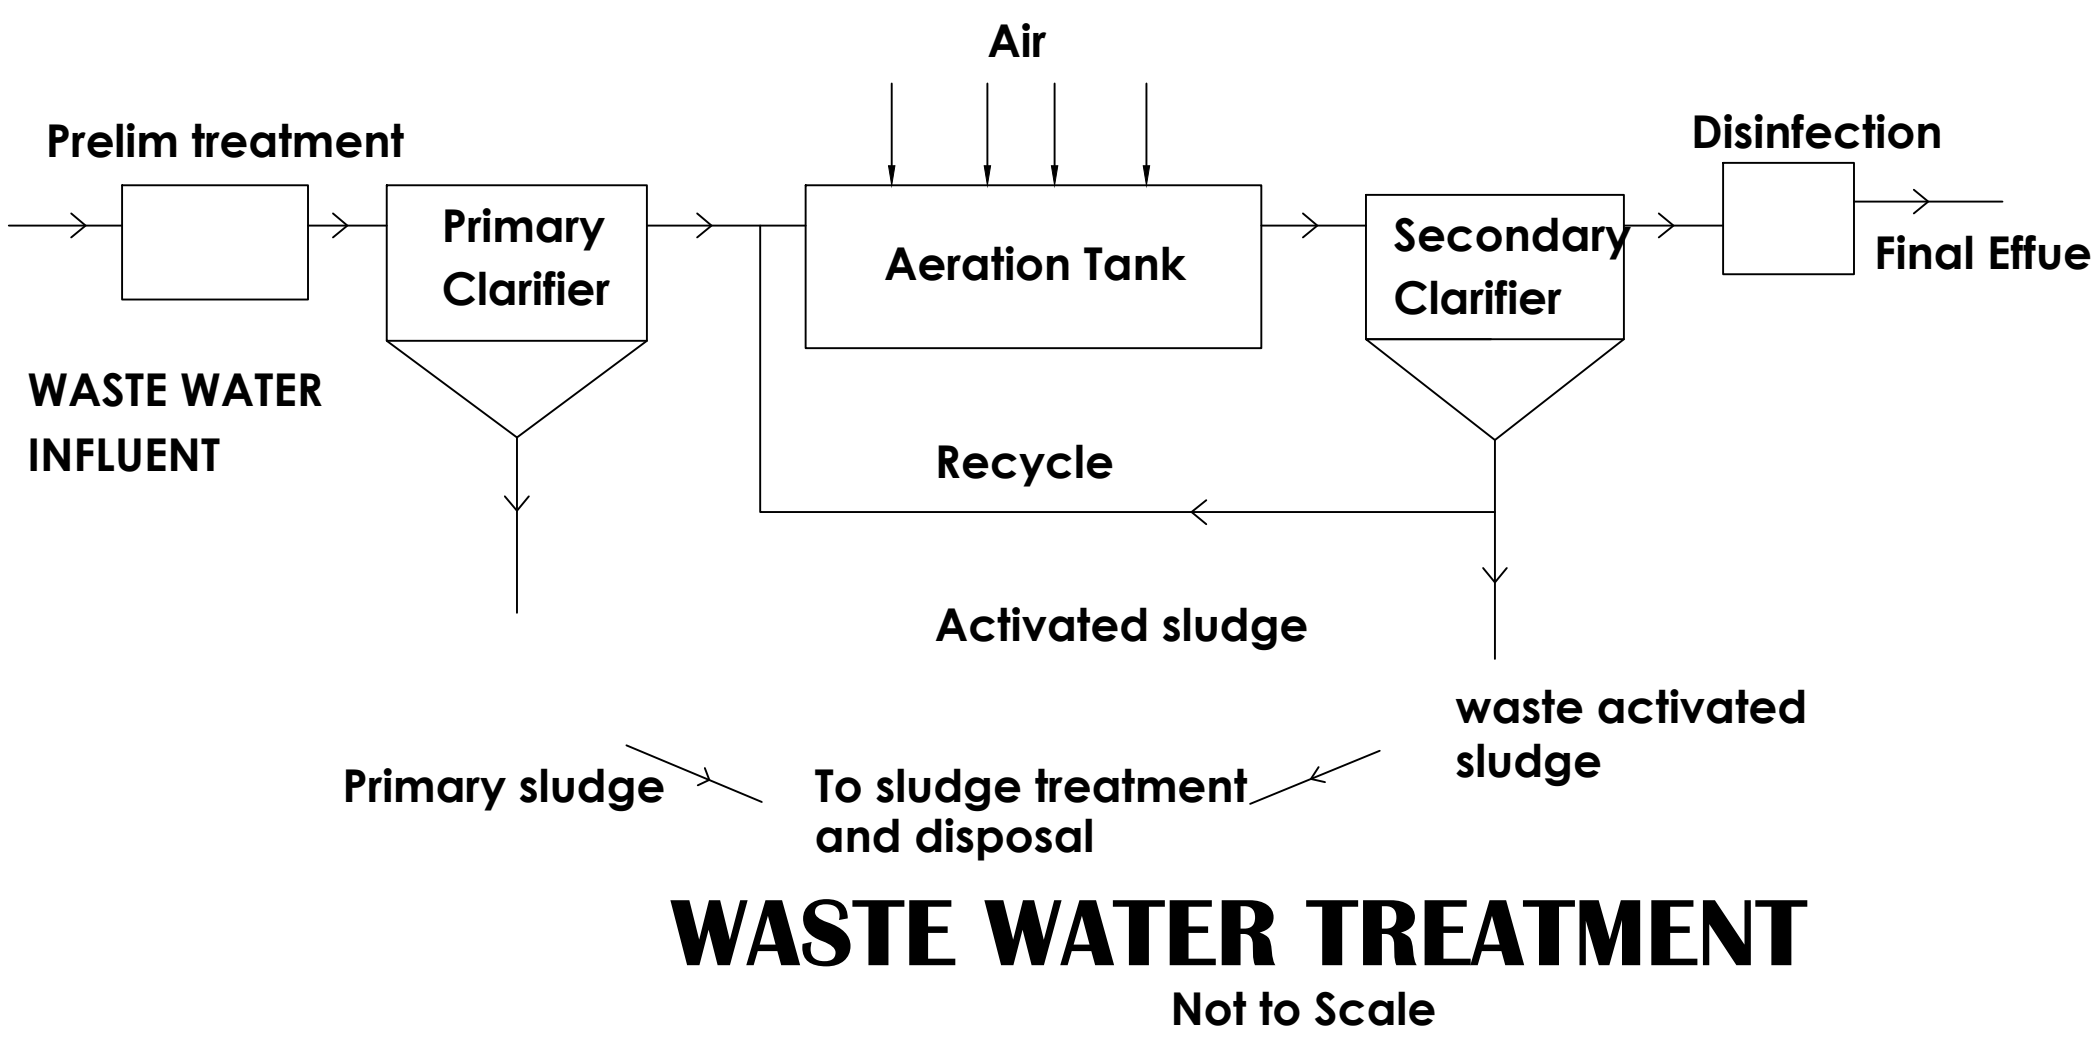

OFFICE USE

Signature Not Verified
Stamp Not Verified
Date 2023.11.01