
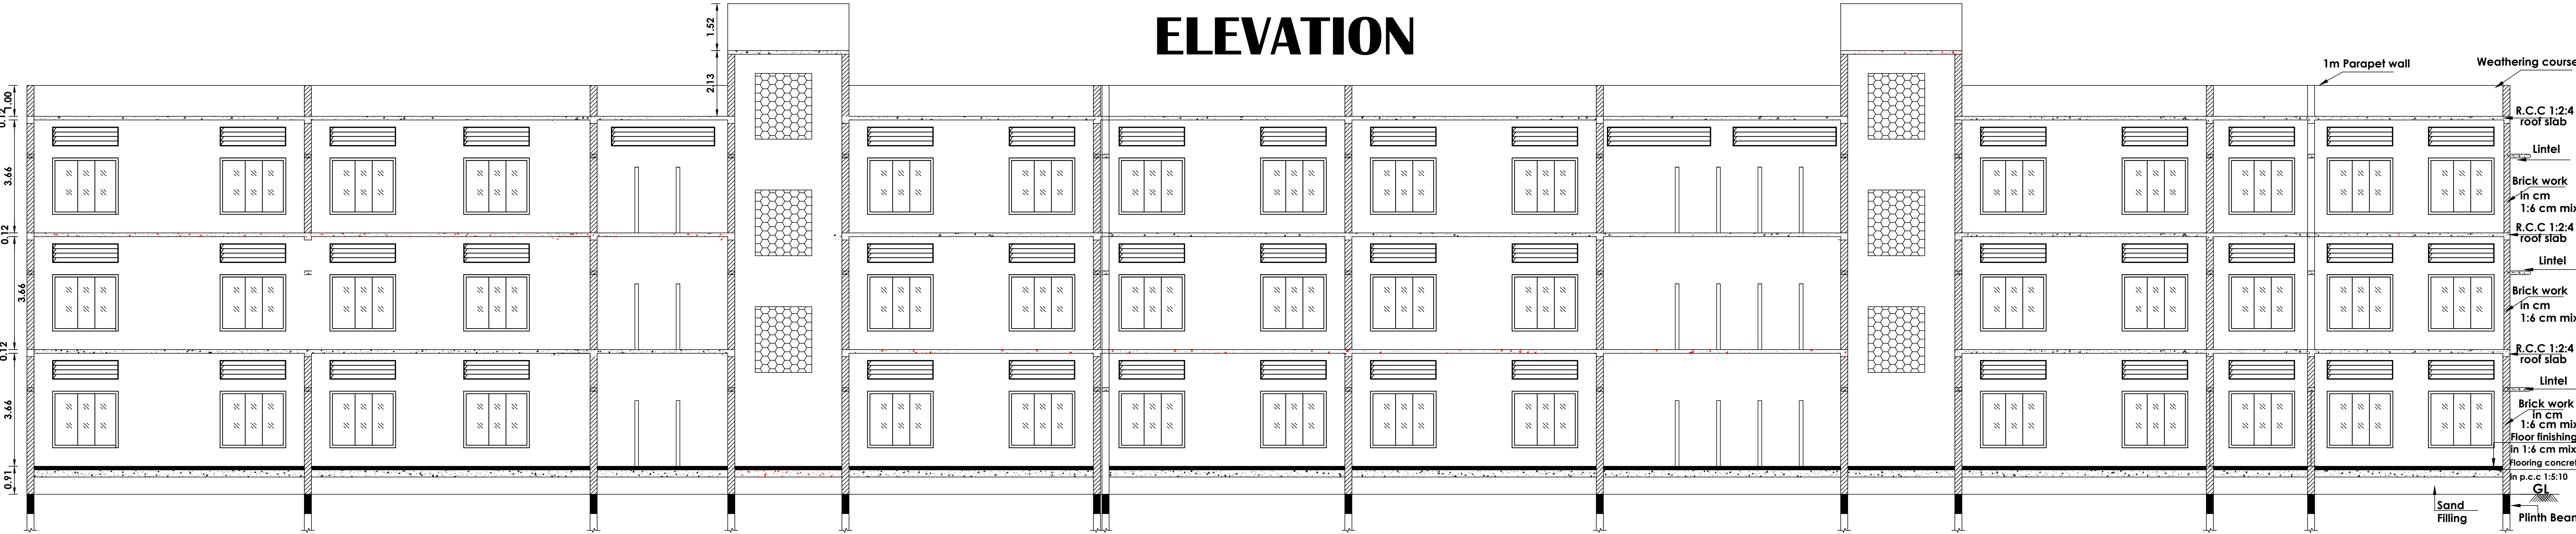


PLAN SHOWING THE RCC ROOF PROPOSED CONSTRUCTION OF SCHOOL BUILDING FOR " M/S JAYAPRIYA VIDYALAYA MATRIC.HIGHER SECONDARY SCHOOL " AT OLD R.S.NO. 47/1H1C, NEW S.F.NO:47/24, 47/25 IN VADAKUTHU VILLAGE, KURINJIPADI PANCHAYAT UNION, KURINJIPADI TALUK, CUDDALORE DISTRICT.


APPLICANT NAME: JAYAPRIYA EDUCATIONAL TRUST.

ALL DIMENSIONS ARE IN METER


SCALE 1:100

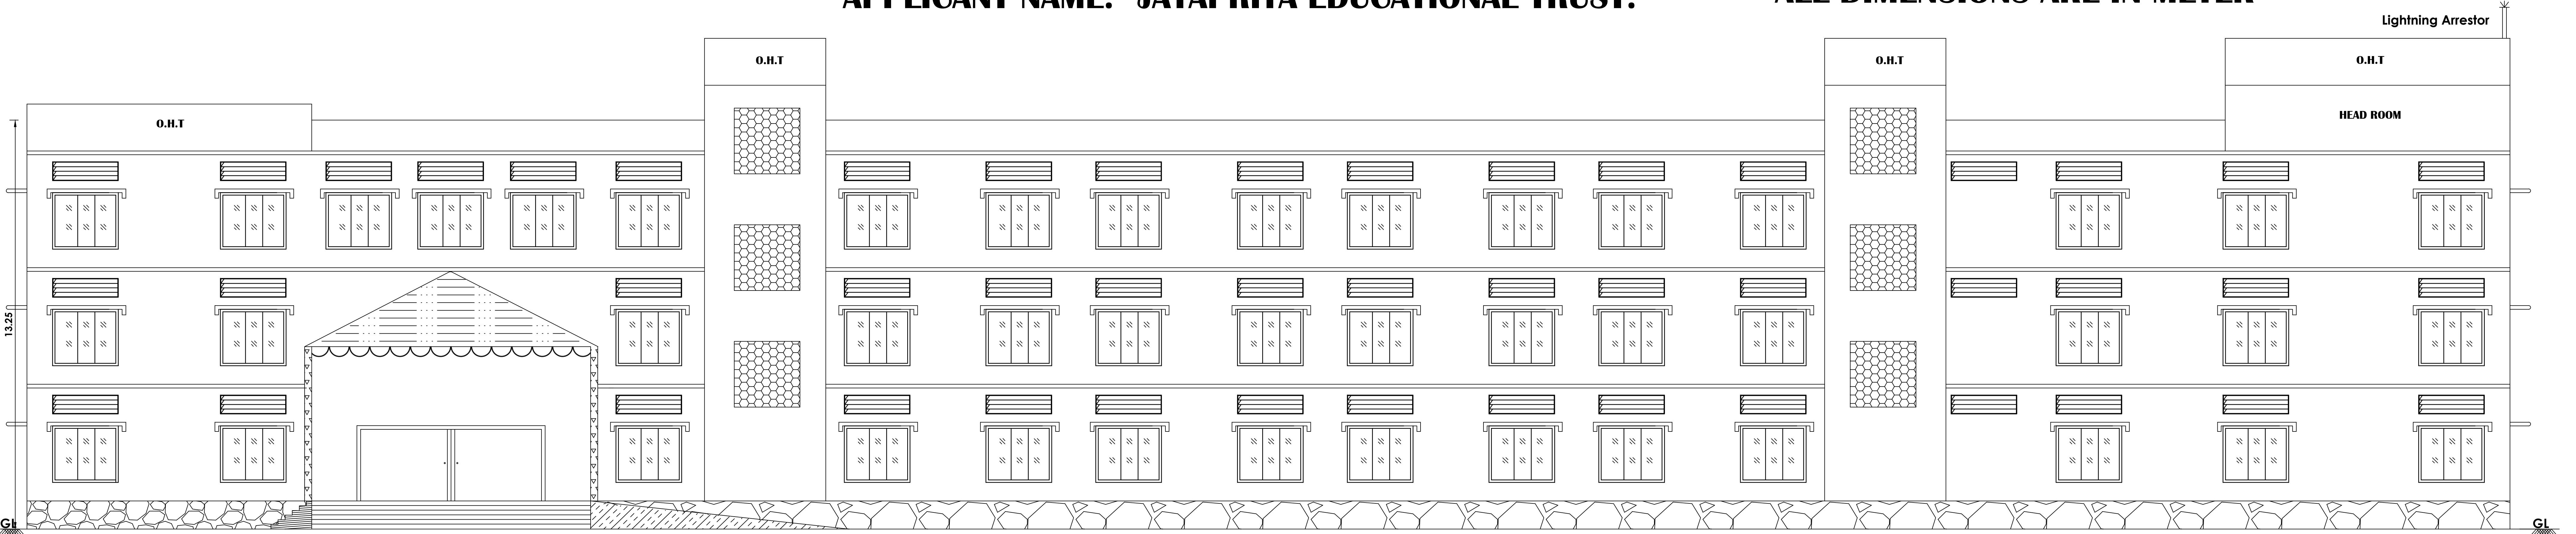


JOINERY DETAILS		
V1	VENTILATOR	3.35 x 0.61
MD	MAIN DOOR	6.10 x 2.44
D	DOOR	1.22 x 2.44
D1	DOOR -1	0.91 x 2.44
D2	DOOR -2	0.76 x 2.13
W	WINDOW	2.13 x 1.83
V	VENTILATOR	2.13 x 0.61
V2	VENTILATOR	2.44 x 0.61
JW	JOLLY WORK	2.13 x 2.44
FA	▽ FIRE ALARM	
FE	△ FIRE EXTINGUISHERS.	
FHR	○ Fire Hose Reel	
EF	⊗ Exhaust Fan With 0.46 Dia	

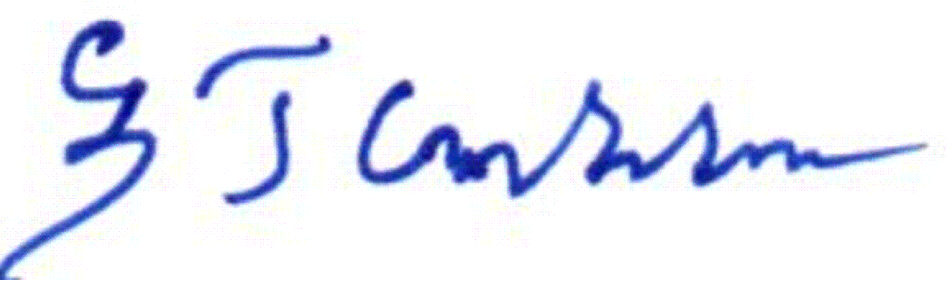

APPLICANT

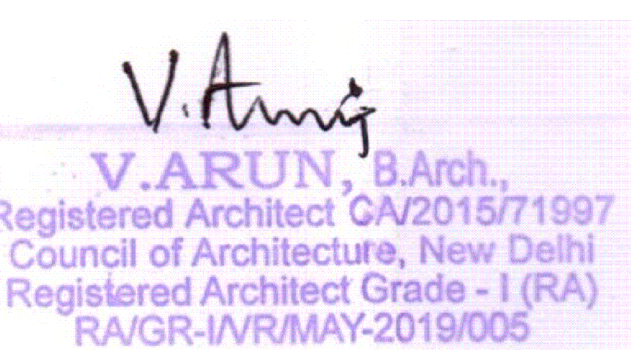

ARCHITECT

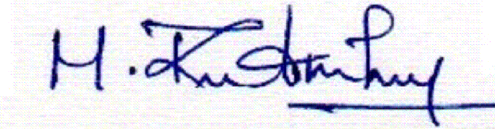

ENGINEER



ENGINEER



STRUCTURAL



STRUCTURAL



OFFICE USE

B.P/DTCP NO: 454/ 2023

JOINERY DETAILS

Pro. Staircase Head Area - 181.36 Sq.m

SCALE 1:100

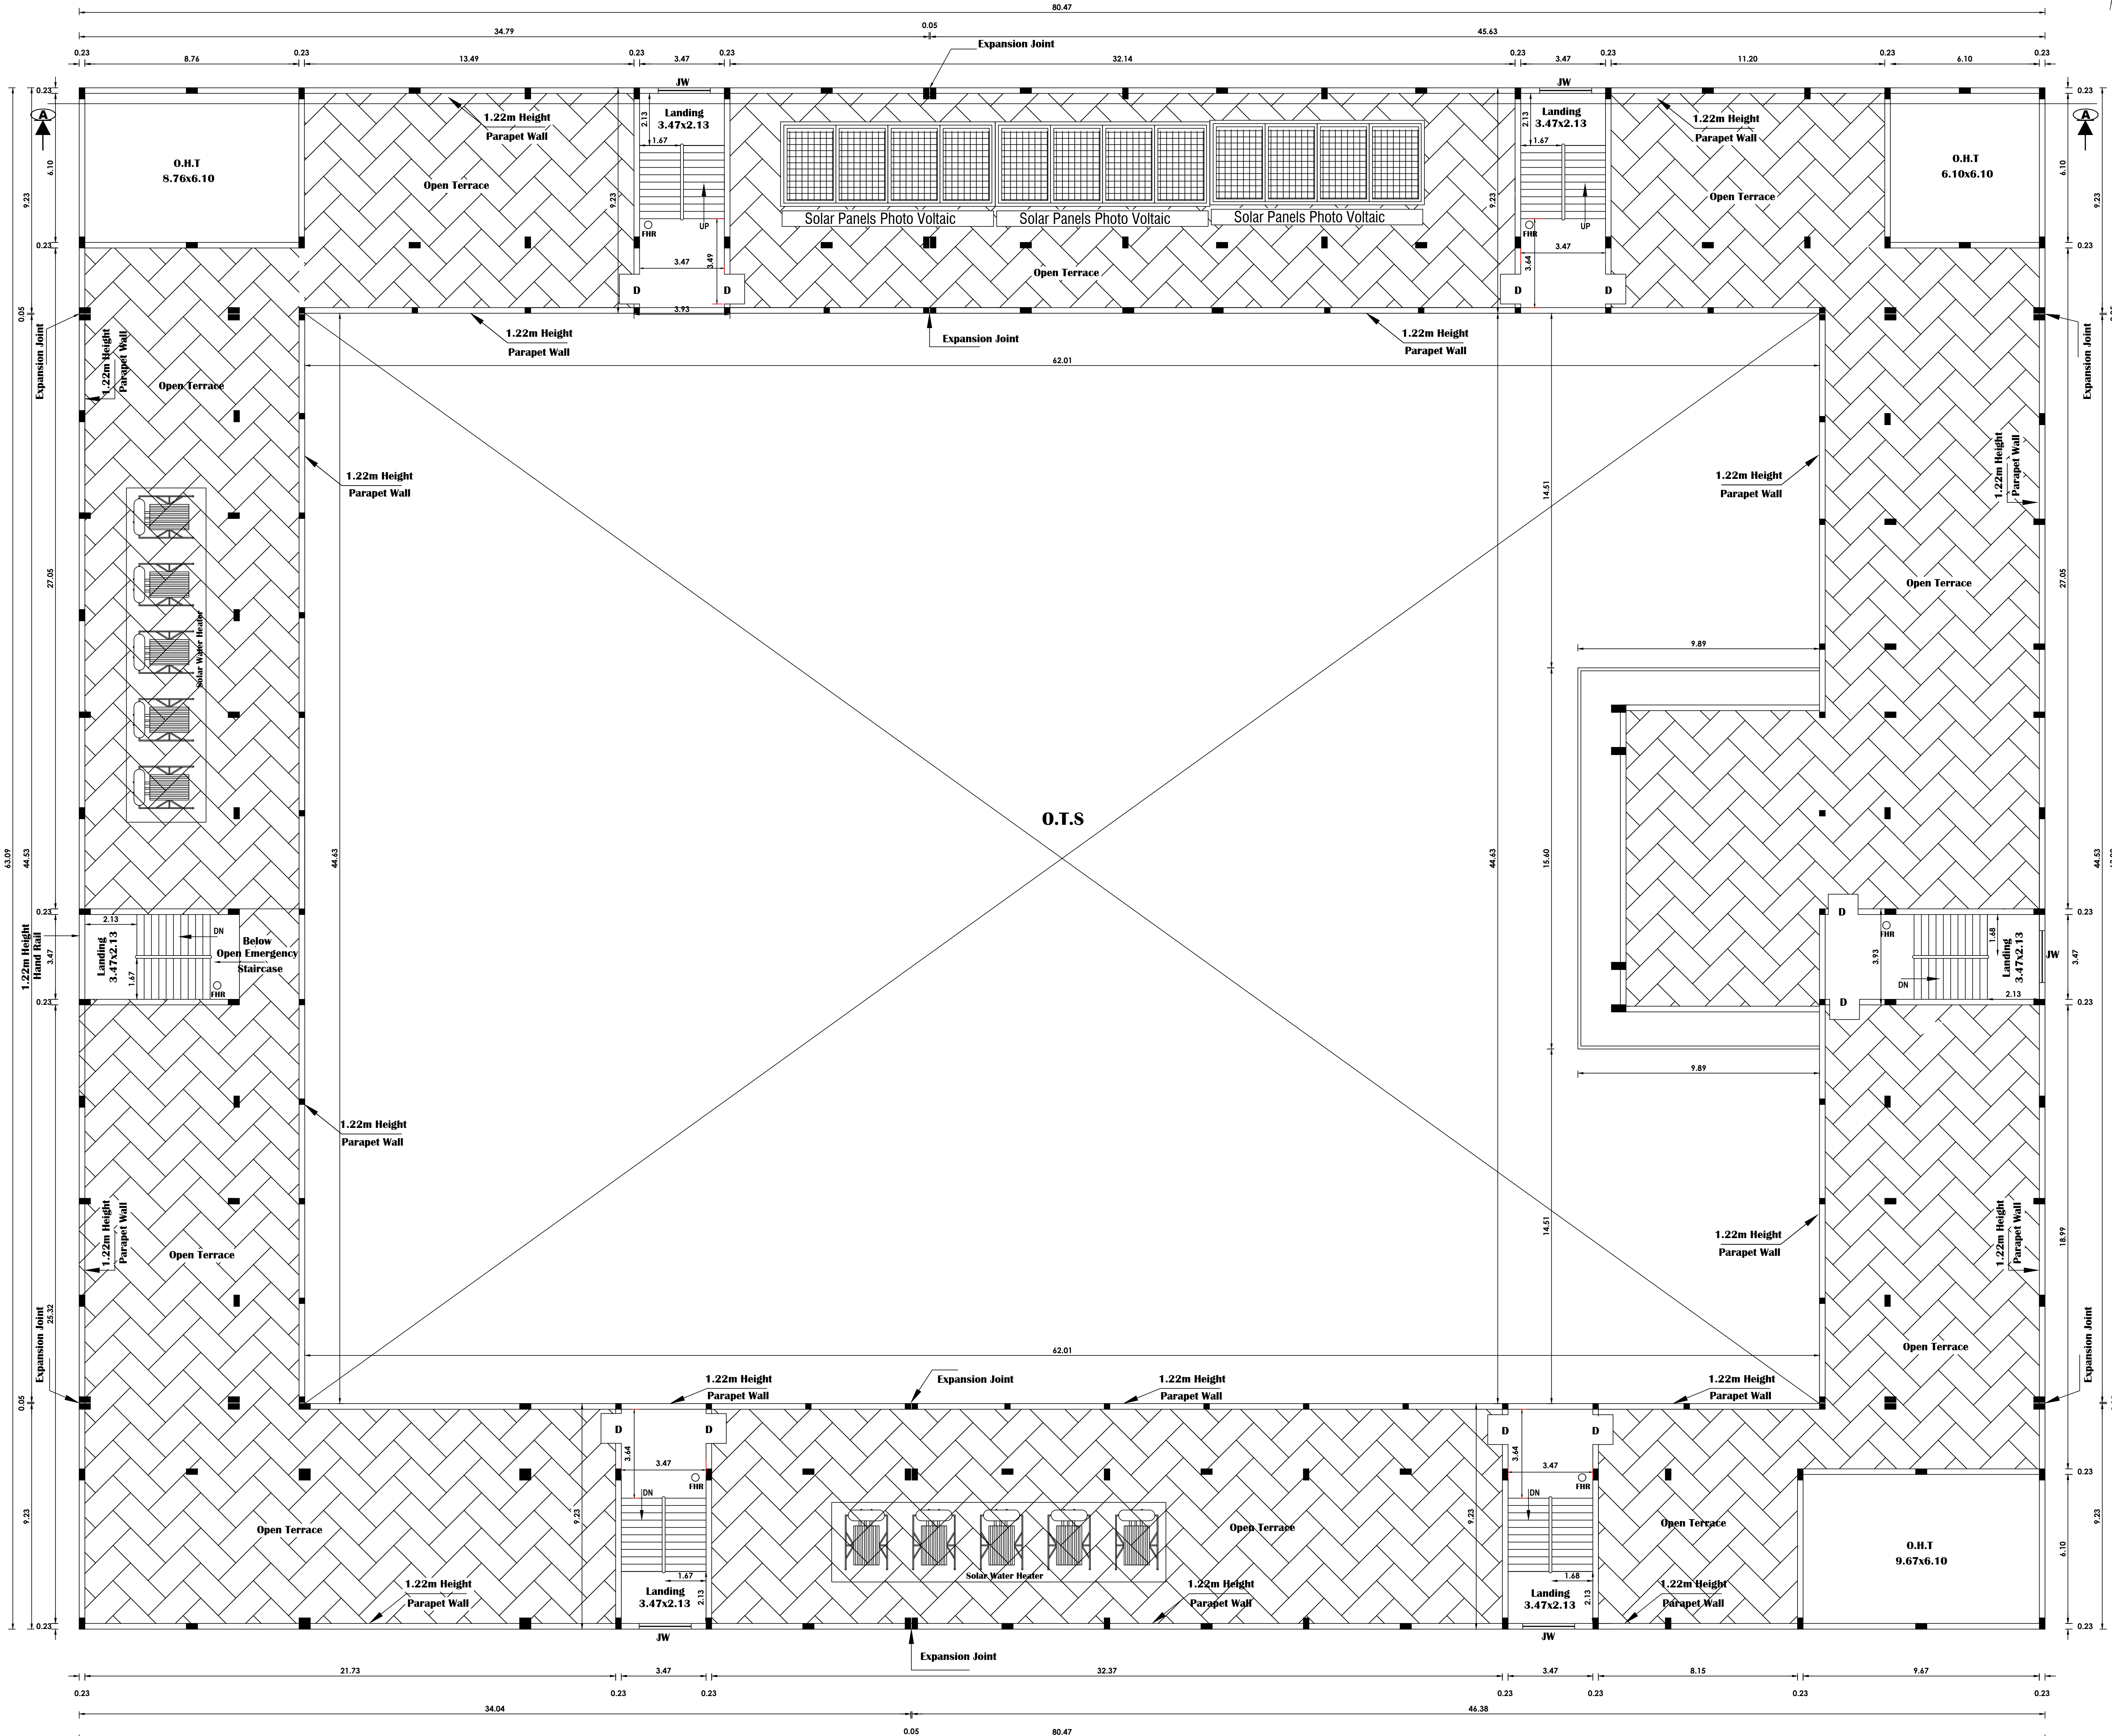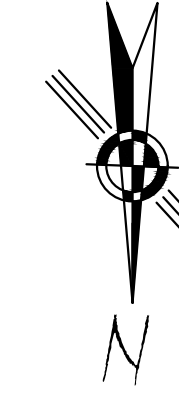

TERRACE FLOOR PLAN

MD	MAIN DOOR	6.10 x 2.44
D	DOOR	1.22 x 2.44
D1	DOOR -1	0.91 x 2.44
D2	DOOR -2	0.76 x 2.13
W	WINDOW	2.13 x 1.83
V	VENTILATOR	2.13 x 0.61
V1	VENTILATOR	3.35 x 0.61
V2	VENTILATOR	2.44 x 0.61
JW	JOLLY WORK	2.13 x 2.44
SD	SLIDE DOOR	1.00 x 2.44
FA	 FIRE ALARM	
FE	 FIRE EXTINGUISHERS.	
FHR	 Fire Hose Reel	
EF	 Exhaust Fan With 0.46 Dia	
PCP	-PHYSICALLY CHALLENGED	

APPLICANT

V. Arun
V. ARUN, B.Arch.,
Registered Architect CA/2015/71997
Council of Architecture, New Delhi
Registered Architect Grade - I (RA)
RA/GR-IVR/MAY-2019/005

ARCHITECT

PCP -PHYSICALLY CHALLENGED PERSON

Er. M. REVATHY, B.E.,
Regd.Engineer Grade-II(RE)
DTCP Reg.No. RE/GR.II/YD/AUGUST-2022/062
RE/GR.II/YD/AUGUST-2022/062
No.47, Ground Floor,Guber Plaza, Trichy Main Road,
Villupuram - 605 602. Ph:96777 43344.

ENGINEER

Er. K.G. Manivachakam
B.E., M.I.E, F.I.V. C. ENGB
Reg No: M2/80777/96
Registered Structural Engineer Grade - II (RSE)
RSE/GR.II/VR/MAY-2019/007
(UNDER TNGDS RULES)
Chartered Engineer, Approved Valuer
Class- 1A - Registered Engineer
Collectorate Panel Engineer
(under Tamilnadu Public Building Act)
D. No: 3/201 First Cross Street Friends Nagar
Semmandalam. Cuddalore - 607 001

STRUCTURAL

B.P/DTCP NO: 454/ 2023


OFFICE USE

PLAN SHOWING THE RCC ROOF PROPOSED CONSTRUCTION OF SCHOOL BUILDING FOR " M/S JAYAPRIYA VIDYALAYA MATRIC.HIGHER SECONDARY SCHOOL " AT OLD R.S.NO. 47/1H1C, NEW S.F.NO:47/24, 47/25 IN VADAKUTHU VILLAGE, KURINJIPADI PANCHAYAT UNION, KURINJIPADI TALUK, CUDDALORE DISTRICT.

APPLICANT NAME: JAYAPRIYA EDUCATIONAL TRUST.

ALL DIMENSIONS ARE IN METER

SCALE 1:100

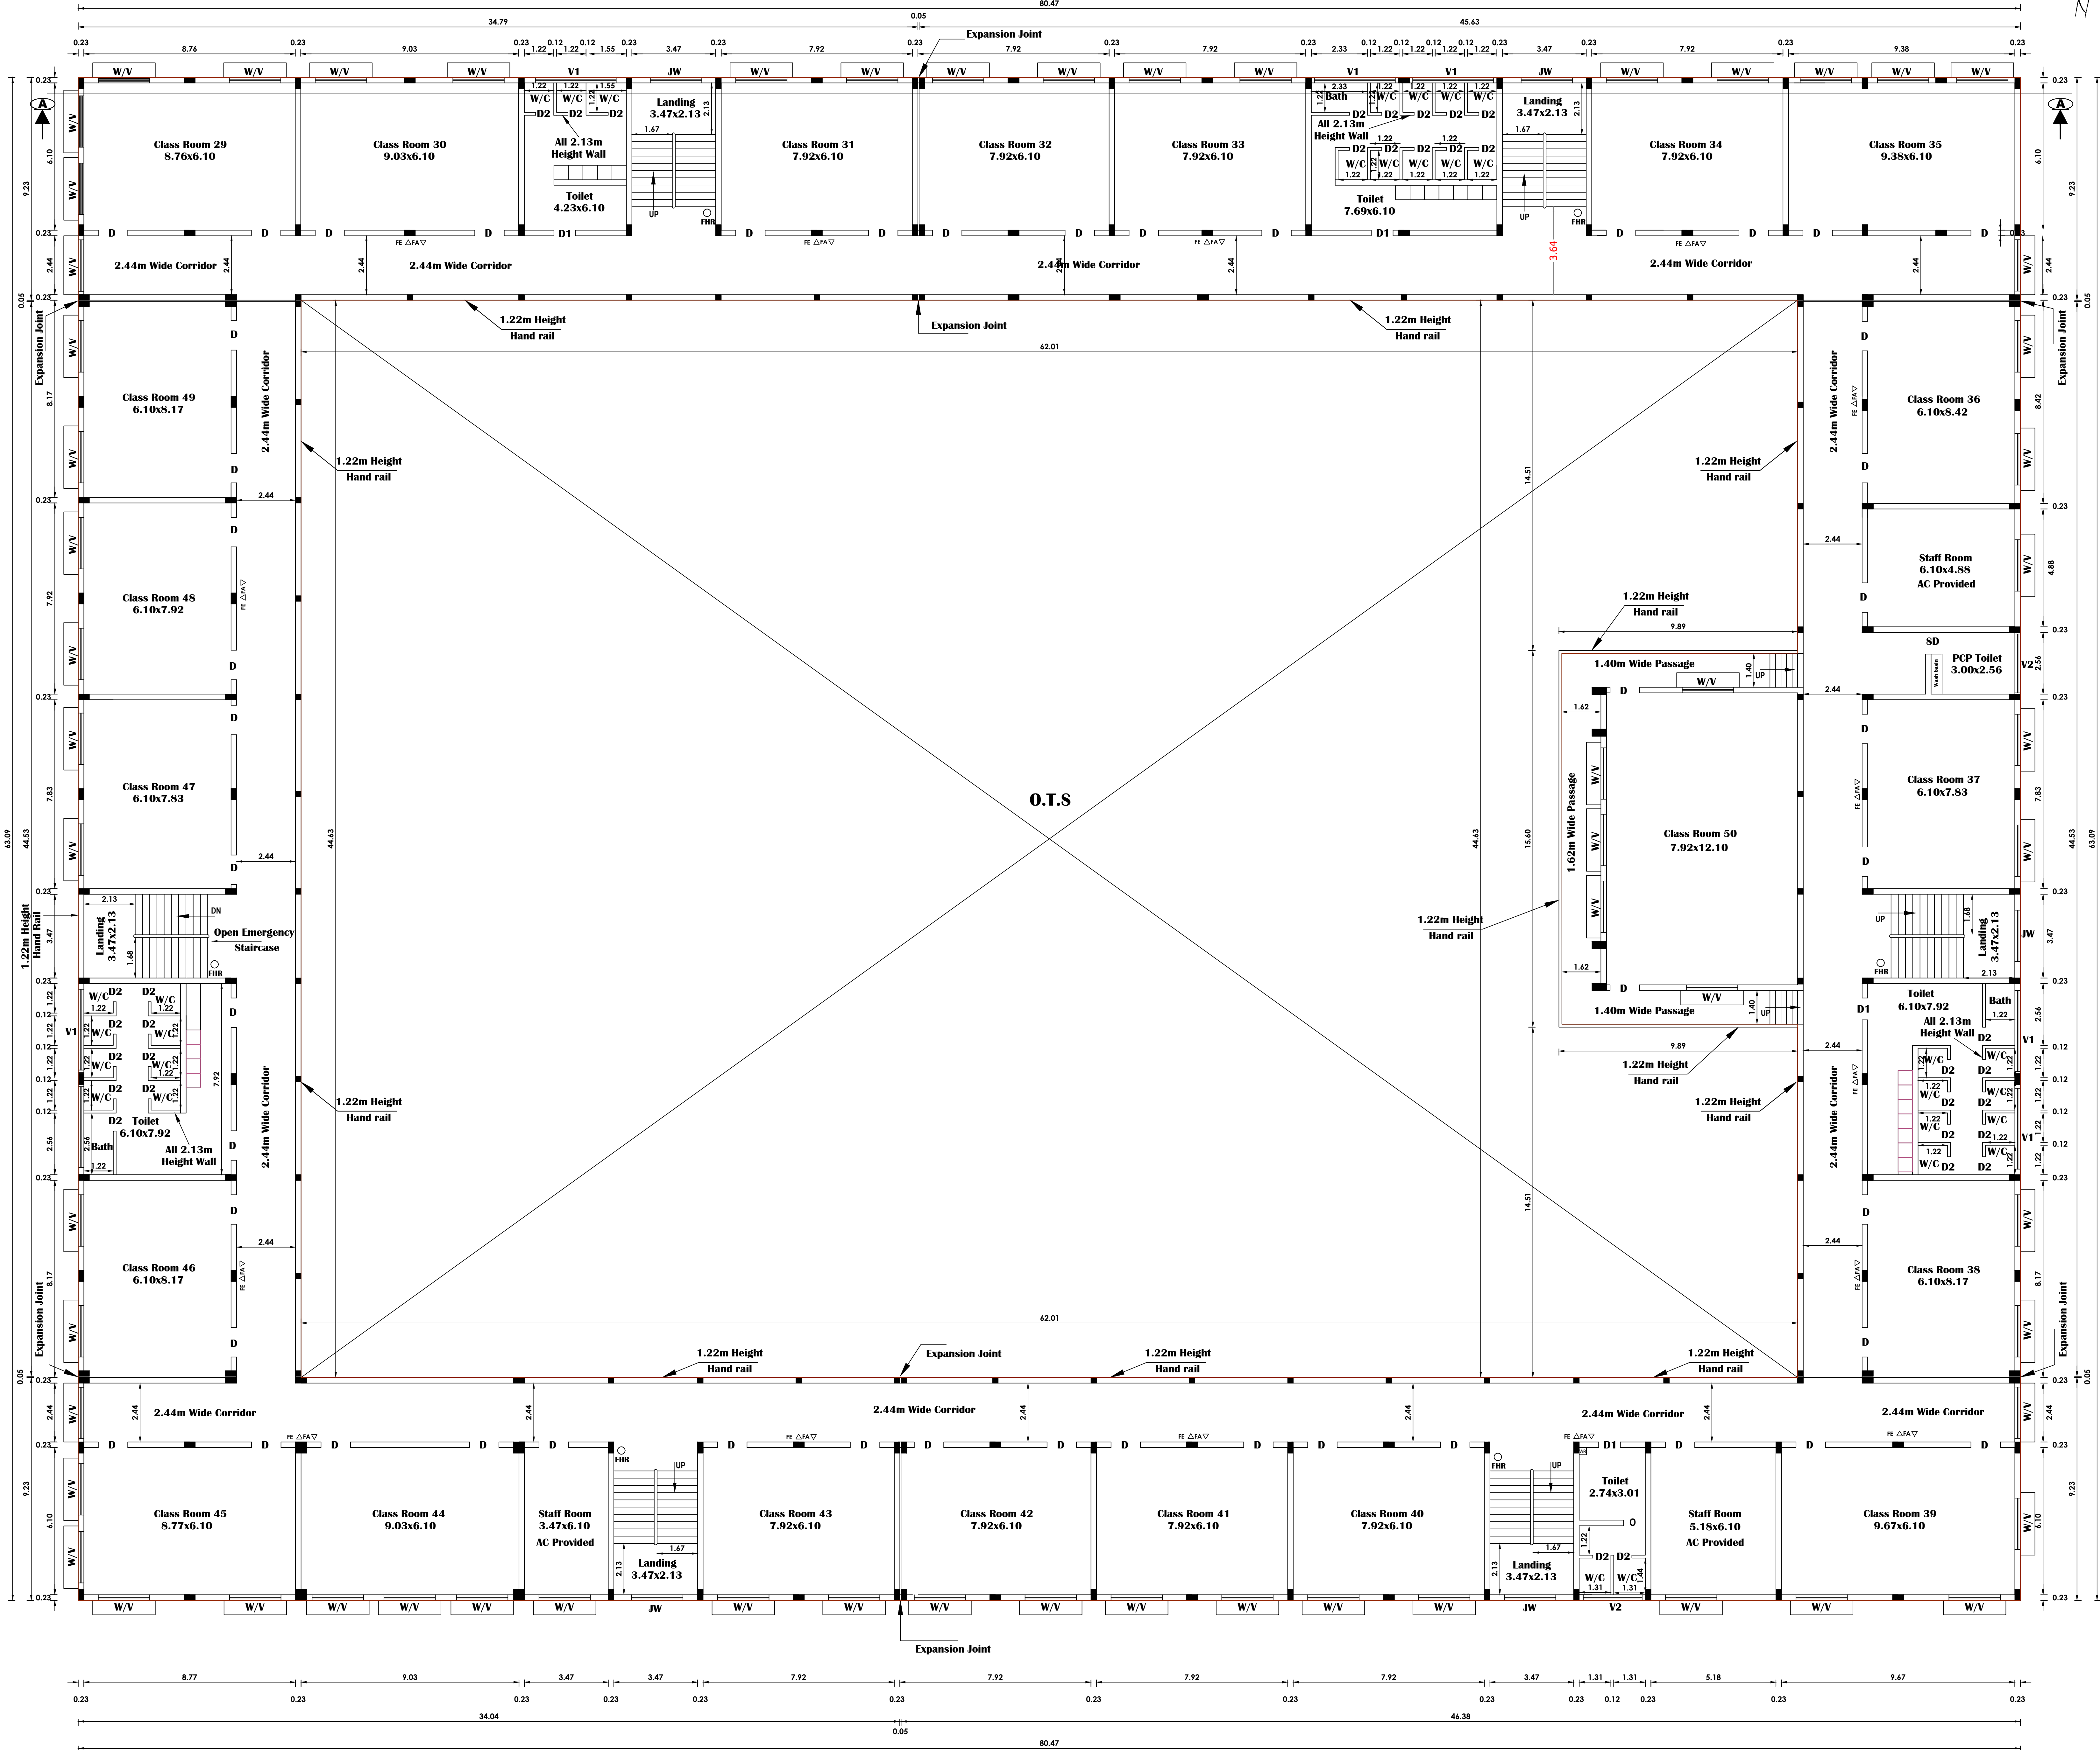

SECOND FLOOR PLAN

JOINERY DETAILS

SCALE 1:100 SHEET No. 4/6

MD	MAIN DOOR	6.10 x 2.44
D	DOOR	1.22 x 2.44
D1	DOOR -1	0.91 x 2.44
D2	DOOR -2	0.76 x 2.13
W	WINDOW	2.13 x 1.83
V	VENTILATOR	2.13 x 0.61
V1	VENTILATOR	3.35 x 0.61
V2	VENTILATOR	2.44 x 0.61
JW	JOLLY WORK	2.13 x 2.44
SD	SLIDE DOOR	1.00 x 2.44
FA	▽ FIRE ALARM	
FE	△ FIRE EXTINGUISHERS.	
FHR	Fire Hose Reel	
EF	⊗ Exhaust Fan With 0.46 Dia	
PCP	-PHYSICALLY CHALLENGED PERSON	

APPLICANT

V. Arun
V. ARUN, B.Arch.,
Registered Architect GA/2015/71997
Council of Architecture, New Delhi
Registered Architect Grade - I (RA)
RA/GR-IVR/MAY-2019/005

ARCHITECT

H. Revathy
Er. M. REVATHY, B.E.,
Regd.Engineer Grade-II(RE)
DTCP Reg.No. RE/GR.II/VD/AUGUST-2022/062
RE/GR.II/VD/AUGUST-2022/062
No.47, Ground Floor,Guber Plaza, Trichy Main Road,
Villupuram - 605 602. Ph:96777 43344.

ENGINEER

K. G. Manivachakam
B.E.,M.I.E.F.I.V. C. ENGB
Reg No: M2/80777/98
Registered Structural Engineer Grade - II(RSE)
RSE/GR.II/VR/MAY-2019/007
(UNDER TNCD B RULES)
Chartered Engineer, Approved Valuer
Class-1A - Registered Engineer
Collectorate Panel Building Act)
D. No: 3/201 First Cross Street Friends Nagar
Semmandalam. Cuddalore - 607 001.

STRUCTURAL

B.P/DTCP NO: 454/ 2023


OFFICE USE

PLAN SHOWING THE RCC ROOF PROPOSED CONSTRUCTION OF SCHOOL BUILDING FOR " M/S JAYAPRIYA VIDYALAYA MATRIC.HIGHER SECONDARY SCHOOL " AT OLD R.S.NO. 47/1H1C, NEW S.F.NO:47/24, 47/25 IN VADAKUTHU VILLAGE, KURINJIPADI PANCHAYAT UNION, KURINJIPADI TALUK, CUDDALORE DISTRICT.

APPLICANT NAME: JAYAPRIYA EDUCATIONAL TRUST.

ALL DIMENSIONS ARE IN METER

SCALE 1:100

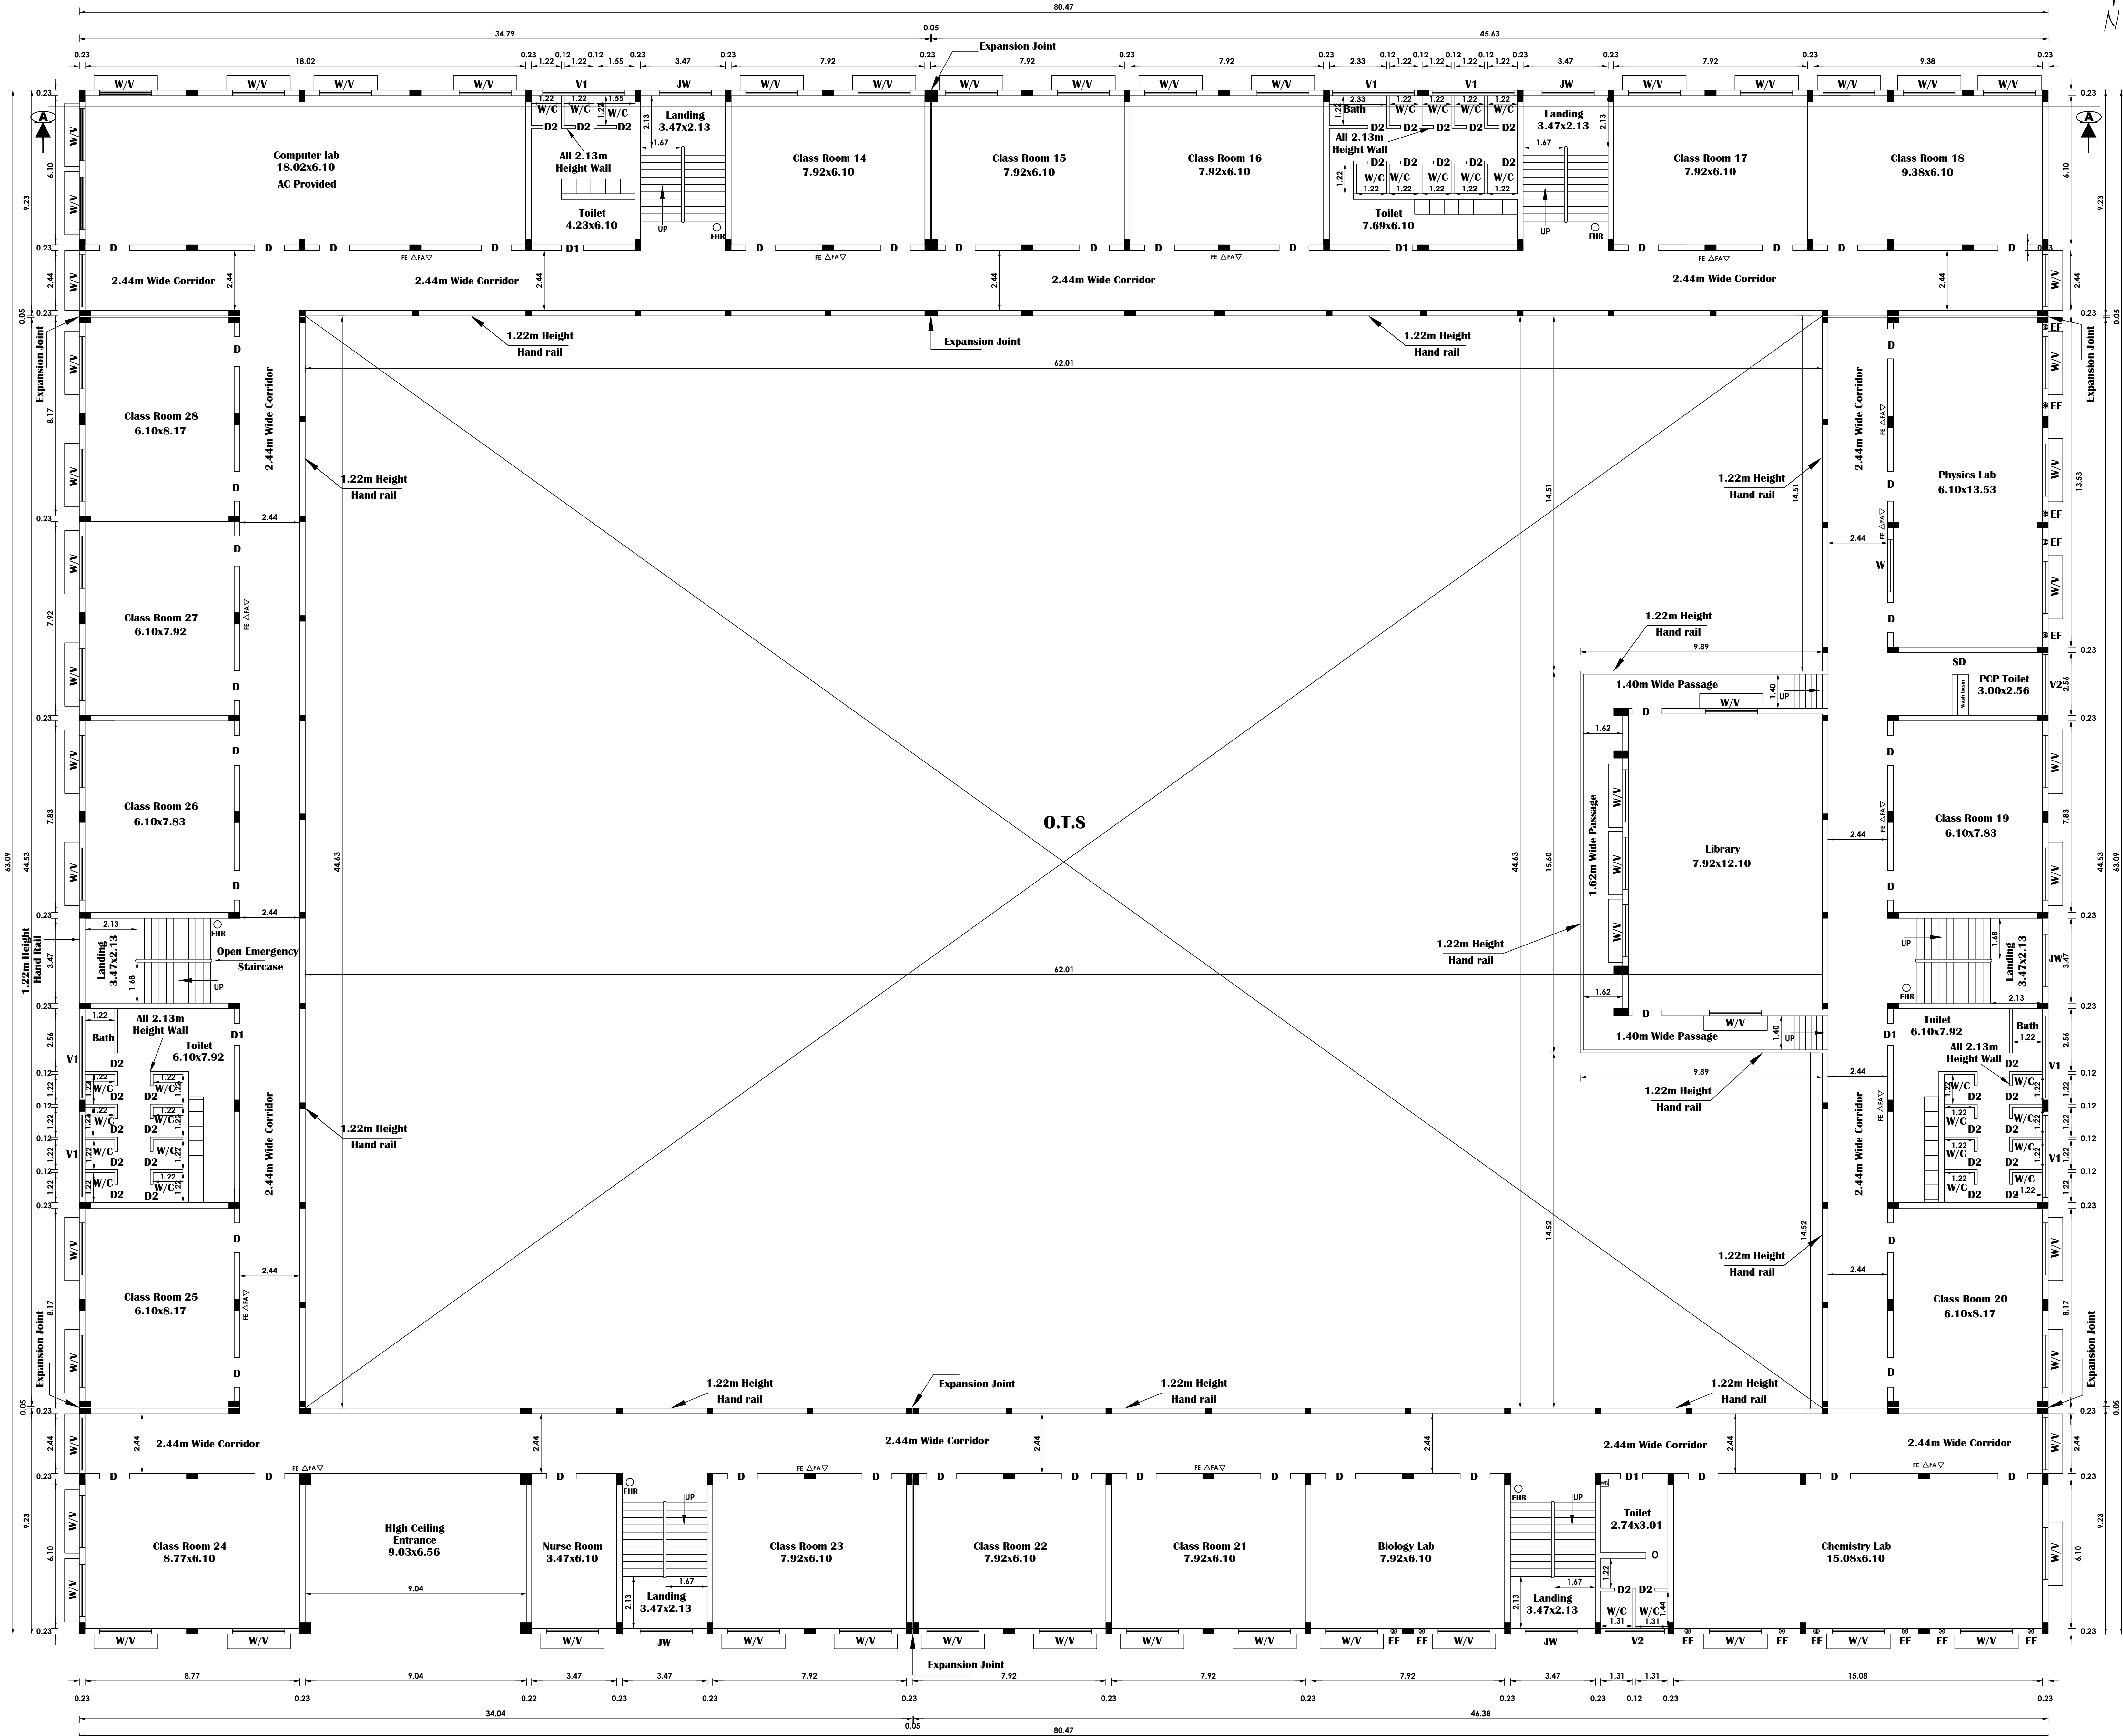

FIRST FLOOR PLAN

JOINERY DETAILS

SCALE 1:100 SHEET No. 3/6

MD	MAIN DOOR	6.10 x 2.44
D	DOOR	1.22 x 2.44
D1	DOOR -1	0.91 x 2.44
D2	DOOR -2	0.76 x 2.13
W	WINDOW	2.13 x 1.83
V	VENTILATOR	2.13 x 0.61
V1	VENTILATOR	3.35 x 0.61
V2	VENTILATOR	2.44 x 0.61
JW	JOLLY WORK	2.13 x 2.44
SD	SLIDE DOOR	1.00 x 2.44

APPLICANT

V. Arun
V. ARUN, B.Arch.,
Registered Architect GA/2015/71997
Council of Architecture, New Delhi
Registered Architect Grade - I (RA)
RA/GR-IVR/MAY-2019/005

ARCHITECT

FA ▽ FIRE ALARM

FE △ FIRE EXTINGUISHERS.

FHR ○ Fire Hose Reel

EF ⊗ Exhaust Fan With 0.46 Dia

PCP -PHYSICALLY CHALLENGED PERSON

M. Revathy
Er. M. REVATHY, B.E.,
Regd.Engineer Grade-II(RE)
DTCP Reg.No, RE/GR.II/VD/AUGUST-2022/062
RE/GR.II/VD/AUGUST-2022/062
No.47, Ground Floor,Guber Plaza, Trichy Main Road,
Villupuram - 605 602. Ph:96777 43344.

ENGINEER

K.G. Manivachakam
Er. K.G. Manivachakam
B.E.,M.I.E.F I V. C. ENGE
Reg NO: M2/80777/96
Registered Structural Engineer Grade - II(RSE)
RSE/GR.II/VR/MAY-2019/007
(UNDER TNCD B RULES)
Chartered Engineer, Approved Valuer
Class- 1A - Registered Engineer
Collectorate Panel Engineer
(under Tamilnadu Public Building Act)
D. No: 3/201 First Cross Street Friends Nagar
Semmandalam. Cuddalore - 607 001.

STRUCTURAL

B.P/DTCP NO: 454/ 2023


OFFICE USE

PLAN SHOWING THE RCC ROOF PROPOSED CONSTRUCTION OF SCHOOL BUILDING FOR " M/S JAYAPRIYA VIDYALAYA MATRIC.HIGHER SECONDARY SCHOOL " AT OLD R.S.NO. 47/1H1C, NEW S.F.NO:47/24, 47/25 IN VADAKUTHU VILLAGE, KURINJIPADI PANCHAYAT UNION, KURINJIPADI TALUK, CUDDALORE DISTRICT.

APPLICANT NAME: JAYAPRIYA EDUCATIONAL TRUST.

ALL DIMENSIONS ARE IN METER

SCALE 1:100

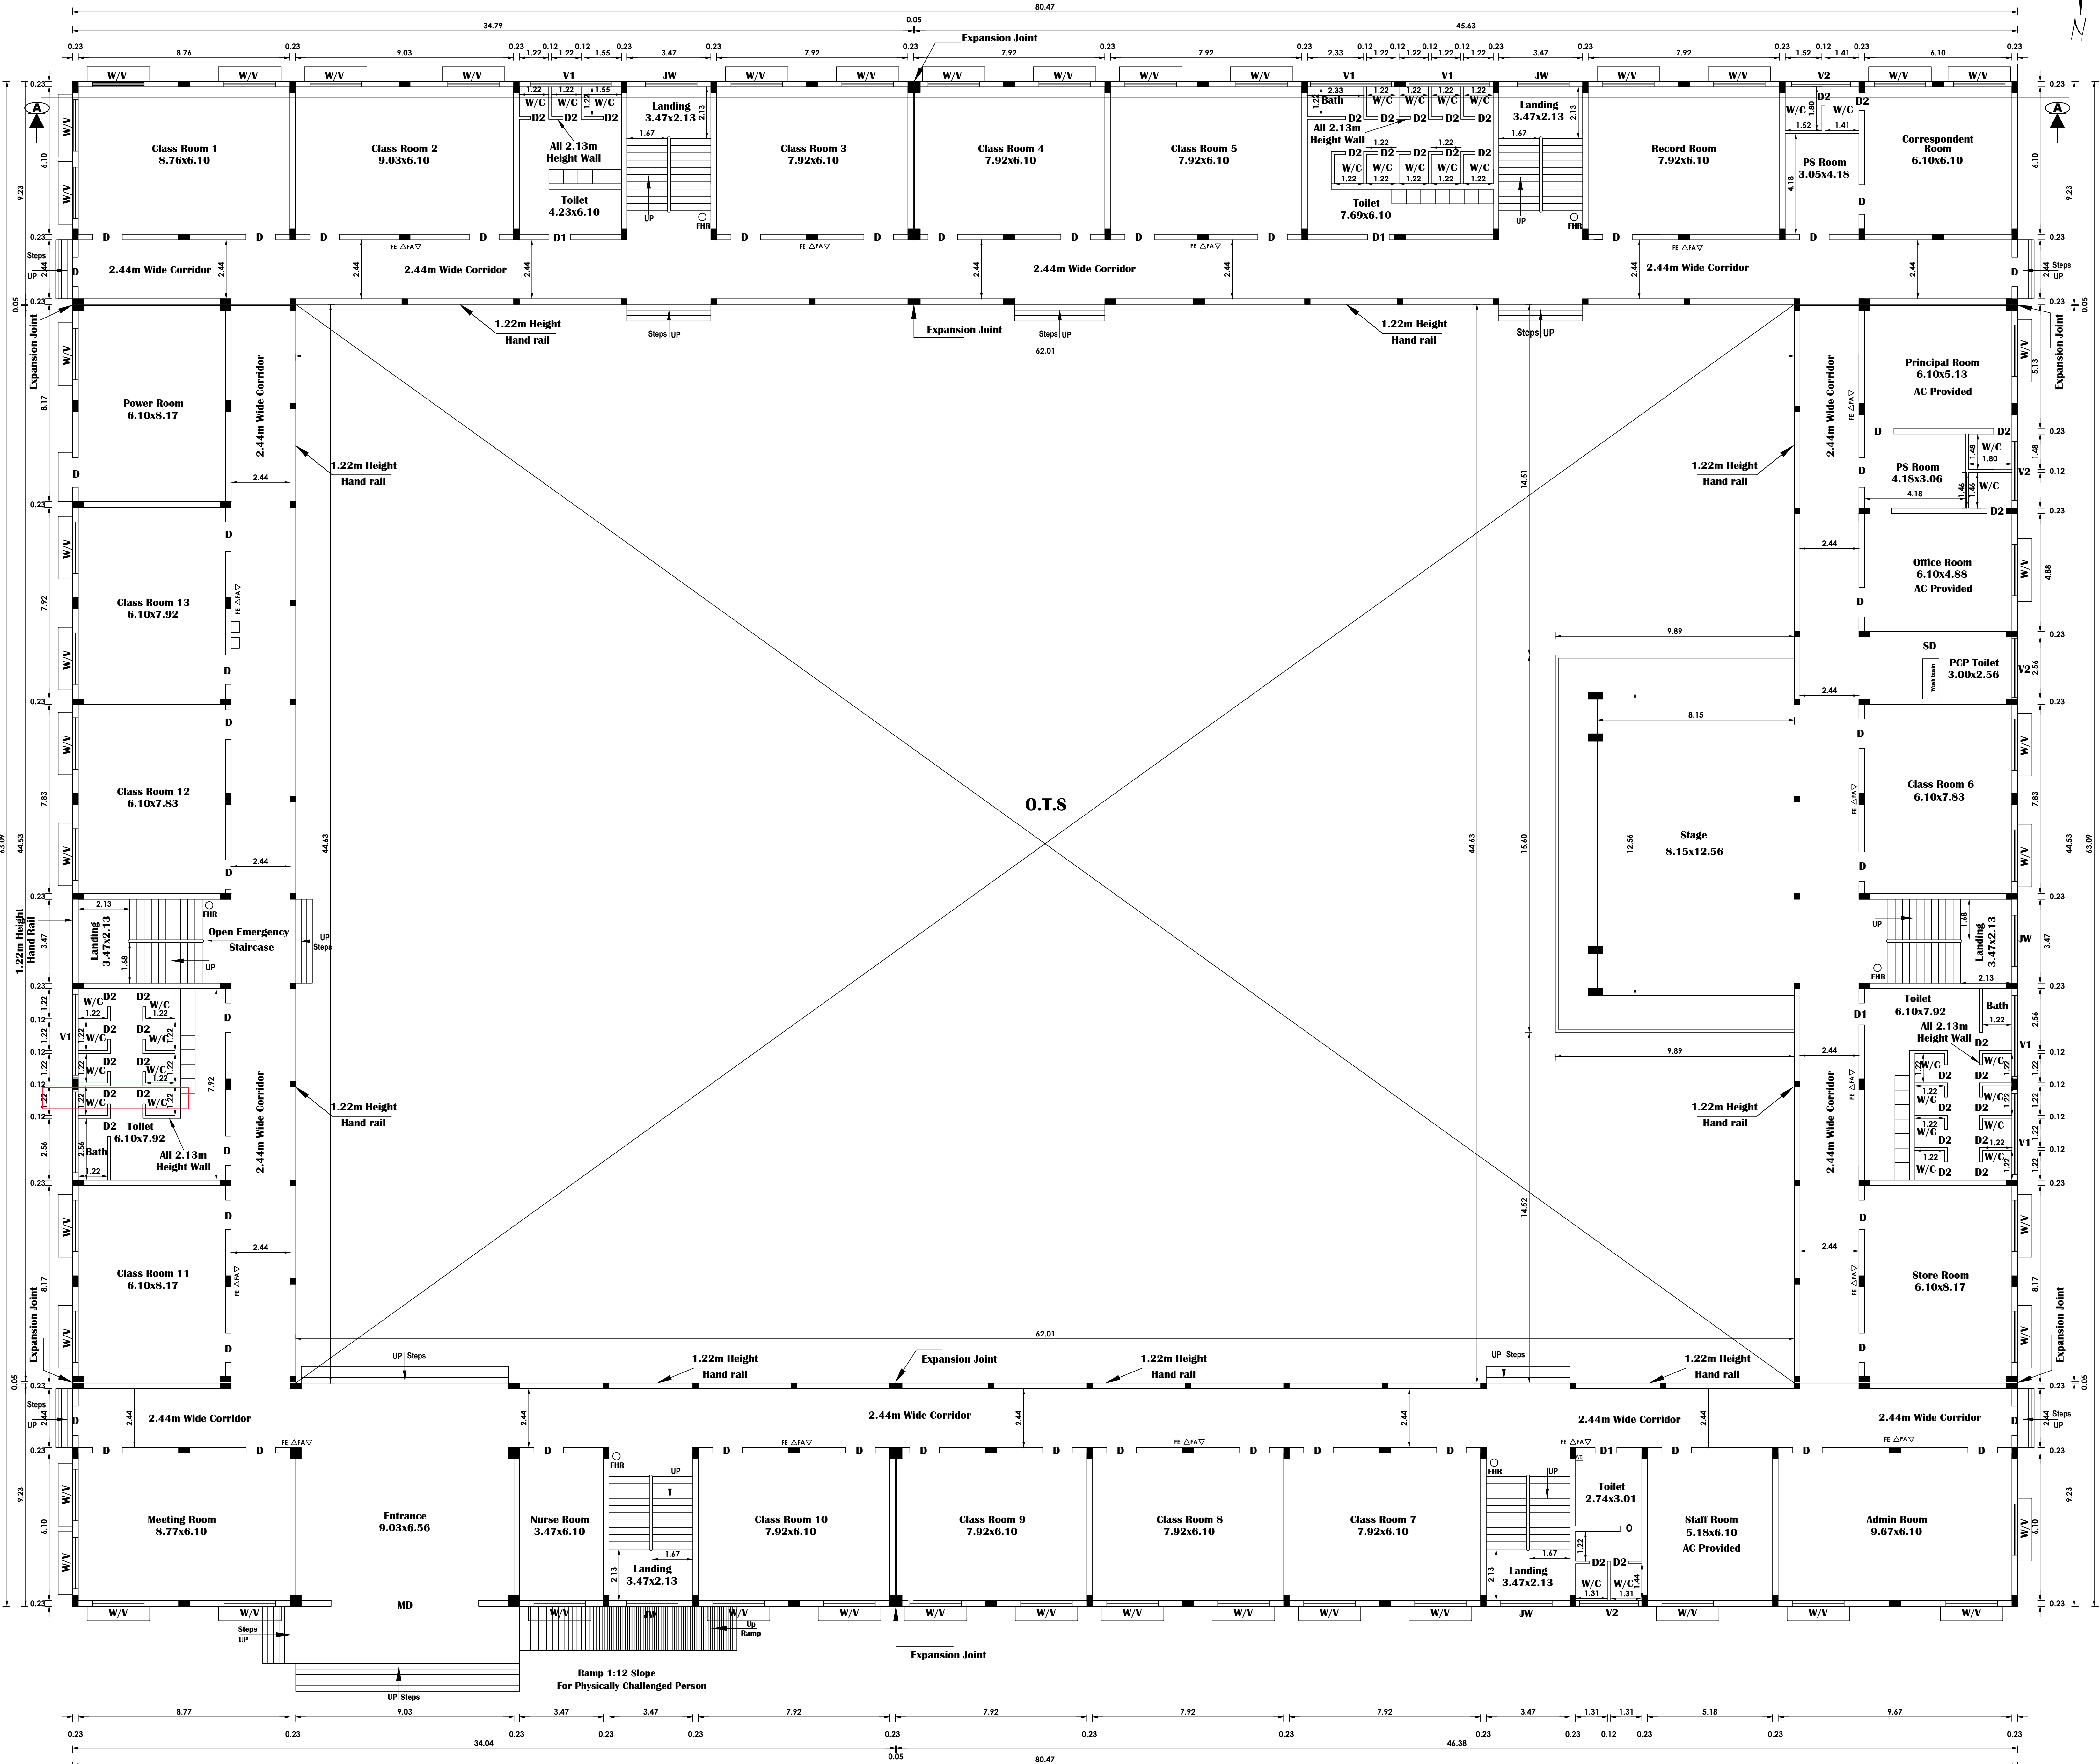


GROUND FLOOR PLAN

JOINERY DETAILS

SCALE 1:100 SHEET No. 2/6

MD	MAIN DOOR	6.10 x 2.44
D	DOOR	1.22 x 2.44
D1	DOOR -1	0.91 x 2.44
D2	DOOR -2	0.76 x 2.13
W	WINDOW	2.13 x 1.83
V	VENTILATOR	2.13 x 0.61
V1	VENTILATOR	3.35 x 0.61
V2	VENTILATOR	2.44 x 0.61
JW	JOLLY WORK	2.13 x 2.44
SD	SLIDE DOOR	1.00 x 2.44

APPLICANT

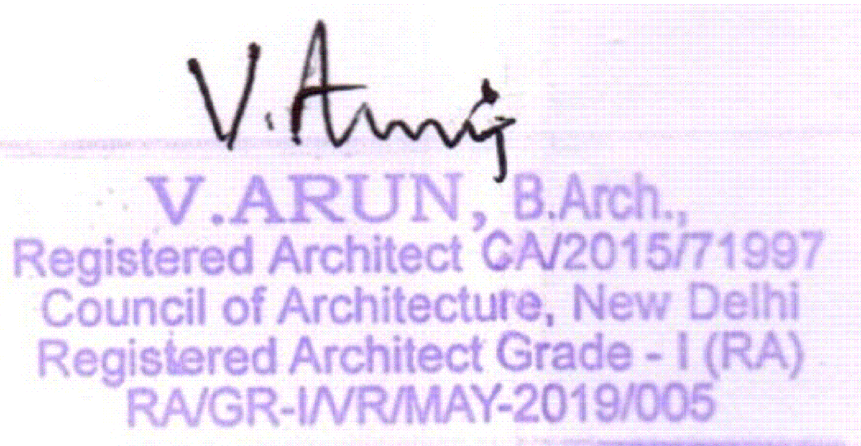

ARCHITECT

- FA ▽ FIRE ALARM
- FE △ FIRE EXTINGUISHERS.
- FHR ○ Fire Hose Reel
- EF ⊗ Exhaust Fan With 0.46 Dia
- PCP -PHYSICALLY CHALLENGED PERSON

Er. M. REVATHY, B.E.,
Regd.Engineer Grade-II(RE)
DTCP Reg.No, RE/GR.II/VD/AUGUST-2022/062
RE/GR.II/VD/AUGUST-2022/062
No.47, Ground Floor,Guber Plaza, Trichy Main Road,
Villupuram - 605 602. Ph:96777 43344.

ENGINEER


Er. K.G. Manivachakam
B.E,M.I.E,F I V. C. ENGE
Reg NO: M2/80777/96
Registered Structural Engineer Grade - II(RSE)
RSE/GR.II/VR/MAY-2019/007
(UNDER TNCD B RULES)
Chartered Engineer, Approved Valuer
Class- 1A - Registered Engineer
Collectorate Panel Engineer
(under Tamilnadu Public Building Act)
D. No: 3/201 First Cross Street Friends Nagar
Semmandalam. Cuddalore - 607 001.

STRUCTURAL

B.P/DTCP NO: 454/ 2023

OFFICE USE

JAYAPRIYA EDUCATIONAL TRUST.

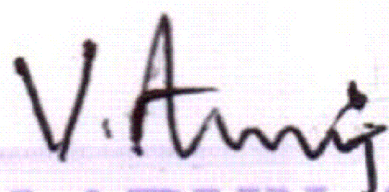SITE EXTENT		SCALE 1:400	SHEET No. 1/6
S.F. NO	Area in Sq.m	 V. ARUN , B.Arch., Registered Architect CA/2015/71997 Council of Architecture, New Delhi Registered Architect Grade - I (RA) RA/GR-I/VR/MAY-2019/005	
47/24	4461		
47/25	7656		
Total	12117 Sq.m		
 APPLICANT		ARCHITECT	

APPLICANT

M. Zuber


Er. M. REVATHY, B.E.,
Regd.Engineer Grade-II(RE)
 DTCP Reg.No. RE/GR.II/VD/AUGUST-2022/062
 RE/GR.II/VD/AUGUST-2022/062
 No.47, Ground Floor,Guber Plaza, Trichy Main Road,
 Villupuram - 605 602. Ph:96777 43344

ENGINEER

Er. K.G. Manivachakam

B.E.,M.I.E,F.I.V.C. ENGINEER
 Reg NO: M2/30777/96
 Registered Structural Engineer Grade - II(RSE)
 RSE/G.R.II/VR/MAY-2019/007
 (UNDER TNCDR RULES)
 Chartered Engineer, Approved Value
 Class- 1A - Registered Engineer
 Collectorate Panel Engineer
 (under Tamilnadu Public Building Act)
 D. No: 3/201 First Cross Street Friends Nagar
 Semmandalam. Cuddalore - 607 001

STRUCTURAL

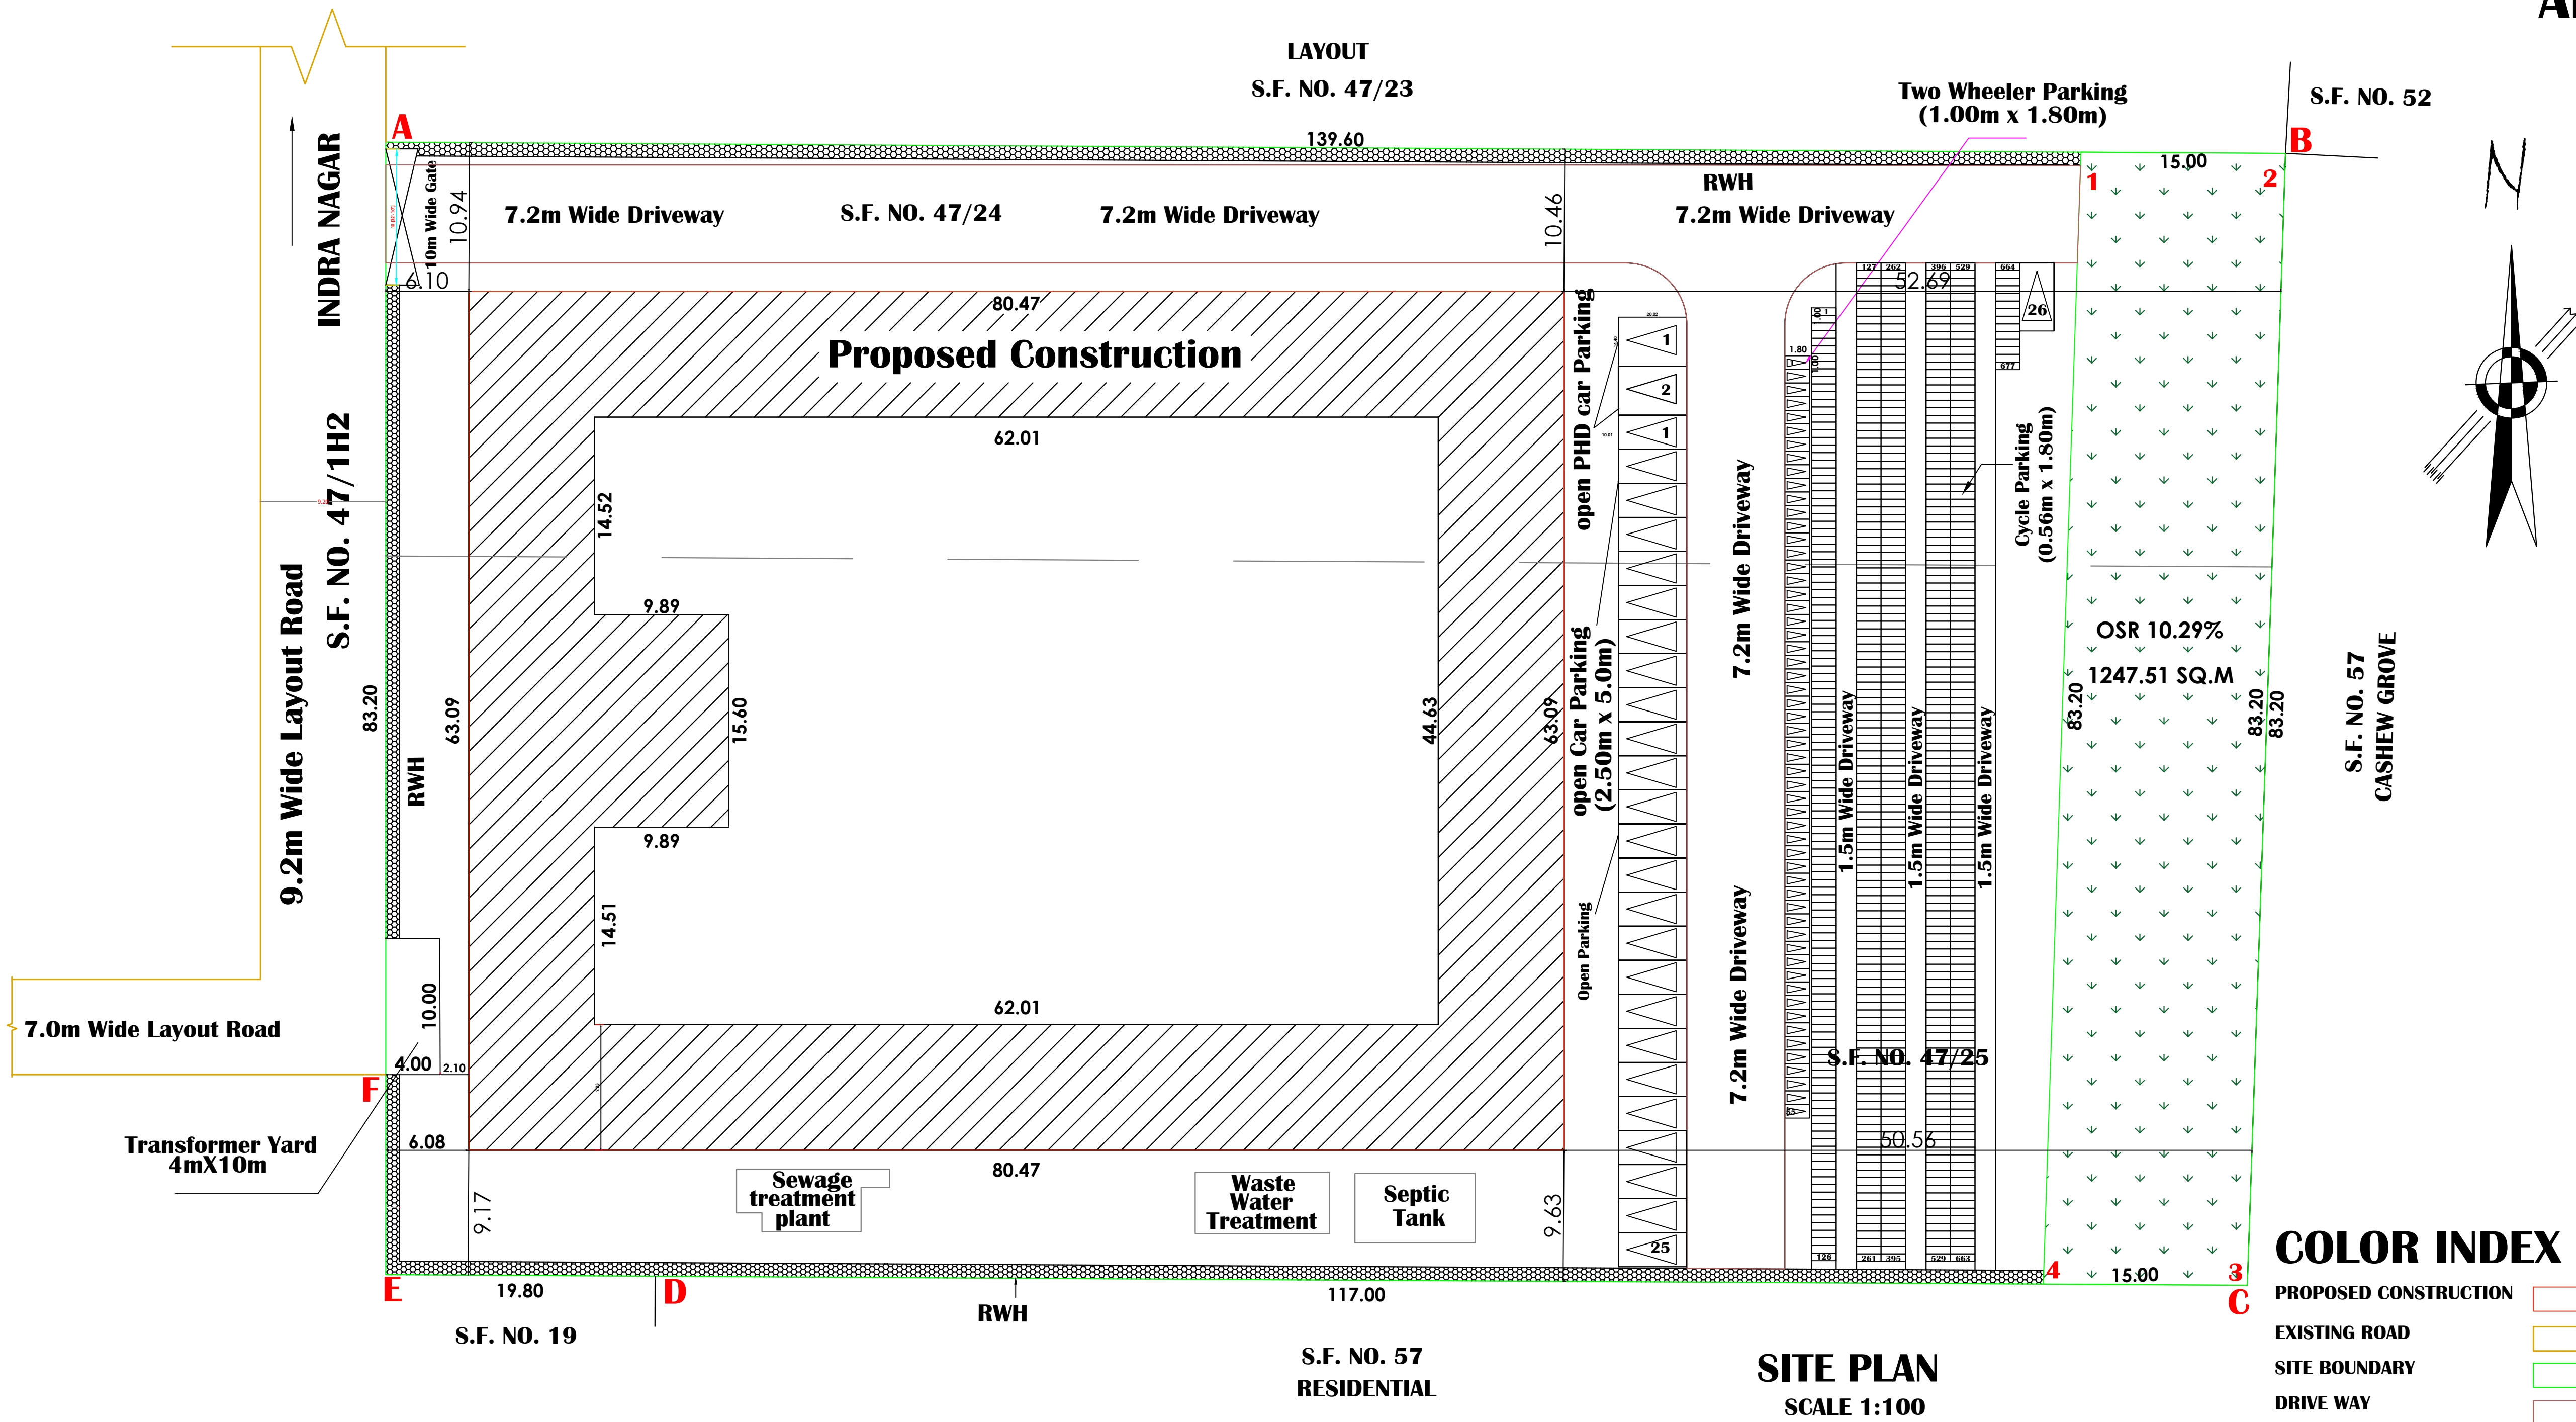




COLOR INDEX

PROPOSED CONSTRUCTION 

EXISTING ROAD 

SITE BOUNDARY 

DRIVE WAY 

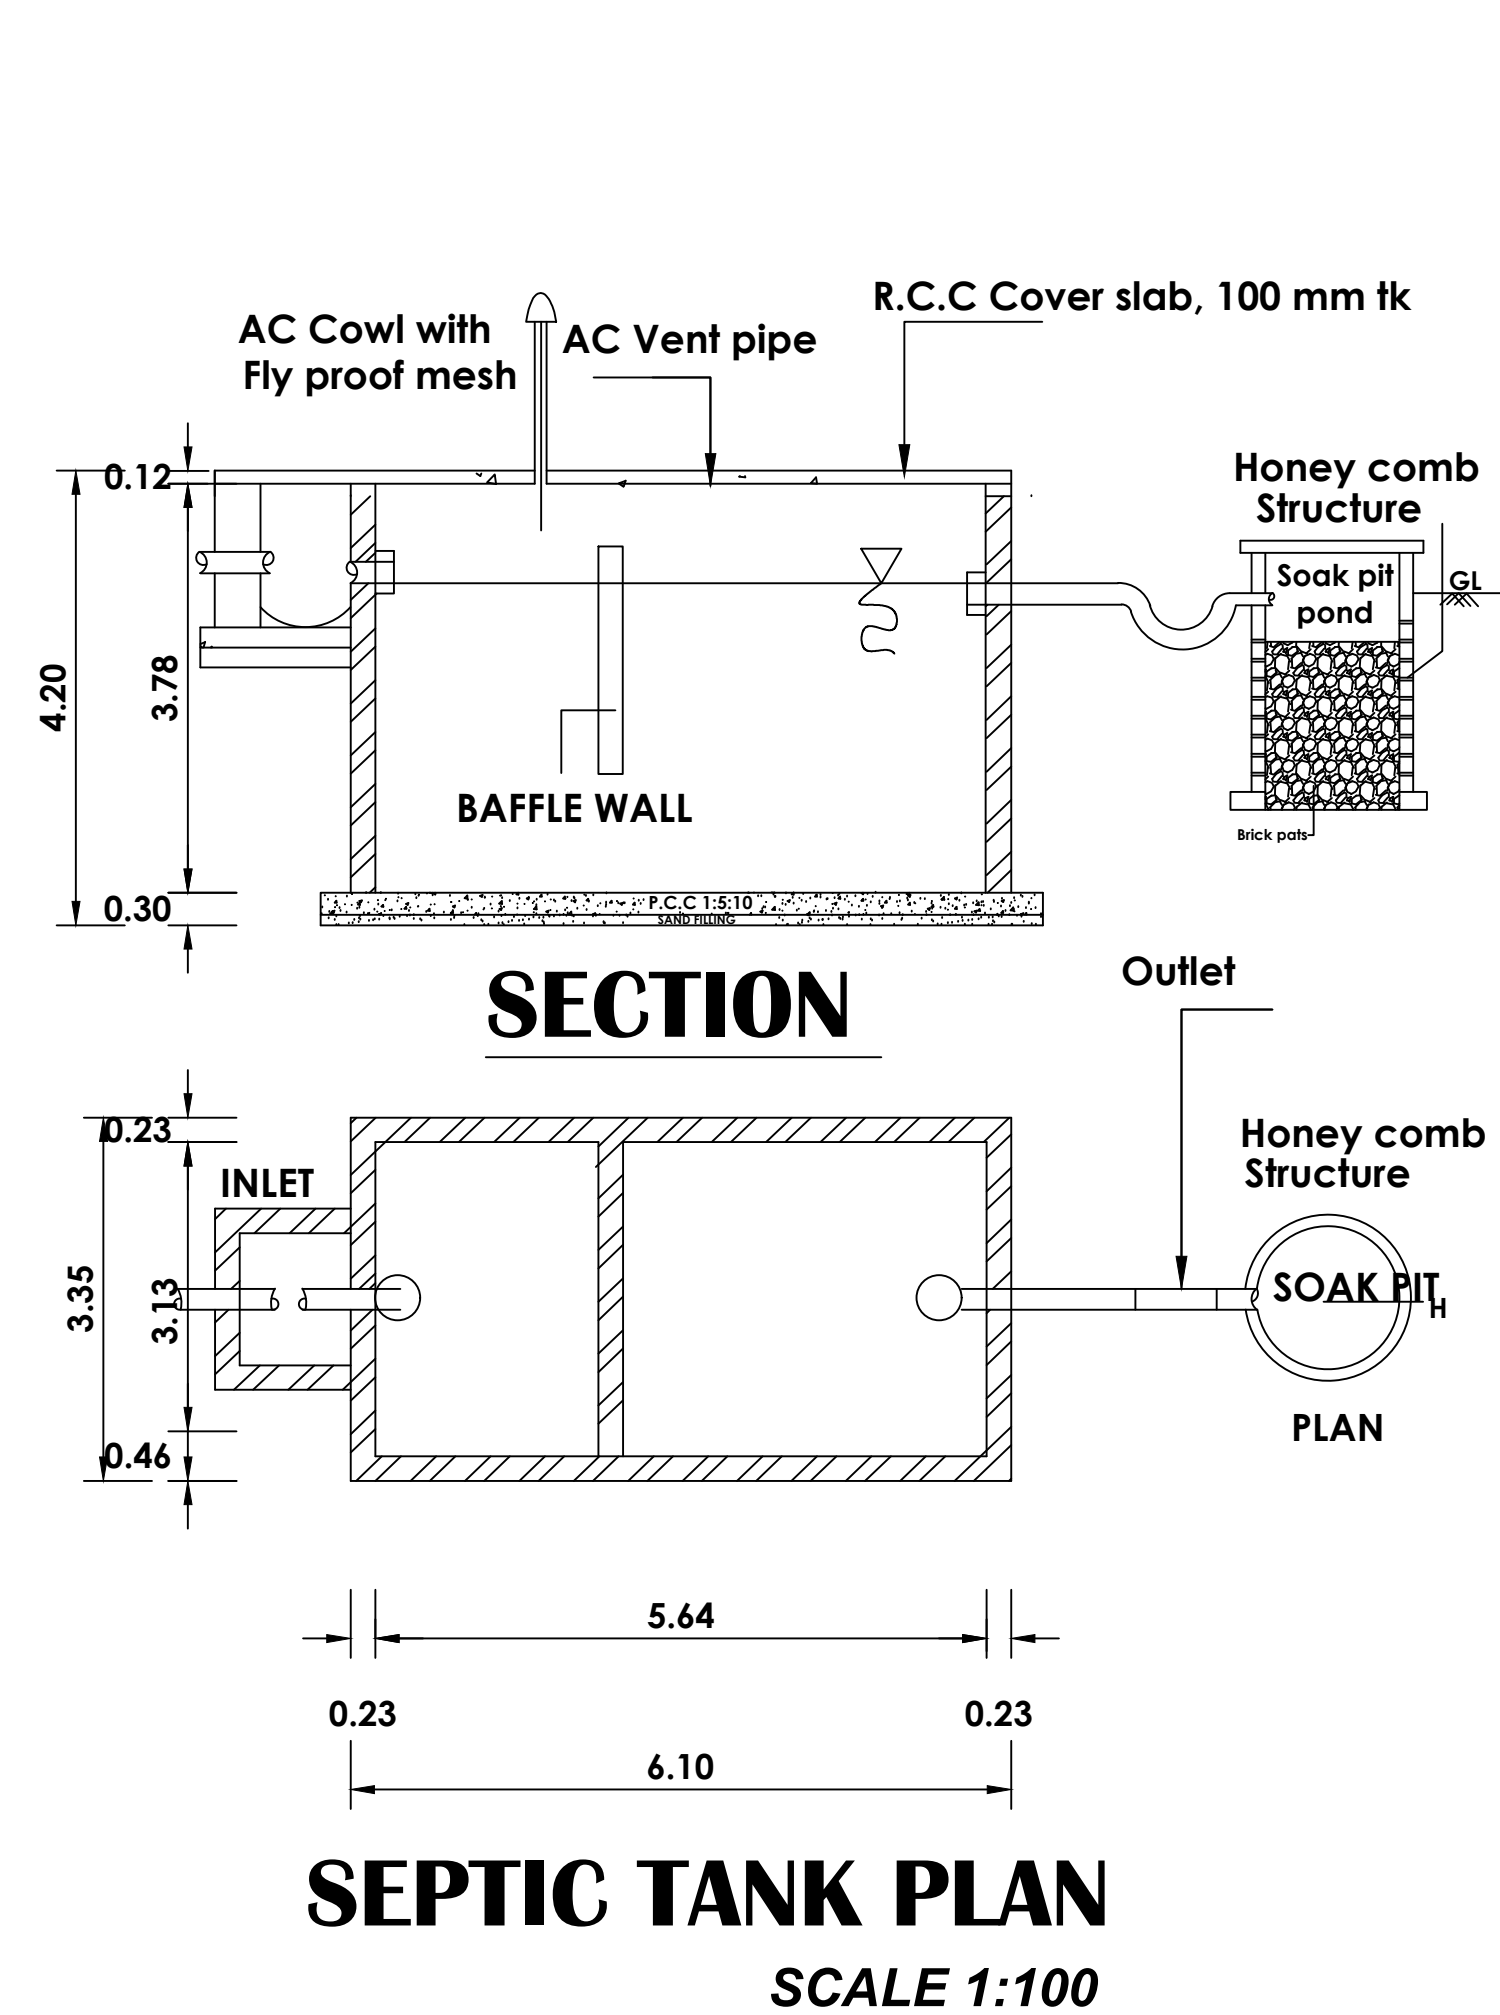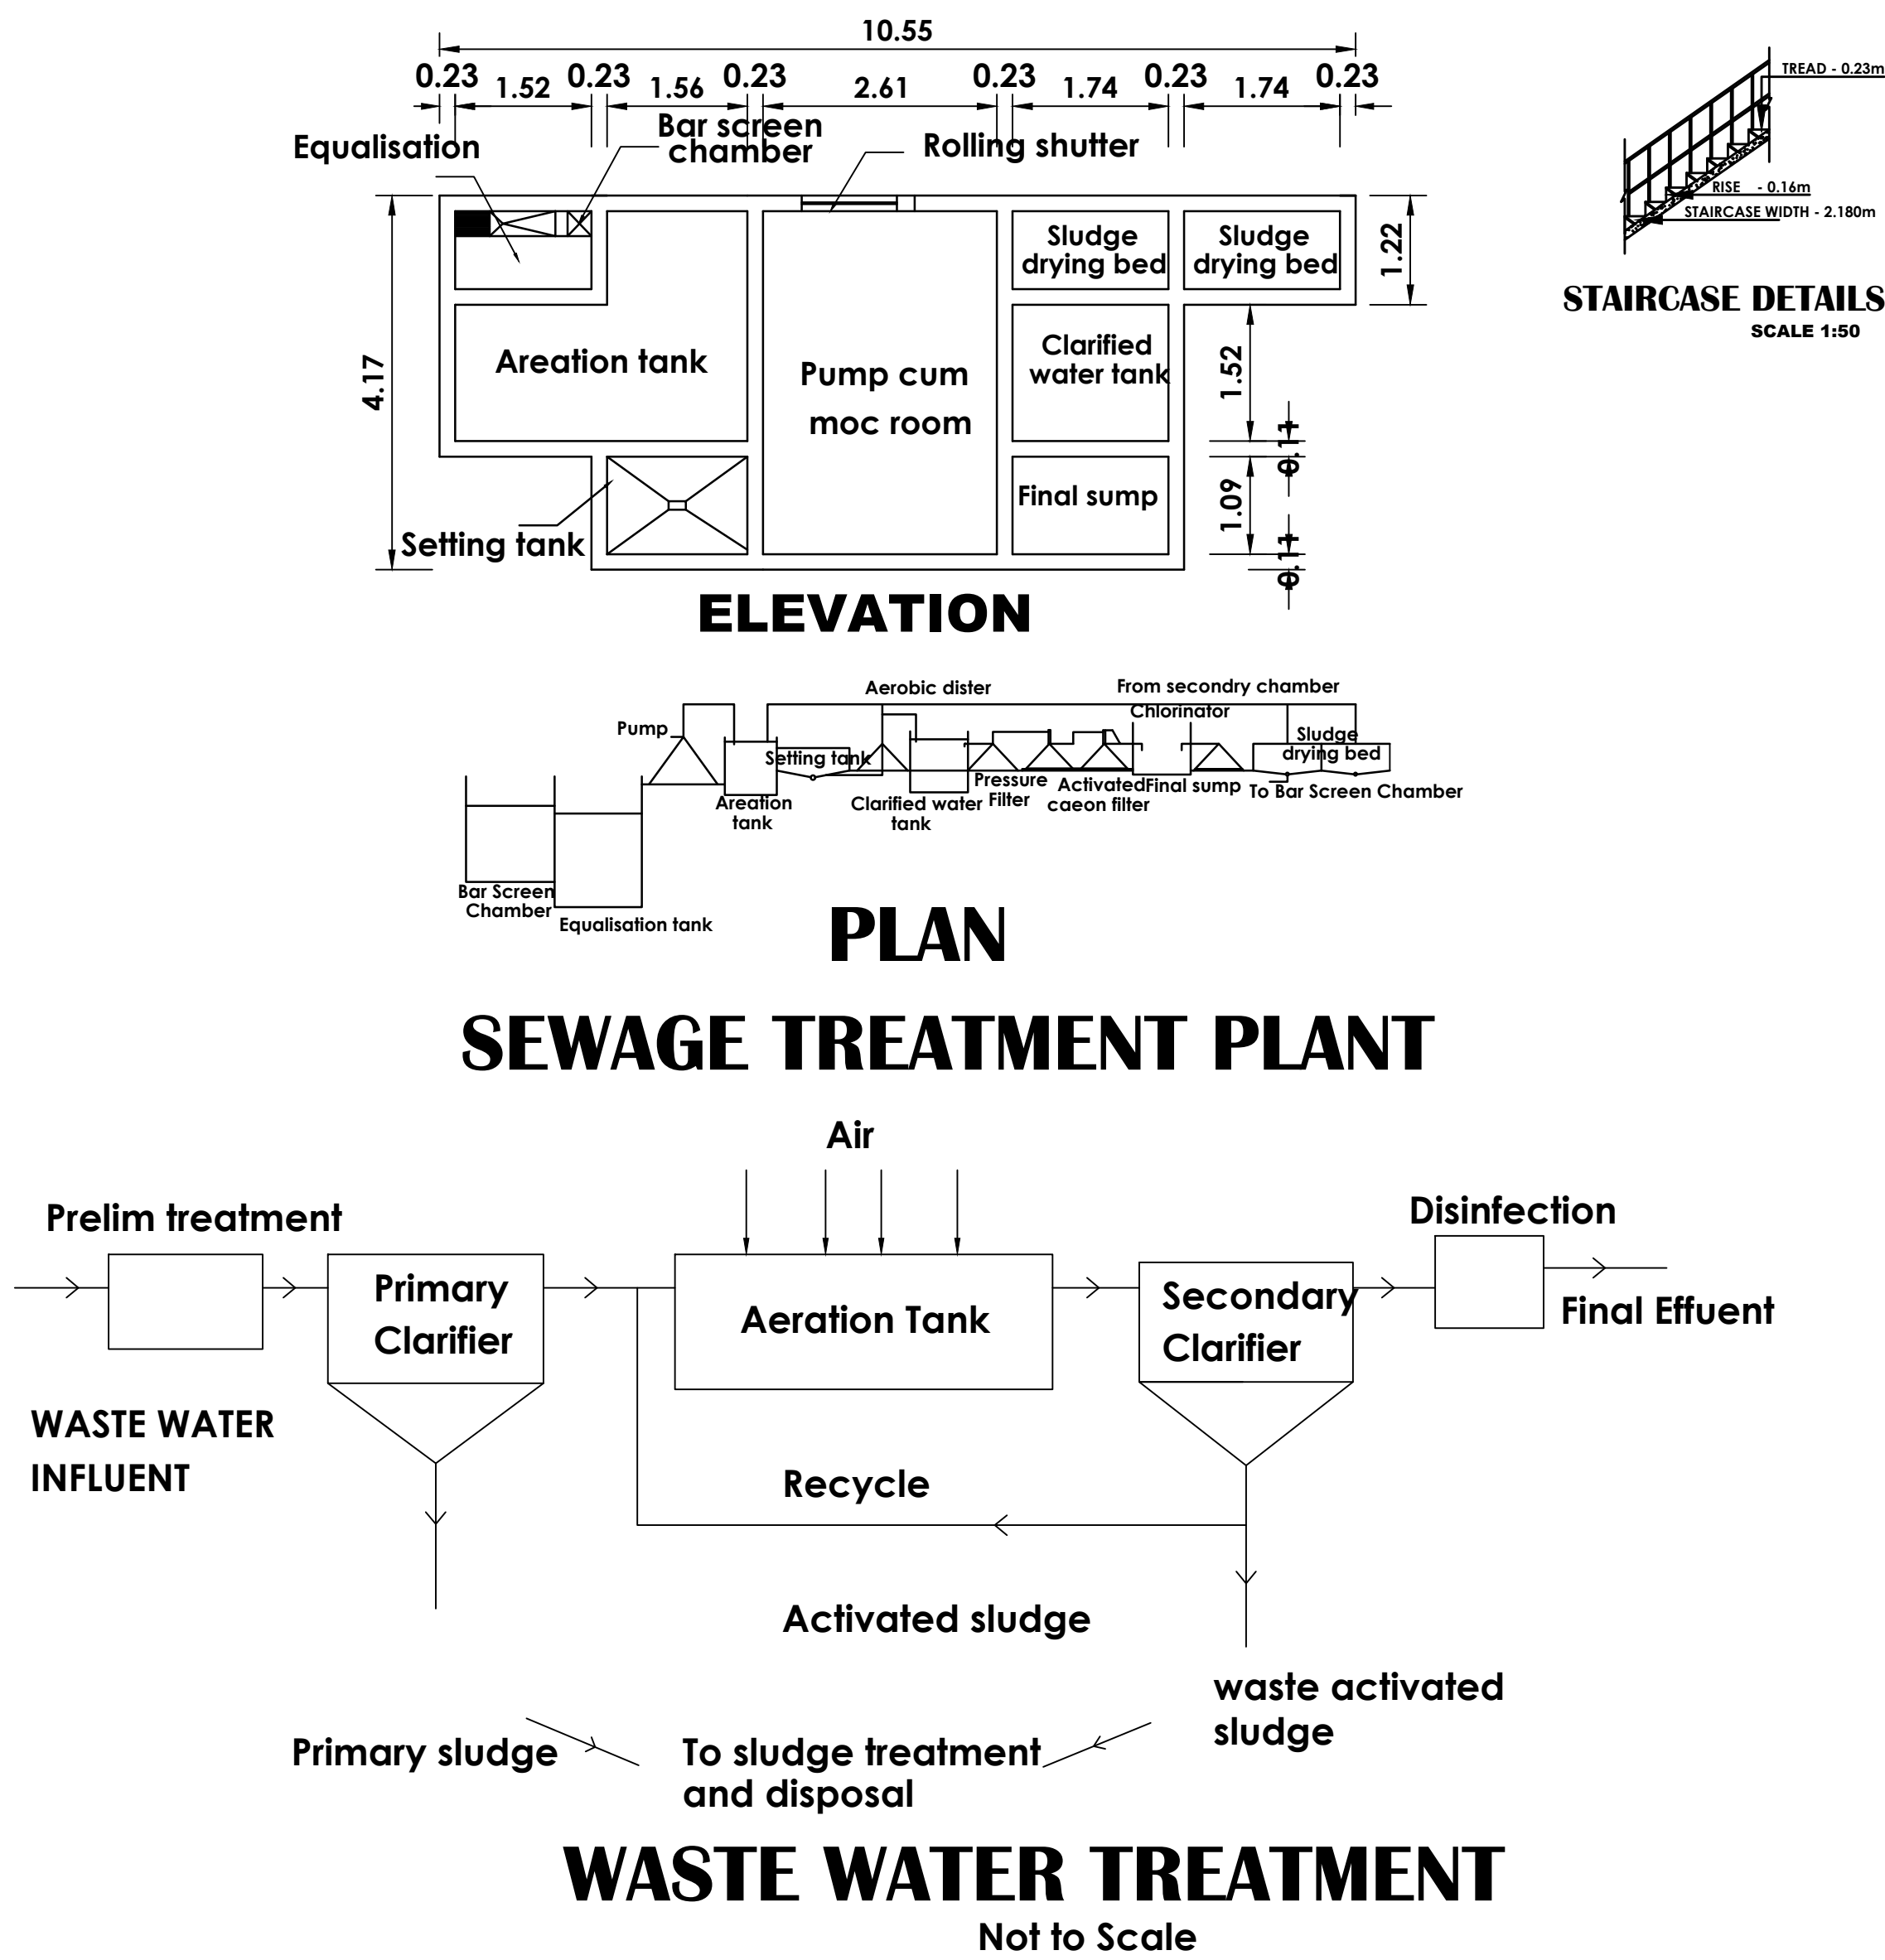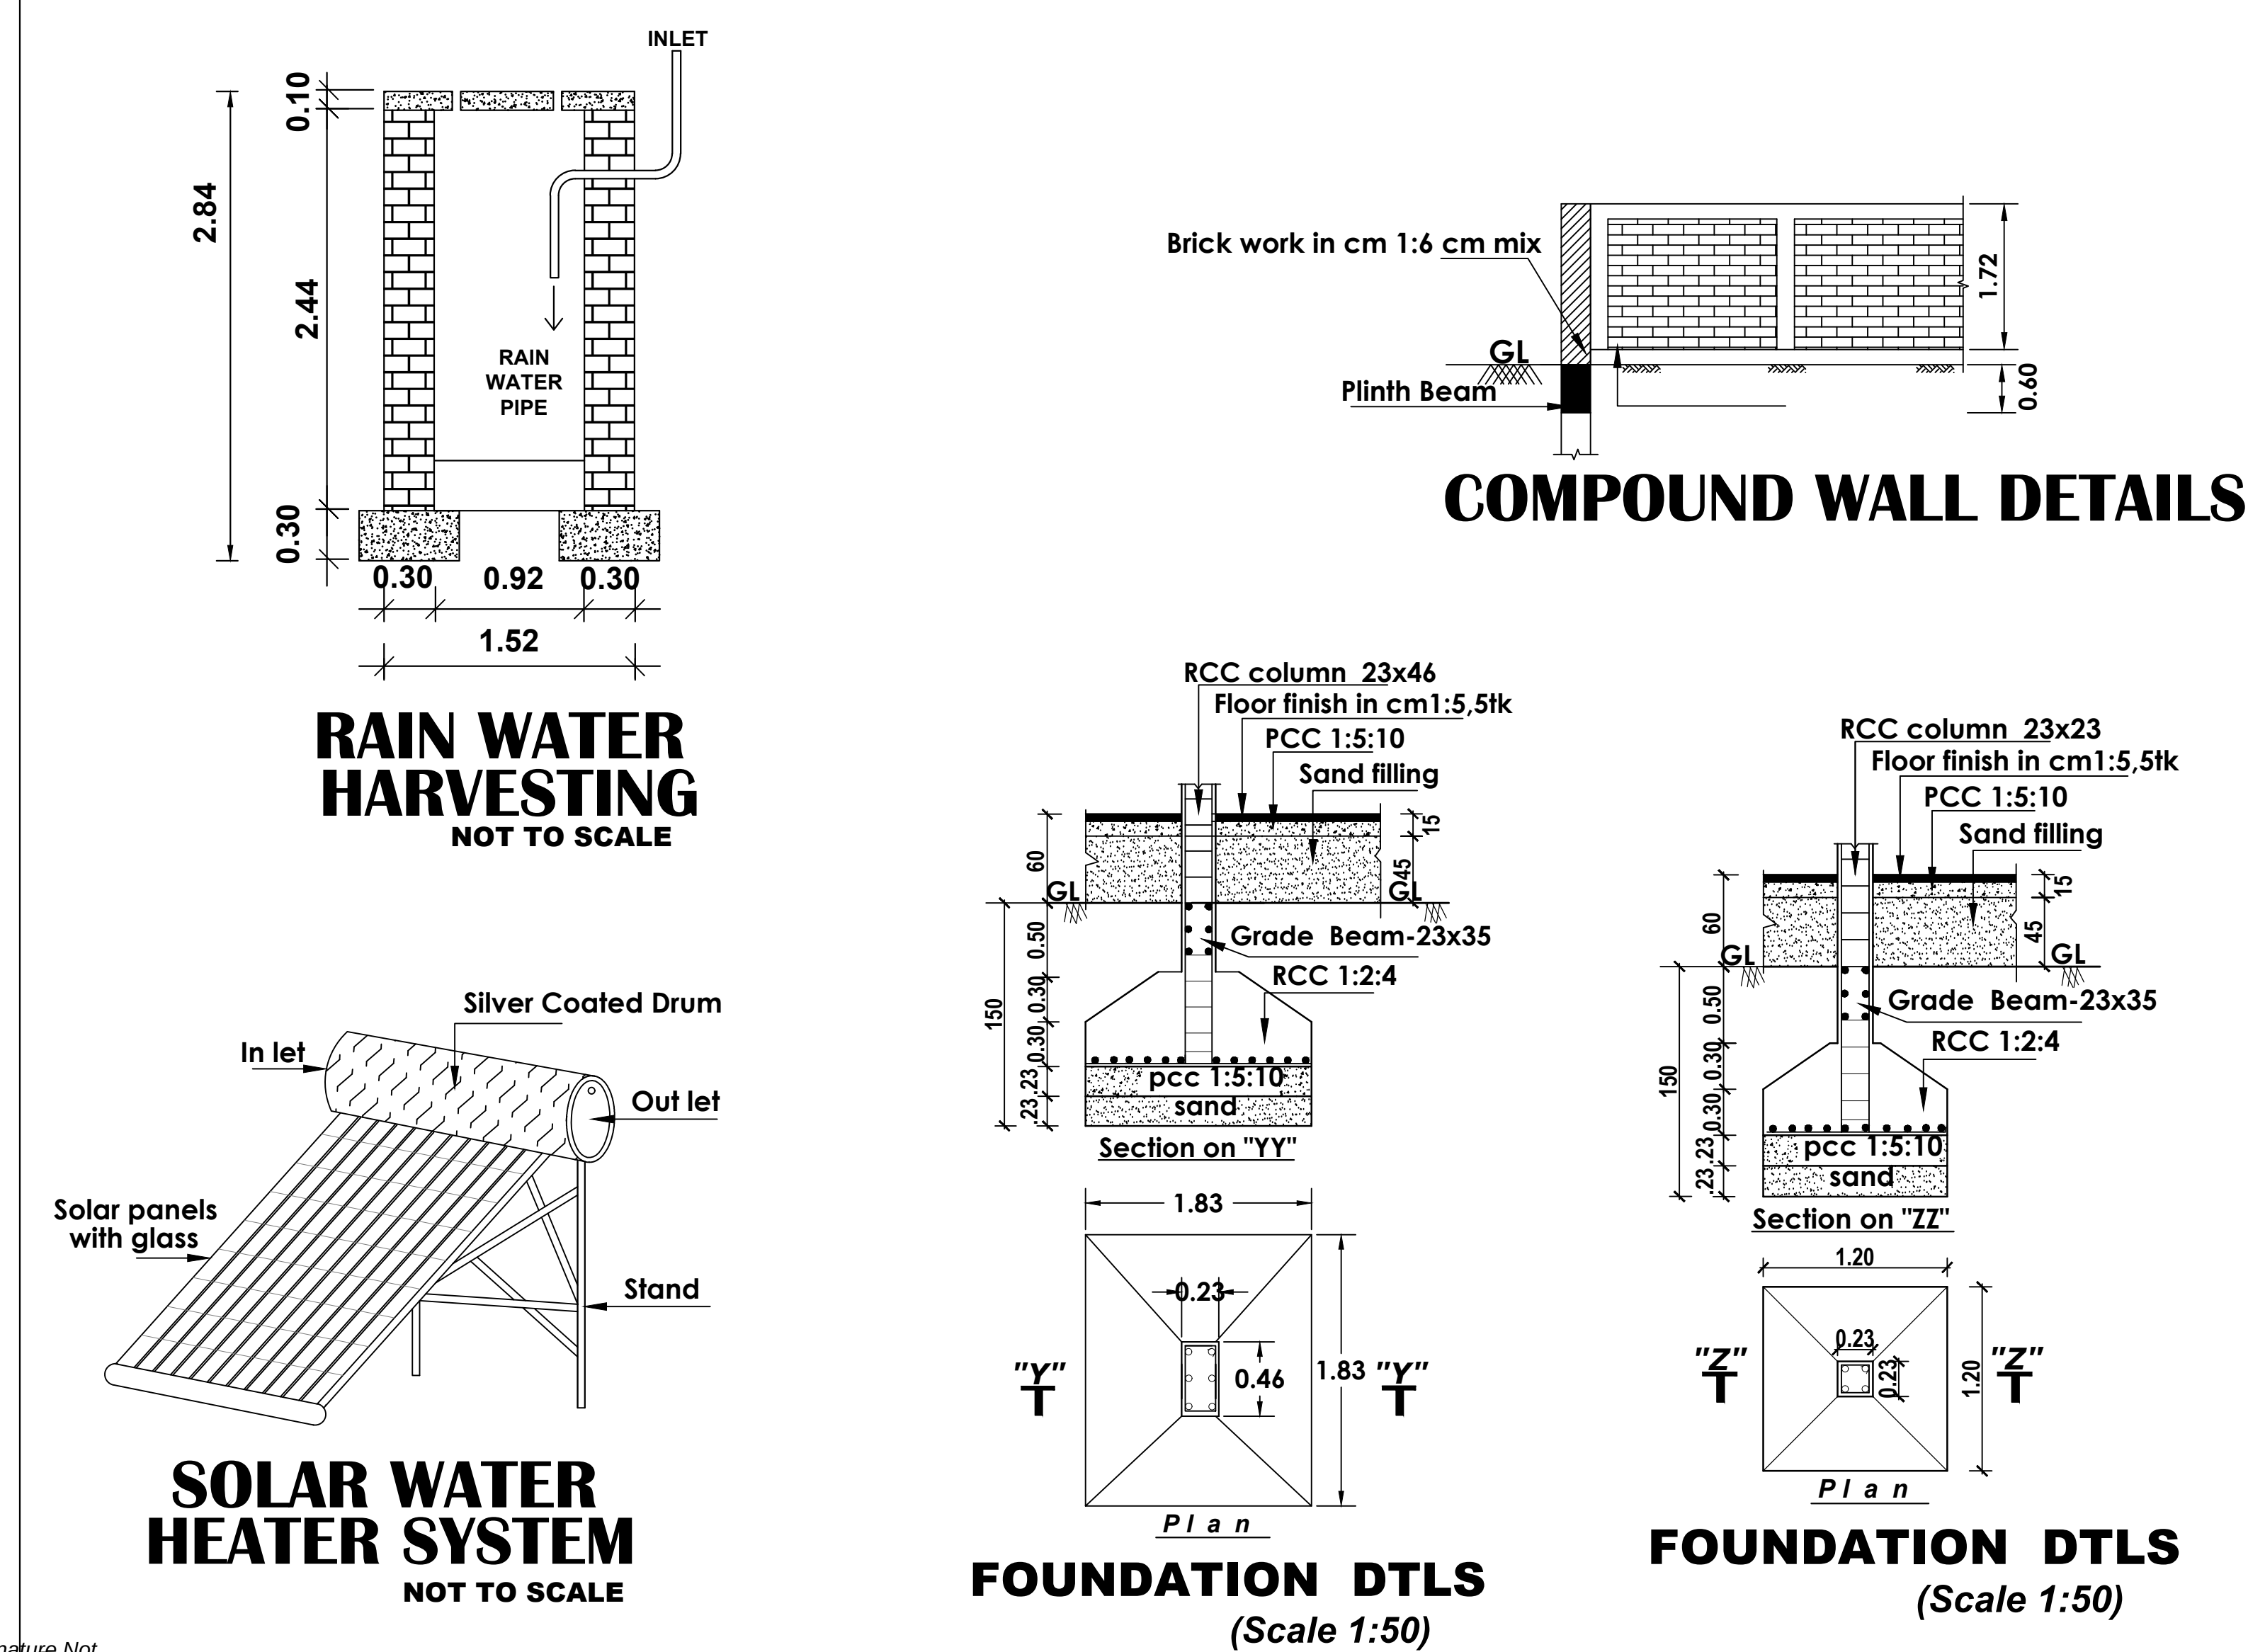**OFFICE USE**

Signature Not Verified	Signature Not Verified	Signature Not Verified
Signed by: LocalDoc Location: null Date: 2022.12.02 12:00:00	Signed by: Assistant Director Location: Cuddleton Date: 2024.01.17 10:44:22	Signed by: Page Branch Location: Cuddleton Date: 2026.06.18 19:05:24