
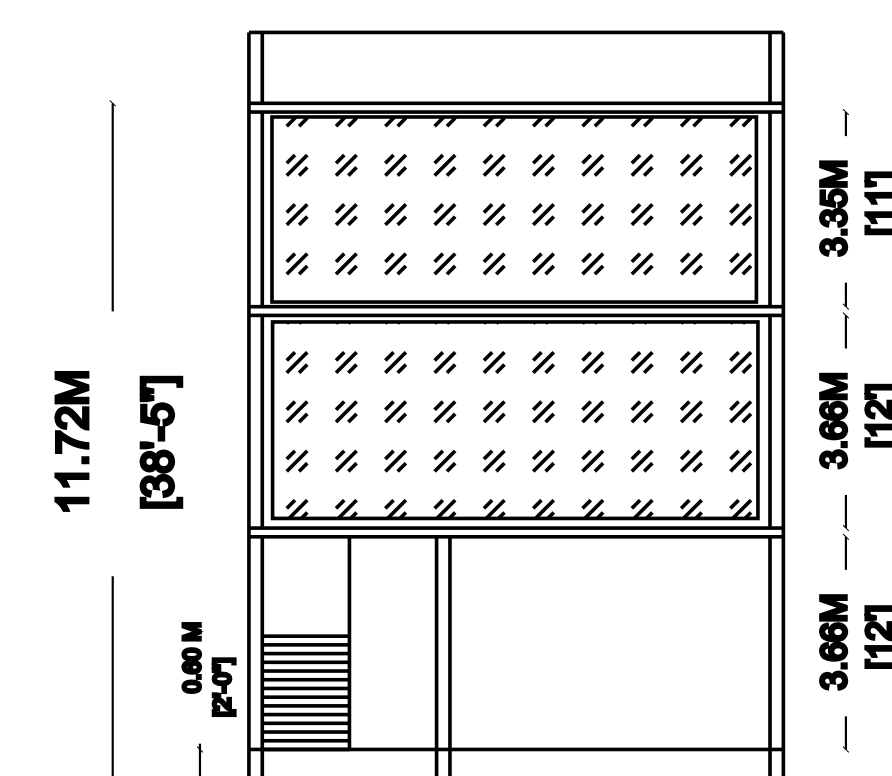



S.F.NO:60/4B3B1

[illegible]


ELEVATION

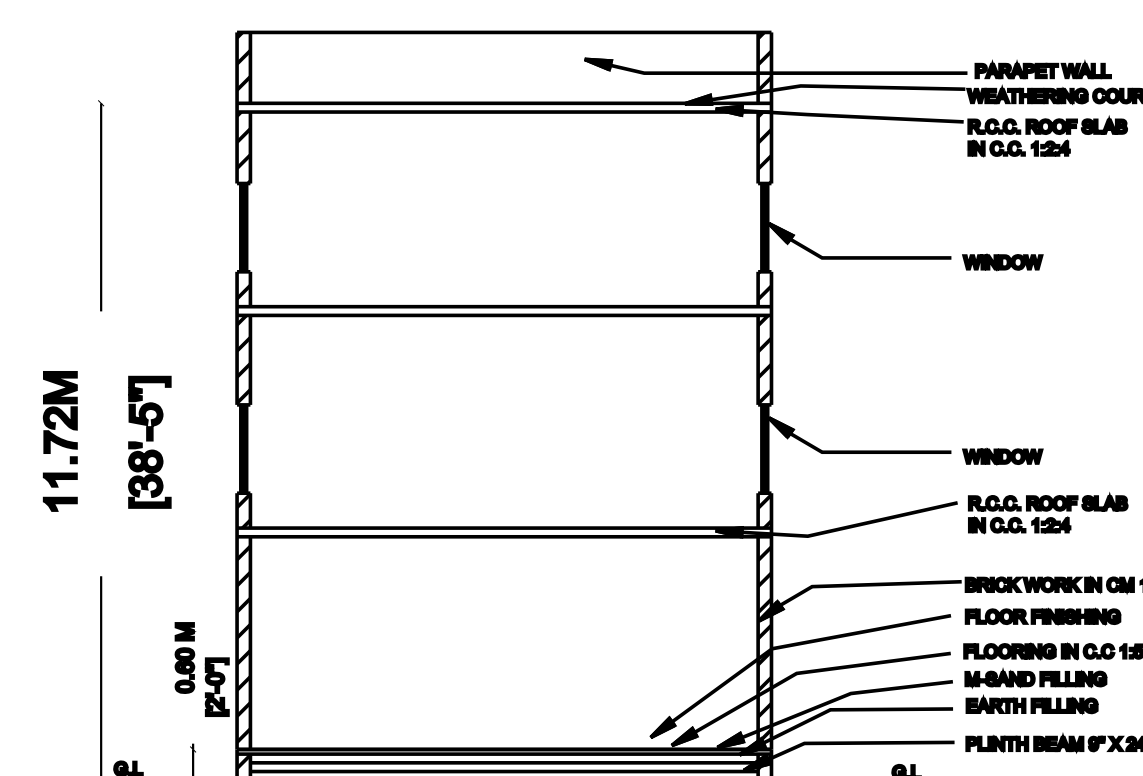


SECTION ON A-A

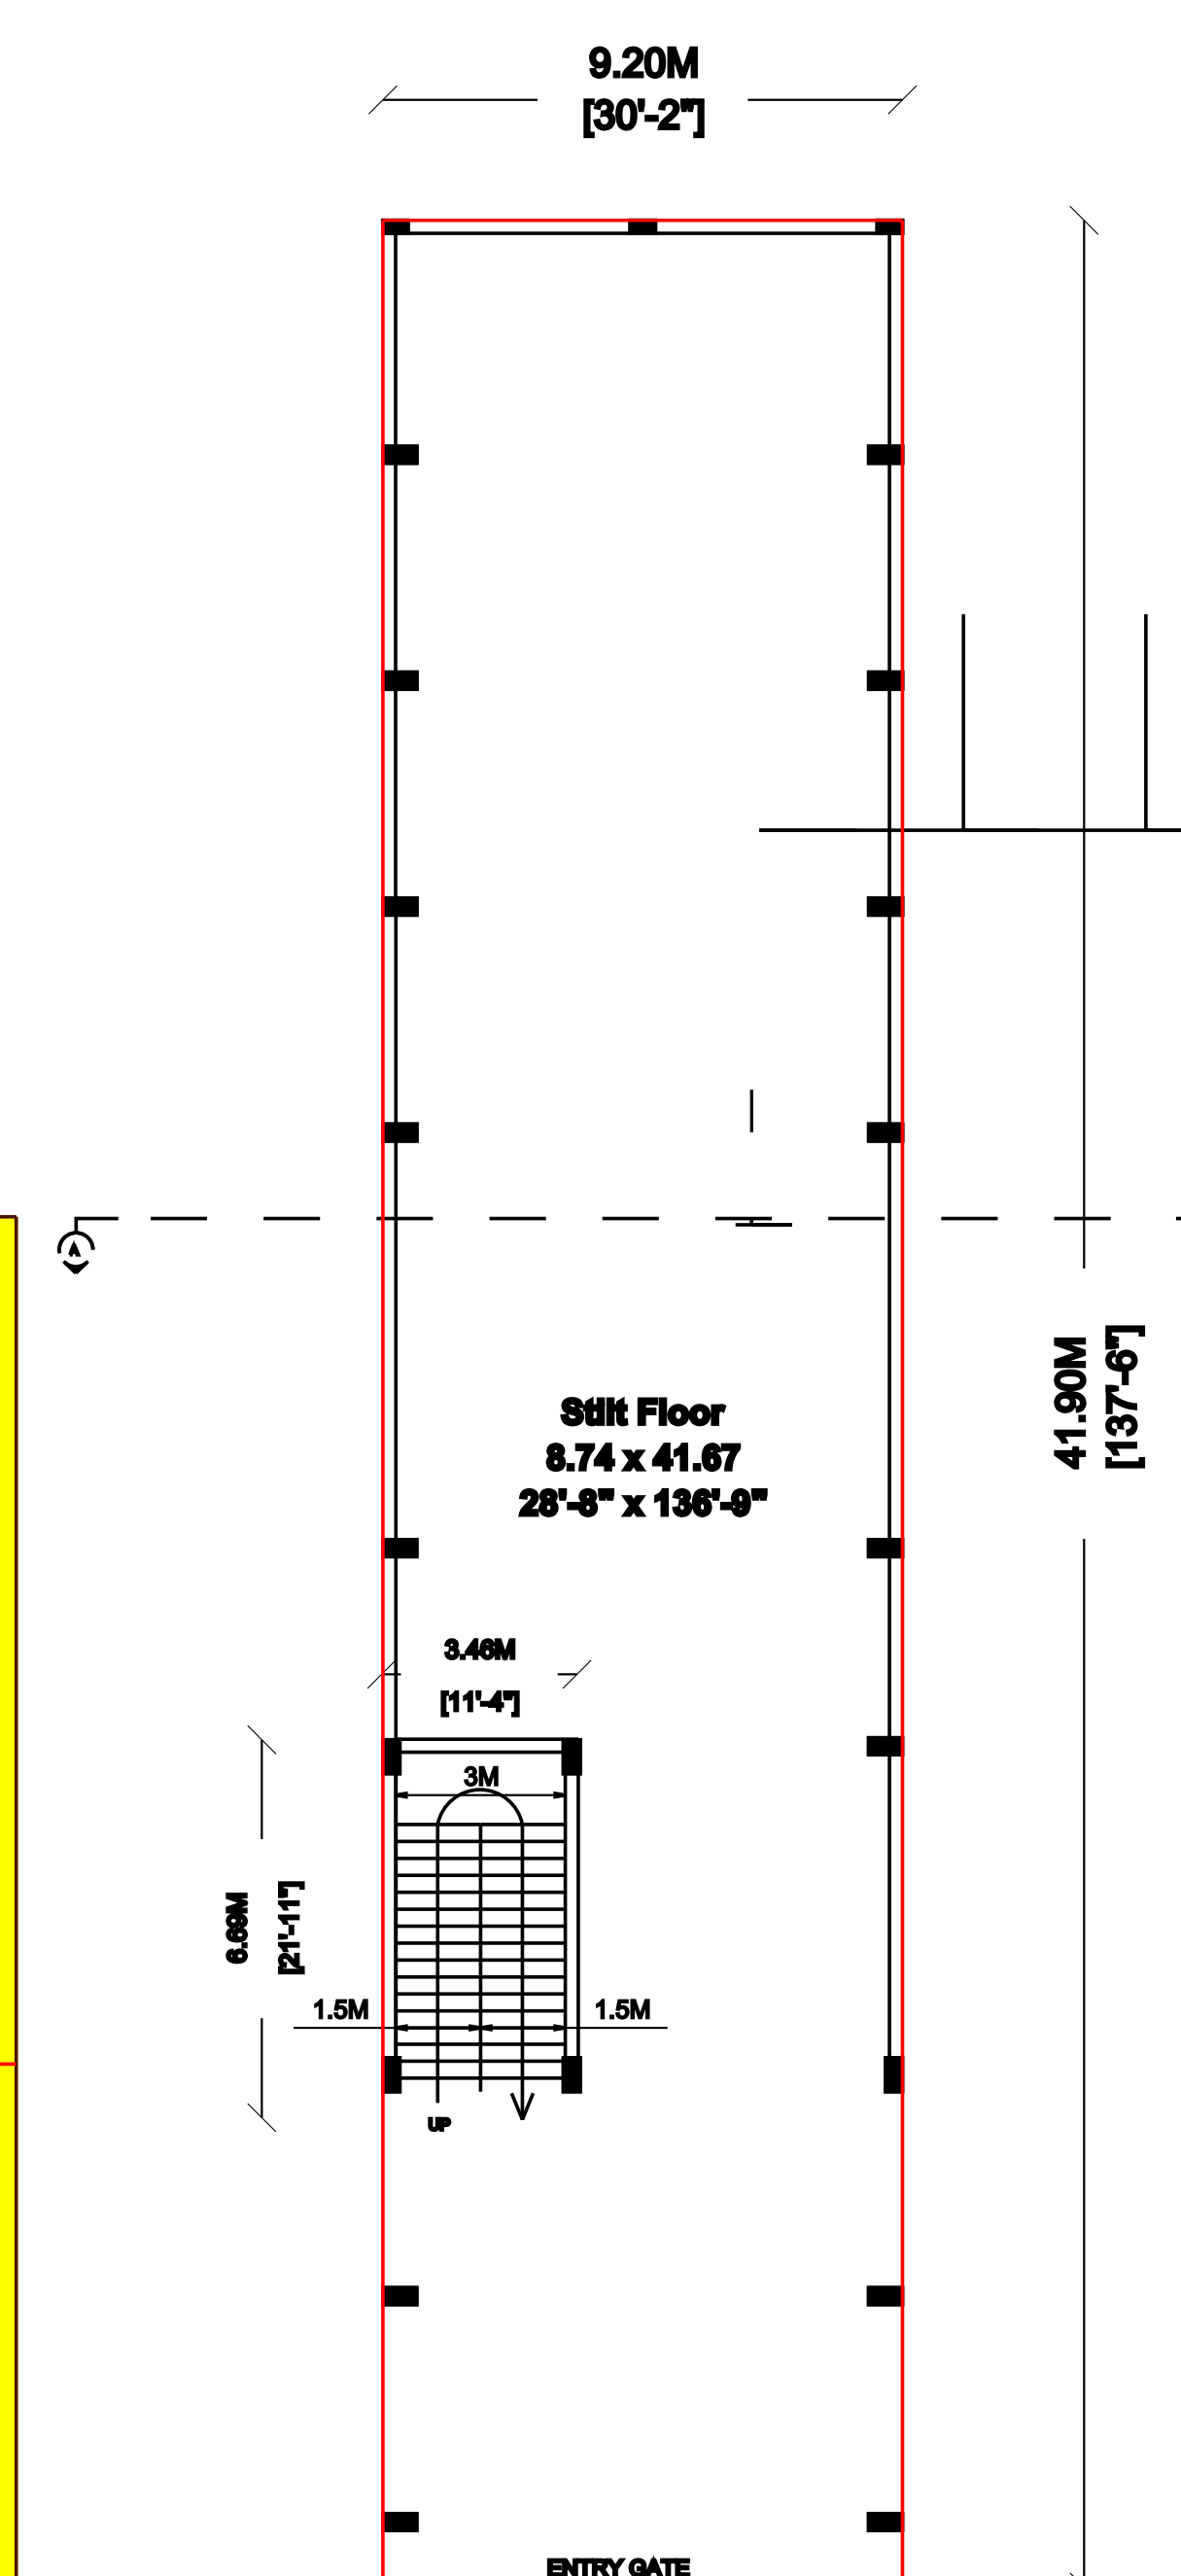


STILT FLOOR PLAN

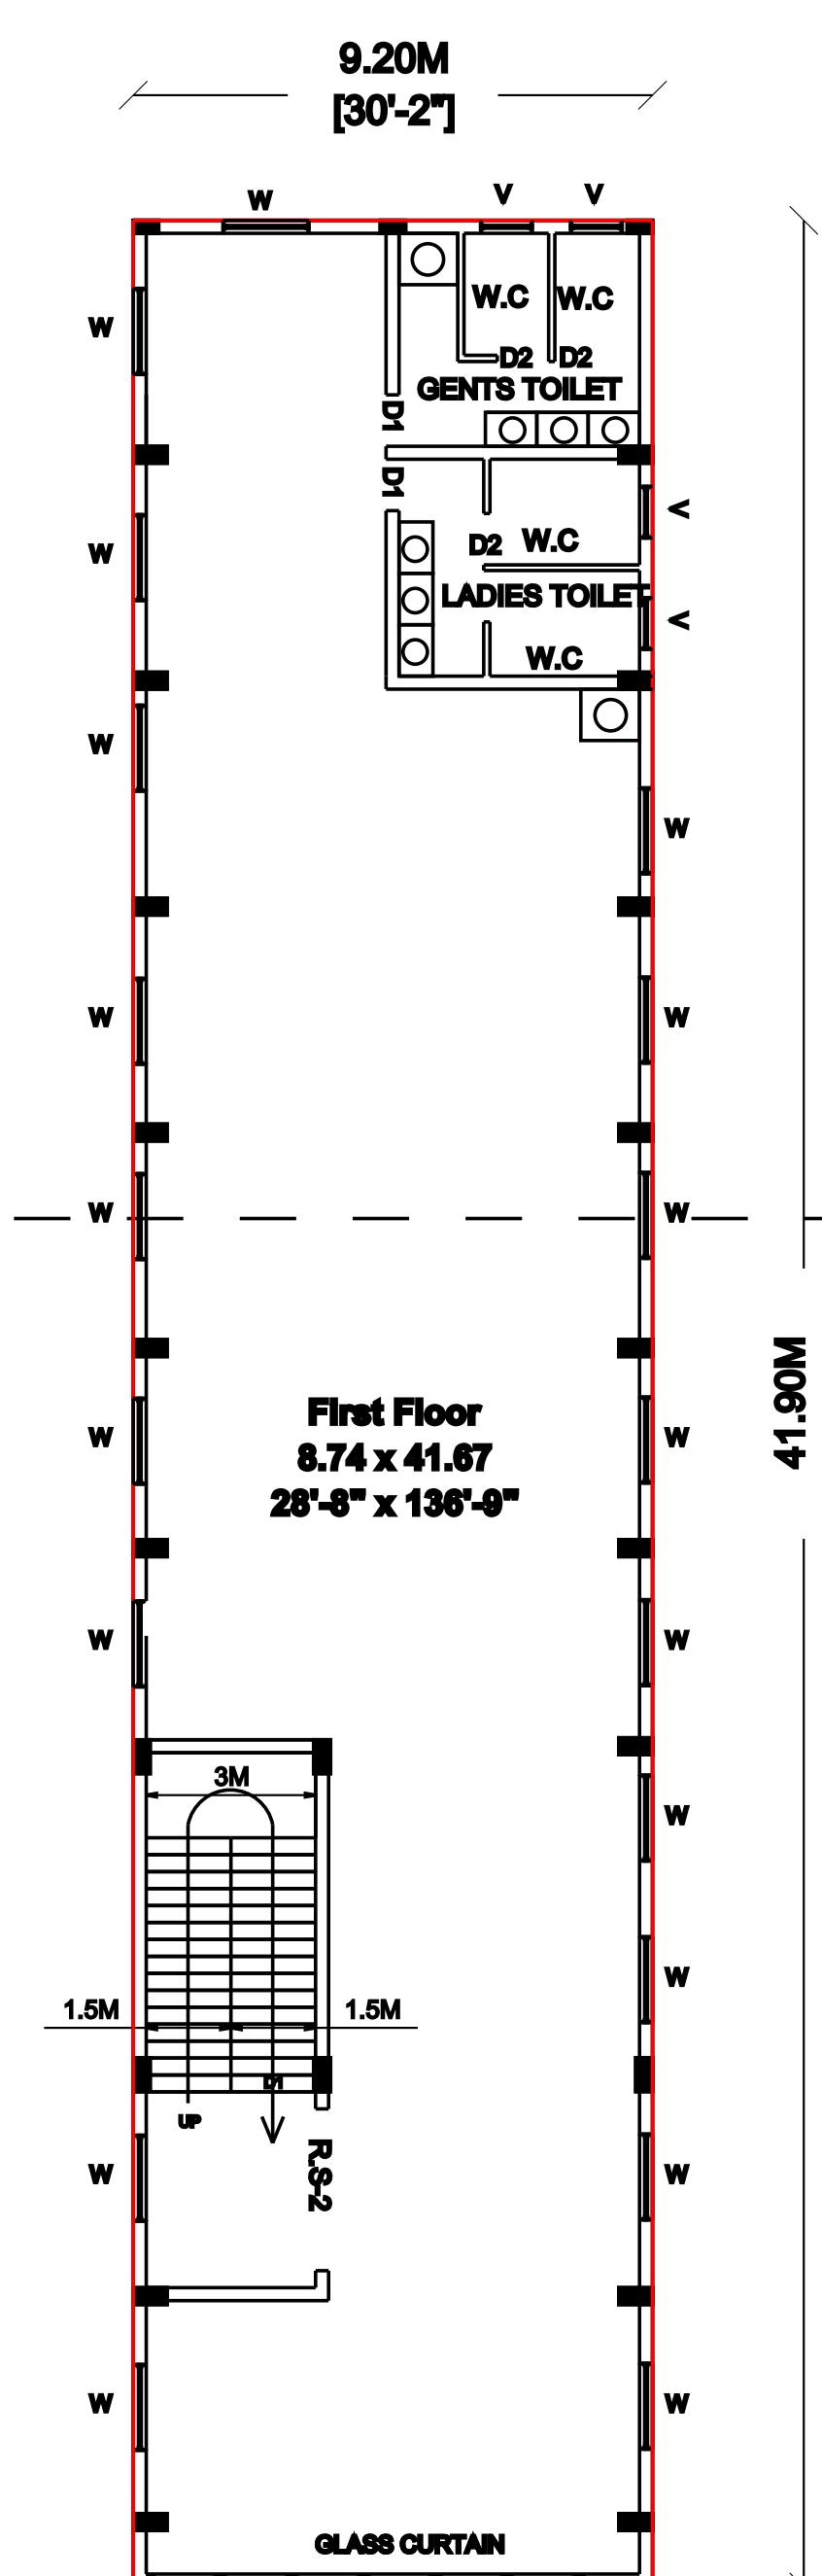

FIRST FLOOR PLAN


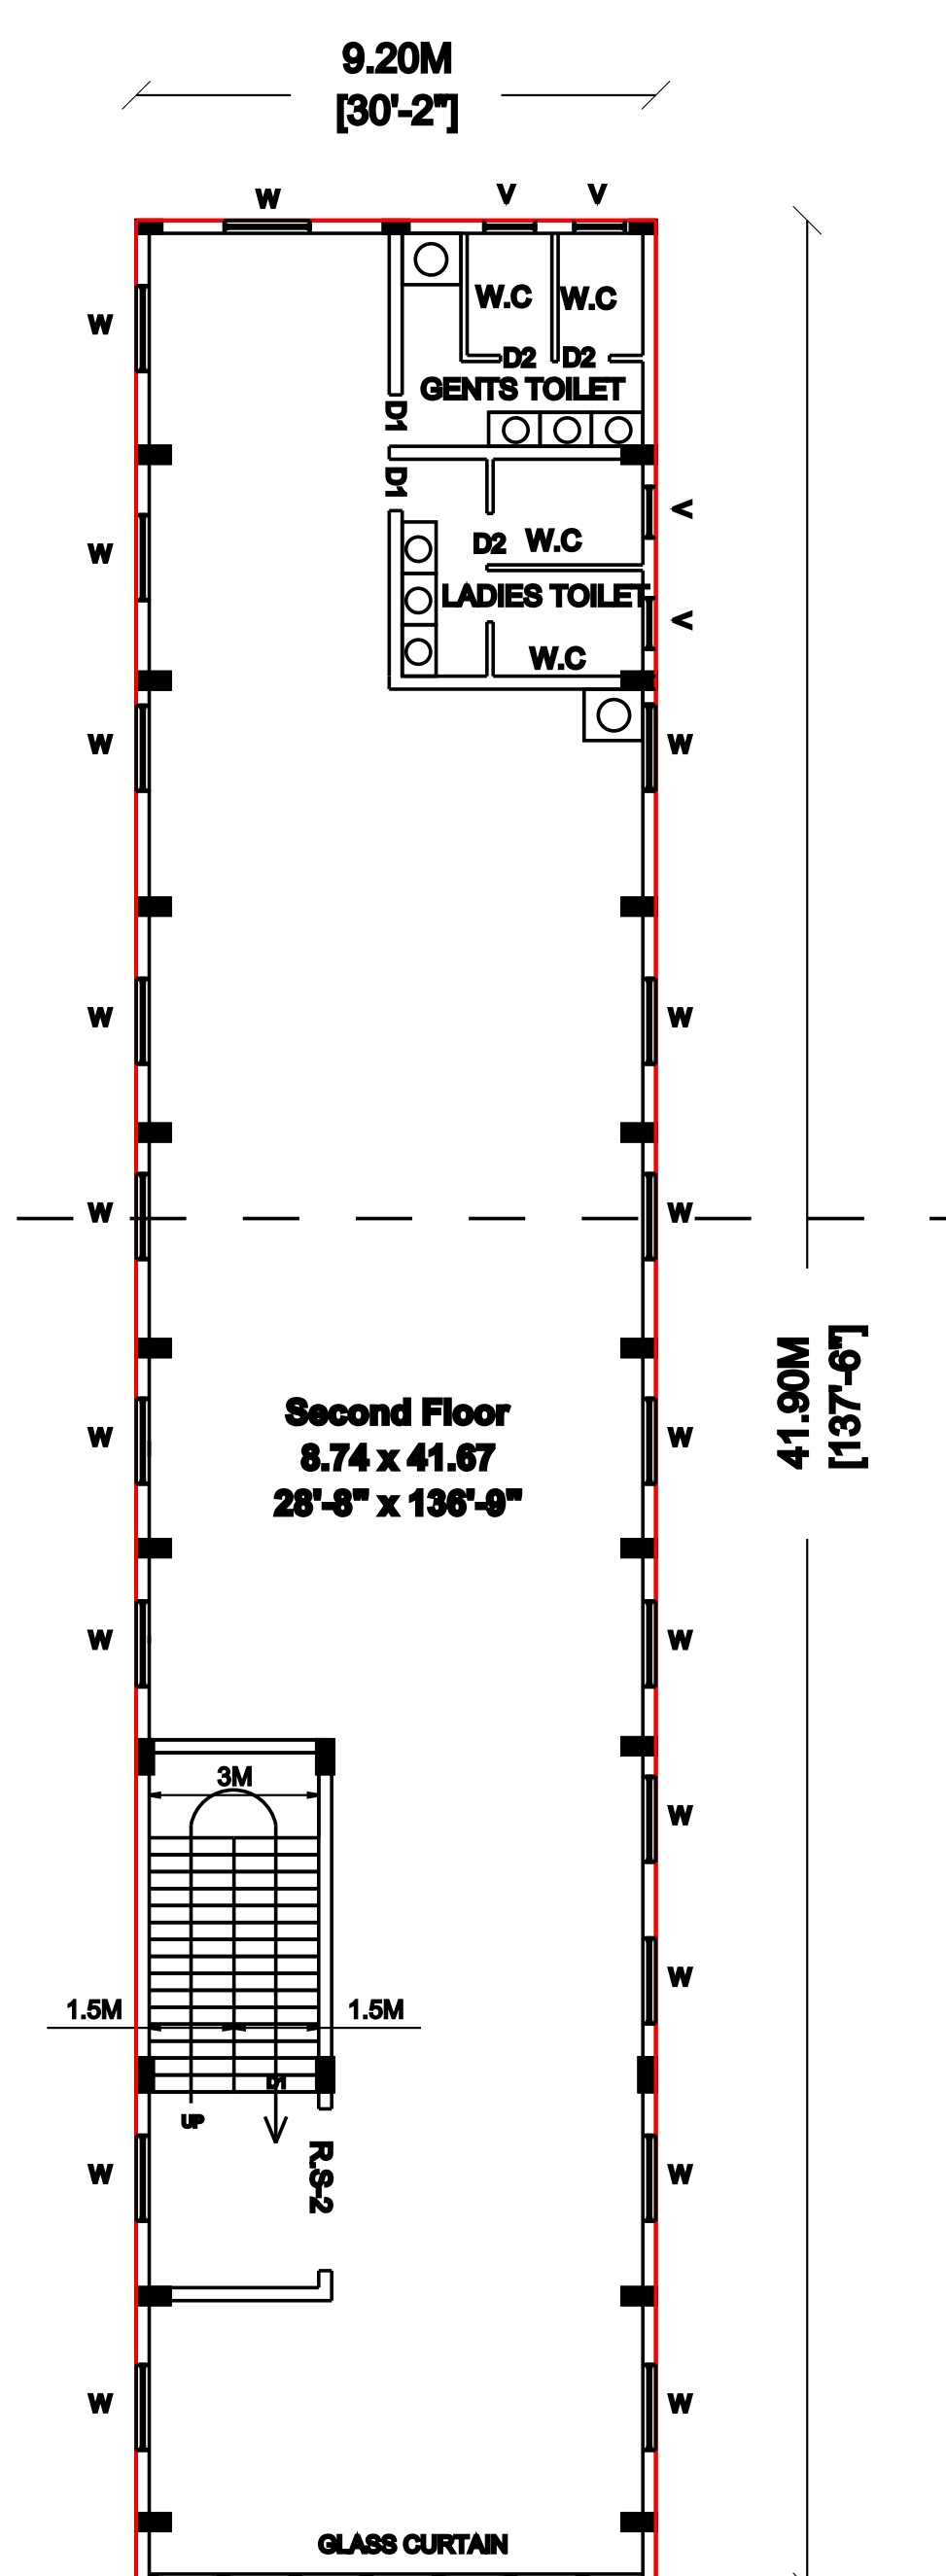


SECOND FLOOR PLAN

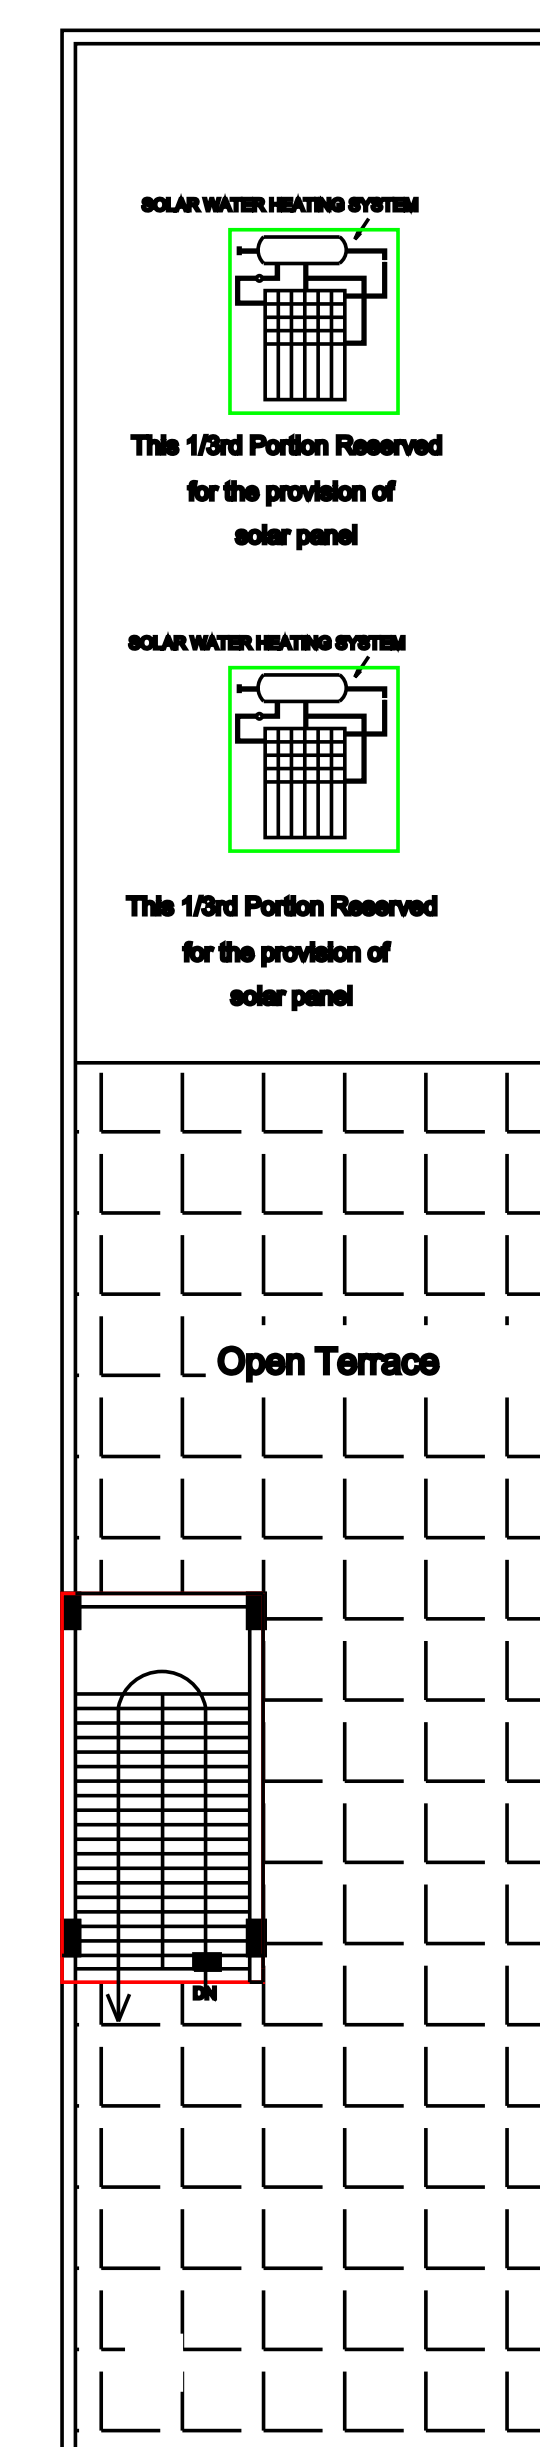


TERRACE FLOOR PLAN


FOR OFFICE USE :

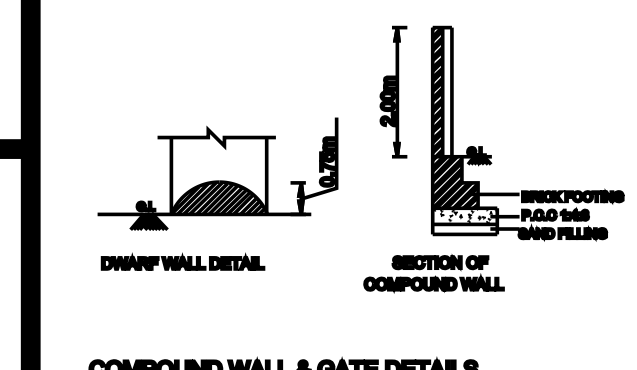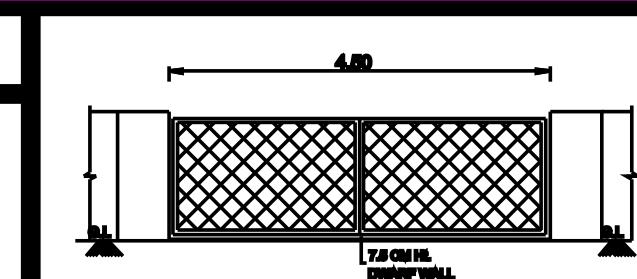


COMPOUND WALL & GATE DETAILS

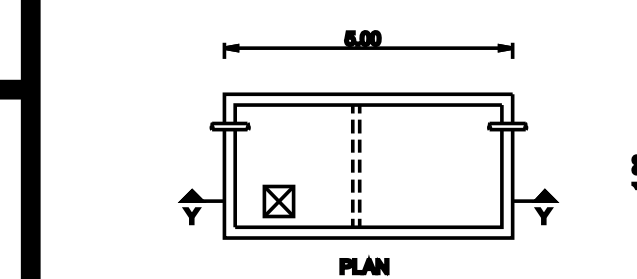


PLAN

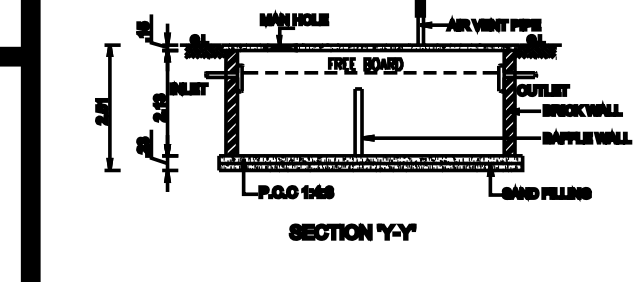


SEPTIC TANK DETAIL 8

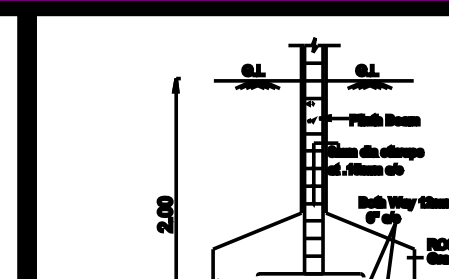

SECTION OF PO

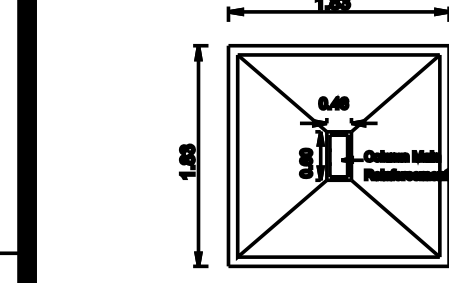


FOUNDATION

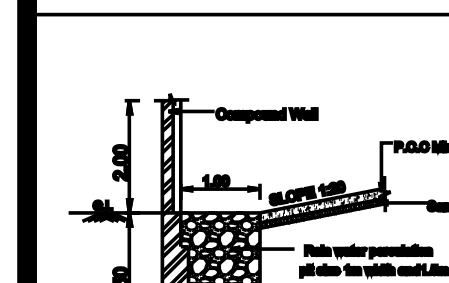

1.50		粗砂或砾石
------	---	-------



100

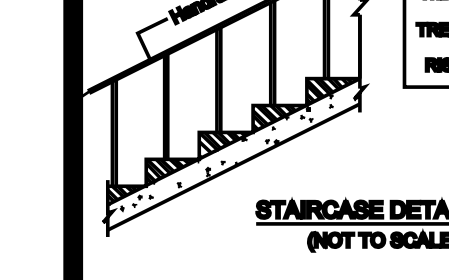[illegible]

NOTE:



1. CCTV CAMERA TO BE PROVIDED.
2. CENTRALIZED AIR - CONDITION SYSTEM TO BE PROVIDED.
3. FIRE EXTINGUISHER AND FIRE ALARMS TO BE PROVIDED.
4. LOUVERED WINDOWS TO BE PROVIDED IN EACH FLOOR.
5. RAMP 1:12 SLOPE TO BE PROVIDED.

 - FIRE EXTINGUISHER - FIRE ALARM - CCTV CAMERA

12 of 12



STAIRCASE DETAIL

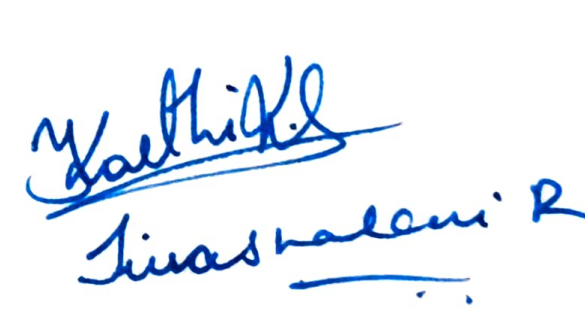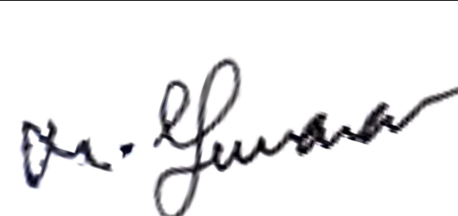SCALE 1 : 100			
ALL DIMENSIONS ARE IN "METER"			
AREA DETAILS :-			In Sq.m
SITE AREA AS PER DOCUMENT			800.00
SITE AREA AS PER PATT A			800.00
SUPERIMPOSED PLOT AREA			800.00
FLOOR DETAILS	FSI AREA	NON-FSI AREA	TOTAL BUILDUP AREA
STILT FLOOR AREA	21.68	385.48	407.17
FIRST FLOOR AREA	385.48	-	385.48
SECOND FLOOR AREA	385.48	-	385.48
TOTAL	792.65	385.48	1178.13
FLOOR SPACE INDEX [F.S.I.] = 792.65 / 800.00			= 1.32
PLOT COVERAGE [P.C.] =(385.48 / 800.00)x100			= 64.24 %
SCHEDULE OF JOINERIES			IN METRE
RS-1	ROLLING SHUTTER	5.03 X 2.44	
RS-2	ROLLING SHUTTER	2.88 X 2.44	
D1	DOOR	0.91 X 2.13	
D2	DOOR	0.91 X 2.13	
W	WINDOW	0.78 X 2.13	
V	VENTILATOR	0.90 X 0.80	
PARKING DETAILS		REQUIRED	PROVIDED
CAR PARKING		07 Nos.	07 Nos.
TWO WHEELERS		27 Nos.	27 Nos.
COLOUR REFERENCES			
SITE BOUNDARY SHOWN IN			
PROPOSED BUILDING SHOWN IN			
DRIVEWAY SHOWN IN			
EXISTING ROAD SHOWN IN			
APPLICANT SIGNATURE :			
			
REGISTERED GEO - TECHNICAL ENGINEER :			
 Er. M.YUVARAJ, M.E., M/GS Geotechnical Engineer Reg. No: CGR/M/AG/1/2019/06/004 yuvaraj.ge@gmail.com Ph:9789319626			
REGISTERED STRUCTURAL ENGINEER :			
 E.R.SRINIVASAN,B.E.,M.B.A., Registered Engineer DTCP Reg.No:BE/GR/1/ND/04/2024/078 Reg. No: RSEG-OR-INDIAUGUST-2024-028 DTCP Valluram Regional Office(VDI) Cell: 9101771257, 9150370354			
REGISTERED ENGINEER :			
 E.R.SRINIVASAN,B.E.,M.B.A., Registered Engineer DTCP Reg.No:BE/GR/1/ND/04/2024/078 Reg. No: RSEG-OR-INDIAUGUST-2024-028 DTCP Valluram Regional Office(VDI) Cell: 9101771257, 9150370354 @grvconstructionsingee@gmail.com			