
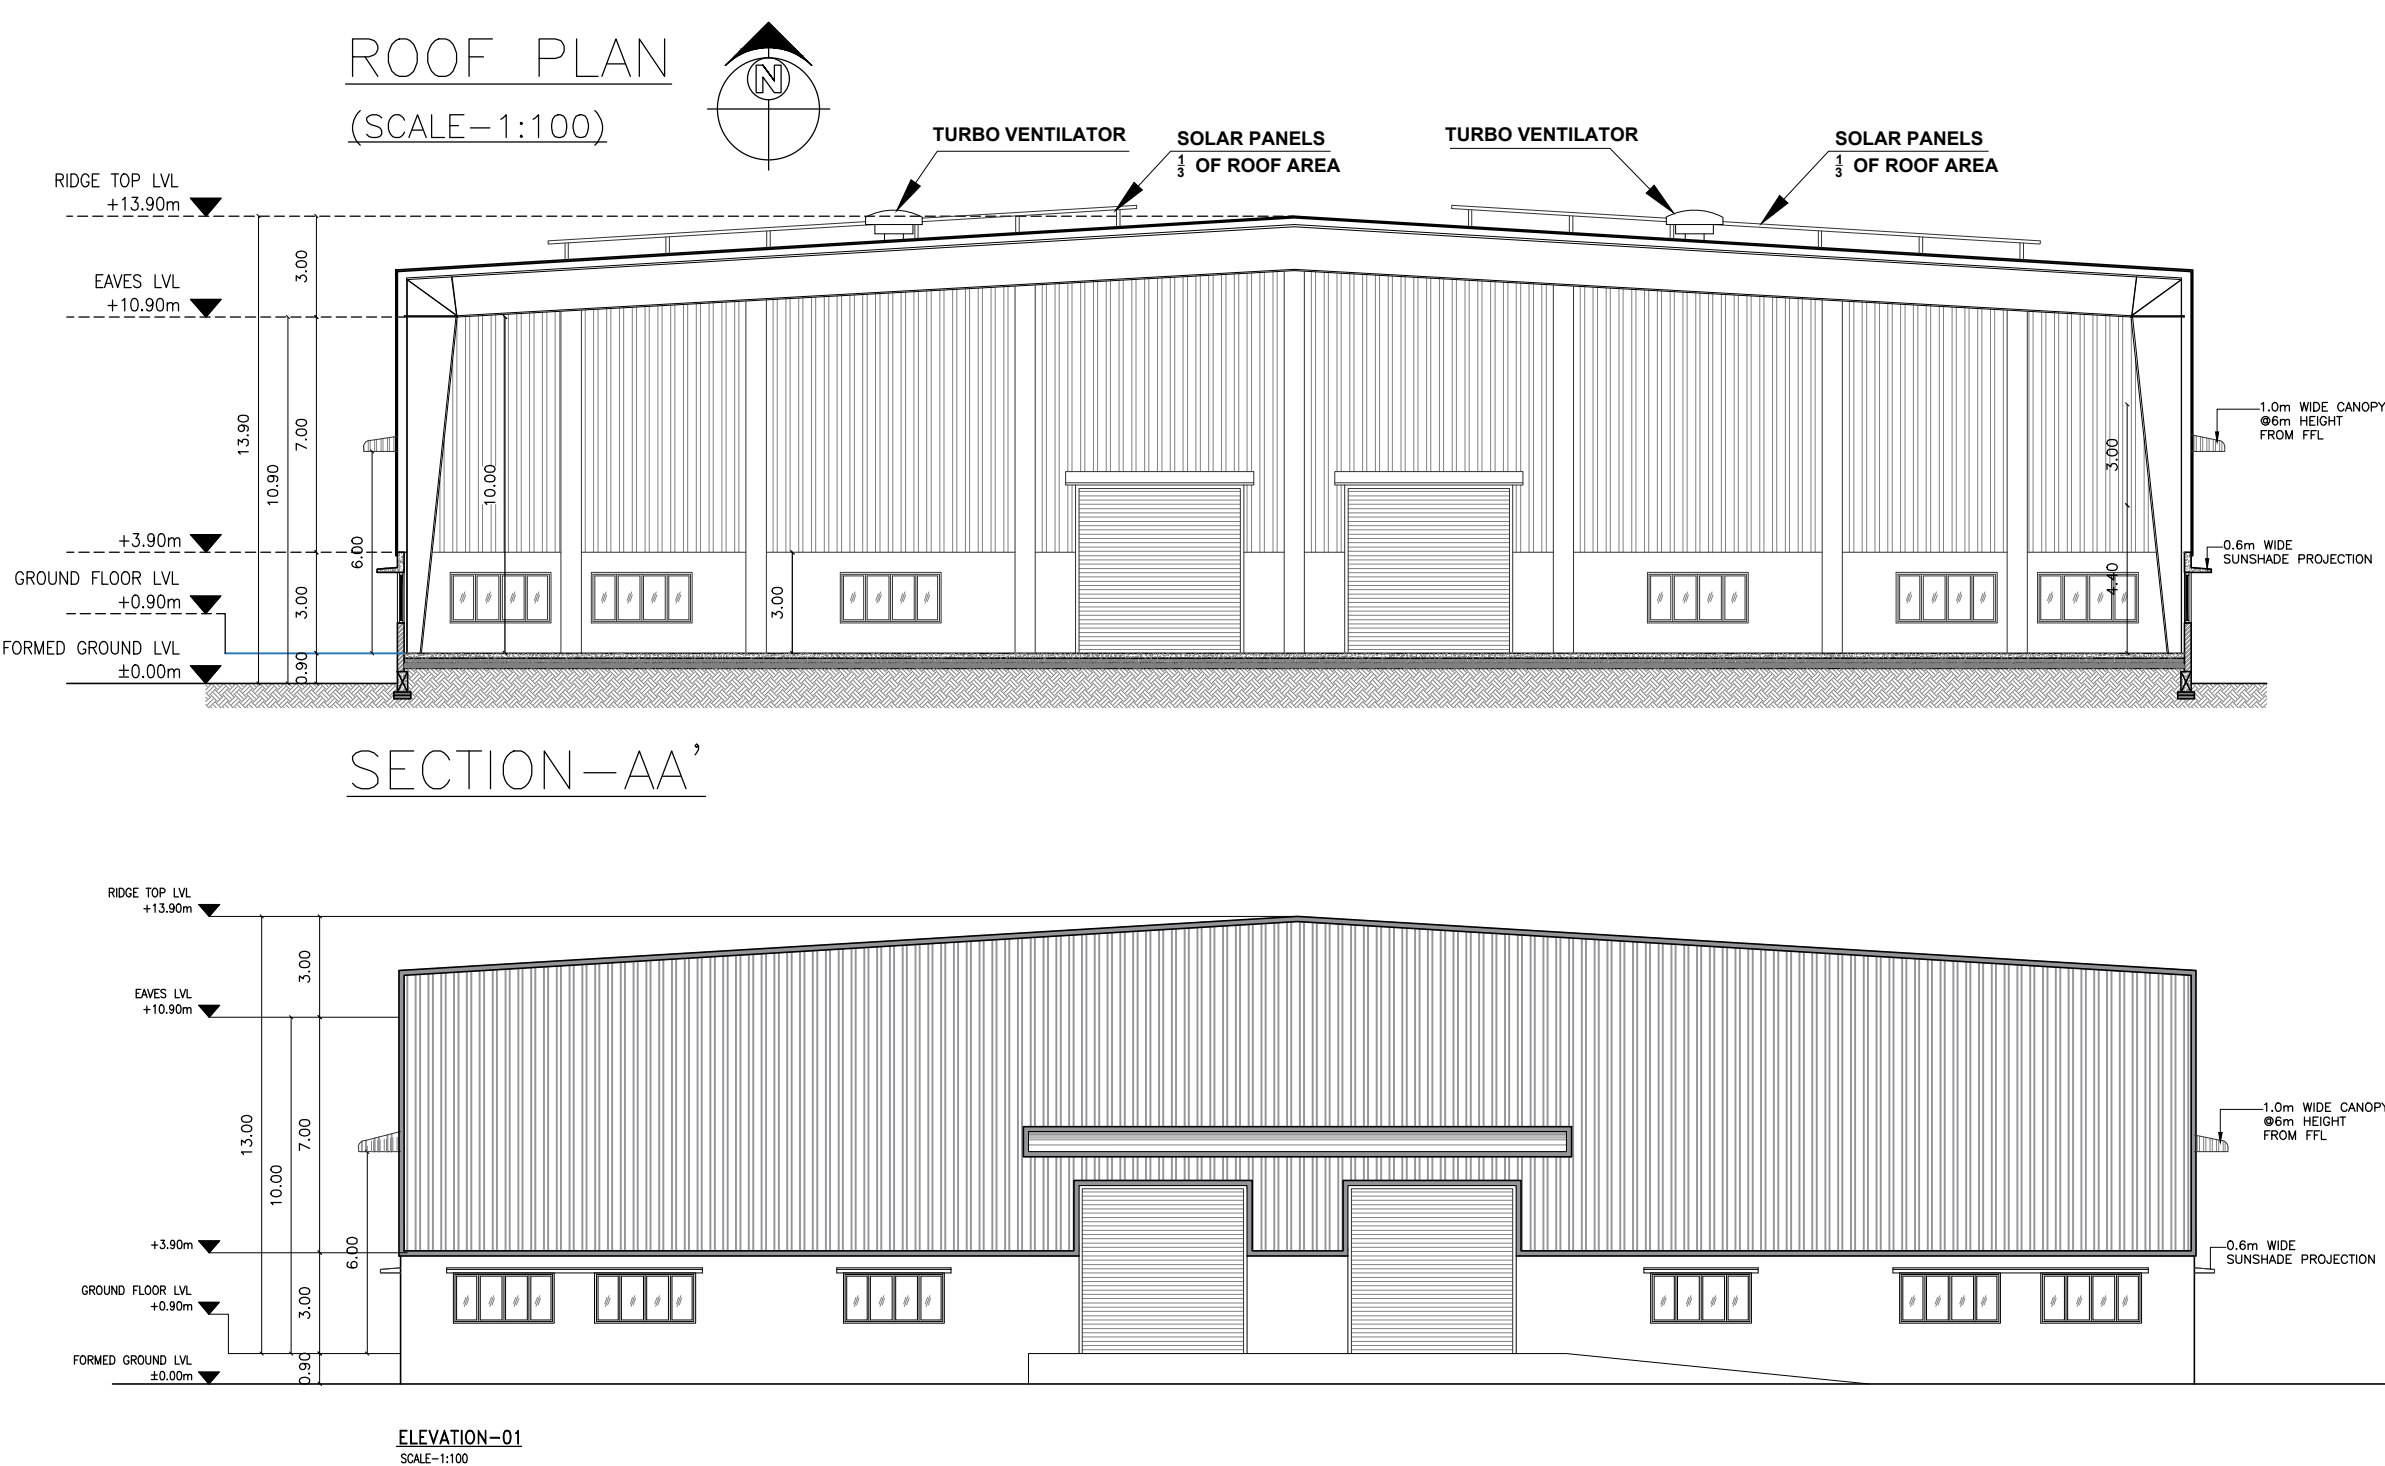
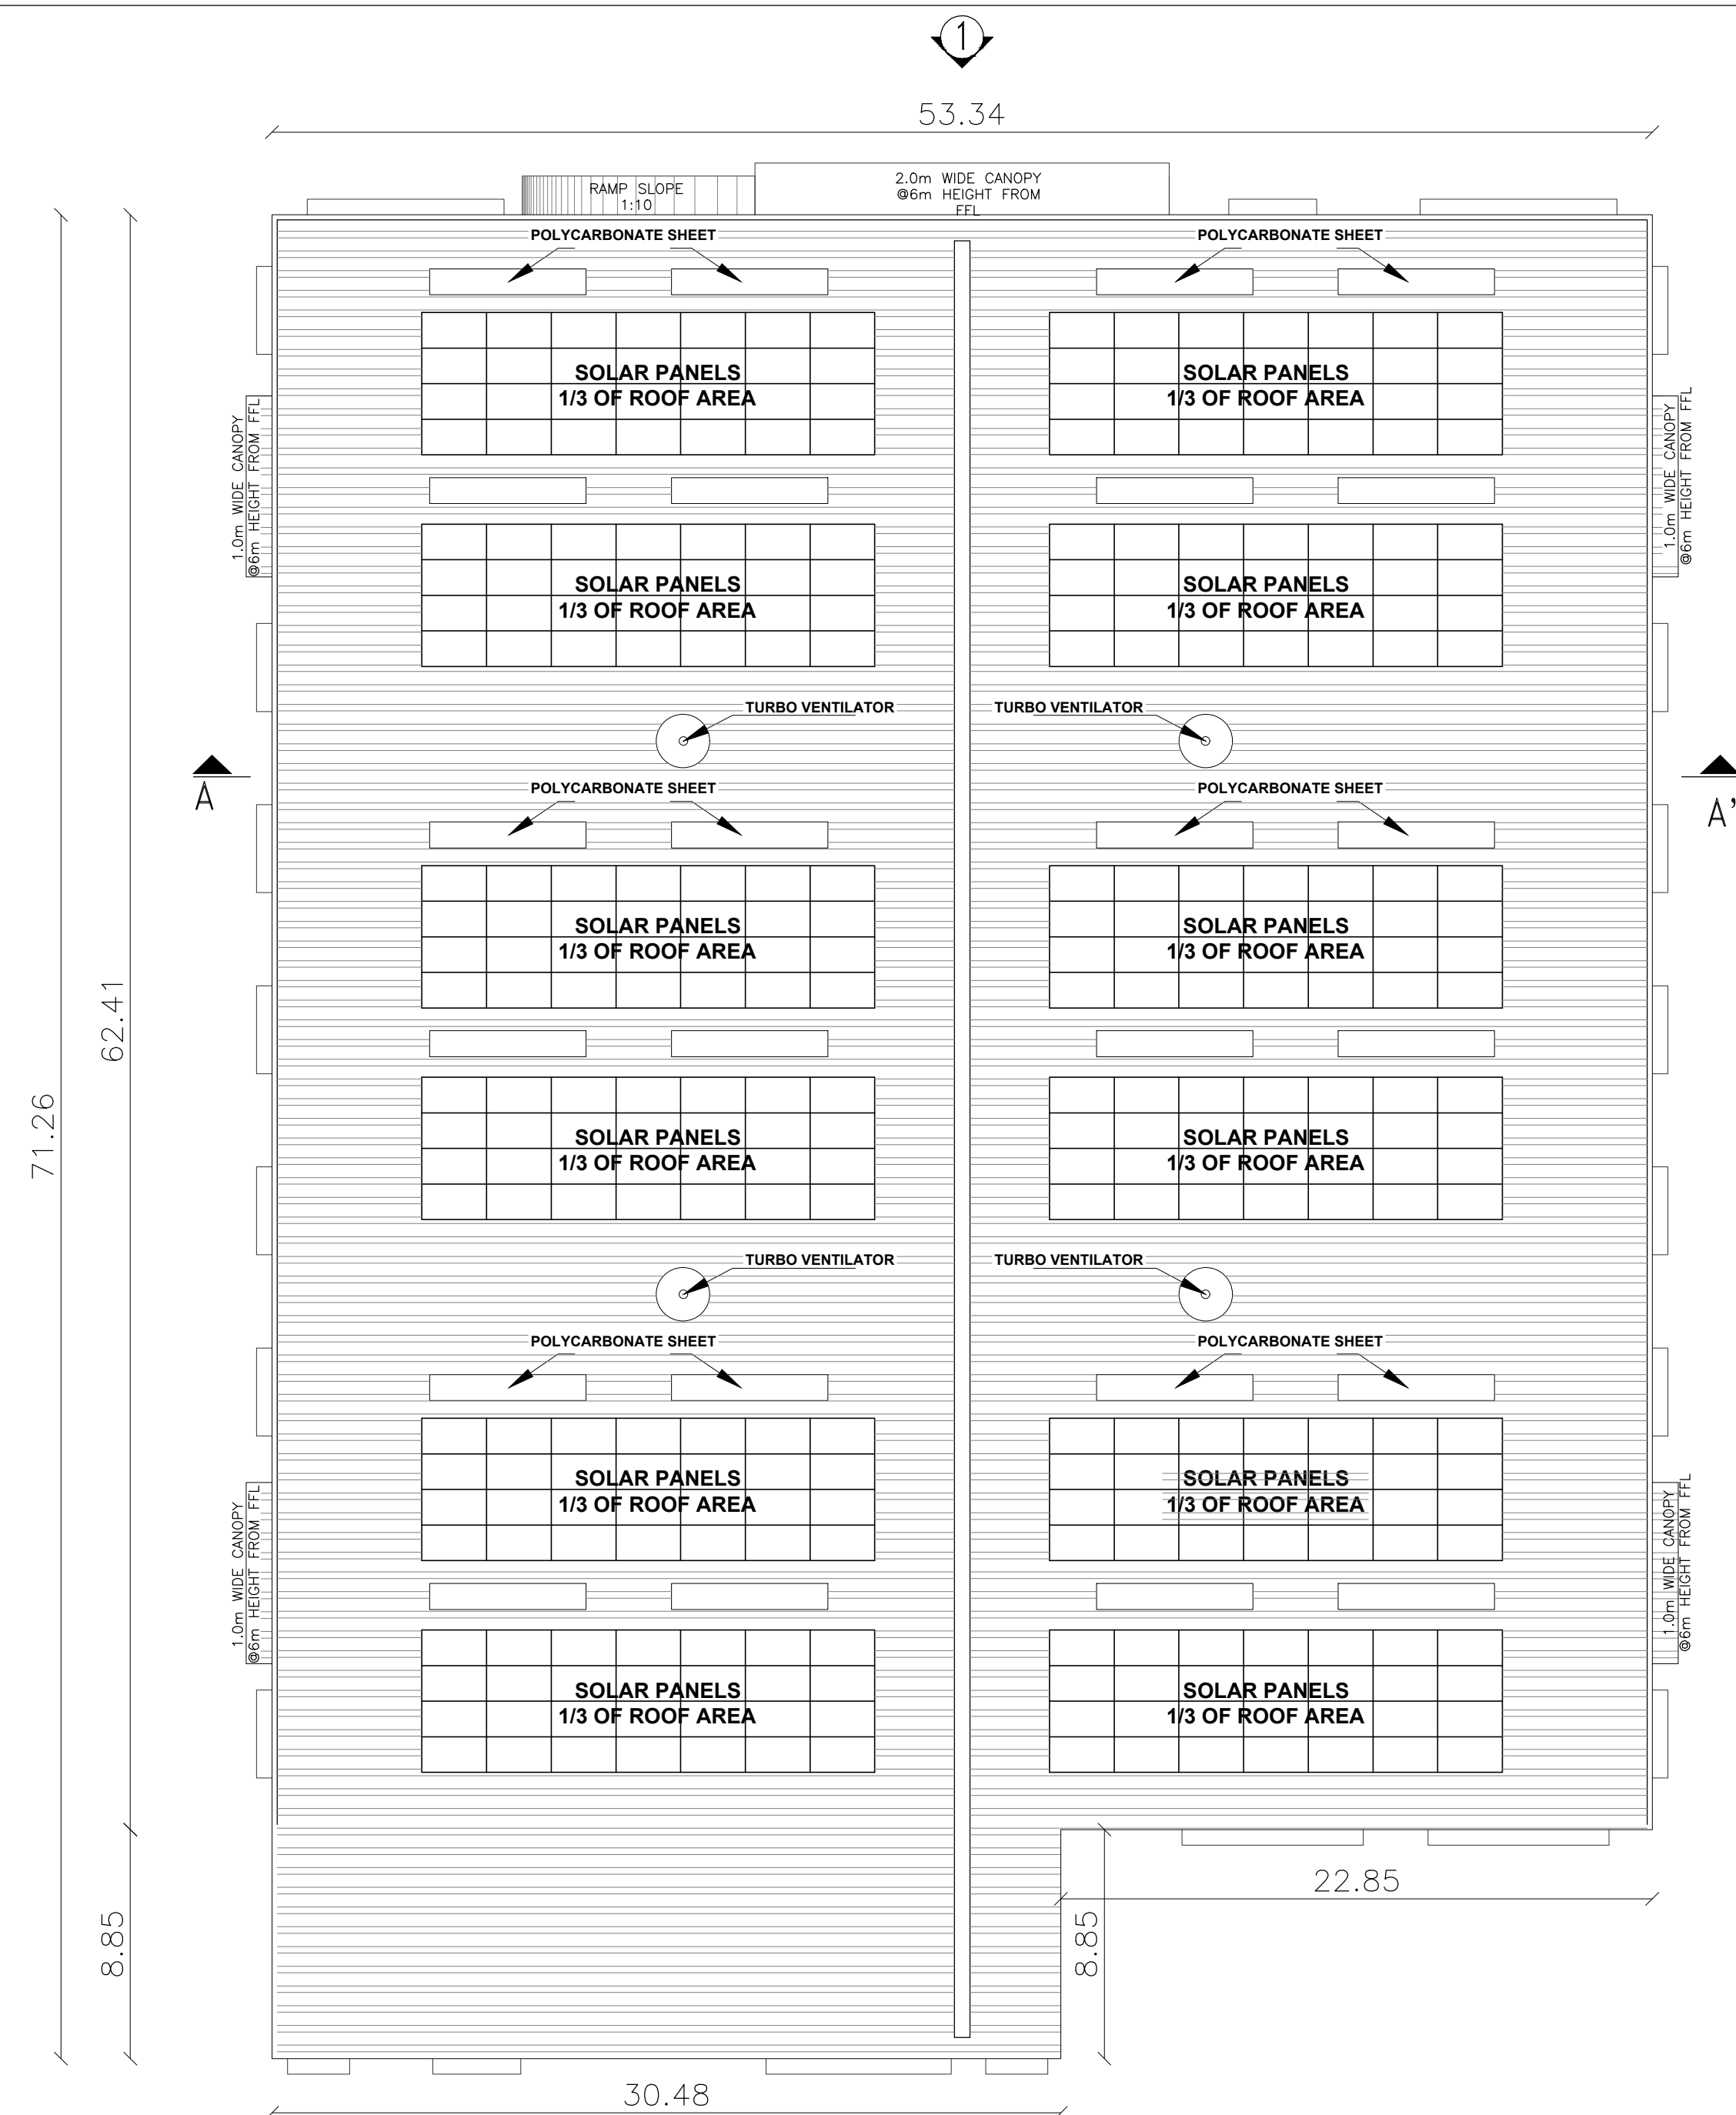
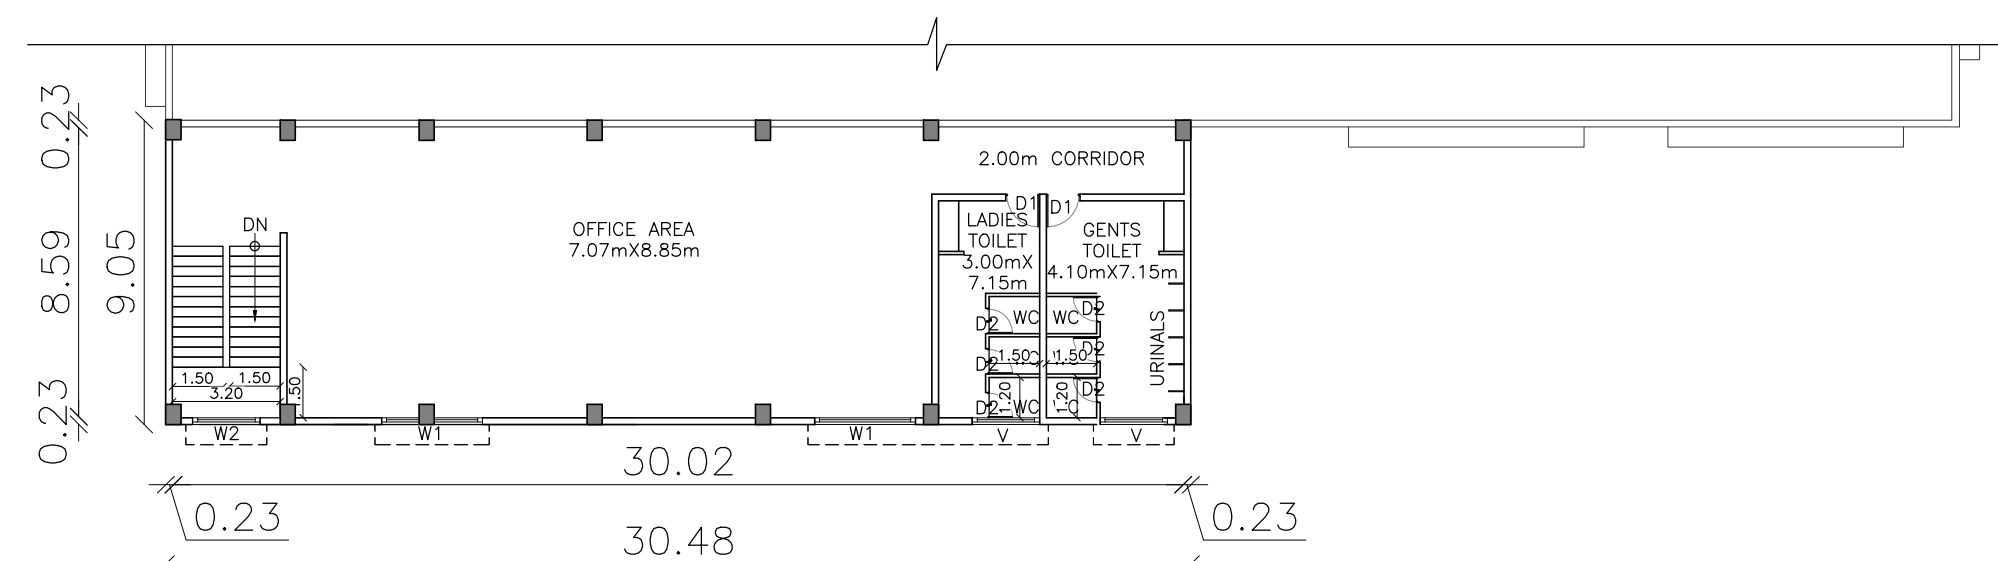


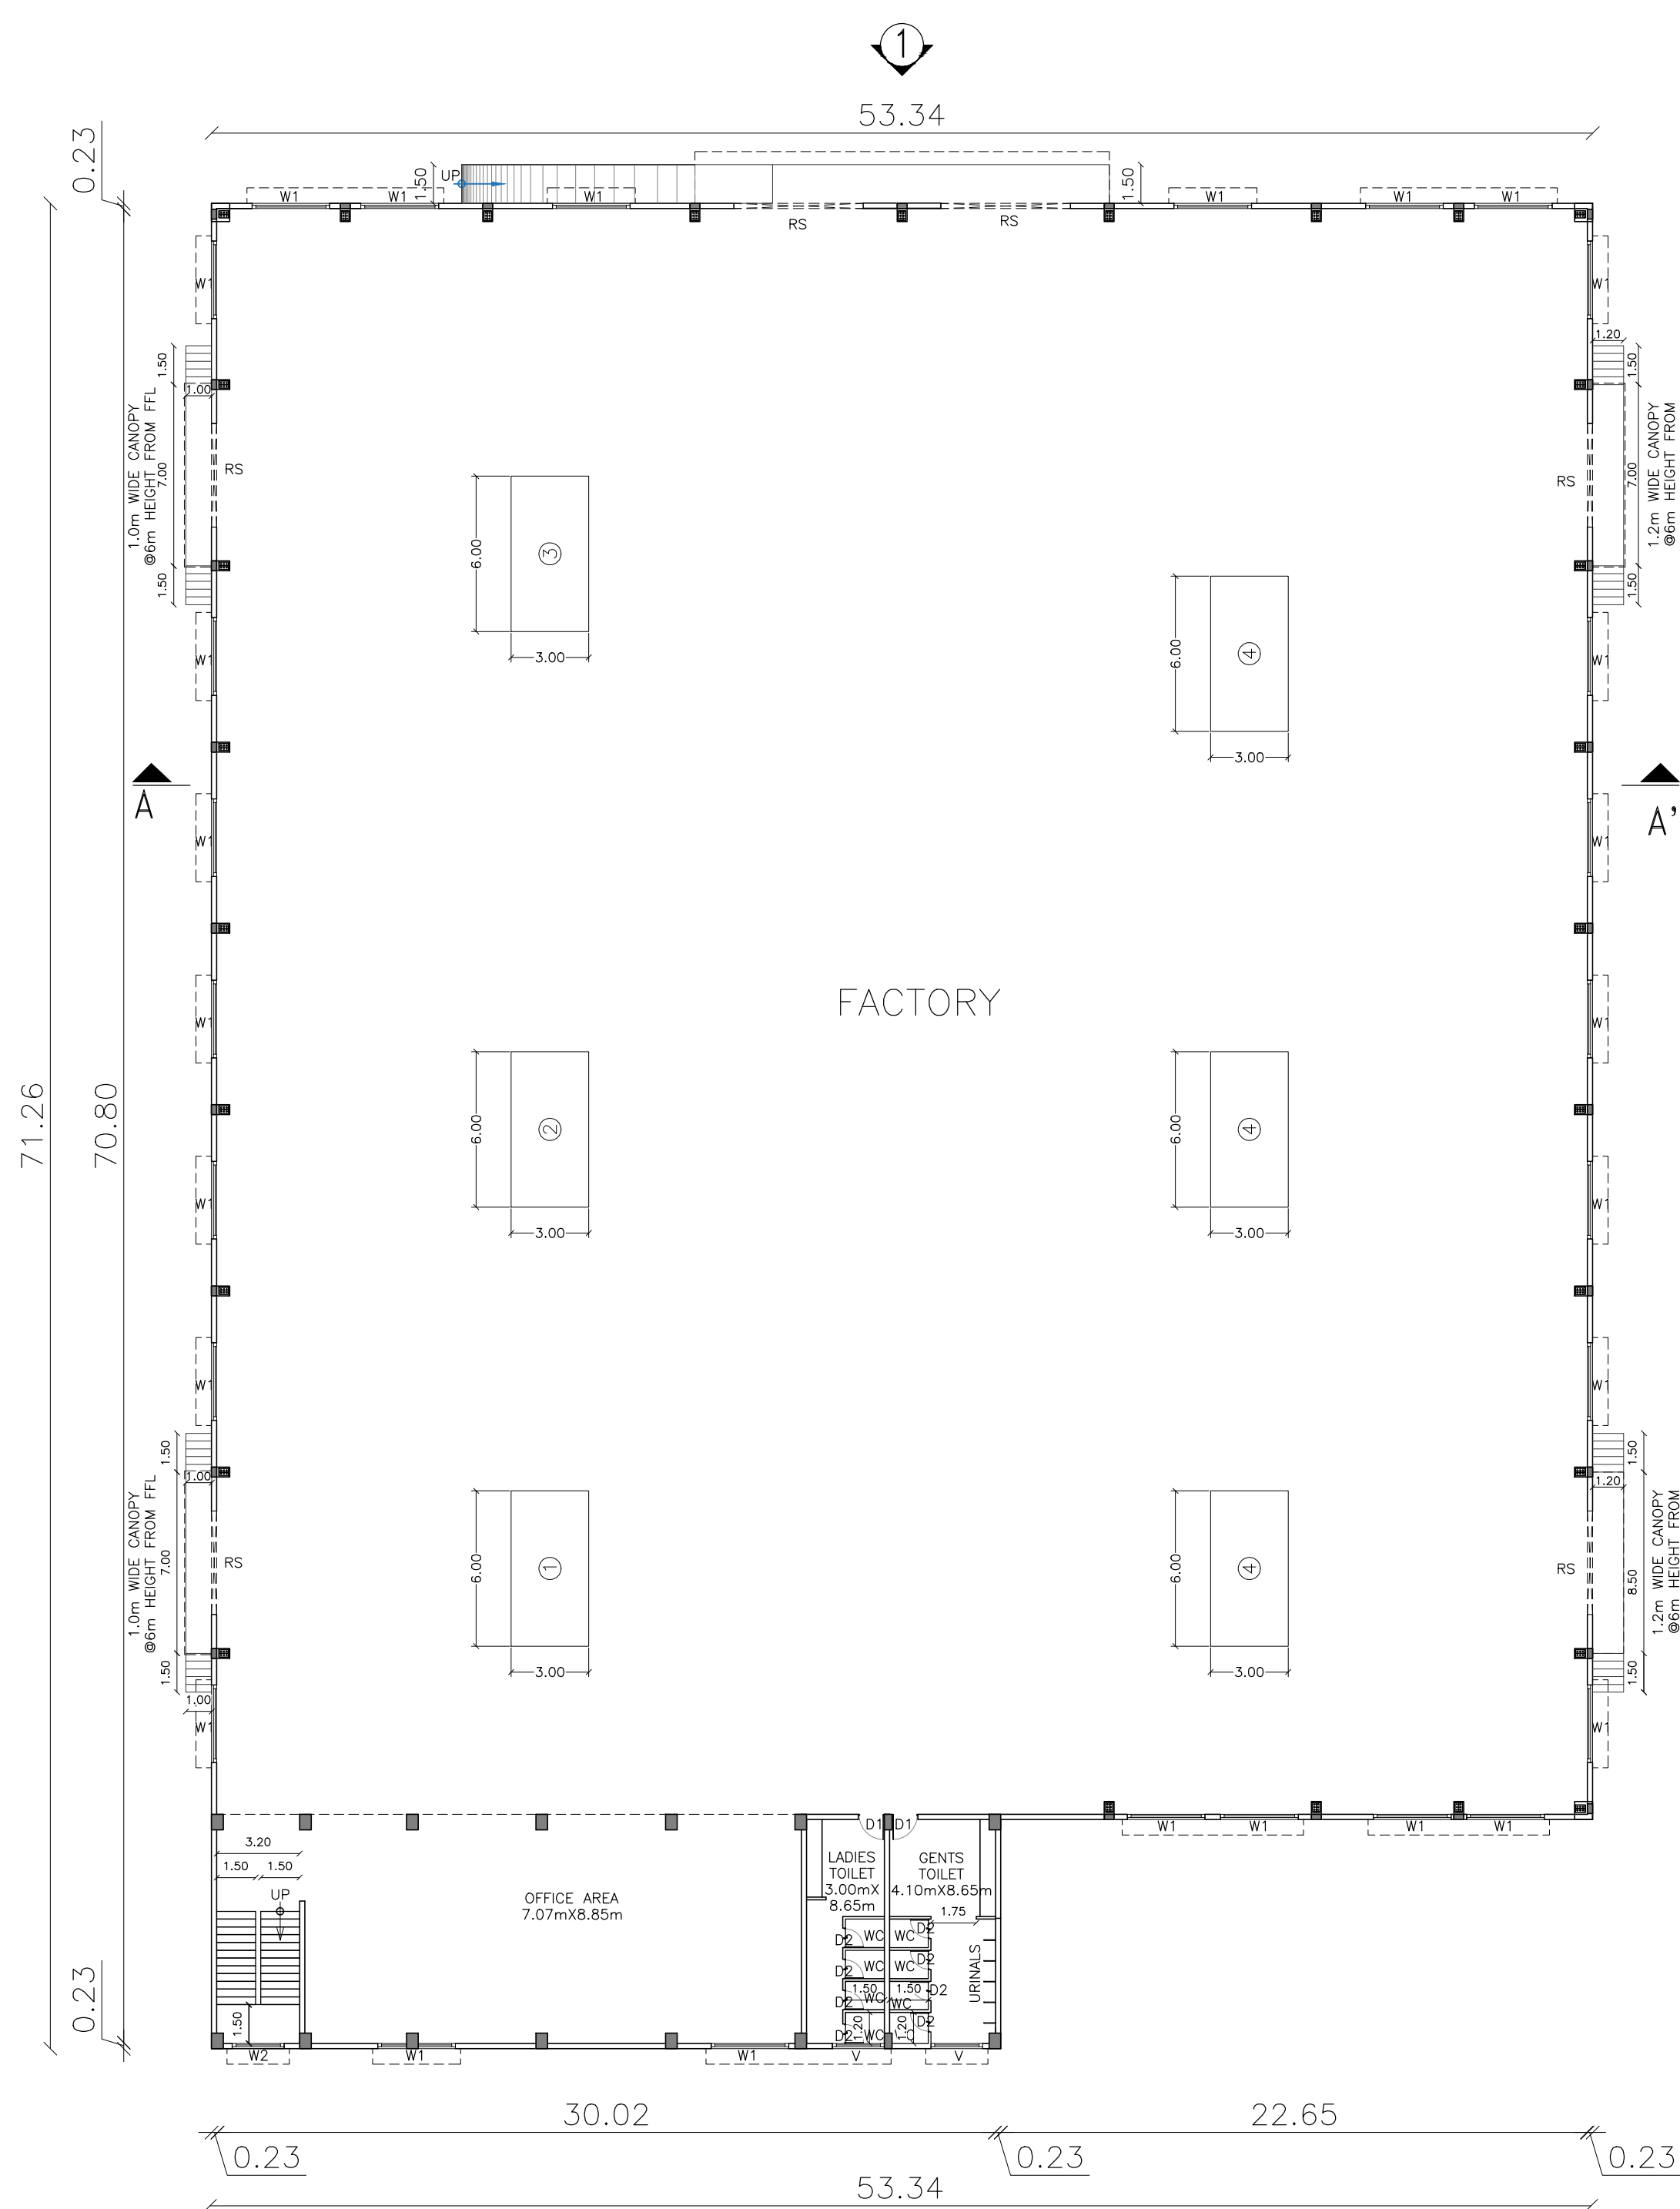

PLAN SHOWING THE PROPOSED CONSTRUCTION OF
FACTORY BUILDING AT PLOT NO. S-03 FOR
M/S VSR INDUSTRIES S.NO. 22pt SIPCOT AEROSPACE
PARK (VALLAM VADAGAL) IN VALLAM-'A' VILLAGE,
SRIPERUMBUDUR TALUK, KANCHEEPURAM DISTRICT.

SIPCOT LAYOUT : ம.வ.ந.ஊ.து.இ(கா.மா) எண்.114/2021
APPROVAL NO : (REVISION OF ம.வ.ந.ஊ.து.இ(கா.மா) எண்.82/2021)

INDUSTRIAL CATEGORY : GREEN
(29 - ASSEMBLY OF AIR COOLERS & CONDITIONERS)
AS PER ANNEXURE -VI

NOTE : ALL DIMENSIONS AREA IN METER

AREA STATEMENT DETAILS	
SITE AREA	: 6070.28 Sq.mt

SCHEDULE OF JOINERIES

S.NO	TYPE	DESCRIPTION	SIZE(IN. M)
01	RS	ROLLING SHUTTER	5.00 x 5.00
02	DD	MAIN DOOR	2.40 x 2.10
03	D1	DOOR	1.20 x 2.10
04	D2	DOOR	0.75 x 2.10
05	W	WINDOW	3.00 x 1.50
06	V	MECHANICAL VENTILATOR	2.00 x 0.60

Machinery Details			

MACHINERY DETAILS				
S.No	DESCRIPTION	QTY	HP	TOTAL HP
01	BOLT FITTING	1	20	20
02	NUT RUNNER	1	40	40
03	TORQUE TIGHT & MOVEMENT CHECK	1	240	240
04	SPRING POSITIONING CENTRE	3	200	600
05	LIGHTING LOAD	-	120	0
TOTAL HP			900.00	

HORSE POWER DETAILS : 900.00 HP

NO OF WORKERS DETAIL :

DESCRIPTION	MALE	FEMALE	TOTAL
FACTORY WORKERS	75	25	100
WATER REQUIREMENT = 20,000 LITRES PER DAY			

MECHANICAL VENTILATION AND FIRE PROTECTION SYSTEM PROVIDED FOR ENTIRE BUILDING
--

DRAWING TITLE:

FLOOR PLAN, SECTION & ELEVATION

COLOR INDEX:		REFERENCE :	
PROPOSED		SCALE 1:100	
BOUNDARY			
ROAD			
DRIVEWAY			

APPLICANT :

For VSR INDUSTRIES

[Signature]



Partner


REGISTERED STRUCTURAL ENGINEER :

Er. S. MOSES ARANGANATHAN
B.E., M.E.(Struct.) FIE, FIA(Struct.), FIV,
DTCIP Registered Structural Engineer-Grade-I (SE)
DTCIP Reg.No. CGLRGN/SE/Gr-I/2019/08/033
Madurai-voyal, Chennai-600095
Email Id: moessesomu@gmail.com

REGISTERED ARCHITECT :


P.PRABHAKARAN, M.Arch.
REGISTERED ARCHITECT
C.O.A No. : CA/2003/32226
Kattupakkam, Chennai - 600 056.

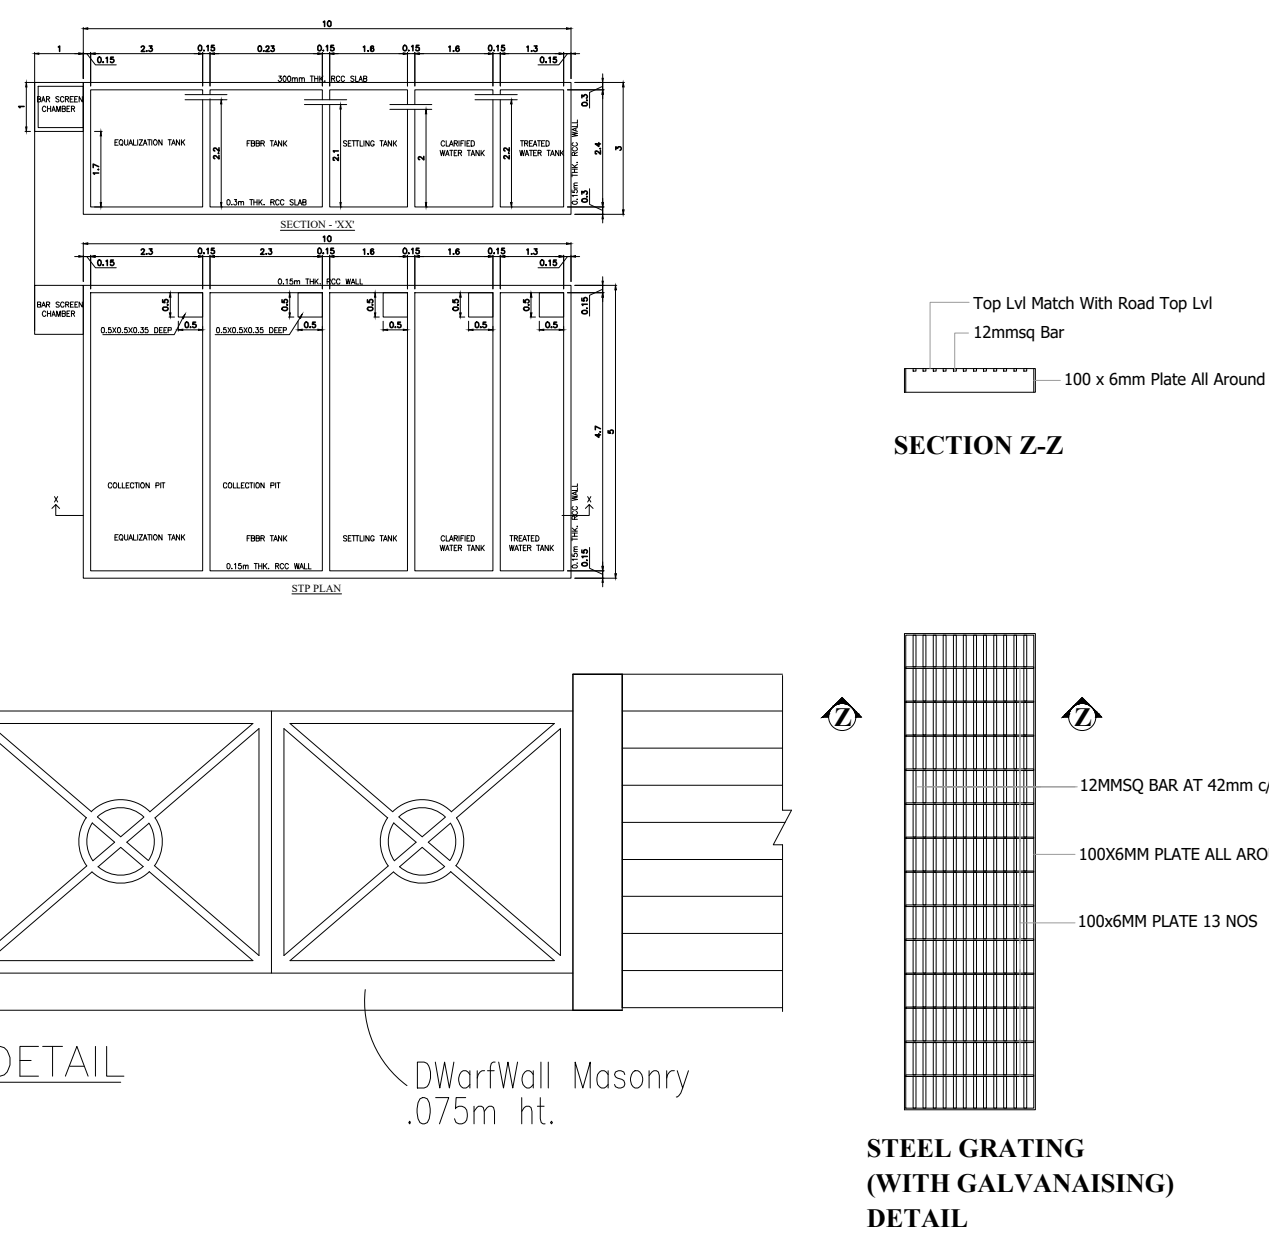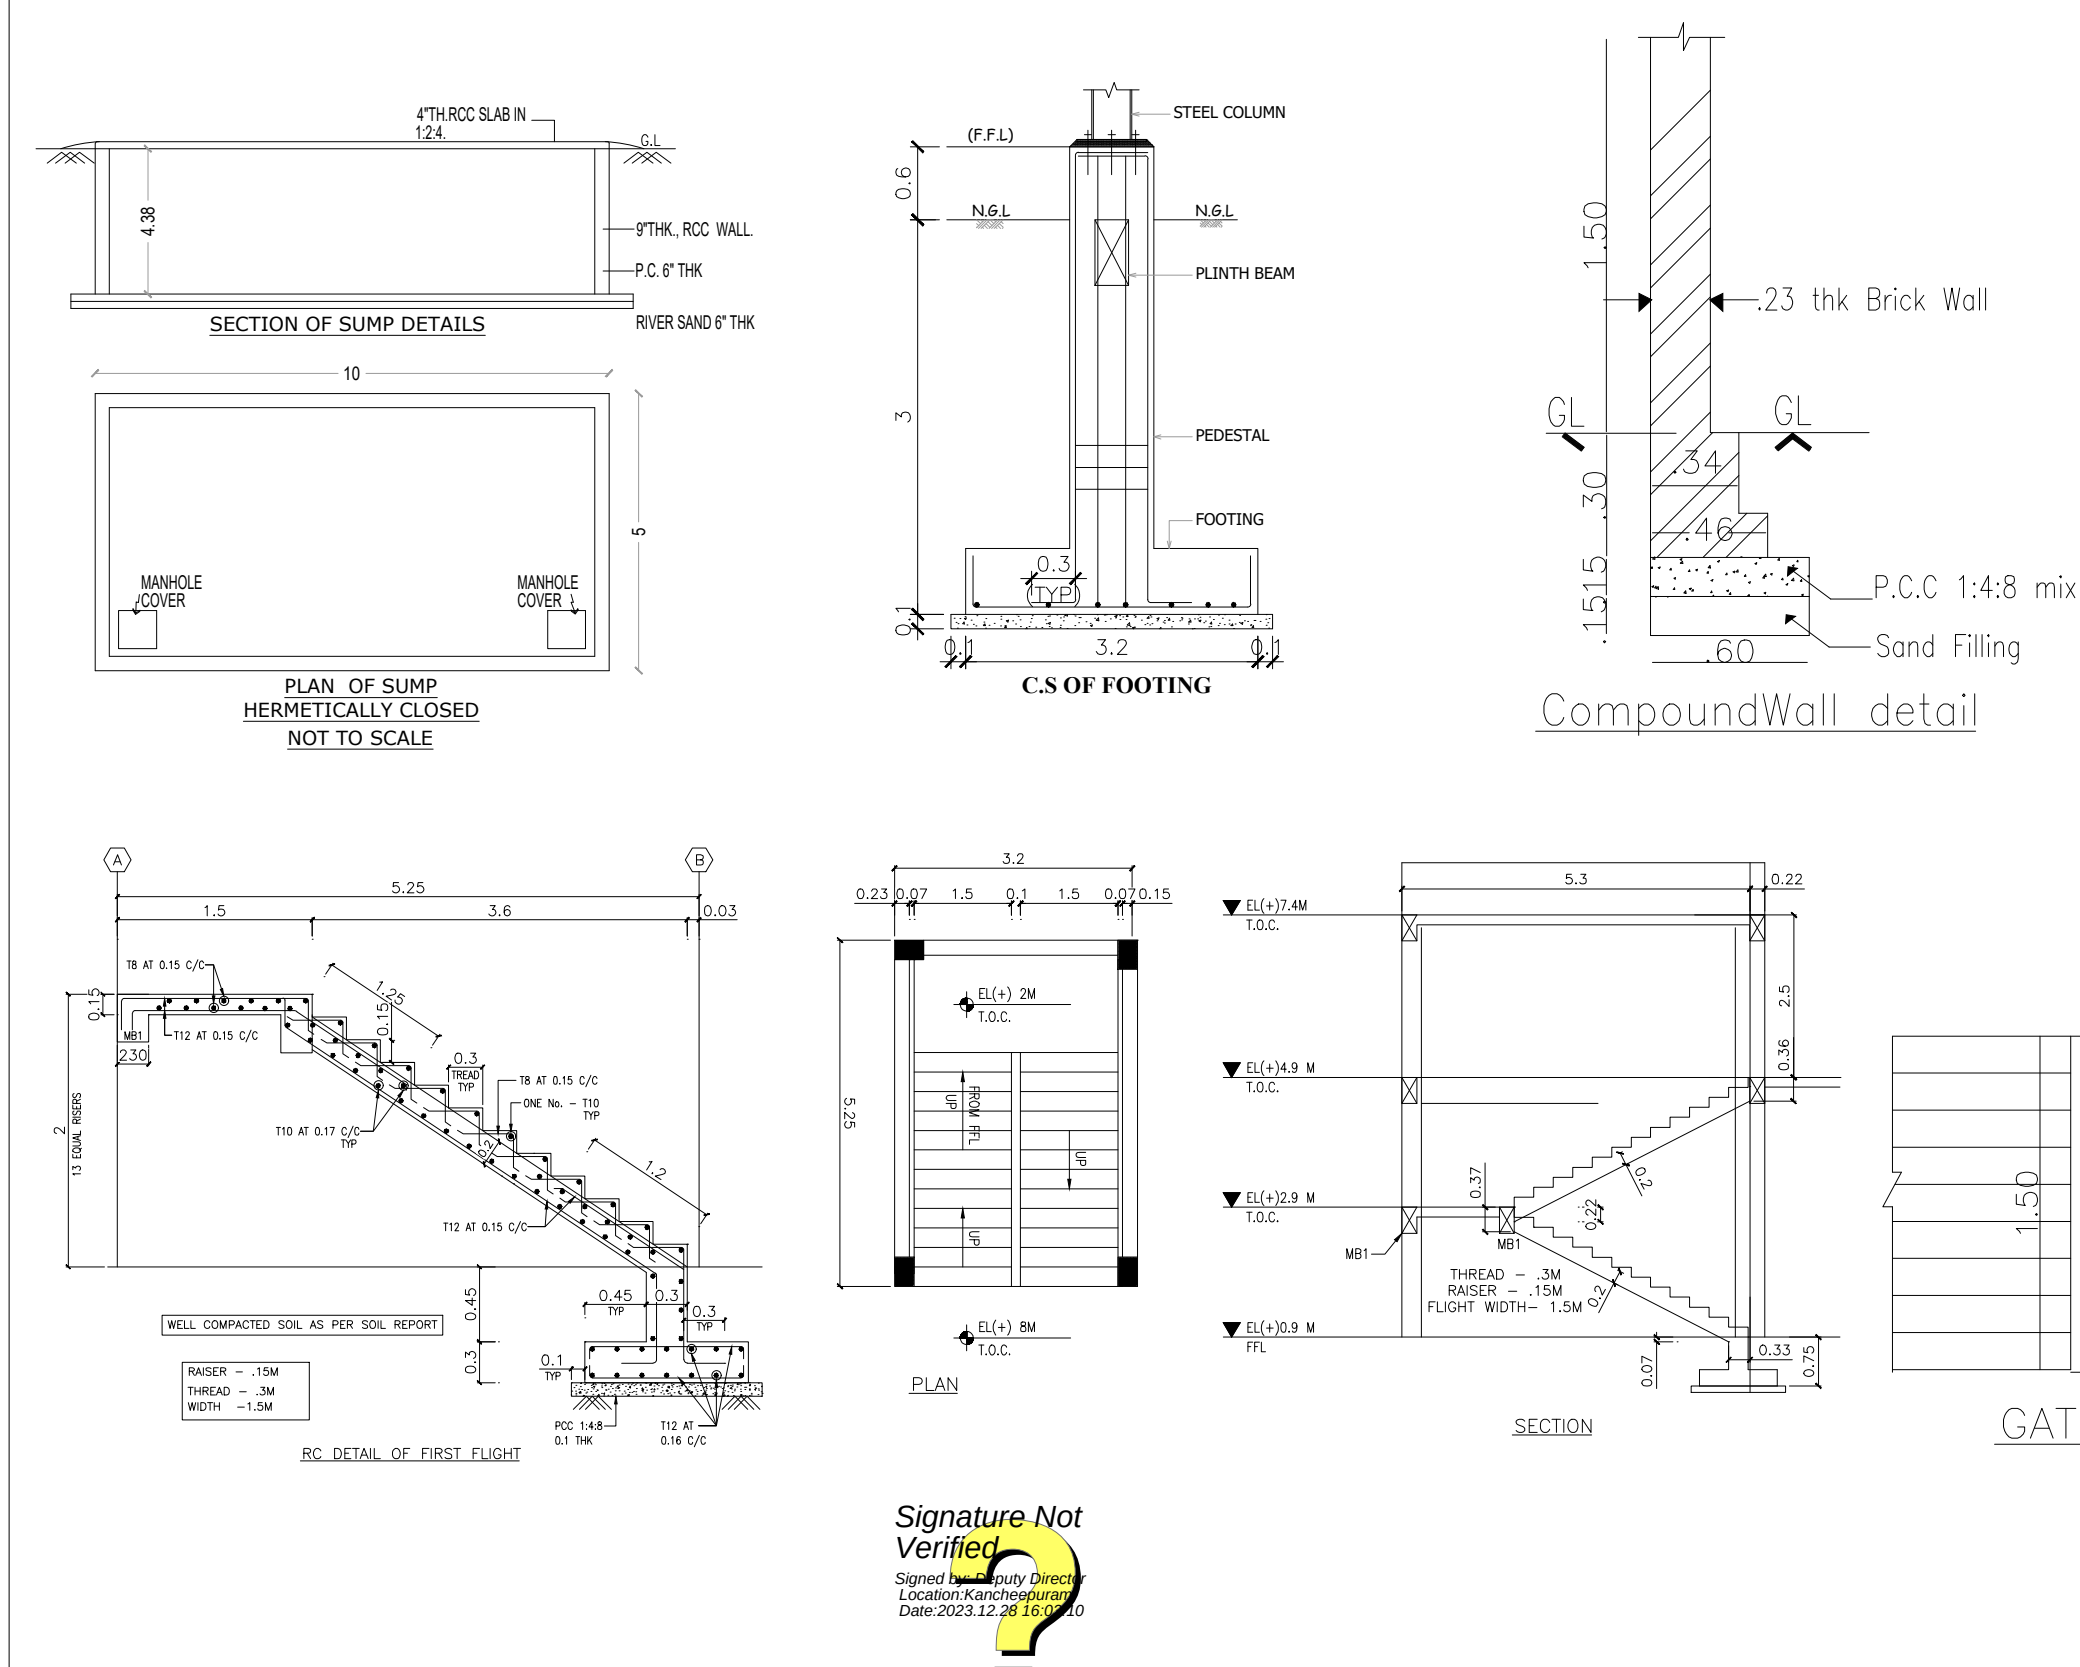

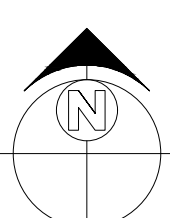DRAWING TITLE:	
SITE PLAN, KEY PLAN & ANCILLARY STRUCTURE	
COLOR INDEX:	REFERENCE :
PROPOSED BOUNDARY ROAD DRIVEWAY	SCALE 1:250 

For VSR INDUSTRIES

[Signature]

Partner

Er. S. MOSES ARANGANATHAN
B.E., M.E(Struct.) FIE, FIA(Struct.), FIV,
DTCP Registered Structural Engineer-Grade-I (SE)
DTCP Reg.No. CGLRG/NS/Gr-I/2019/08/033
Madurevoyal, Chennai-600095
Email Id: mosessomu@gmail.com

P. T. Nubla

P.PRABHAKARAN, M.Arch.
REGISTERED ARCHITECT
C.O.A No. : CA/2003/32226
Kattupakkam, Chennai - 600 056.