

PLAN SHOWING THE PROPOSED CONSTRUCTION OF RCC ROOF
 APARTMENT BUILDING IN S.F.Nos:34/5, 34/7, 34/9, OF
 MALLAPPADI VILLAGE, MALLAPPADI PANCHAYAT,
 BARGUR PANCHAYAT UNION, BARGUR TALUK, KRISHNAGIRI DISTRICT.

ALL DIMENSIONS
 ARE IN "METER"

SCALE 1:100



Area Details

Particulars	Total Building Area Sq.mt	Deduction Area Sq.mt	Non FSI Area Sq.mt	Total FSI Area Sq.mt
Area of Ground Floor	358.43	4.76	-	353.68
Area of Ground Floor (Parking Area)	633.76	-	633.76	-
Area of First Floor	992.19	21.43	-	970.76
Area of Second Floor	992.19	21.43	-	970.76
Area of Third Floor	665.76	14.31	-	651.45
Area of Lift Room	4.32	-	4.32	-
Area of Head Room	32.69	-	32.69	-
Area of Electrical Transformer Room	24.00	-	-	24.00
Total Area	3703.34	61.93	670.77	2970.65

Schedule of Joineries

M.D	Main Door	1.20 X 2.10
G.D	Glass Door	1.20 X 2.10
D	Door	0.90 X 2.10
D1	Door	0.75 X 2.10
O	Open	1.61 X 2.10
O1	Open	2.18 X 2.10
W	Window	1.70 X 2.00
W1	Window	0.90 X 1.60
W2	Window	0.90 X 1.60
W3	Window	0.56 X 2.00
S.W	Sliding Window	2.60 X 2.00
S.W1	Sliding Window	1.80 X 2.00
S.W2	Sliding Window	1.00 X 2.00
V	Ventilator	1.00 X 0.85
J	Jolly	6.00 X 0.60

NOTE:-

1. TOTAL SITE AREA - 2310.00 Sq.Mt.
2. TOTAL BUILDING HEIGHT - 13.92M.
3. SOLAR 1/3 AREA OF ROOF AREA - 341.00 Sq.Mt.
4. TOTAL NUMBER OF DWELLING - 24 , AREA - 2578.68 Sq.Mt.

KEY

EL	EMERGENCY LIGHT	FE	FIRE EXTINGUISHER
FA	FIRE ALARM	LB	LONG BELL
FH	FIRE HYDRANT	WD	DRINKING WATER

FIRE CERTIFICATE:-

Necessary Fire Extinguishers will be provided with the permission from the fire Service

OFFICE USE:-

APPLICANT


Er.M.VADIVEL, ME(Struct), AME, C.Eng(II), MISTE, AV, MCL, MISSE, MICA
 Consulting Civil Engineer, Chartered Engineer,
 TN.Govt. Registered Professional of DTCP,
 R.E-II-01/2023, R.S.E-II-21/2020, R.C.E-27/2020, R.D-06/2020,
 R.E.(G-3), DMC No.037/LS/2019/00004, CCMC No.004/2021,
DMV CONSTRUCTION,
 #19/17, 1st Floor, Annamalai Street, Near Municipality Office,
 Dharmapuri - 636701, Cell: 8122 101 282, 9443 101 282.
 E-Mail : dmvcconstruction.dp@gmail.com

REGISTERED CONSTRUCTION ENGINEER & REGISTERED DEVELOPER ENGINEER


Er.M.VADIVEL, ME(Struct), AME, C.Eng(II), MISTE, AV, MCL, MISSE, MICA
 Consulting Civil Engineer, Chartered Engineer,
 TN.Govt. Registered Professional of DTCP,
 R.E-II-01/2023, R.S.E-II-21/2020, R.C.E-27/2020, R.D-06/2020,
 R.E.(G-3), DMC No.037/LS/2019/00004, CCMC No.004/2021,
DMV CONSTRUCTION,
 #19/17, 1st Floor, Annamalai Street, Near Municipality Office,
 Dharmapuri - 636701, Cell: 8122 101 282, 9443 101 282.
 E-Mail : dmvcconstruction.dp@gmail.com

REGISTERED ENGINEER & REGISTERED STRUCTURAL ENGINEER

Er.M.Vadivel, ME(Struct), AME, C.Eng(II), MISTE, AV, MCL, MISSE, MICA, - D.M.V Construction - 8122 101 282

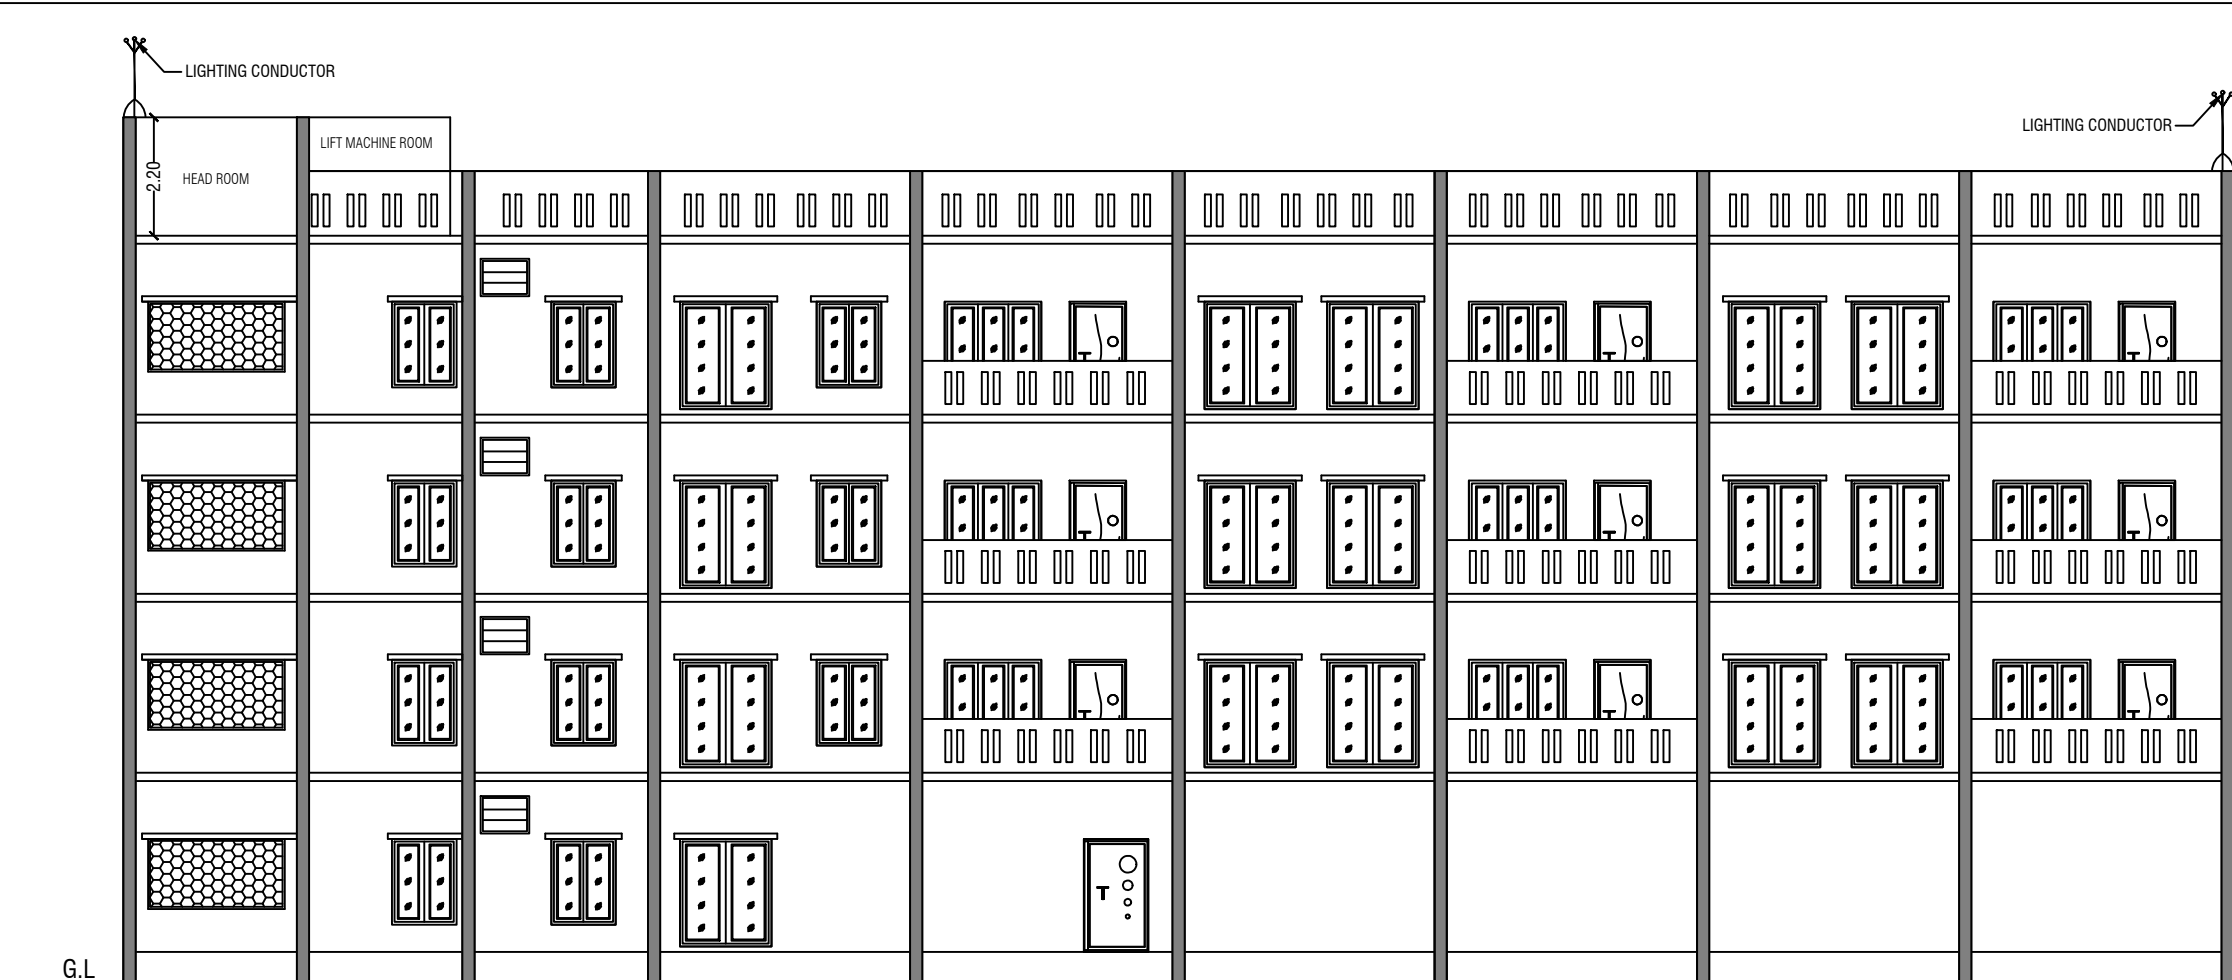


SOUTH ELEVATION

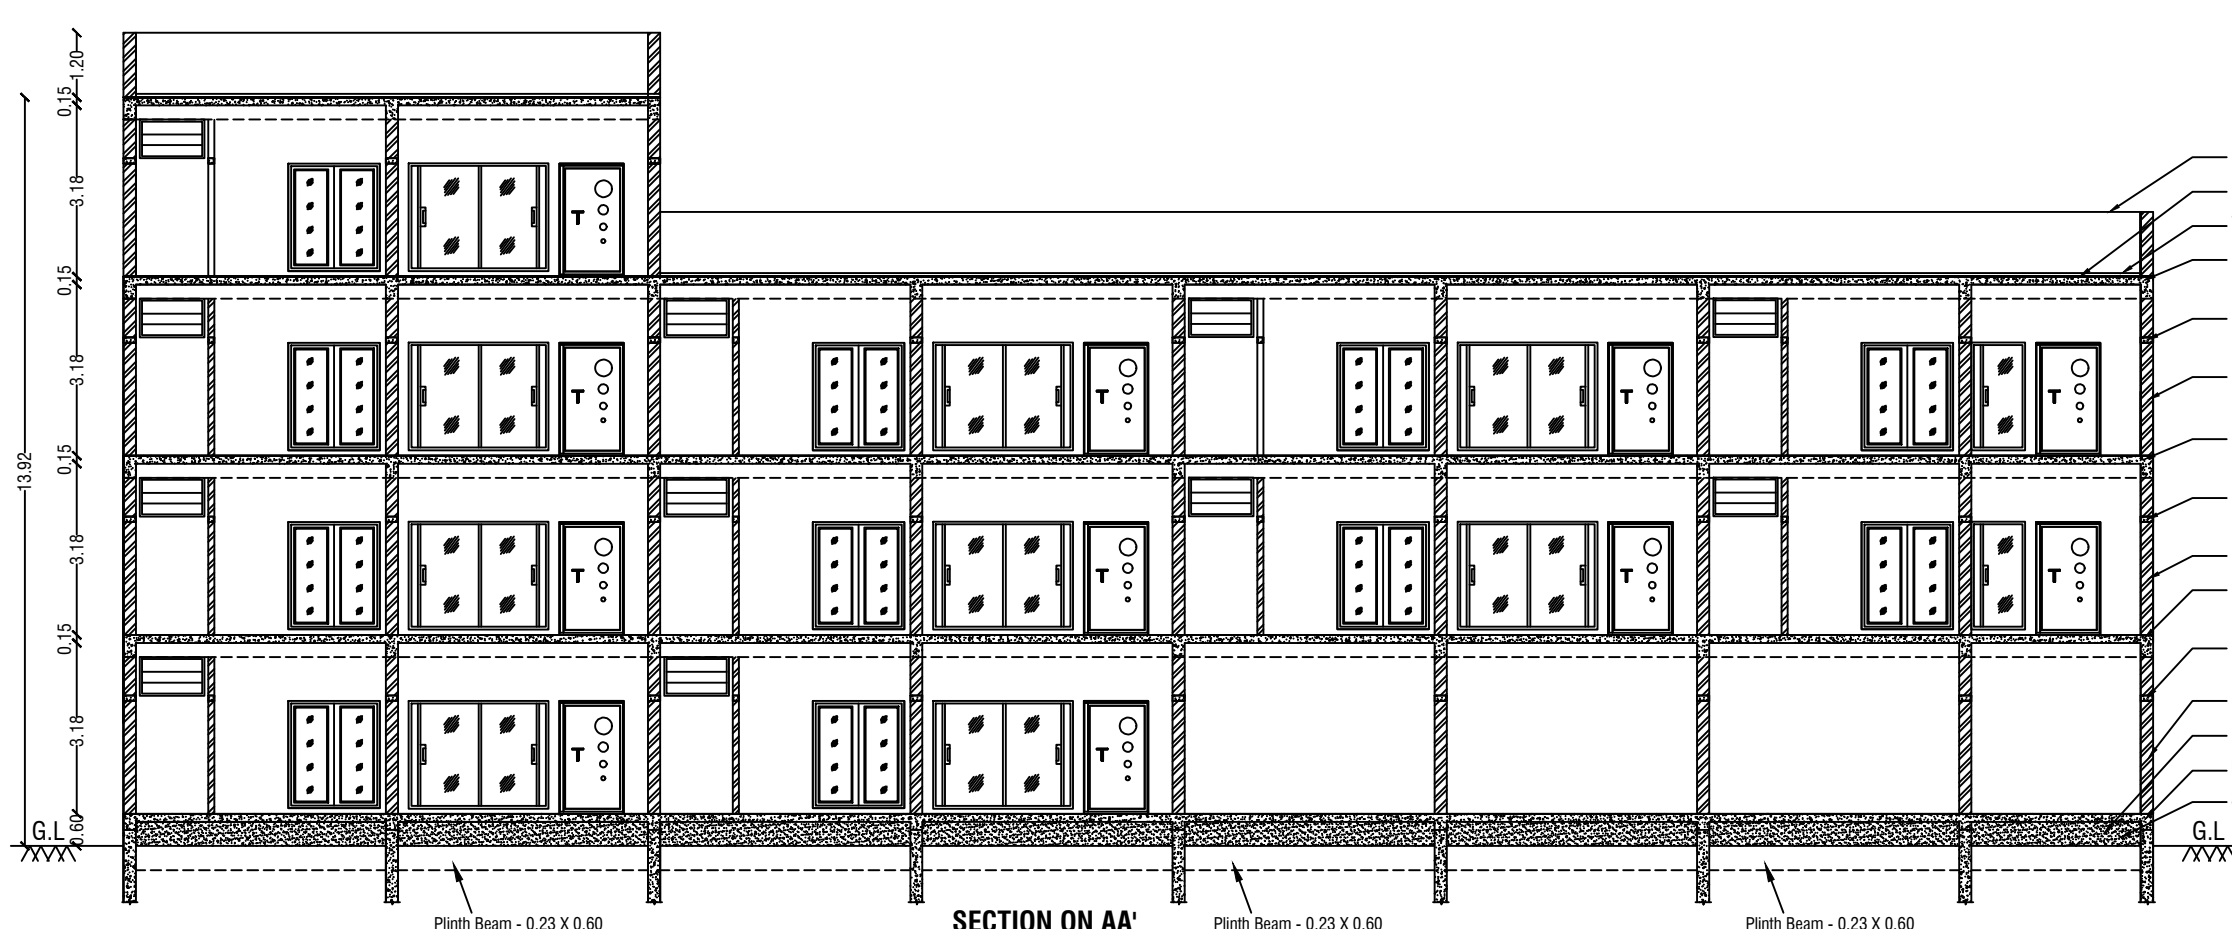



SECTION AA'



SECOND FLOOR PLAN

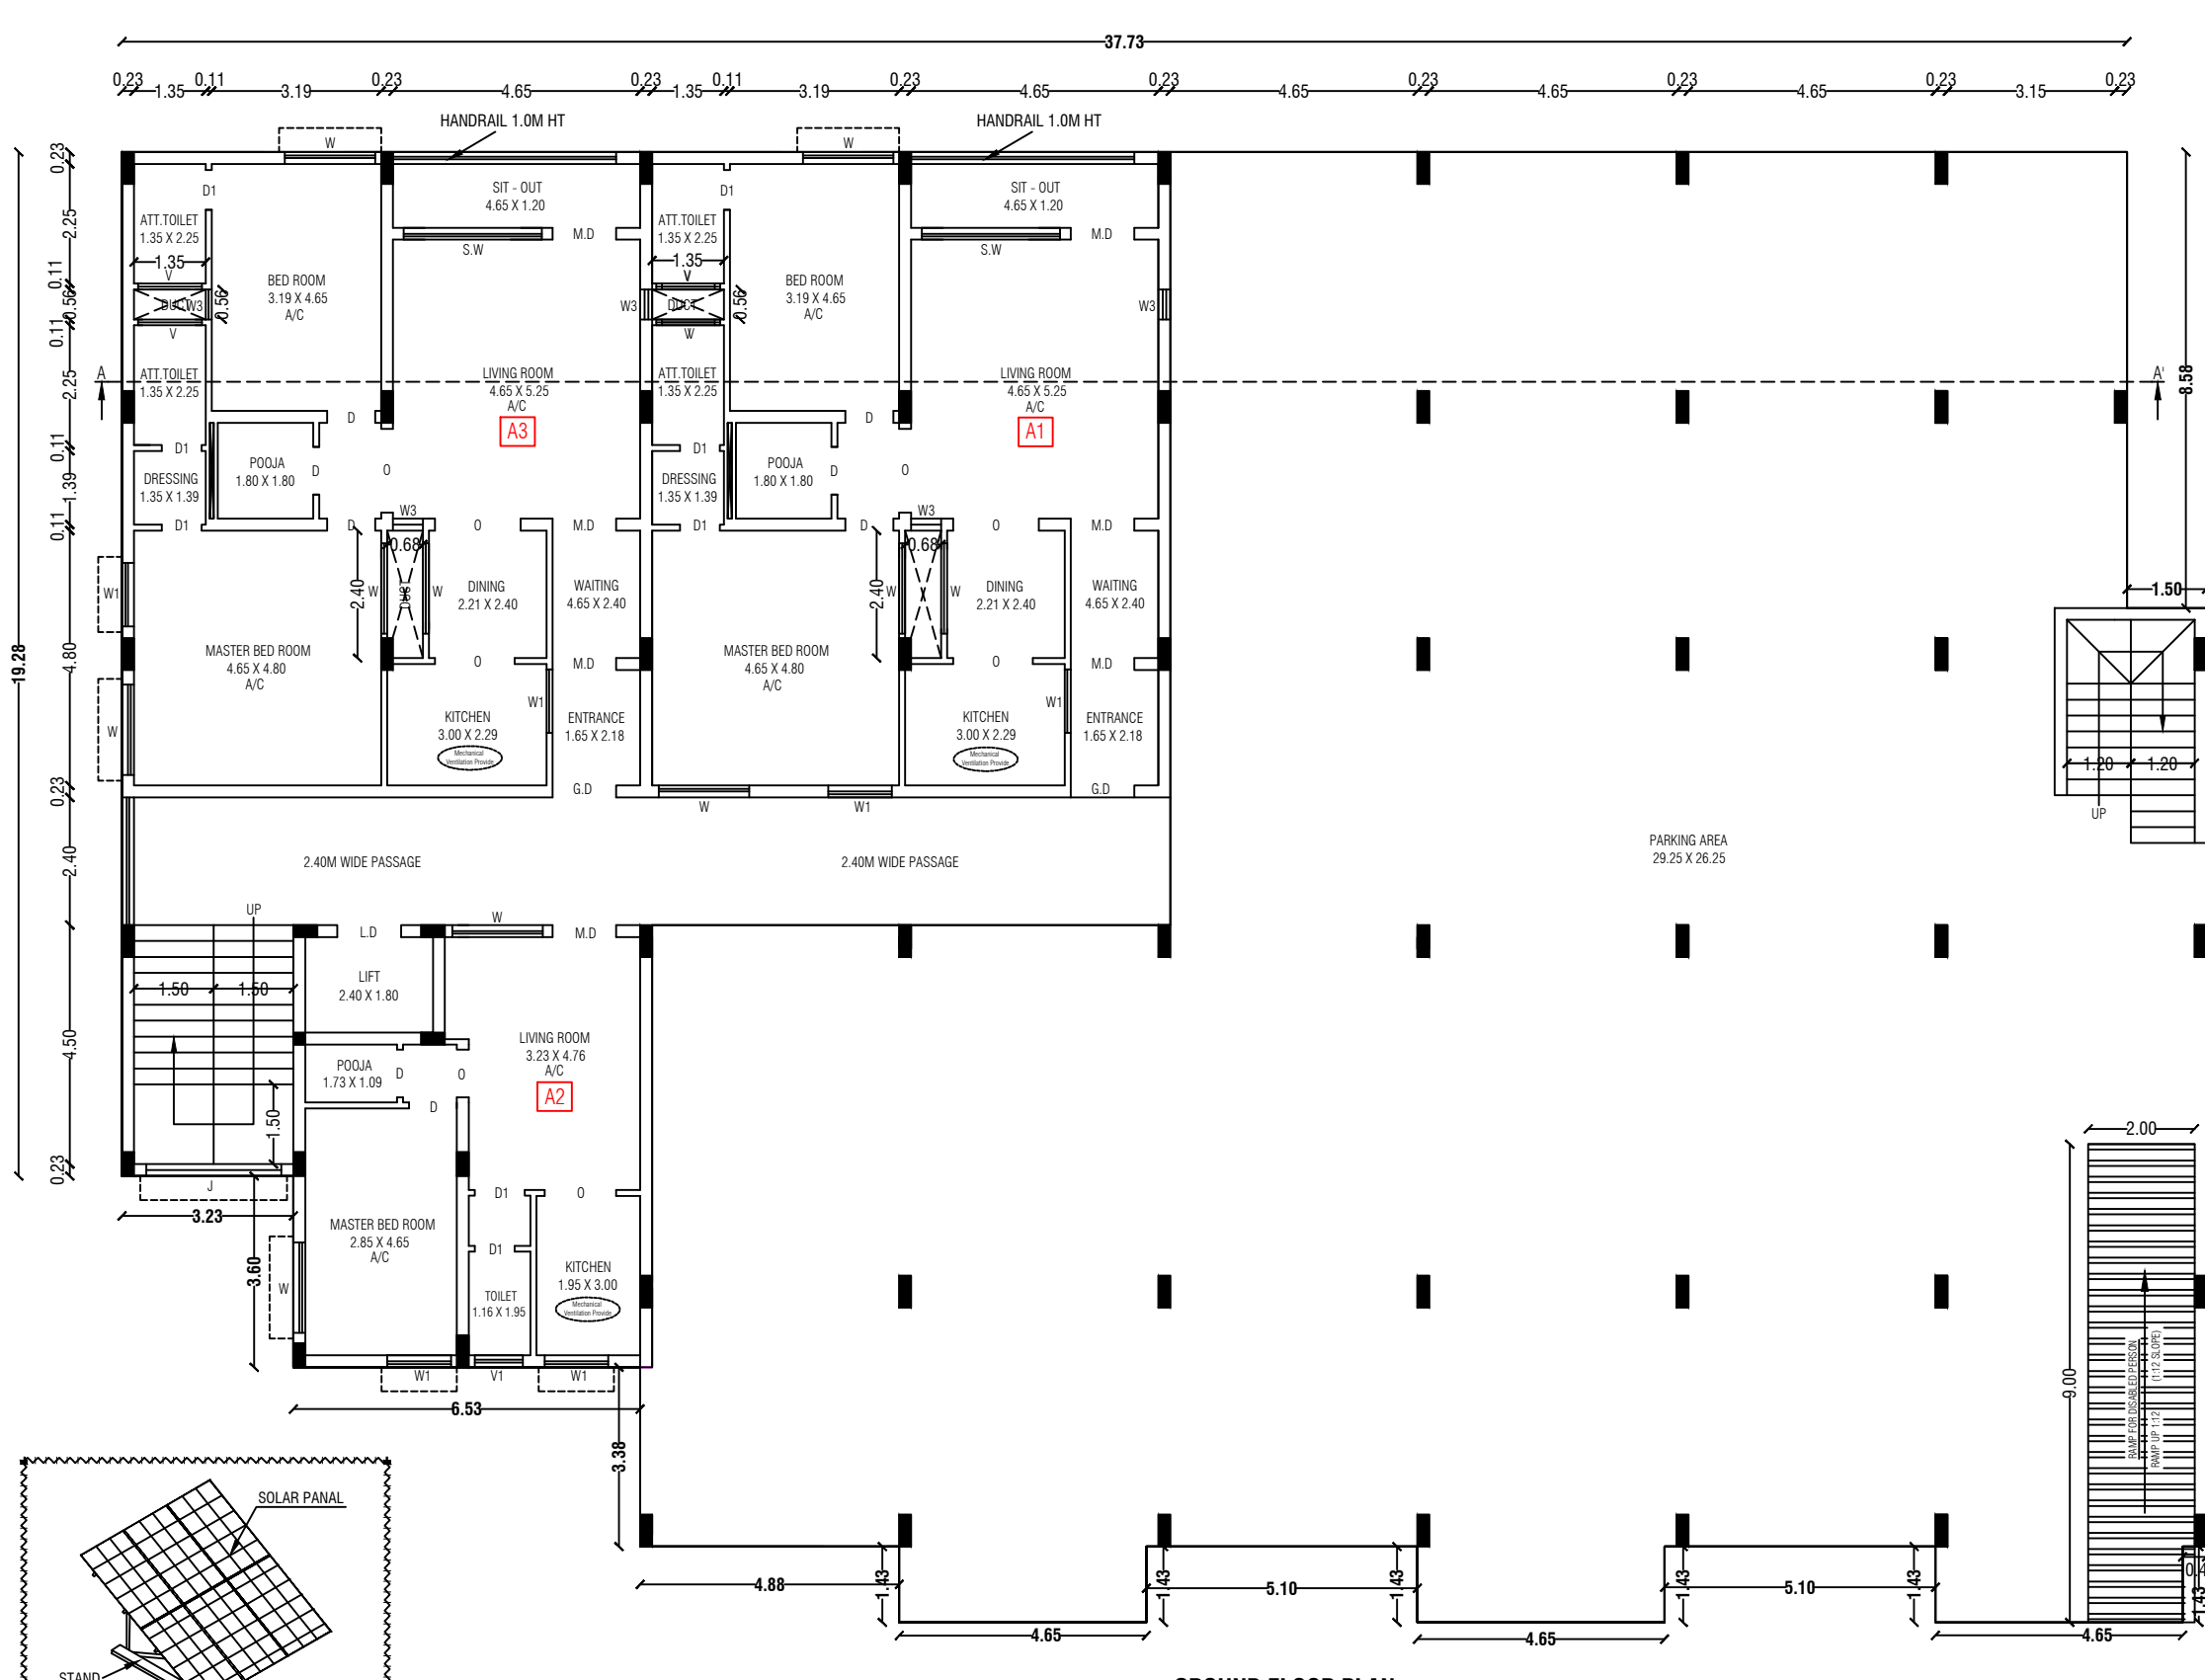

GROUND FLOOR PLAN

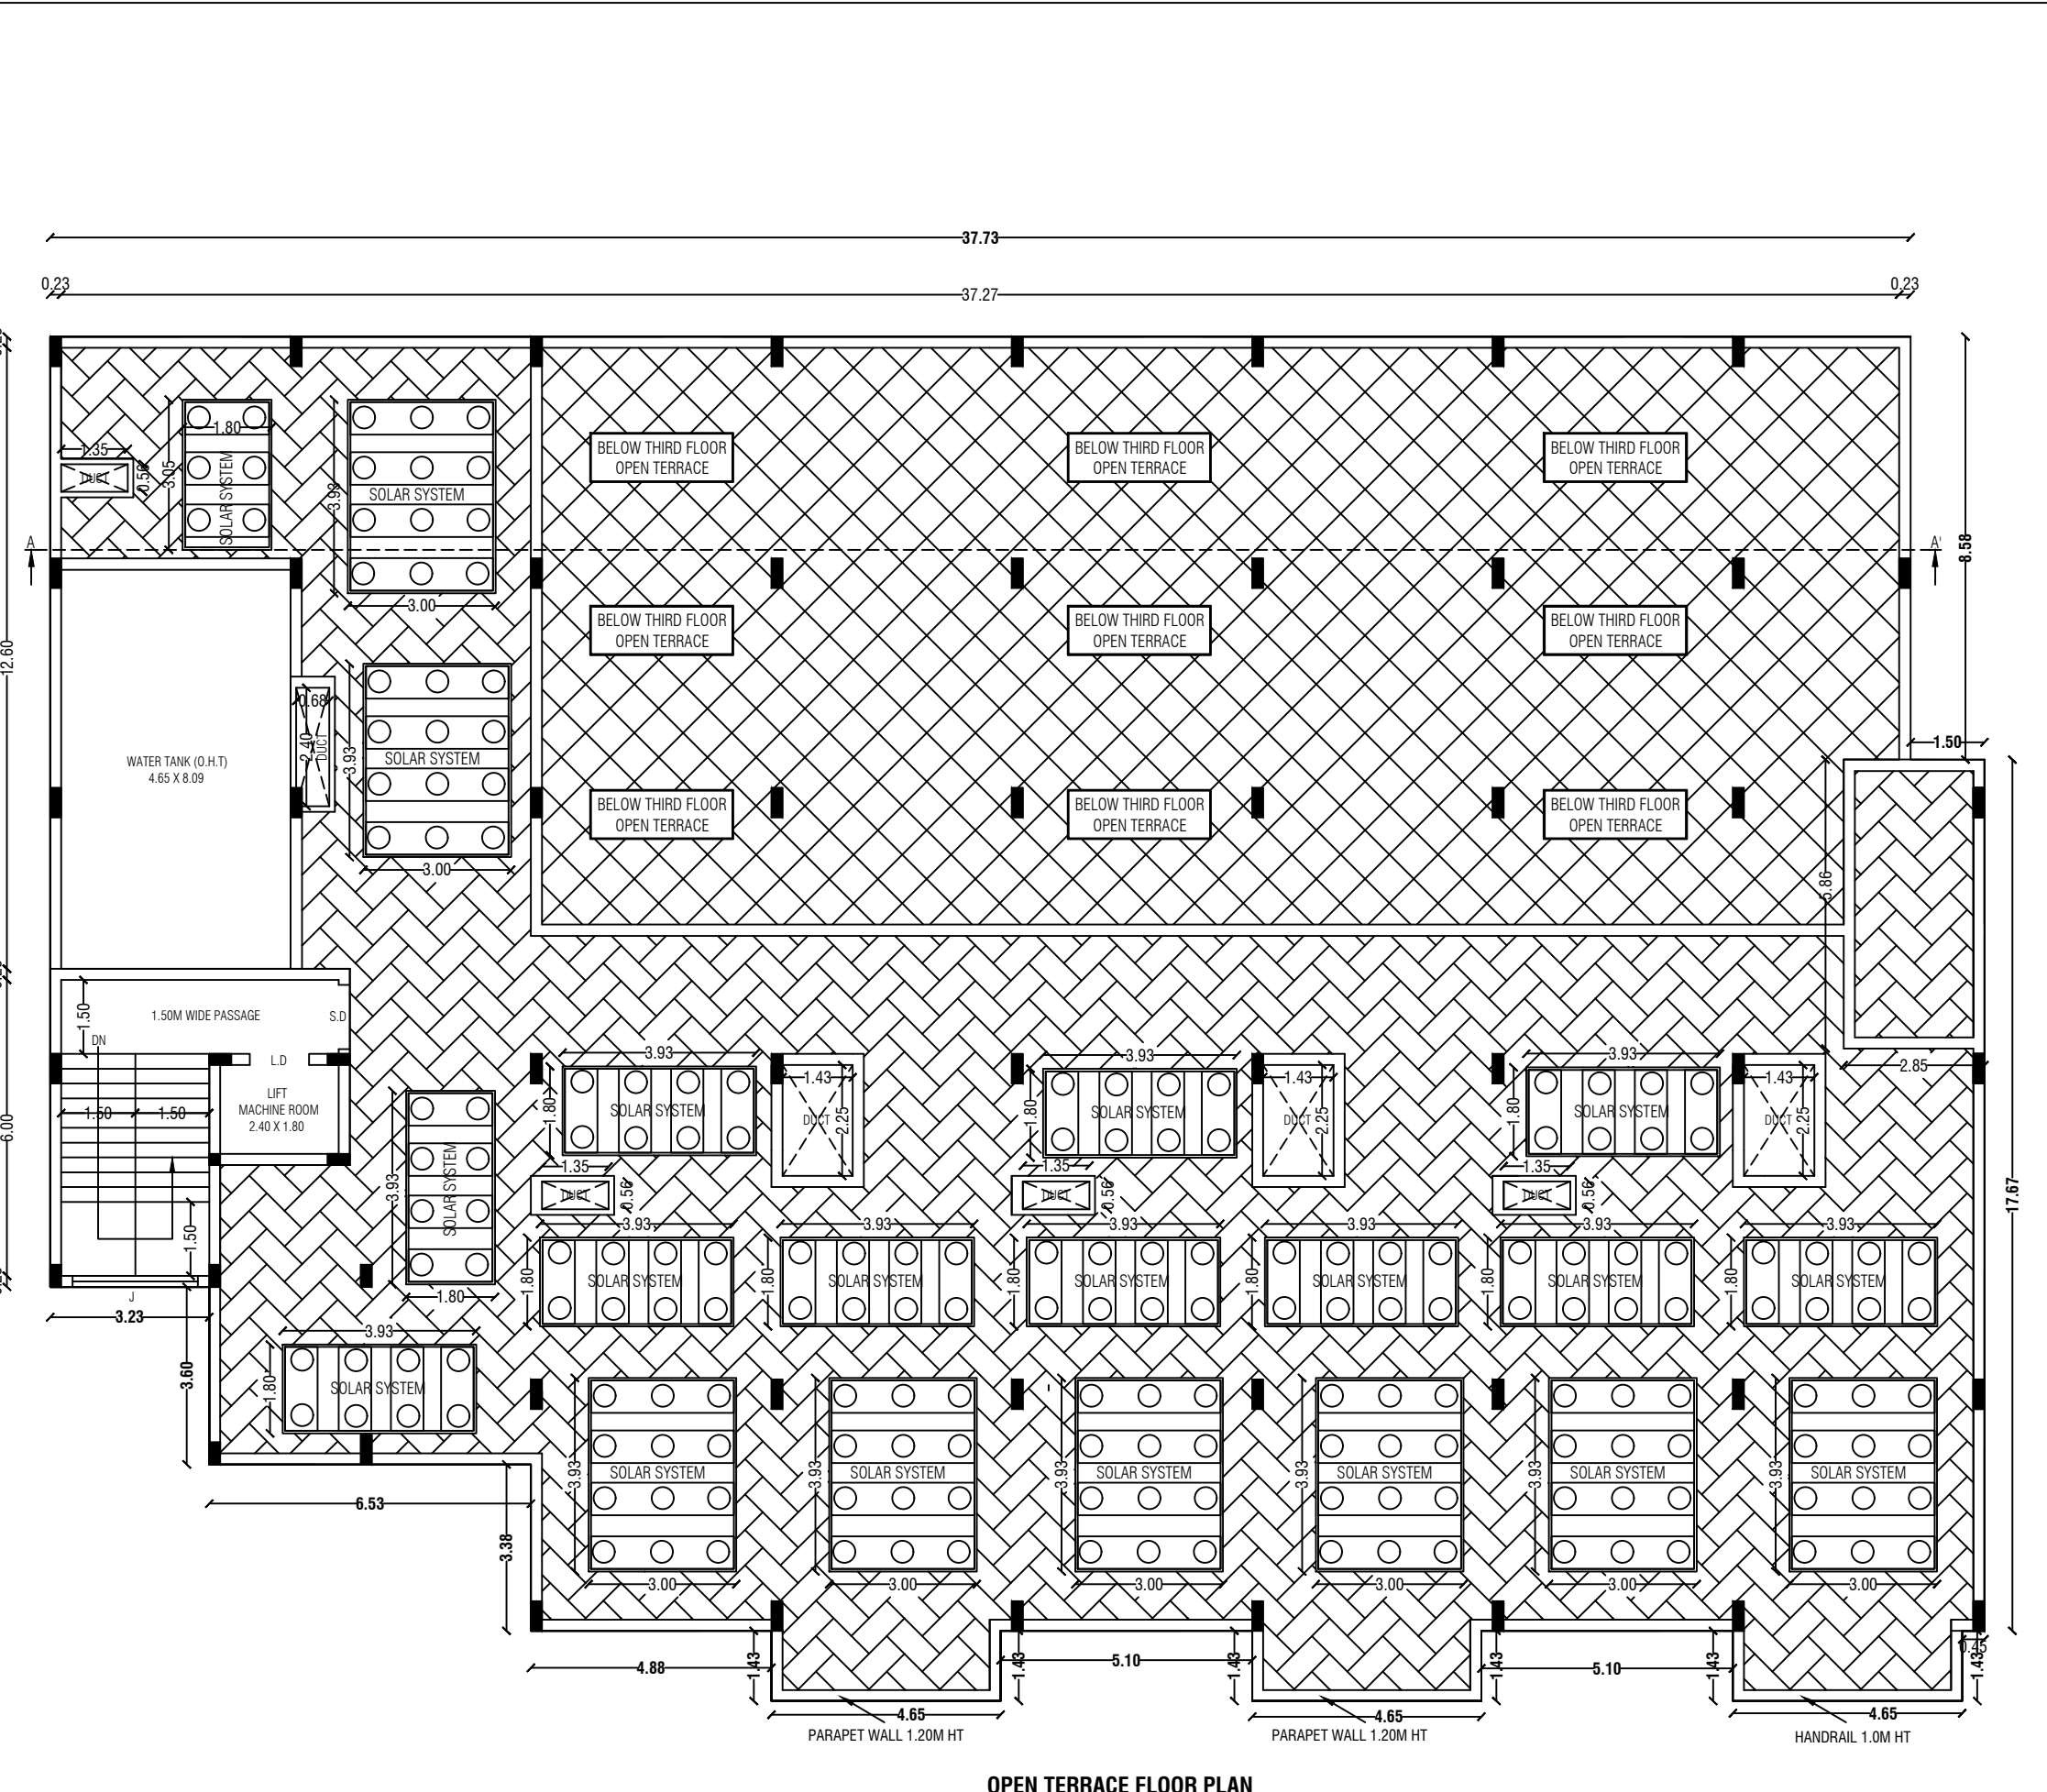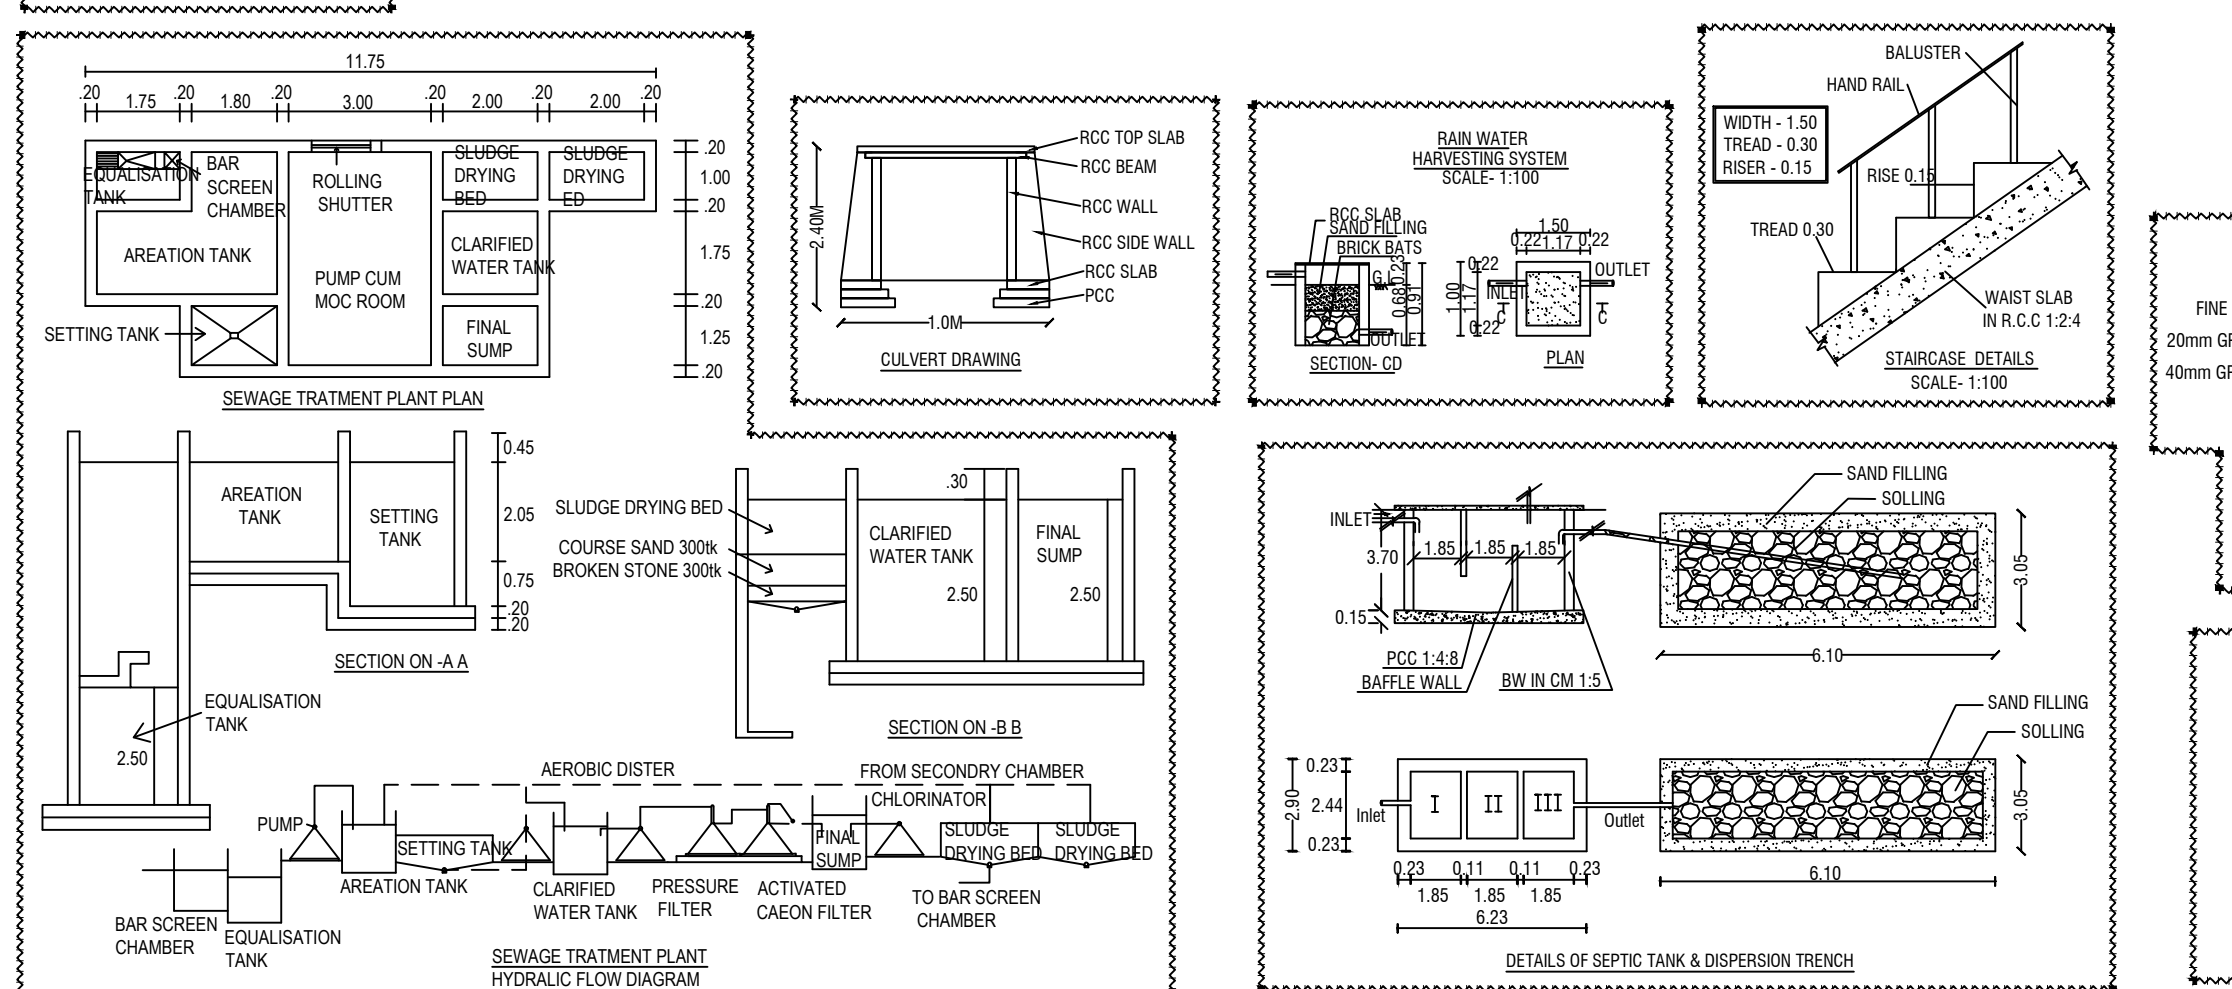


OPEN TERRACE FLOOR PLAN



THIRD FLOOR PLAN



FIRST FLOOR PLAN

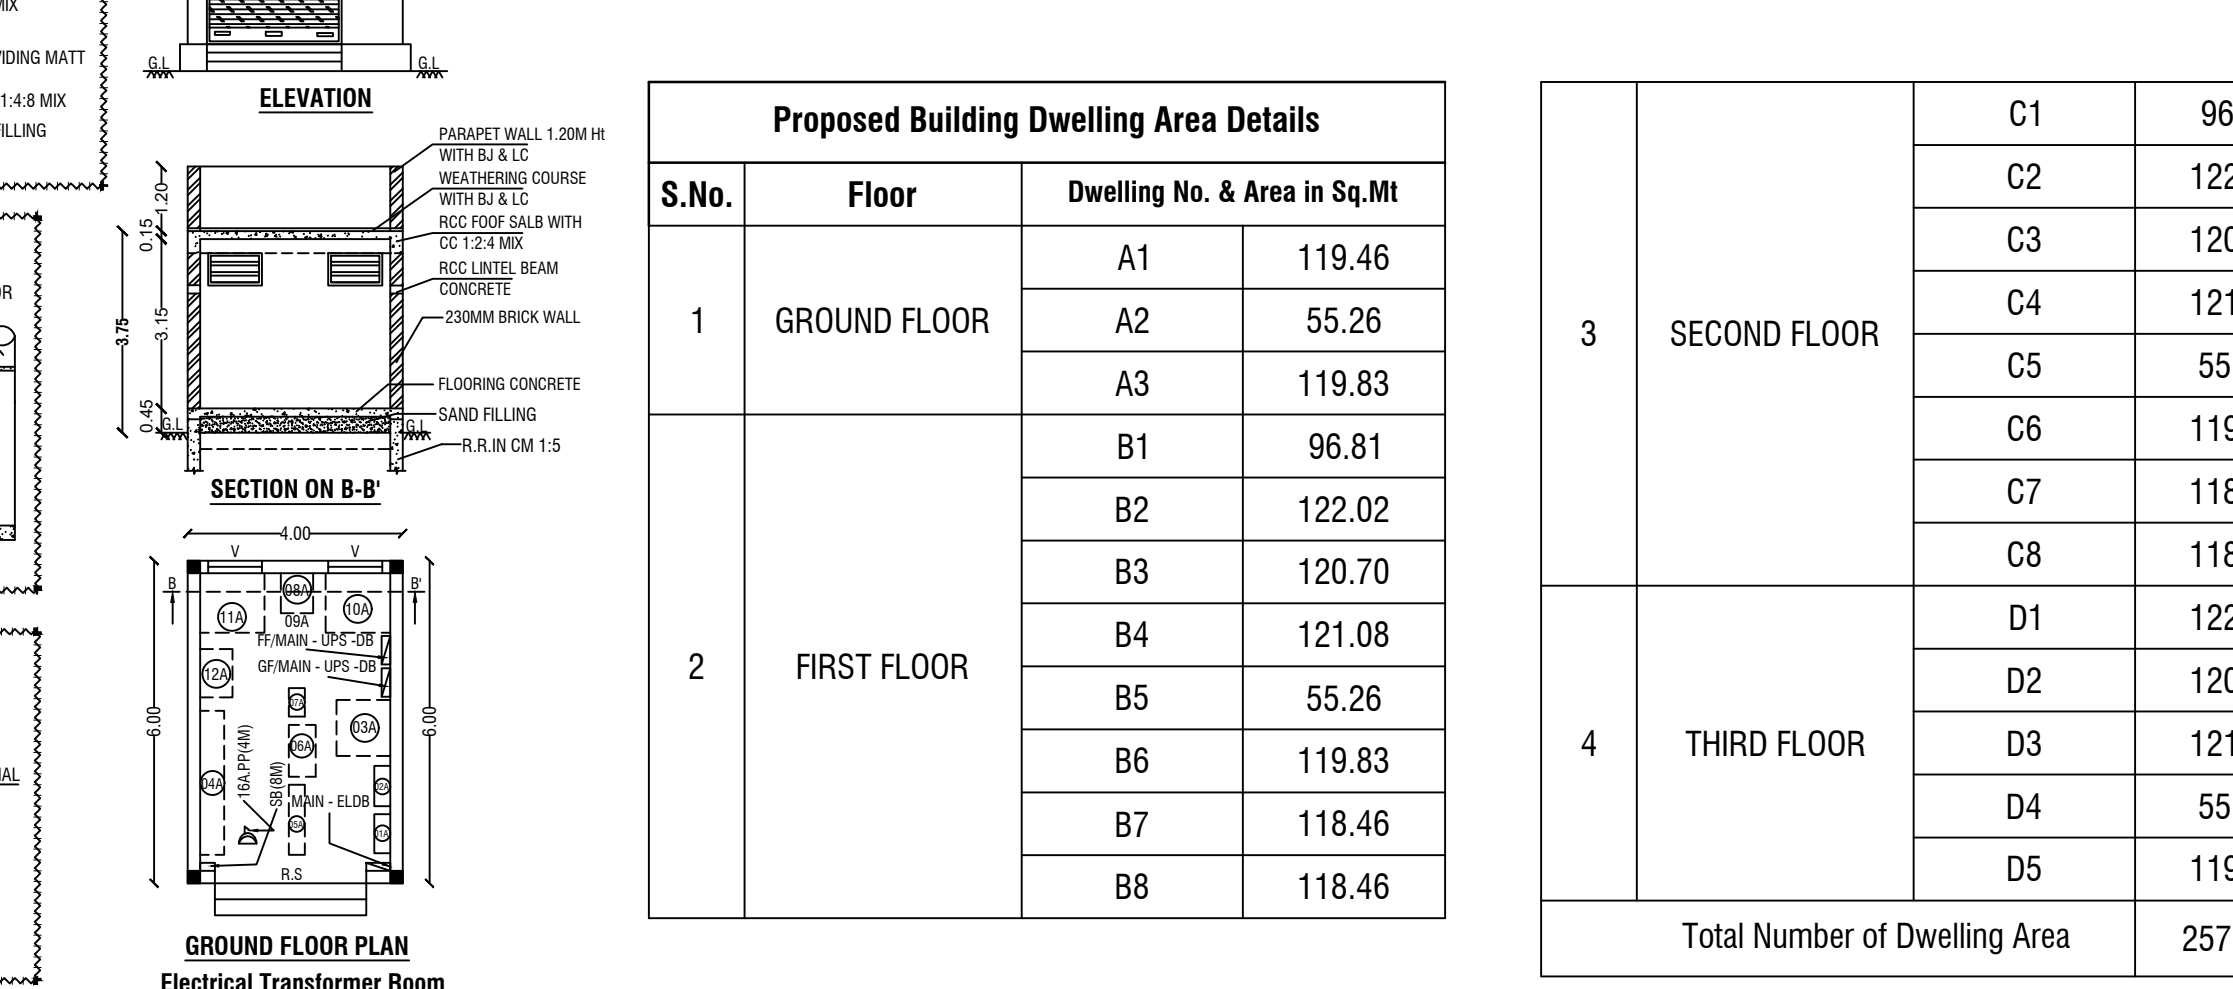

GROUND FLOOR PLAN

Proposed Building Dwelling Area Details

S.No.	Floor	Dwelling No. & Area in Sq.Mt
1	GROUND FLOOR	A1 119.46
		A2 55.26
		A3 119.83
2	FIRST FLOOR	B1 96.81
		B2 122.02
		B3 120.70
		B4 121.08
		B5 55.26
		B6 119.83
		B7 118.46
		B8 118.46

3	SECOND FLOOR	C1	96.81
		C2	122.02
		C3	120.70
		C4	121.08
		C5	55.26
		C6	119.83
		C7	118.46
		C8	118.46
4	THIRD FLOOR	D1	122.02
		D2	120.70
		D3	121.08
		D4	55.26
		D5	119.83
Total Number of Dwelling Area			2578.68

