

PLAN SHOWING THE PROPOSED CONSTRUCTION OF GI SHEET ROOF GROUND FLOOR INDUSTRIES BUILDING IN R.S.NO: 144 PT, KULICHAR VILLAGE , MAYILADUTHURAI TALUK & MAYILADUTHURAI DISTRICT.

ALL DIMENSIONS ARE IN METER

APPLICANT NAME: Mrs. B. PREMA

AREA DETAILS		SQ.MT.
AS PER PATTA AS PER DOCUMENT AS PER SITE		824.22
		824.22
		824.22
AREA OF GROUND FLOOR	F.S.I	NON F.S.I
TOTAL AREA OF FLOOR	417.58	-
FLOOR SPACE INDEX (FSI) = 417.58 / 824.22 = 0.50		

PROVIDED	
NUMBER OF CAR PARKING (2.50 X 5.00) = 2.00 NOS.	
NUMBER OF EV CAR PARKING (2.50 X 5.00) = 1.00 NOS.	
NUMBER OF TWO WHEELR PARKING (1.00 X 1.80) = 09.00 NOS.	
NUMBER OF DA WHEELR PARKING (1.00 X 1.80) = 01.00 NOS.	
NUMBER OF EV WHEELR PARKING (1.00 X 1.80) = 01.00 NOS.	
NUMBER OF CYCLE PARKING (0.56 X 1.80) = 10.00 NOS.	
COLOUR INDEX	
SITE BOUNDARY	☐
EXISTING ROAD	☐
PROPOSED BUILDING	☐
PROPOSED DRIVE WAY	☐
RAIN WATER PERCOLATION BED	☐

SCHEDULE OF JOINERIES	
MD- MAIN DOOR	- 1.83 X 2.10M
W - WINDOW	- 2.44 X 1.20M
V - VENTILATOR	- 0.91 X 0.76M


- NOTES:-
1. ALL DIMENSIONS ARE IN METRE
 2. RAINWATER COLLECTION WELLS WILL BE PROVIDED
 3. FIRE FIGHTING ARRANGEMENTS WILL BE PROVIDED
 4. EMERGENCY ALARMS WILL BE PROVIDED
 5. DRINKING WATER WILL BE PROVIDED
 6. GROUND WATER SUMPS WILL BE PROVIDED
 7. FILTERED RAIN WATER SUMPS WILL BE PROVIDED
 8. EXHAUST FAN PROVISION IS MADE AT TOILET & WASH
 9. SOLAR WATER HEATING SYSTEM PROVIDED.
 10. RAINWATER HARVESTING FACILITIES PROVIDED.
 11. WASTE WATER RECYCLING TRENCH AND TANK PROVIDED.
 12. SEWAGE TREATMENT PLANT PROVIDED.
 13. SEPTIC TANK PROVIDED.
 14. WATER FACILITIES PROVIDED.
 15. TRANSFORMER YARD PROVIDED.
 16. FA - FIRE ALARAM PROVIDED
 17. F E - FIRE SAFETY MEASURES PROVIDED.
 18. SB - SAND BUCKET PROVIDED

[Signature]


APPLICANT

[Signature]
Er. S. SELVA SUGUMARAN, B.E.,
Registered Engineer Grade-II
Reg. No. NGT/RE-II/2021/012
DTCP., NAGAPATTINAM,
No. 2, Kenikarai, Thiruvavur Road,
Mayiladuthurai-609 001,
Cell: 9080750852.


ENGINEER

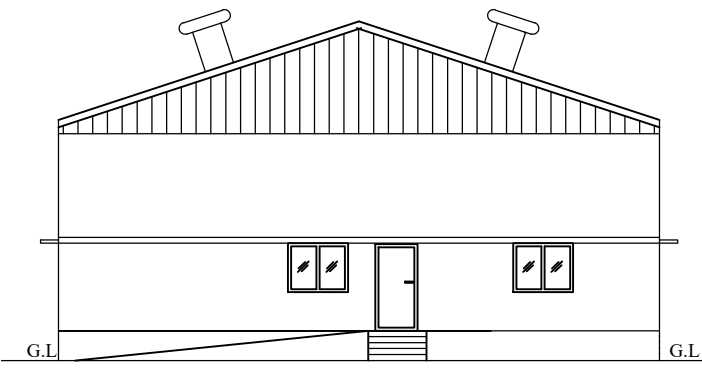


FRONT ELEVATION

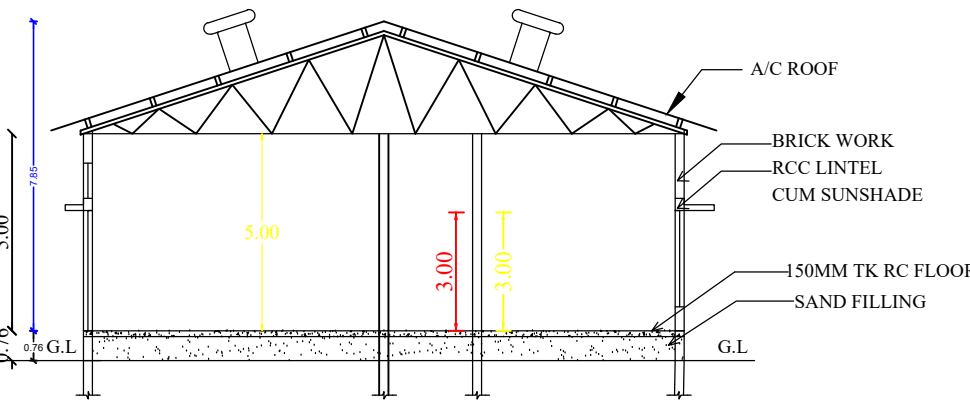


SECTION ON "A-B"

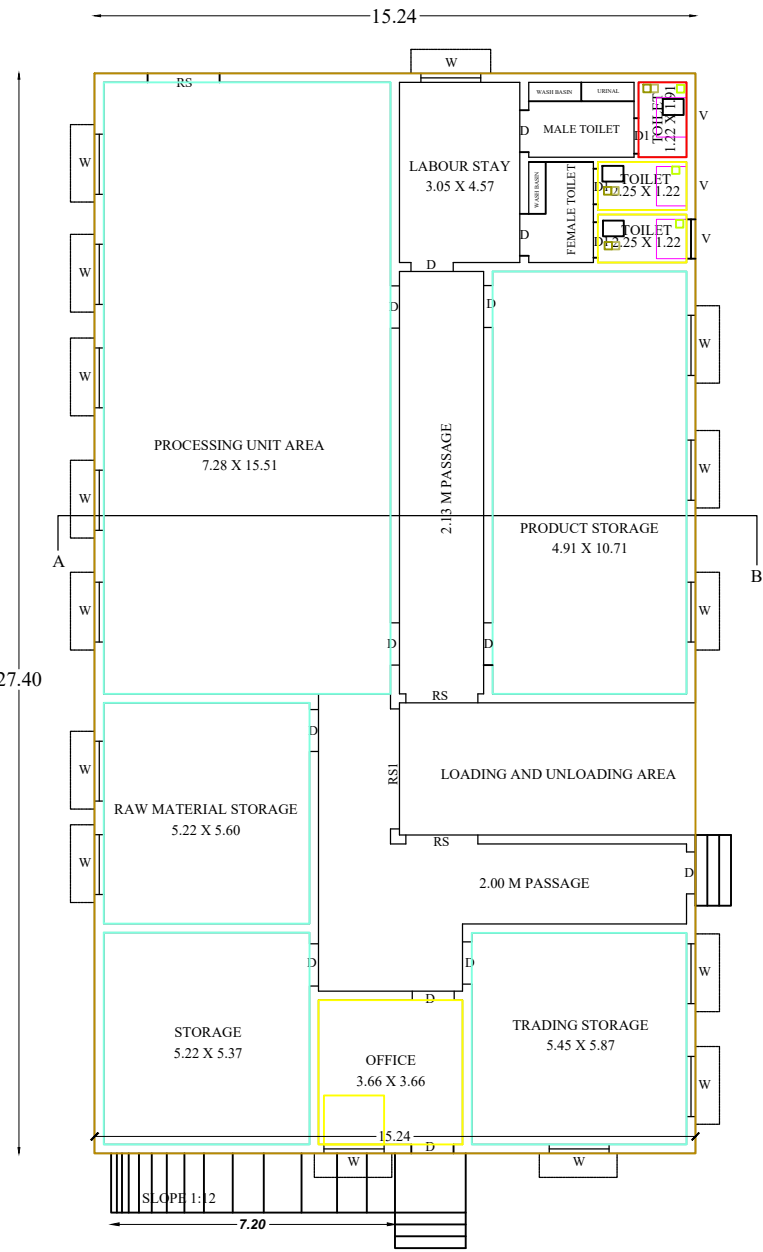


GROUND FLOOR PLAN

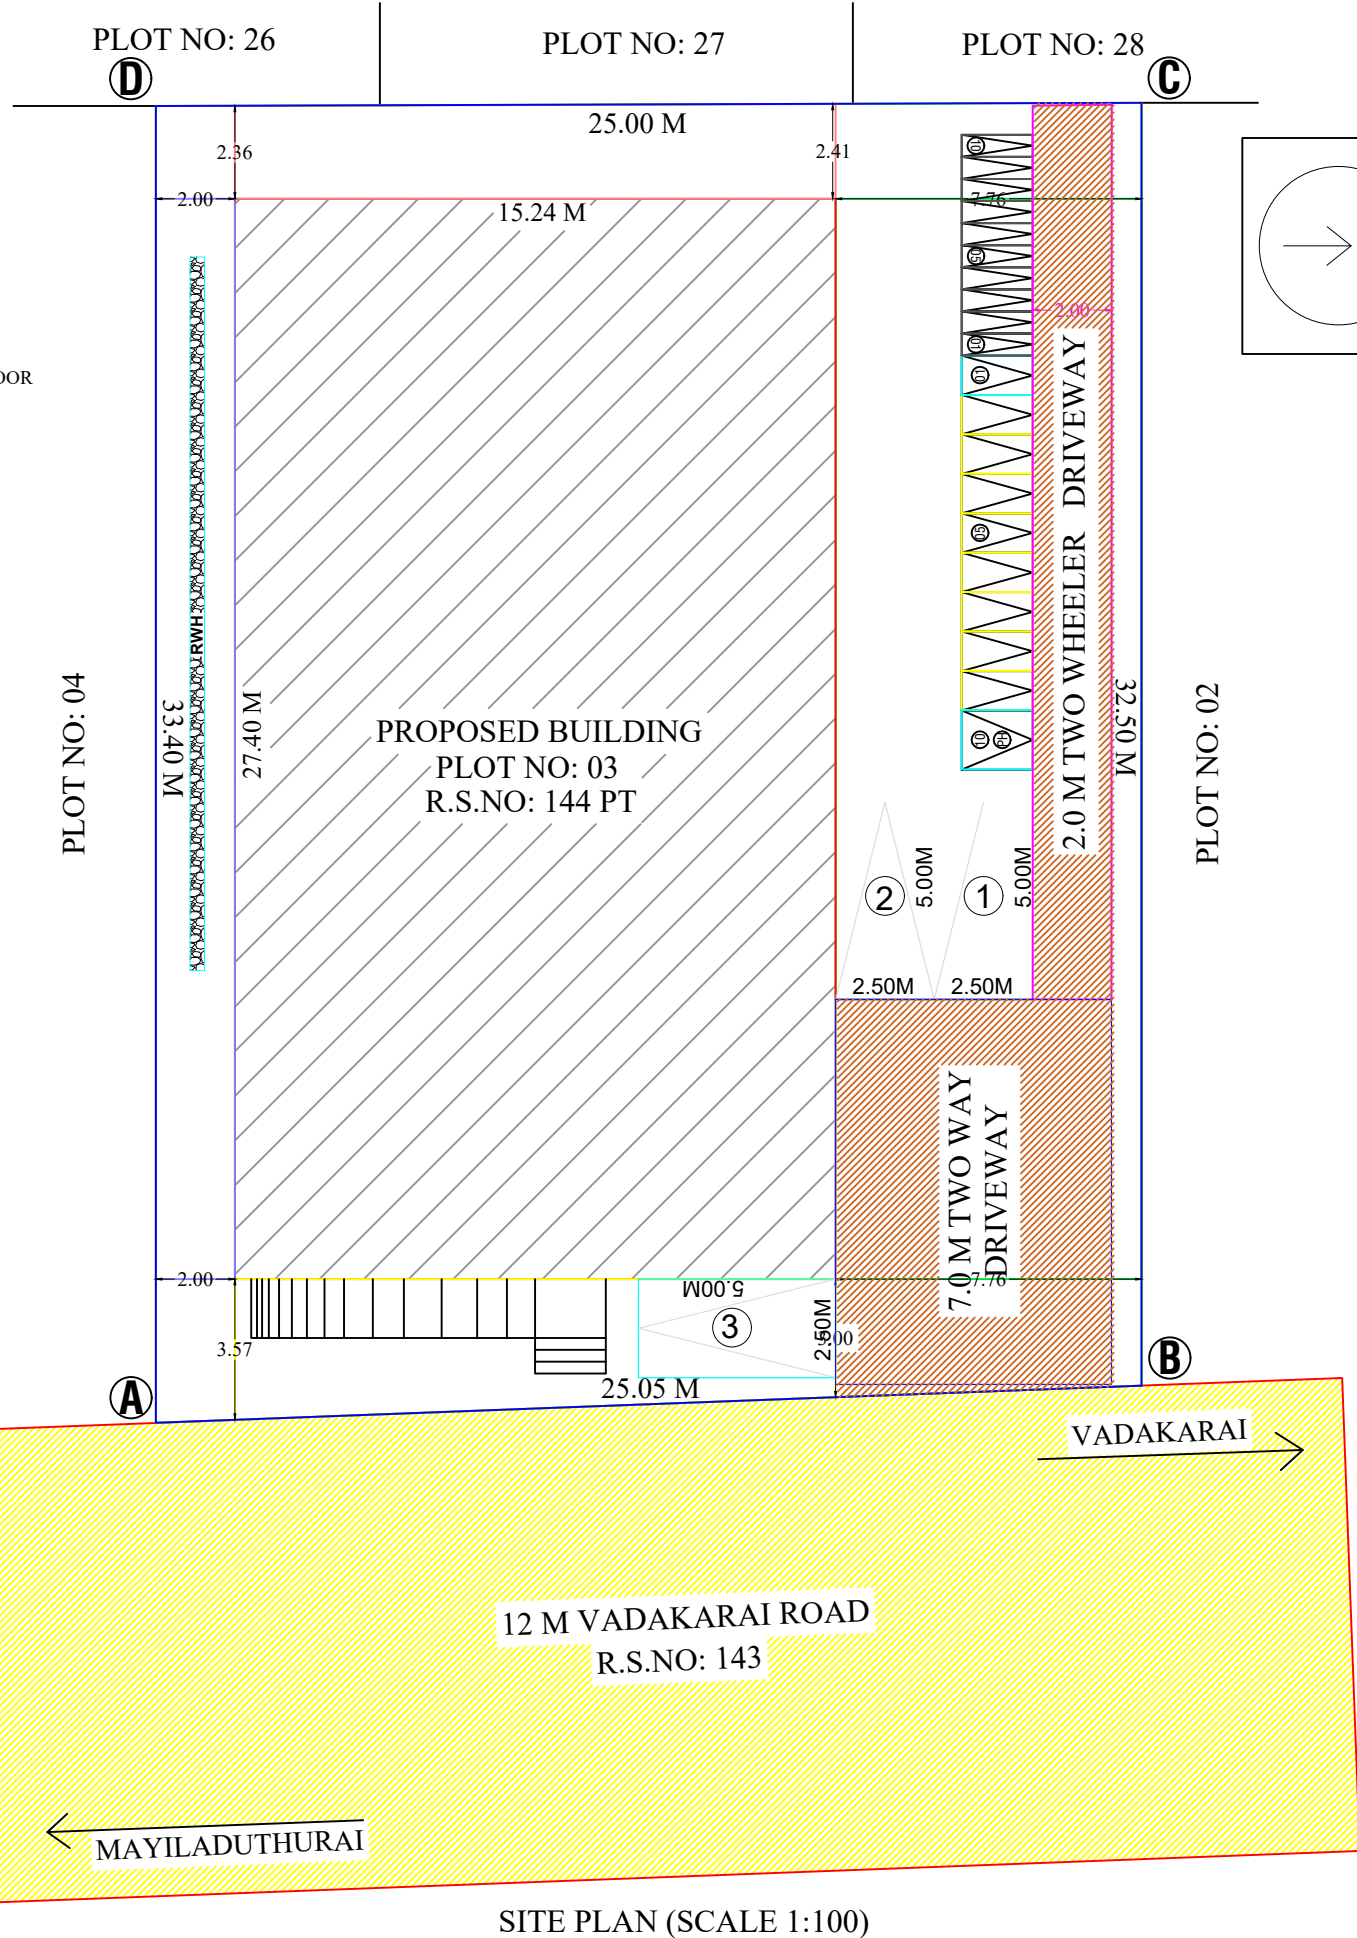


SITE PLAN (SCALE 1:100)

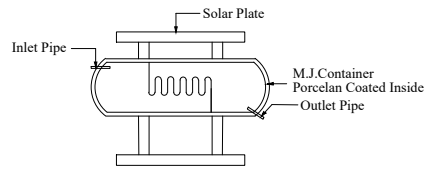


SOLAR WATER HEATING SYSTEM
SCALE : NOT TO SCALE

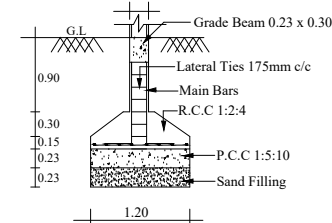


FOOTING DETAILS
SCALE : NOT TO SCALE

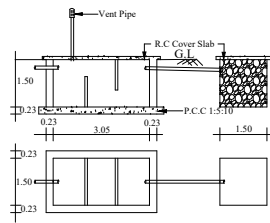


SEPTIC TANK & D-TRENCH DETAILS
SCALE : NOT TO SCALE

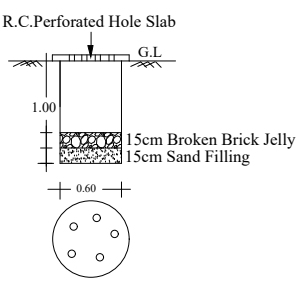

RAIN WATER HARVEST PIT
SCALE : NOT TO SCALE

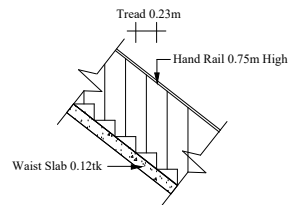

STAIR DETAILS
SCALE : NOT TO SCALE

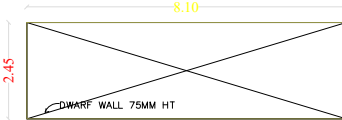

MAIN GATE