

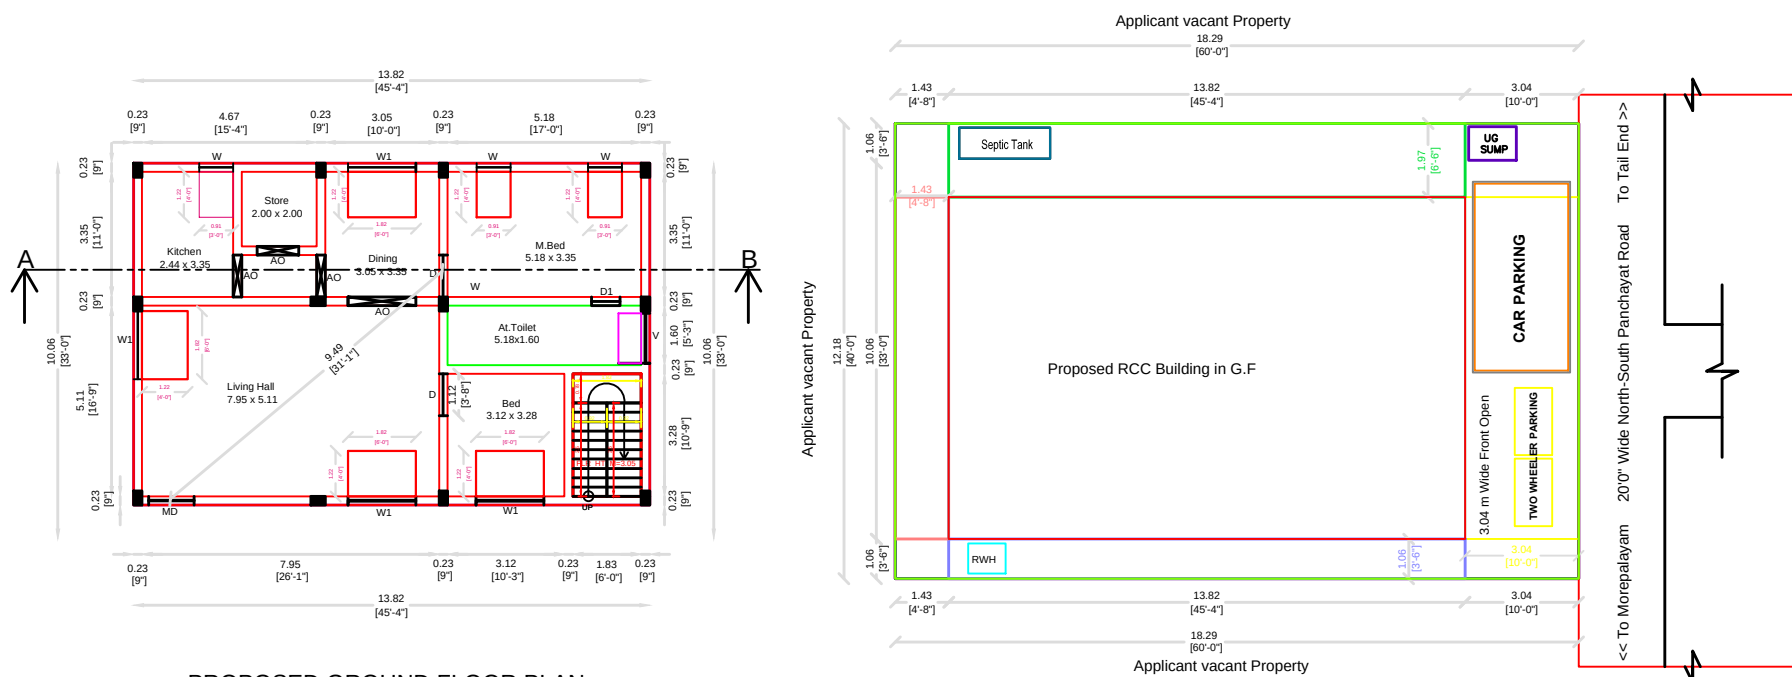


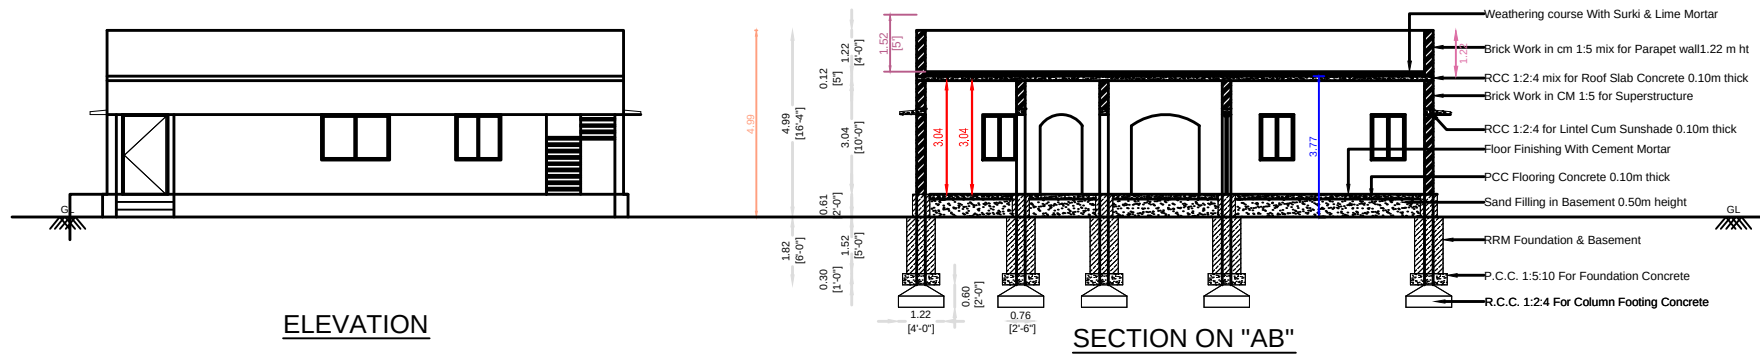


PROPOSED GROUND FLOOR PLAN

SITE PLAN
(Scale : 1:100)


PLAN INFO
PLOT_AREA_M2=222.78
AS_AT_SITE=222.77
FMB_OR_PLR=222.78
AS_PER_DOCUMENT=222.78
SURVEY_NO=61/1
PATTI_NO=227
PREMIUM_FSI_REQUIRED=NO
BLOCK_1_MEMBER_COUNT=1
OSR_APPLICABLE=NO
OSR_SURRENDBACK_RETAIN=NOT APPLICABLE
IS_APPROVED_LAYOUT=YES
SINGLE_FAMILY_BLDG=YES
CRZ=NO
SECURITY_ZONE=NO
ACCESS_WIDTH_M=500.00
WHETHER_GOVT_OR_AIDED_SCHOOL=NO
ROAD_WIDTH=7.62
ROAD_LENGTH=250.00
AVG_PLOT_DEPTH=18.29
AVG_PLOT_WIDTH=12.18
LAND_USE_ZONE=E02
PLOT_NO=0
DISTRICT=NAMAKKAL
TALUK=THIRUCHENGODE
RWHD_DECLARED=YES
BUILDING_NEAR_TO_RIVER=NO
AREA_TYPE=OTHERS
BUILDING_NEAR_MONUMENT=NO
BUILDING_NEAR_GOVT_BLDG=NO
ORGANIZATION_TYPE=PRIVATE
PROVISION_FOR_GREEN_BUILDINGS_AND_SUSTAINABILITY=YES
FIRE_PROTECTION_AND_FIRE_SAFETY_REQUIREMENTS=YES
NOC_FOR_CONSTRUCTION_NEAR_MONUMENT=NO
NOC_FIRE_DEPT=YES
JURISDICTION_TYPE=PANCHAYAT
IS_SWIMMING_POOL_EXISTS=NO
IF_HERITAGE_TOWN_LESS_THAN_1KM_RADIUS=NO

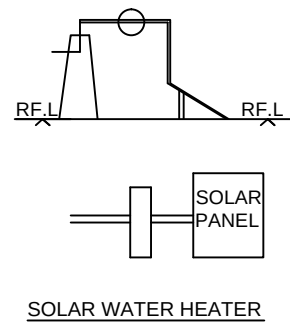


SOLAR WATER HEATER

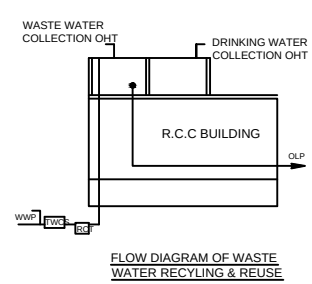




FLOW DIAGRAM OF WASTE
WATER RECYCLING & REUSE

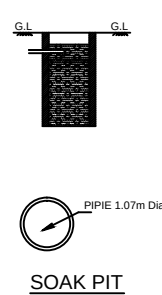


SOAK PIT

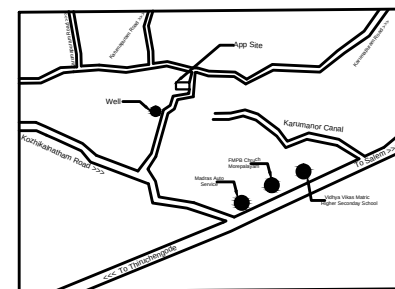

Column & Footing Reinforcement Details

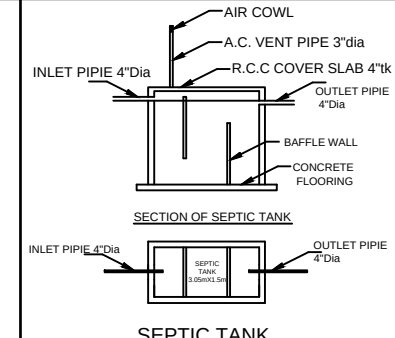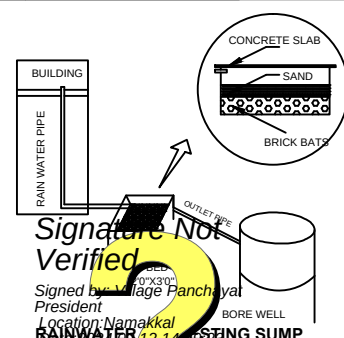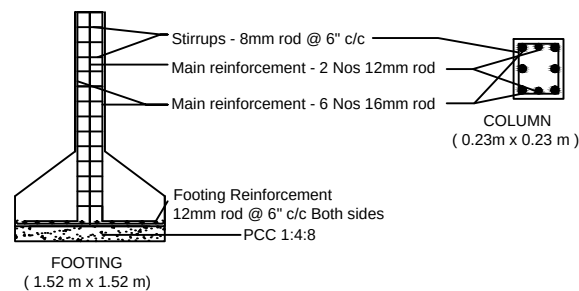

SEPTIC TANK

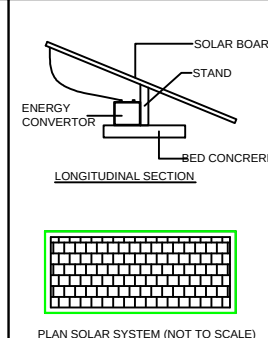

PLAN SOLAR SYSTEM (NOT TO SCALE)

Plan Showing the Proposed RCC Ground Floor Dwelling House
Construction at S.F.No: 381/1B, Karumapuram Village & Panchayat ,
Thoppukadu, Karumapuram, Thiruchengode Taluk ,Namakkal District.

Applicant :

Thiru.P.Sakthivel,
S/o.Thiru.K.Palanivel.

AREA DETAILS	SQM	SFT
Area of the Applicant Site (As on Document)	2690.59	28961.26
Hypothicated Area of the Applicant Site	222.78	2400.00
Plinth Area of the Proposed RCC Building in G.F	139.04	1496.61
Carpet Area of the Proposed RCC Building in G.F	109.01	1173.37
Area of the Open Space	83.74	901.37
Proposed Septic Tank & Soak Pit - Each	01 No	
Proposed Stair case	01 No	
Proposed Rain Water Harvesting Sump	01 No	

JOINERY DETAILS :-

Main Door	MD	1.22 x 2.13	Door	D	1.12 x 2.13
Door	D1	0.76 x 2.13	Window	W	0.91 x 1.22
Window	W1	1.82 x 1.22	Arch Open	AO	1.82 x 2.13
Arch Open	AO1	1.12 x 2.13	Ventilator	V	1.34 x 0.61

Note :-

ALL DIMENSIONS ARE IN "METER"
ALL ROOMS ARE HAVING SUFFICIENT "VENTILATION"
"U" DROP WILL BE PROVIDED IN THE OUTLET
COLLECTION TANK WATER WILL BE REUSE TOILET & BATH ROOM OUTLET
SOLAR WATER HEATER SYSTEM OF 180LIT CAPACITY IS TO BE PROVIDED (1NOS)

APPLICANT

REGISTER ENGINEER

Signature of Applicant

Er. K. KAVIN, B.E.,
Reg. Civil Engineer
THE TUSKER CONSTRUCTIONS
10/35A, Vattamalai, Gandhi Nagar,
Sankari(Tk), Salem(Dt)-638 183.
Ph: 99653 15456.