


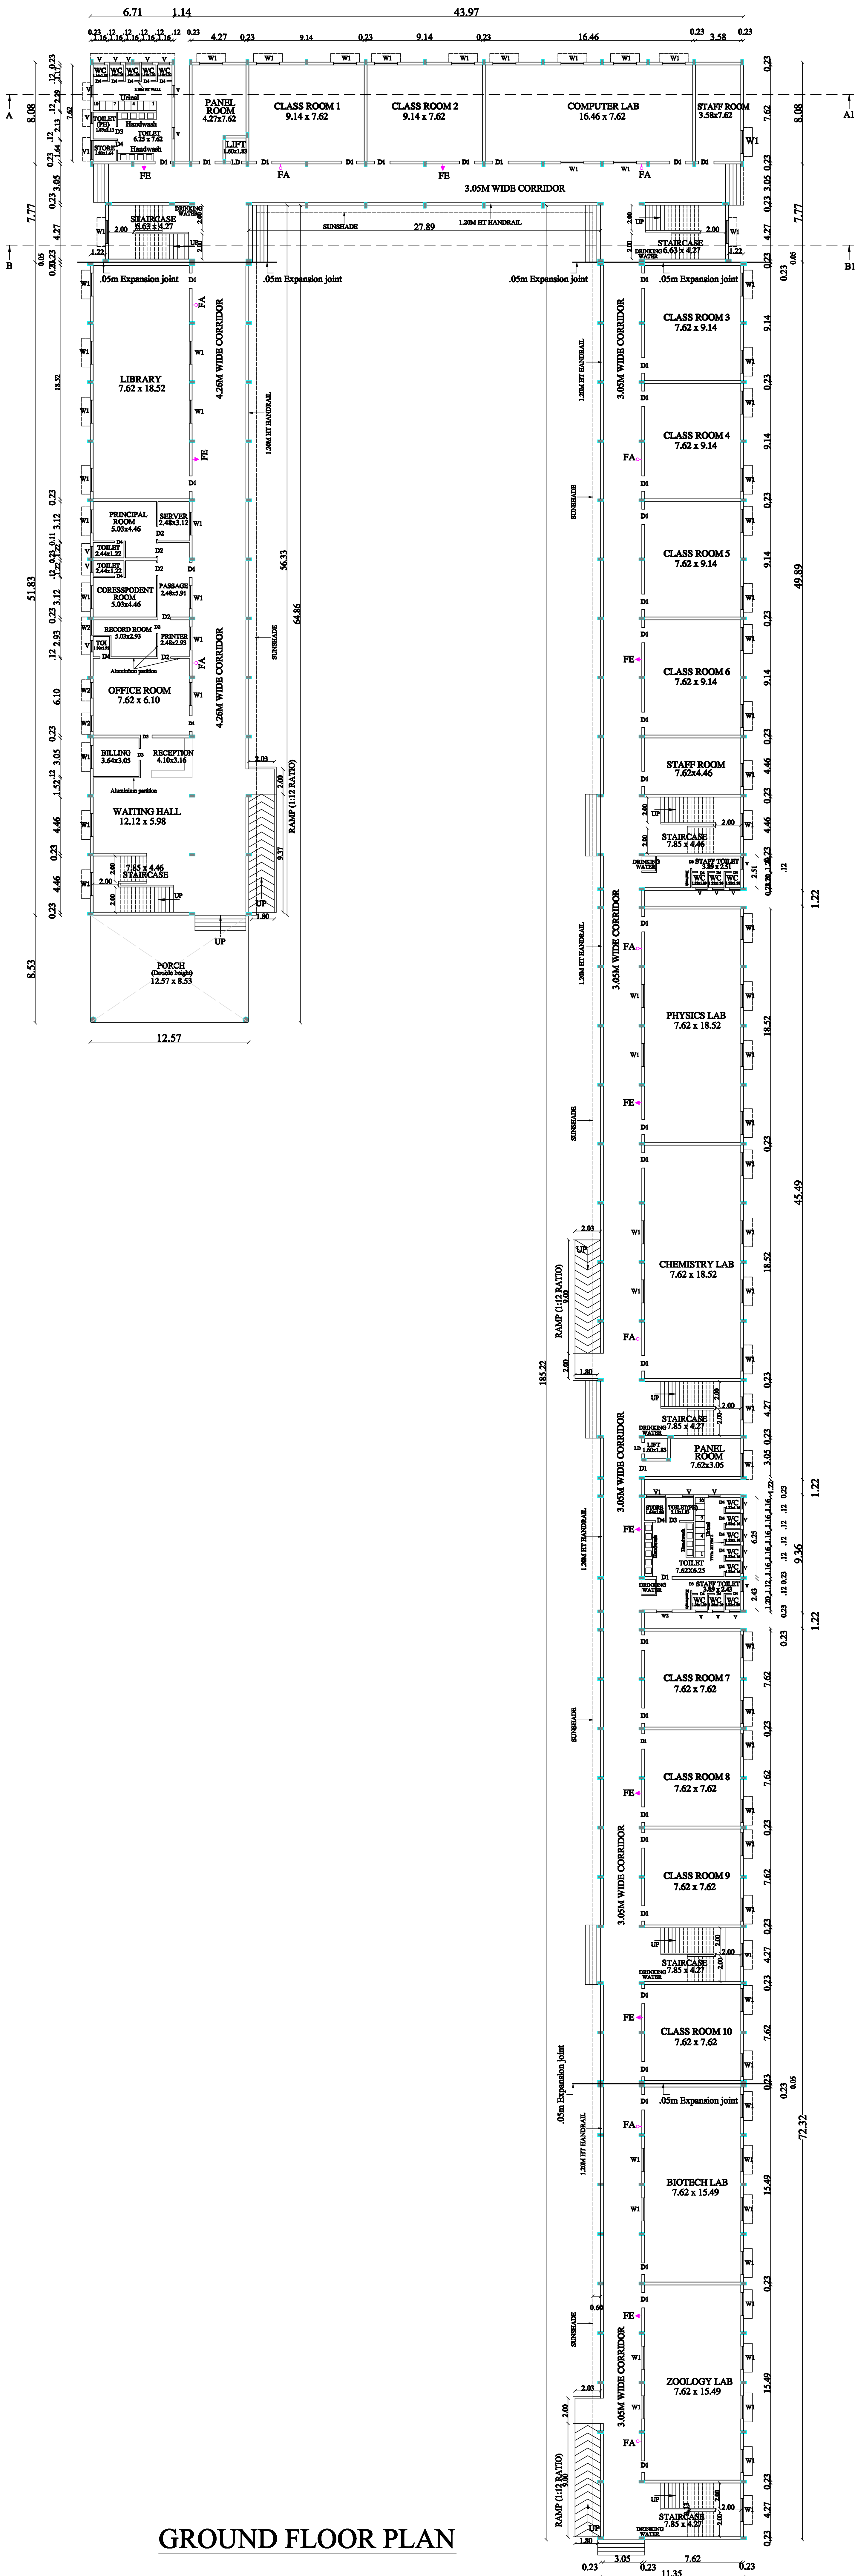

GROUND FLOOR PLAN

SHEET NO - 1

PLAN SHOWING THE PROPOSED CONSTRUCTION OF DR.ABDULLAH ARTS AND SCIENCE COLLEGE FOR MEN IN S.NO - 255/1A2(part), PULLANGUDI VILLAGE, RAMANATHAPURAM TALUK, RAMANATHAPURAM DISTRICT.

ALL DIMENSIONS ARE IN METER, SCALE - 1:100

AREA DETAILS:

FLOOR DETAILS	AREA IN Sq.M		TOTAL BUILDUP AREA
	FSI	NON-FSI	
GROUND FLOOR	3450.32	—	3450.32
HEADROOM	—	259.01	259.01
TOTAL AREA			3709.33

JOINERY DETAILS :

D1	DOOR	1.22 X 2.44
D2	DOOR	1.06 X 2.44
D3	DOOR	0.99 X 2.44
D4	DOOR	0.76 X 2.13
LD	OPENING	0.91 X 2.13
W1	WINDOW	1.83 X 1.52
W2	WINDOW	1.22 X 1.52
V	VENTILATOR	0.91 X 0.76
V1	VENTILATOR	1.50 X 1.50

SANITATION REQUIREMENTS FOR EDUCATIONAL OCCUPANCY
OTHER EDUCATIONAL INSTITUTIONS - BOYS:

TOTAL NO OF STUDENTS - 400 NOS
TOTAL NO OF STAFFS - 30 NOS

S.NO	SANITARY UNIT	REQUIRED	PROVIDED
1	WATER CLOSET(W.C)	10	10
2	WATER CLOSET(W.C) FOR P.H	2	2
3	URINALS	20	20
4	WASHBASIN	10	18
5	DRINKING WATER	8	8

NOTE :

1. RAINWATER STORAGE TANK TO BE PROVIDED
2. DRINKING WATER STORAGE TANK TO BE PROVIDED
3. FIRE SAFETY STORAGE TANK TO BE PROVIDED
4. SOLAR PHOTO VOLTAIC PANELS TO BE PROVIDED
5. SOLAR ENERGY HEATING SYSTEM TO BE PROVIDED
6. FA - FIRE ALARM TO BE PROVIDED
7. FE - FIRE EXTINGUISHER TO BE PROVIDED
8. E.EXIT - EMERGENCY EXIT PROVIDED
9. RAMP RATIO OF 1:12 PROVIDED
10. LIFT TO BE PROVIDED FOR FUTURE EXPANSION
11. TRANSFORMER YARD PROVIDED
12. RWP - RAINWATER COLLECTION PITS
13. WATER SUMP PROVIDED
14. SEPTIC TANK PROVIDED

THE CORRESPONDENT,
DR.ABDULLAH ARTS AND SCEINCE COLLEGE FOR MEN
PULLANGUDI VILLAGE,
RAMANATHAPURAM.

MANAGING TRUSTEE
Syed Ammal Trust
127, Swamy Vivekanandar Salai,
Ramanathapuram - 623 501.

Applicant

Er. P.R. RETHNASAMI, B.E.,
Registered Civil Engineer Grade-I
Reg.No. RE/Gr-I/SVG Region/001/2019
PAANDIYAN CONSTRUCTION
No.1, Muthuoorani South Street
Karaikudi - 630 001
Cell : 9842436203,

Registered Engineer/Architect

Er. P.R. RETHNASAMI, B.E.,
Registered Structural Engineer Grade-II (SE)
Reg. No.RE/Gr-II/SVG. Dist./012/2021
PAANDIYAN CONSTRUCTION
No.1, Muthuoorani South Street
Karaikudi - 630 001
Cell : 9842436203

Registered Structural Engineer

Er. V. MUTHU B.E., M.I.E., F.I.V., M.Sc (Valuation),
Registered Valuer: No:1881/RV/02/2019/12232
I.T. Reg. No. 07/2004 - 05 (Wealth Tax)
Chartered Engineer, Consulting Civil Engineer
DTCP Regd. Construction Engineer
No. CE /SVG / Region / 001 /2019
No:25, " Ever Green Complex ", College Road
Karaikudi - 2, Sivagangai District.
Ph: 04565 - 226127, Cell: 94432 - 26127

Registered Construction Engineer

Ar. R. SUDHARSANA PANDIYAN, B.Arch.,
Registered Architect
Regd.No.CA/2018/103016
Paandiyan Architectural Designn Studio
No.1, Muthuoorani South Street
Karaikudi - 630 001
Cell : 9698295810, 8248580953

Registered Engineer/Architect

ONLINE SCRUTINY REFERENCE NUMBER:8HMXJCPG
ONLINE APPLICATION NUMBER :SWP/BPA/040368/2023
BP/DTCP(RAMANATHAPURAM DISTRICT) NO: 12 /2023

Office Use

PLAN SHOWING THE PROPOSED CONSTRUCTION OF DR.ABDULLAH ARTS AND SCIENCE COLLEGE FOR MEN IN S.NO - 255/1A2(part), PULLANGUDI VILLAGE, RAMANATHAPURAM TALUK, RAMANATHAPURAM DISTRICT.

ALL DIMENSIONS ARE IN METER, SCALE - 1:100

AREA DETAILS:

FLOOR DETAILS	AREA IN SqM		TOTAL BUILDUP AREA
	FSI	NON-FSI	
GROUND FLOOR	3450.32	—	3450.32
HEADROOM	—	259.01	259.01
TOTAL AREA	3450.32	259.01	3709.33

JOINERY DETAILS :

D1	DOOR	1.22 X 2.44
D2	DOOR	1.06 X 2.44
D3	DOOR	0.99 X 2.44
D4	DOOR	0.76 X 2.13
LD	OPENING	0.91 X 2.13
W1	WINDOW	1.83 X 1.52
W2	WINDOW	1.22 X 1.52
V	VENTILATOR	0.91 X 0.76
V1	VENTILATOR	1.50 X 1.50

SANITATION REQUIREMENTS FOR EDUCATIONAL OCCUPANCY
OTHER EDUCATIONAL INSTITUTIONS - BOYS:

TOTAL NO OF STUDENTS - 400 NOS
TOTAL NO OF STAFFS - 30 NOS

S.NO	SANITARY UNIT	REQUIRED	PROVIDED
1	WATER CLOSET(W.C)	10	10
2	WATER CLOSET(W.C) FOR P.H	2	2
3	URINALS	20	20
4	WASHBASIN	10	18
5	DRINKING WATER	8	8

NOTE :

1. RAINWATER STORAGE TANK TO BE PROVIDED
2. DRINKING WATER STORAGE TANK TO BE PROVIDED
3. FIRE SAFETY STORAGE TANK TO BE PROVIDED
4. SOLAR PHOTO VOLTAIC PANELS TO BE PROVIDED
5. SOLAR ENERGY HEATING SYSTEM TO BE PROVIDED
6. FA - FIRE ALARM TO BE PROVIDED
7. FE - FIRE EXTINGUISHER TO BE PROVIDED
8. E.EXIT - EMERGENCY EXIT PROVIDED
9. RAMP RATIO OF 1:12 PROVIDED
10. LIFT TO BE PROVIDED FOR FUTURE EXPANSION
11. TRANSFORMER YARD PROVIDED
12. RWP - RAINWATER COLLECTION PITS
13. WATER SUMP PROVIDED
14. SEPTIC TANK PROVIDED

THE CORRESPONDENT,
DR.ABDULLAH ARTS AND SCEINCE COLLEGE FOR MEN
PULLANGUDI VILLAGE,
RAMANATHAPURAM.

Applicant

Registered Engineer/Architect


Registered Structural Engineer


Registered Construction Engineer

Registered Engineer/Architect


ONLINE SCRUTINY REFERENCE NUMBER:8HMXJCPG
ONLINE APPLICATION NUMBER :SWP/BPA/040368/2023
BP/DTCP(RAMANATHAPURAM DISTRICT) NO: 12 /2023

Office Use

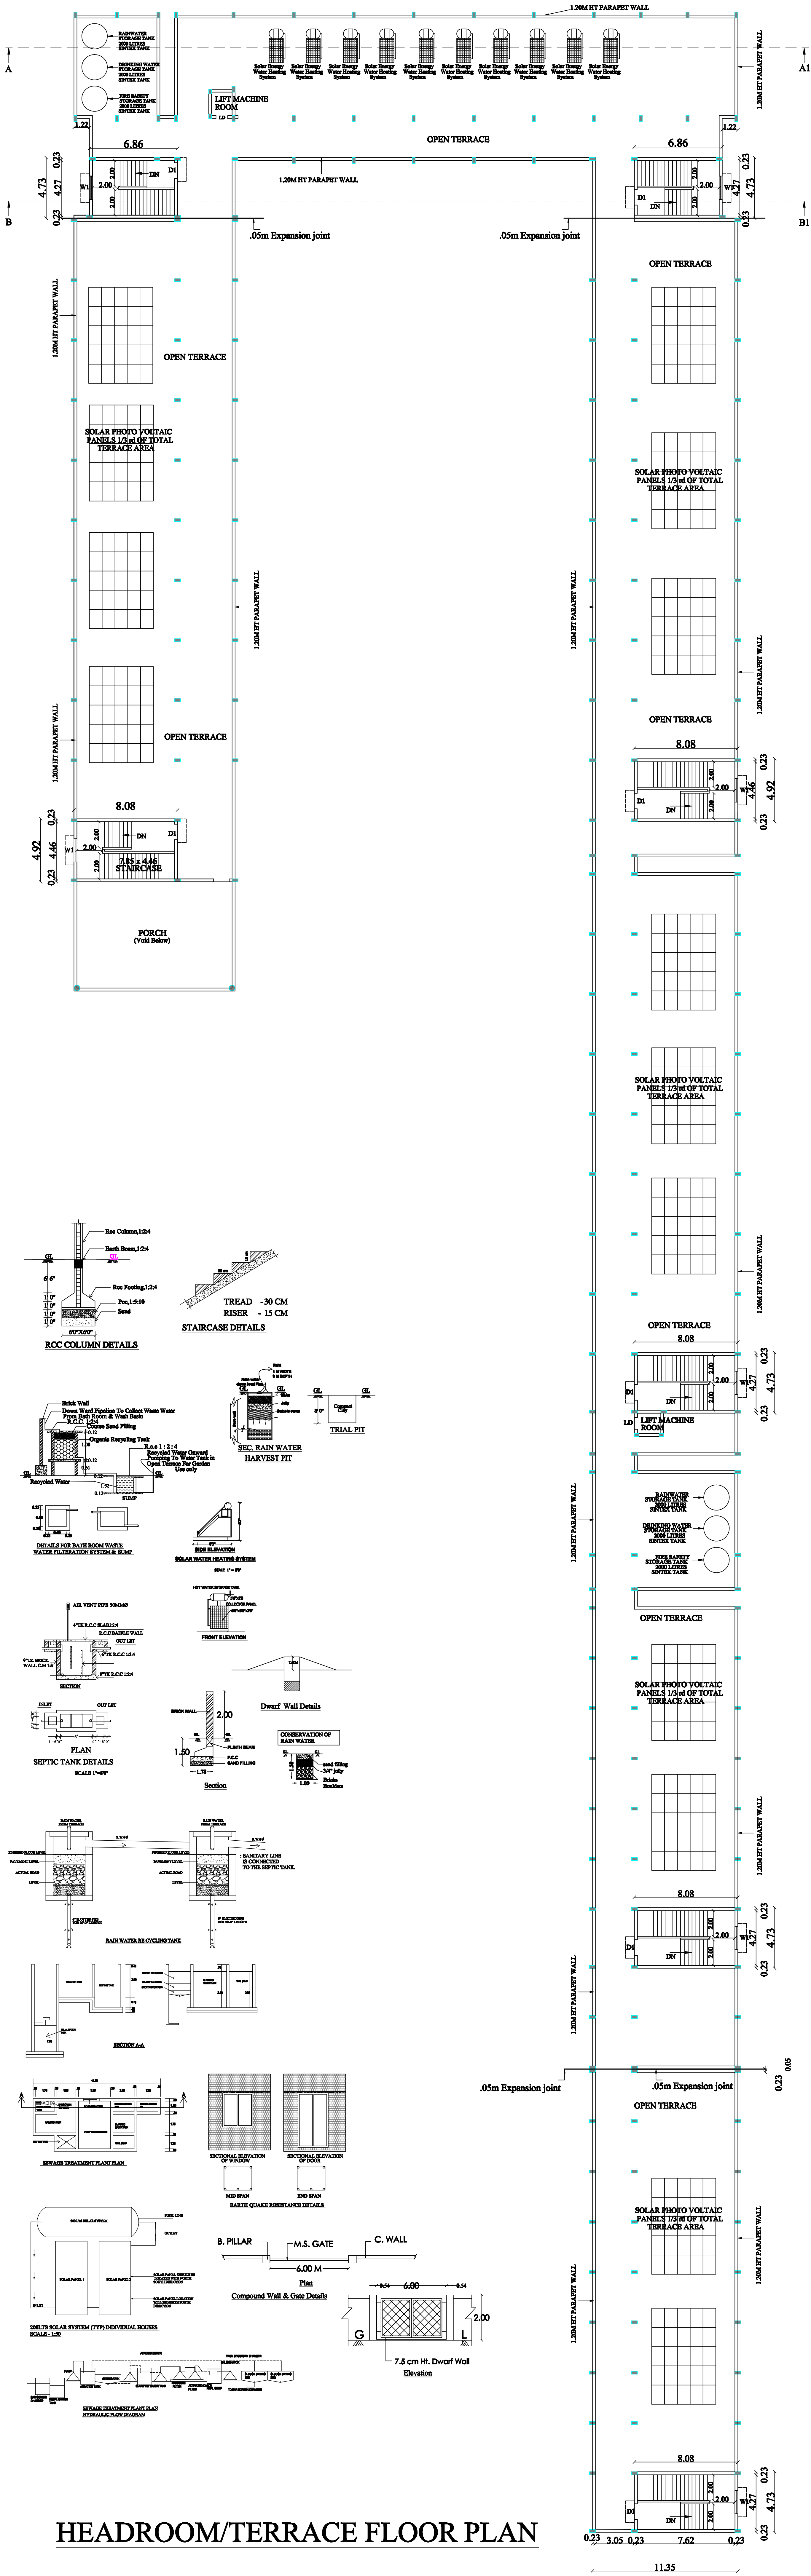


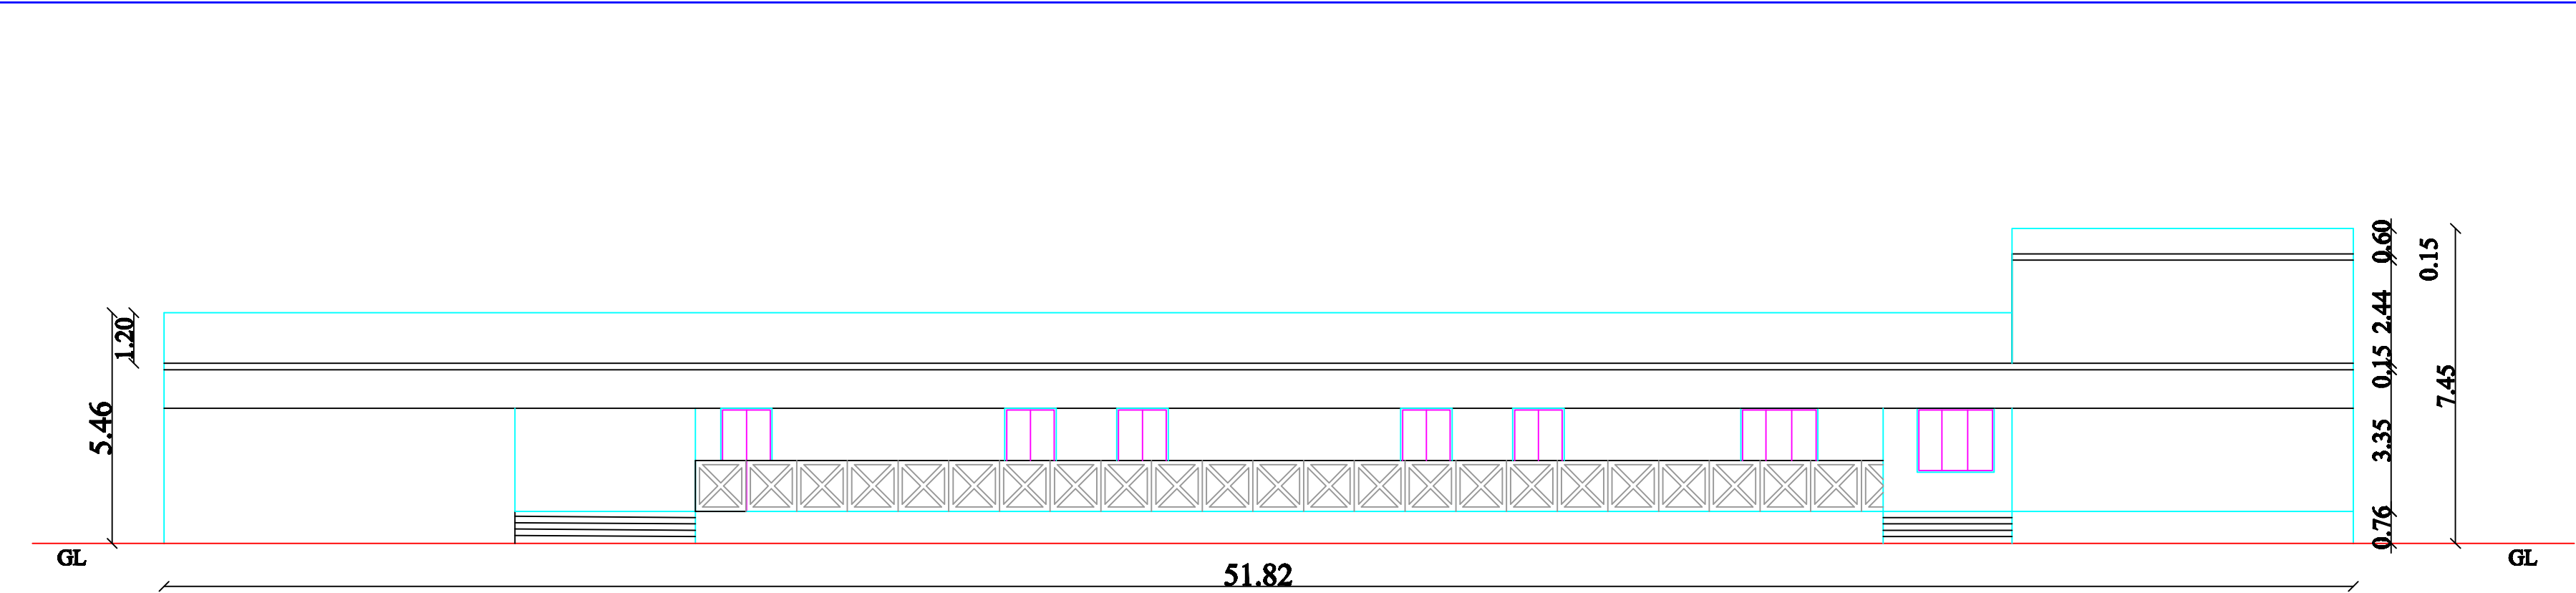

FRONT ELEVATION

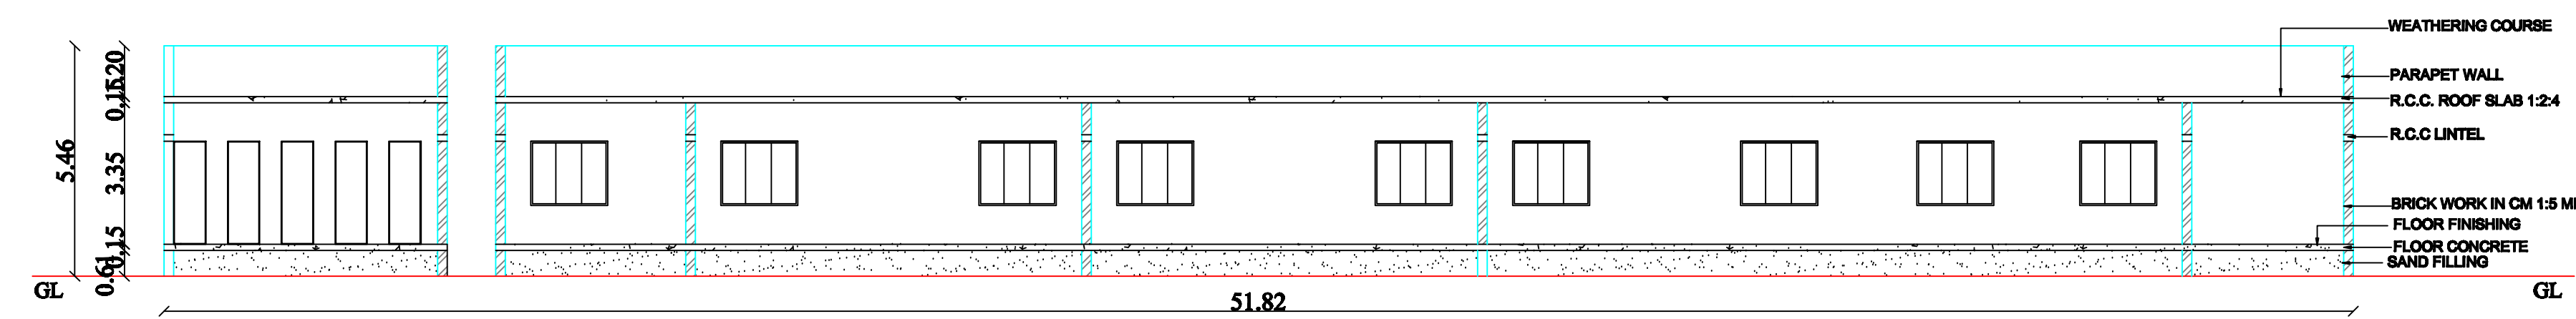

SECTION A-A1

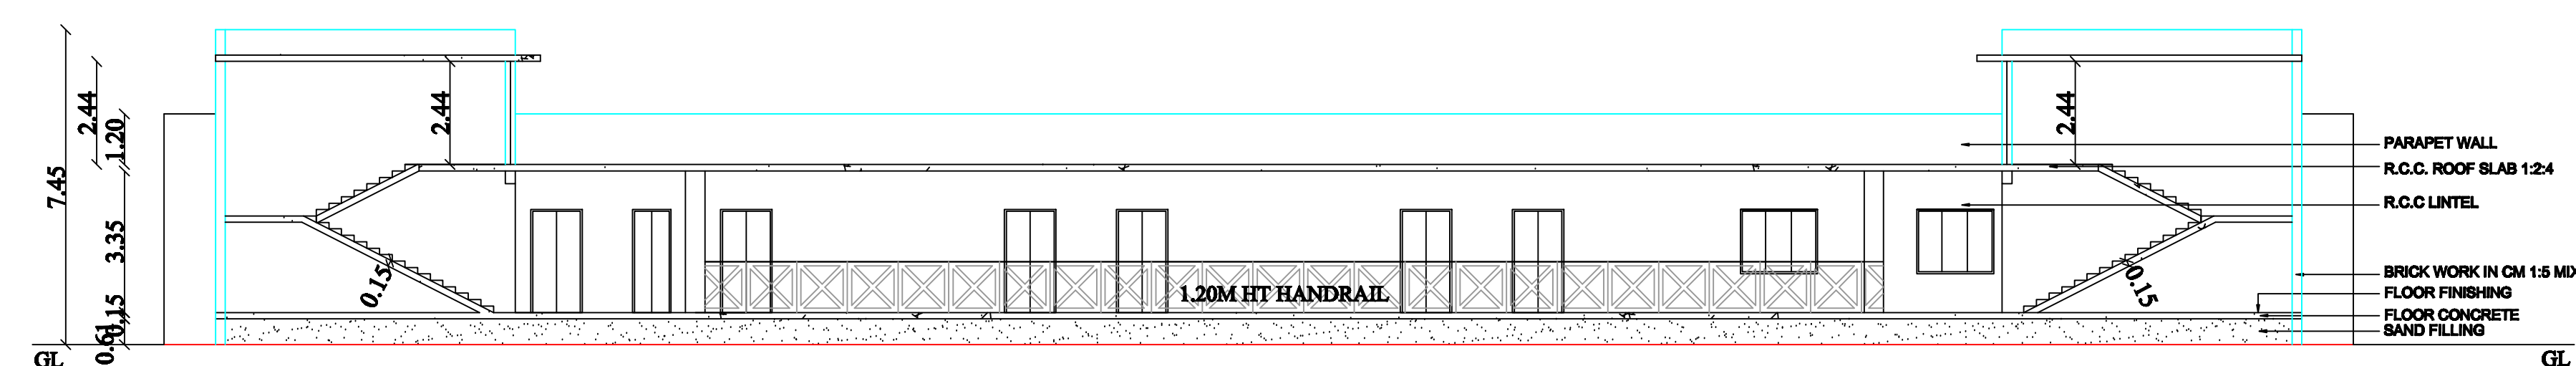

SECTION B-B1

SHEET NO - 3


PLAN SHOWING THE PROPOSED CONSTRUCTION OF DR.ABDULLAH ARTS AND SCIENCE COLLEGE FOR MEN IN S.NO - 255/1A2(part), PULLANGUDI VILLAGE, RAMANATHAPURAM TALUK, RAMANATHAPURAM DISTRICT.

ALL DIMENSIONS ARE IN METER, SCALE - 1:100


JOINERY DETAILS :

D1	DOOR	1.22 X 2.44
D2	DOOR	1.06 X 2.44
D3	DOOR	0.99 X 2.44
D4	DOOR	0.76 X 2.13
LD	OPENING	0.91 X 2.13
W1	WINDOW	1.83 X 1.52
W2	WINDOW	1.22 X 1.52
V	VENTILATOR	0.91 X 0.76
V1	VENTILATOR	1.50 X 1.50


THE CORRESPONDENT,
DR.ABDULLAH ARTS AND SCIENCE COLLEGE FOR MEN
PULLANGUDI VILLAGE,
RAMANATHAPURAM.

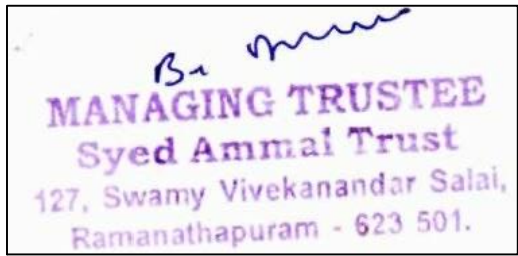


Applicant

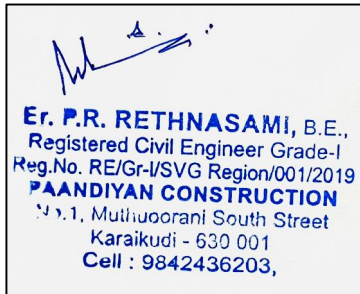

Registered Engineer/Architect

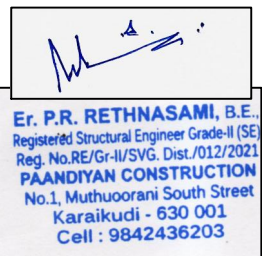

Registered Structural Engineer

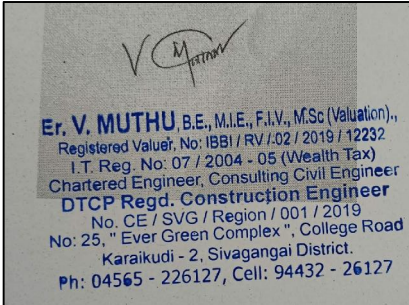

Registered Construction Engineer

ONLINE SCRUTINY REFERENCE NUMBER:8HMJCJCPG
ONLINE APPLICATION NUMBER :SWP/BPA/040388/2023
BP/DTCP(RAMANATHAPURAM DISTRICT) NO: 12 /2023

Office Use

ALL DIMENSIONS ARE IN METER, SCALE - 1:200