
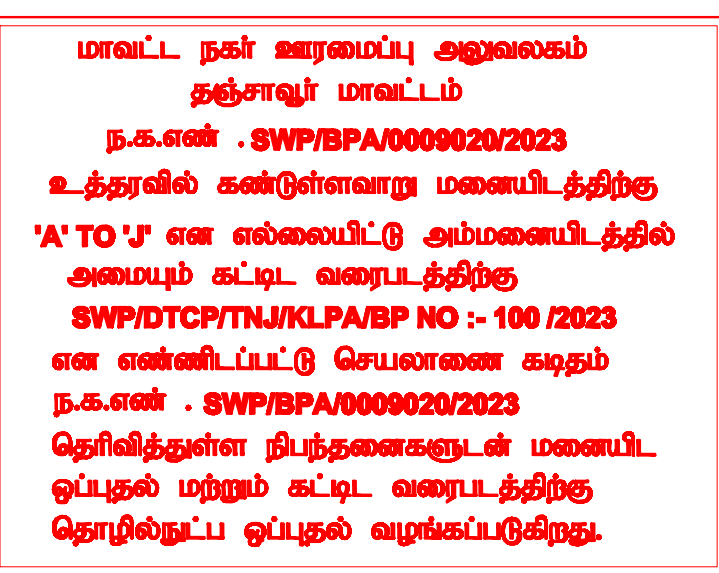


AT T.S.NO: 2125/1B,2125/1C1 ,2129/4 & 2127/4 (OLD NO:2125/1B&1C1 ,2127/4,5&6 & 2129 PART) , WARD NO: 06, BLOCK NO: 42,

NEW RAILWAY ROAD,KUMBAKONAM CITY MUNICIPAL CORPORATION, THANJAVUR DISTRICT.

T.S.NO:2

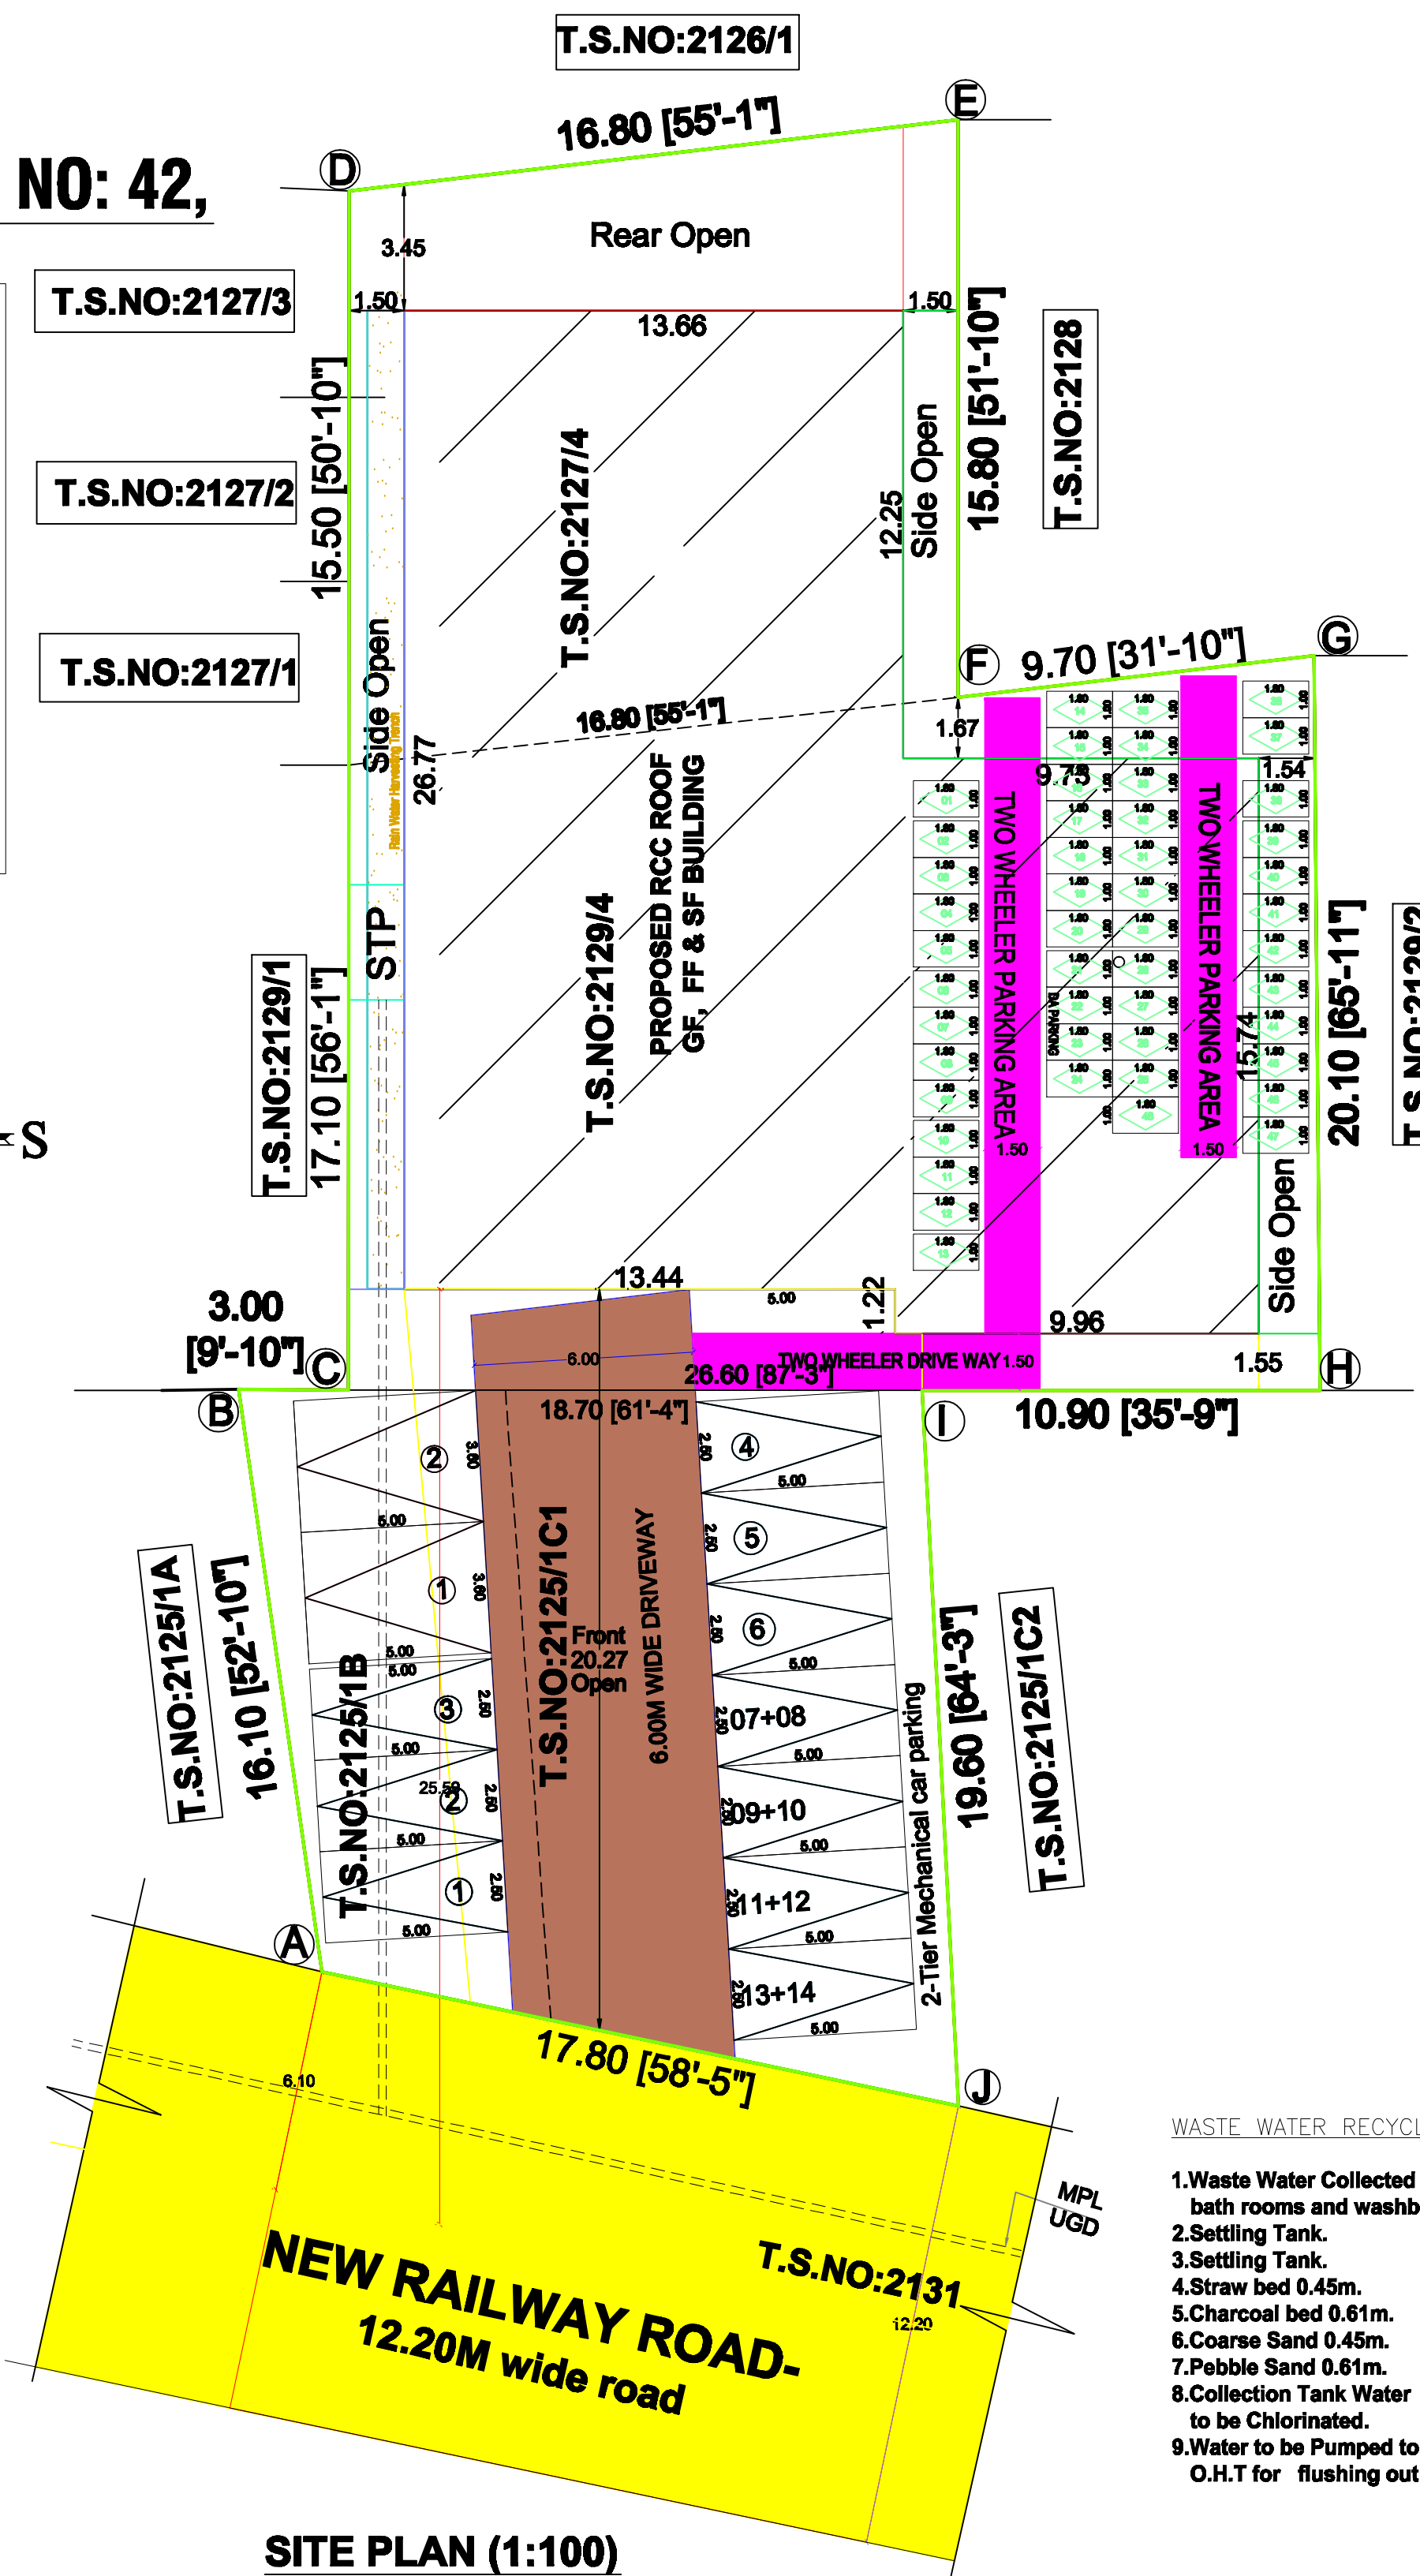

All Dimensions are in MetreScale 1:100

SCHEDULE OF JOINERY:

GD	GLASS DOOR	-3.06x2.13
LD	LEFT DOOR	-1.20x2.13
D	DOOR	-1.00x2.13
d	DOOR	-2.10x2.13
d	DOOR	-0.76x2.13
W	WINDOW	-1.84x1.52
W1	WINDOW	-1.52x1.37
V	VENTILATOR	-0.91x0.61

AREA STATEMENT:-

PLYTHM Area1072.80

Document Area1072.80

Super Imposed PCC Area1072.79

FLOOR NAME	TOTAL BUILDUP AREA	NON FIRE AREA	INCIDENTAL STRUCTURES	TOTAL COVERED AREA	TOTAL COVERED AREA
FLOORING/CORNER	519.21	519.21	103.52	-	622.73
FLOORING	77.90	77.90	-	-	77.90
FLOORING	519.21	-	-	-	519.21
FLOORING	519.21	-	-	-	519.21
TOTAL	1035.53	597.12	103.52	-	700.64

AREA STATEMENT:-

TOTAL SITE AREA- 1072.79 Sqm- 11548.00 Sqft

GROUND FLOOR AREA- 519.21 Sqm- 5589.00 Sqft

FIRST FLOOR AREA- 519.21 Sqm- 5589.00 Sqft

SECOND FLOOR AREA- 519.21 Sqm- 5589.00 Sqft

TERrace AREA- 77.90 Sqm- 838.00 Sqft

OPEN SPACE AREA- 553.58 Sqm- 5959.00 Sqft

NOTE:

MANUAL / AUTOMATIC FIRE ALARM SYSTEM, THE PROTECTION AND DISTURBING SYSTEM ARE PROVIDED, CONFORMY TO THE STANDARDS & RECOMMENDATIONS AND TO THE NOTIFICATION OF THE DISCREPANCIES OF THE SERVICE.

RAIN WATER HARVESTING SYSTEMS ARE PROVIDED AS PER THE STANDARD SPECIFICATIONS IN OLD WS NO 136, NA & WS D-11, 10, 92, 82.

APPLICANT:

REGISTERED ENGINEER:

Mr. S.KATYANASUNDARAM

ARCHITECT:

STRUCTURAL ENGINEER:

A.C.GOWDHANSHANKAR'S Reg.No. CA/2016/73503

R.N.HARIHARAN Reg.No.TJVNSPE-2010/073

APPROVING AUTHORITY

Surveyor - Sathya

Draftsman - Punithavathi

Supervisor - Sadapakiam

ASST. DIRECTOR / MEMBER SECRETARY

TOWN & COUNTRY PLANNING

KUMBAKONAM LOCAL PLANNING AUTHORITY

THANJAVUR DISTRICT