



PLAN SHOWING THE PROPOSED CONSTRUCTION FOR " P.A.N.MODERN RICE MILL " BUILDING IN S.F.NO : 228-1D,2C , 231-1A , 2 ,3 AT VALLAM PUDUR SETHI , THANJAVUR TALUK & DISTRICT.


SCALE 1:100

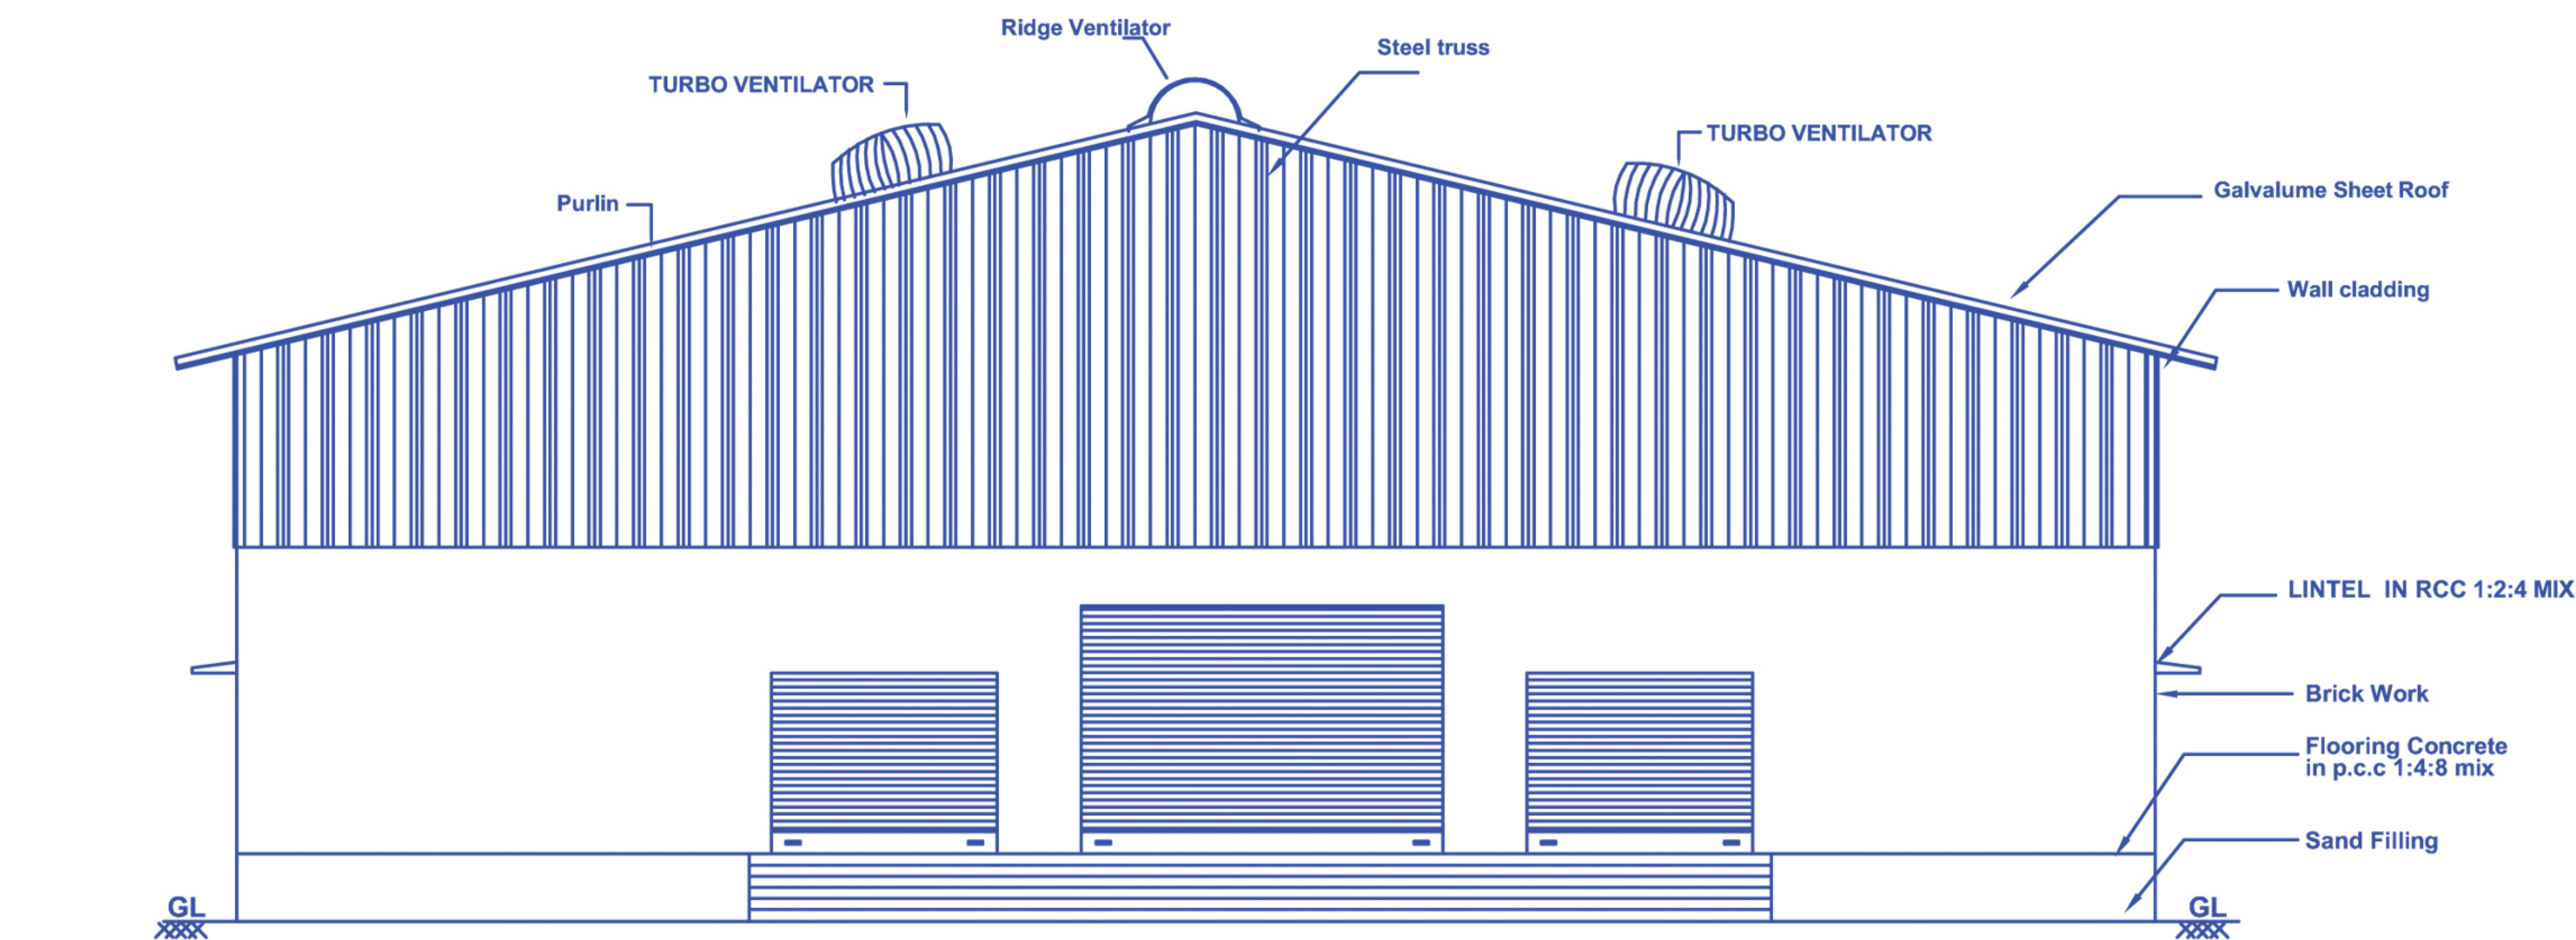


Elevation

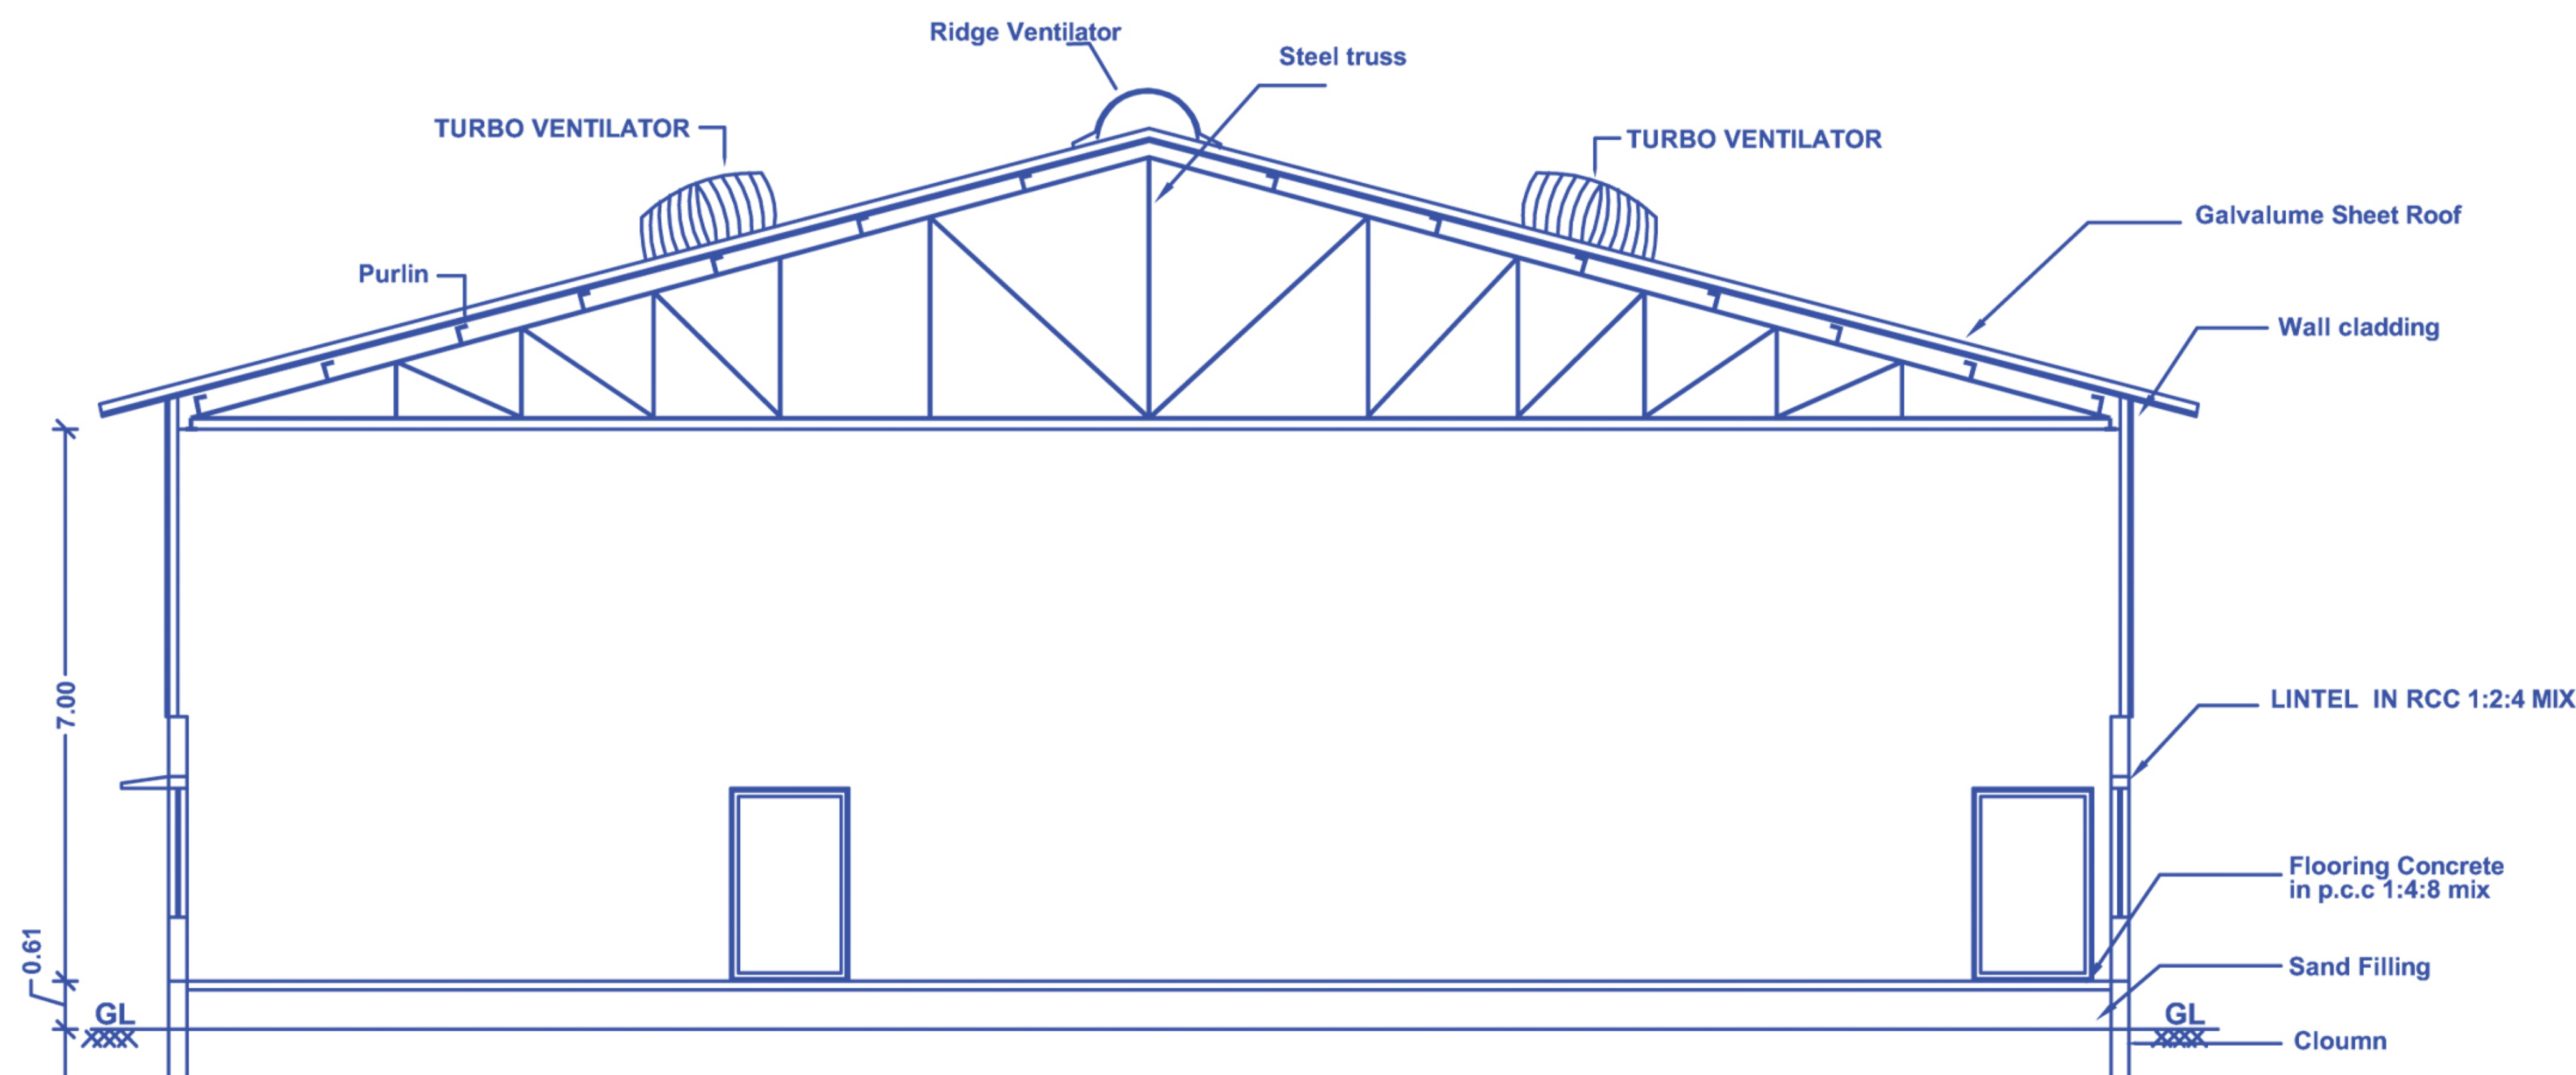








Section on 'AA'

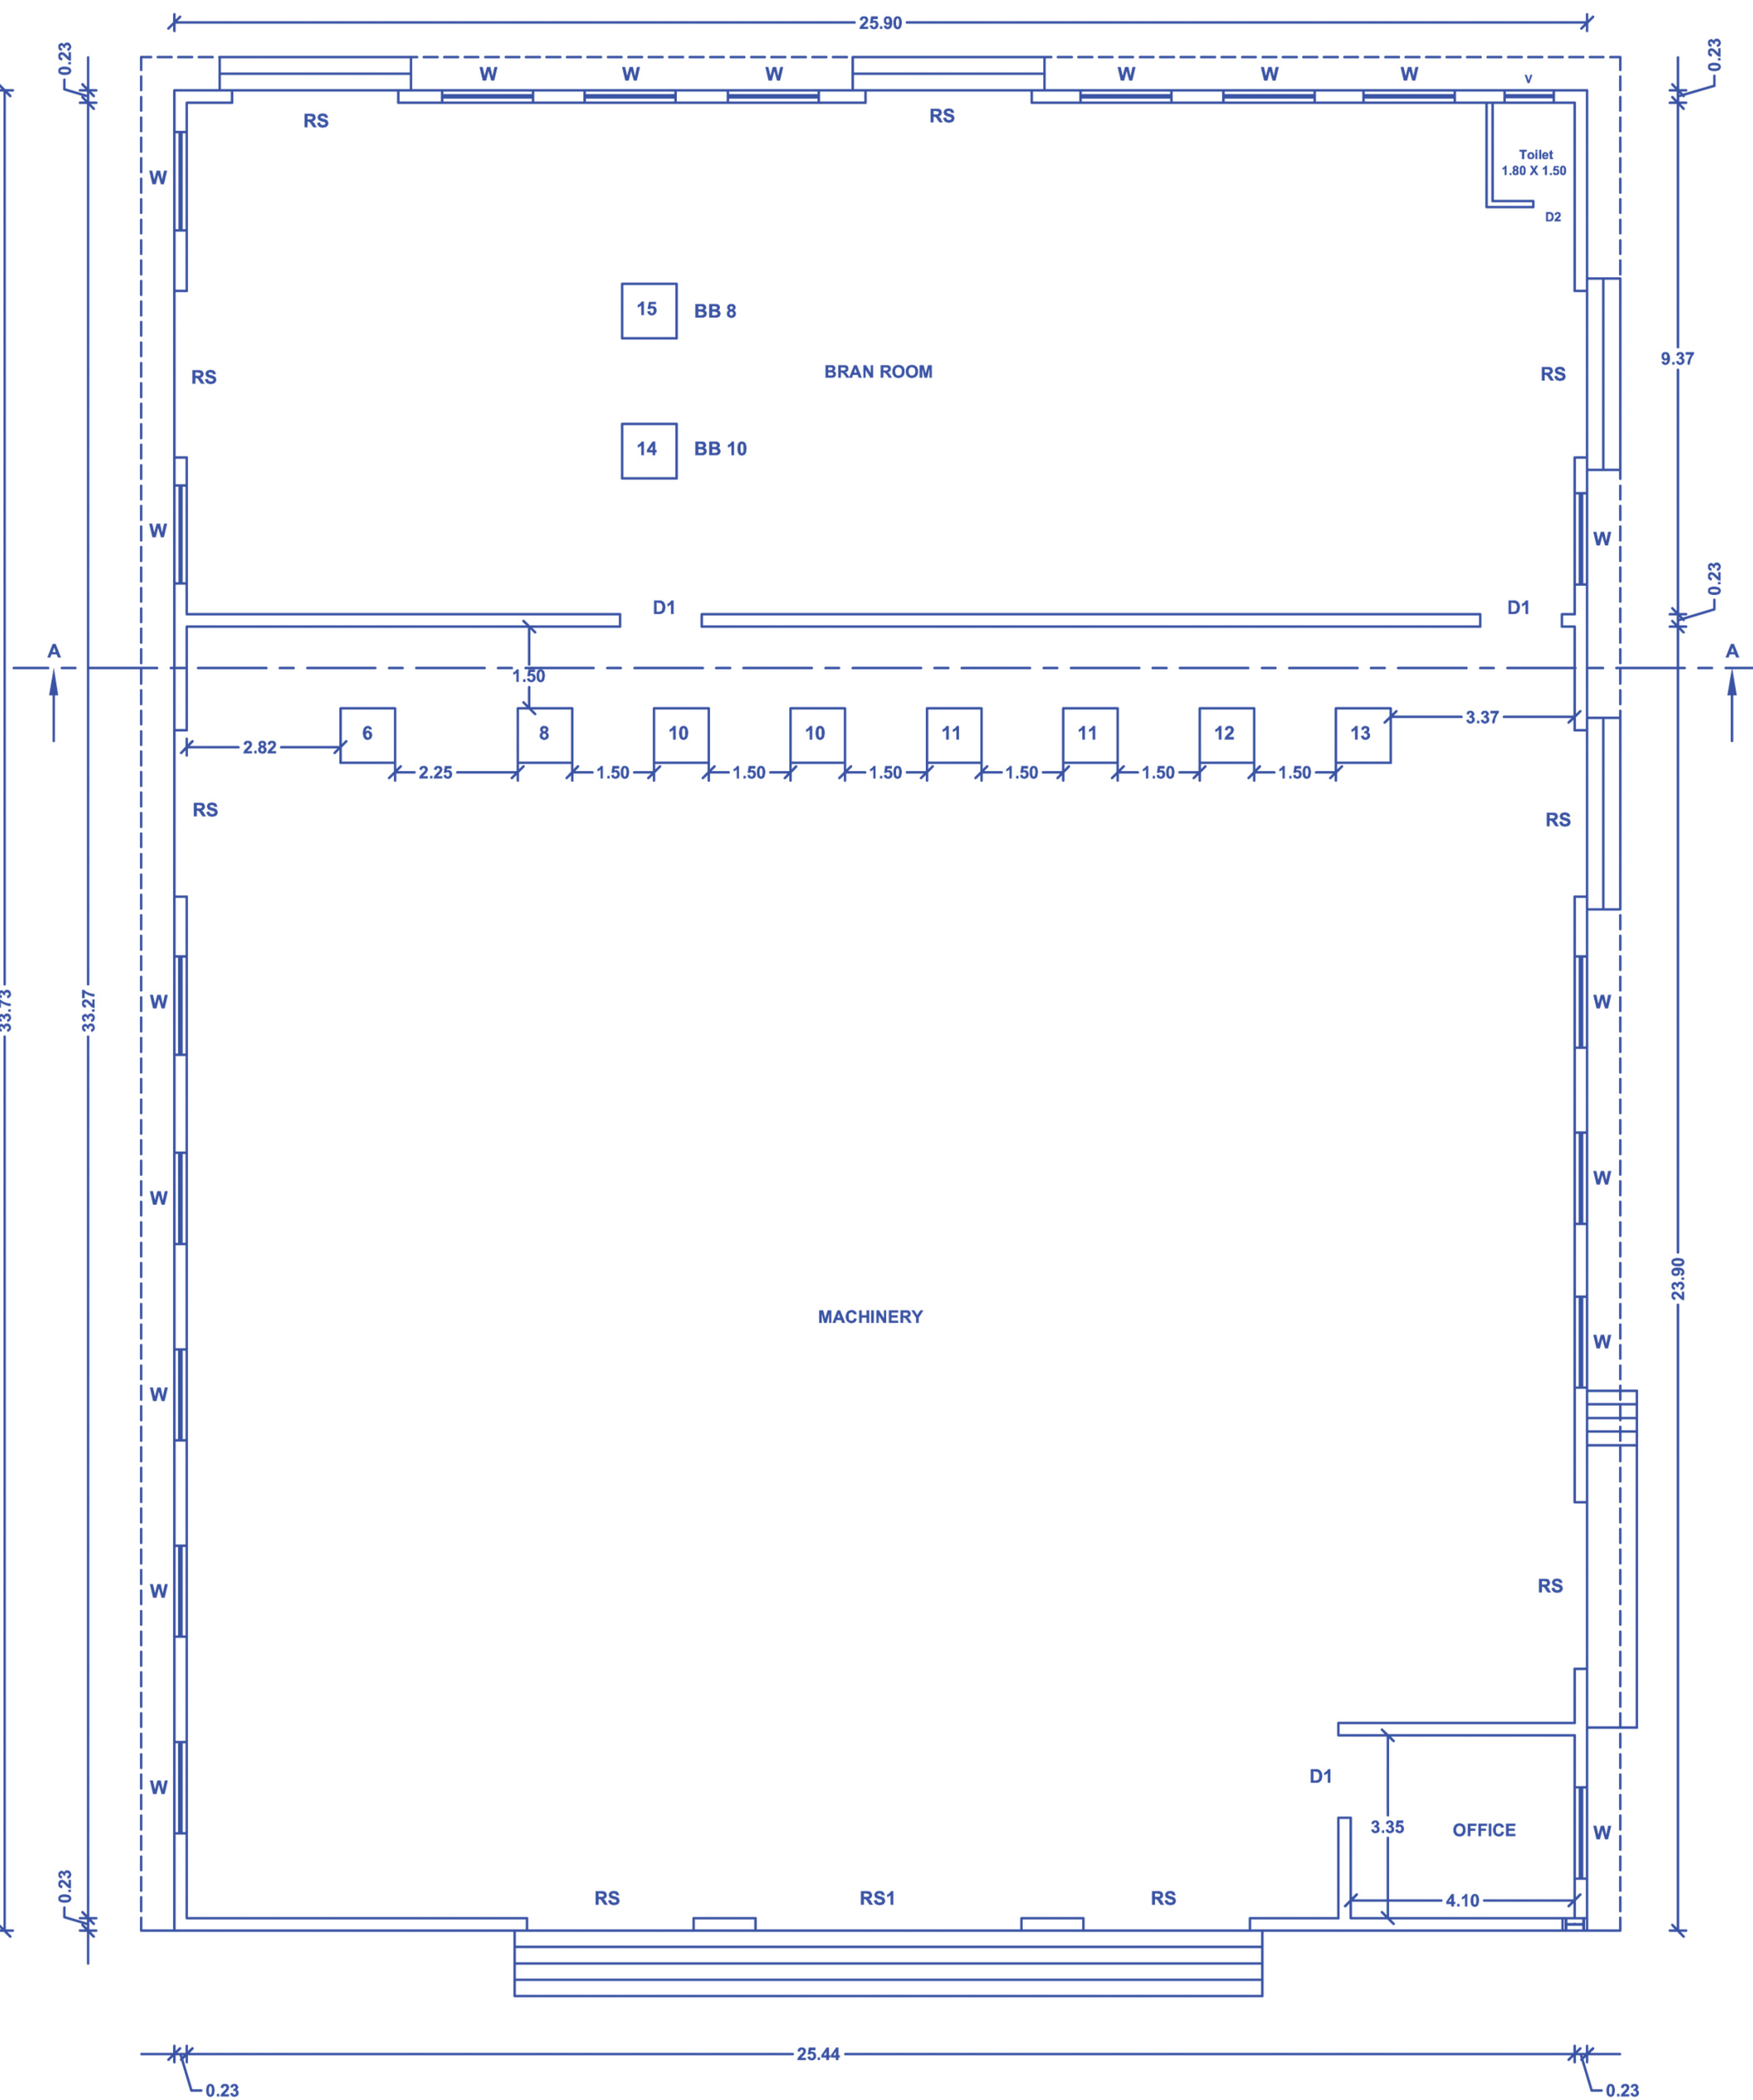

GROUND FLOOR PLAN

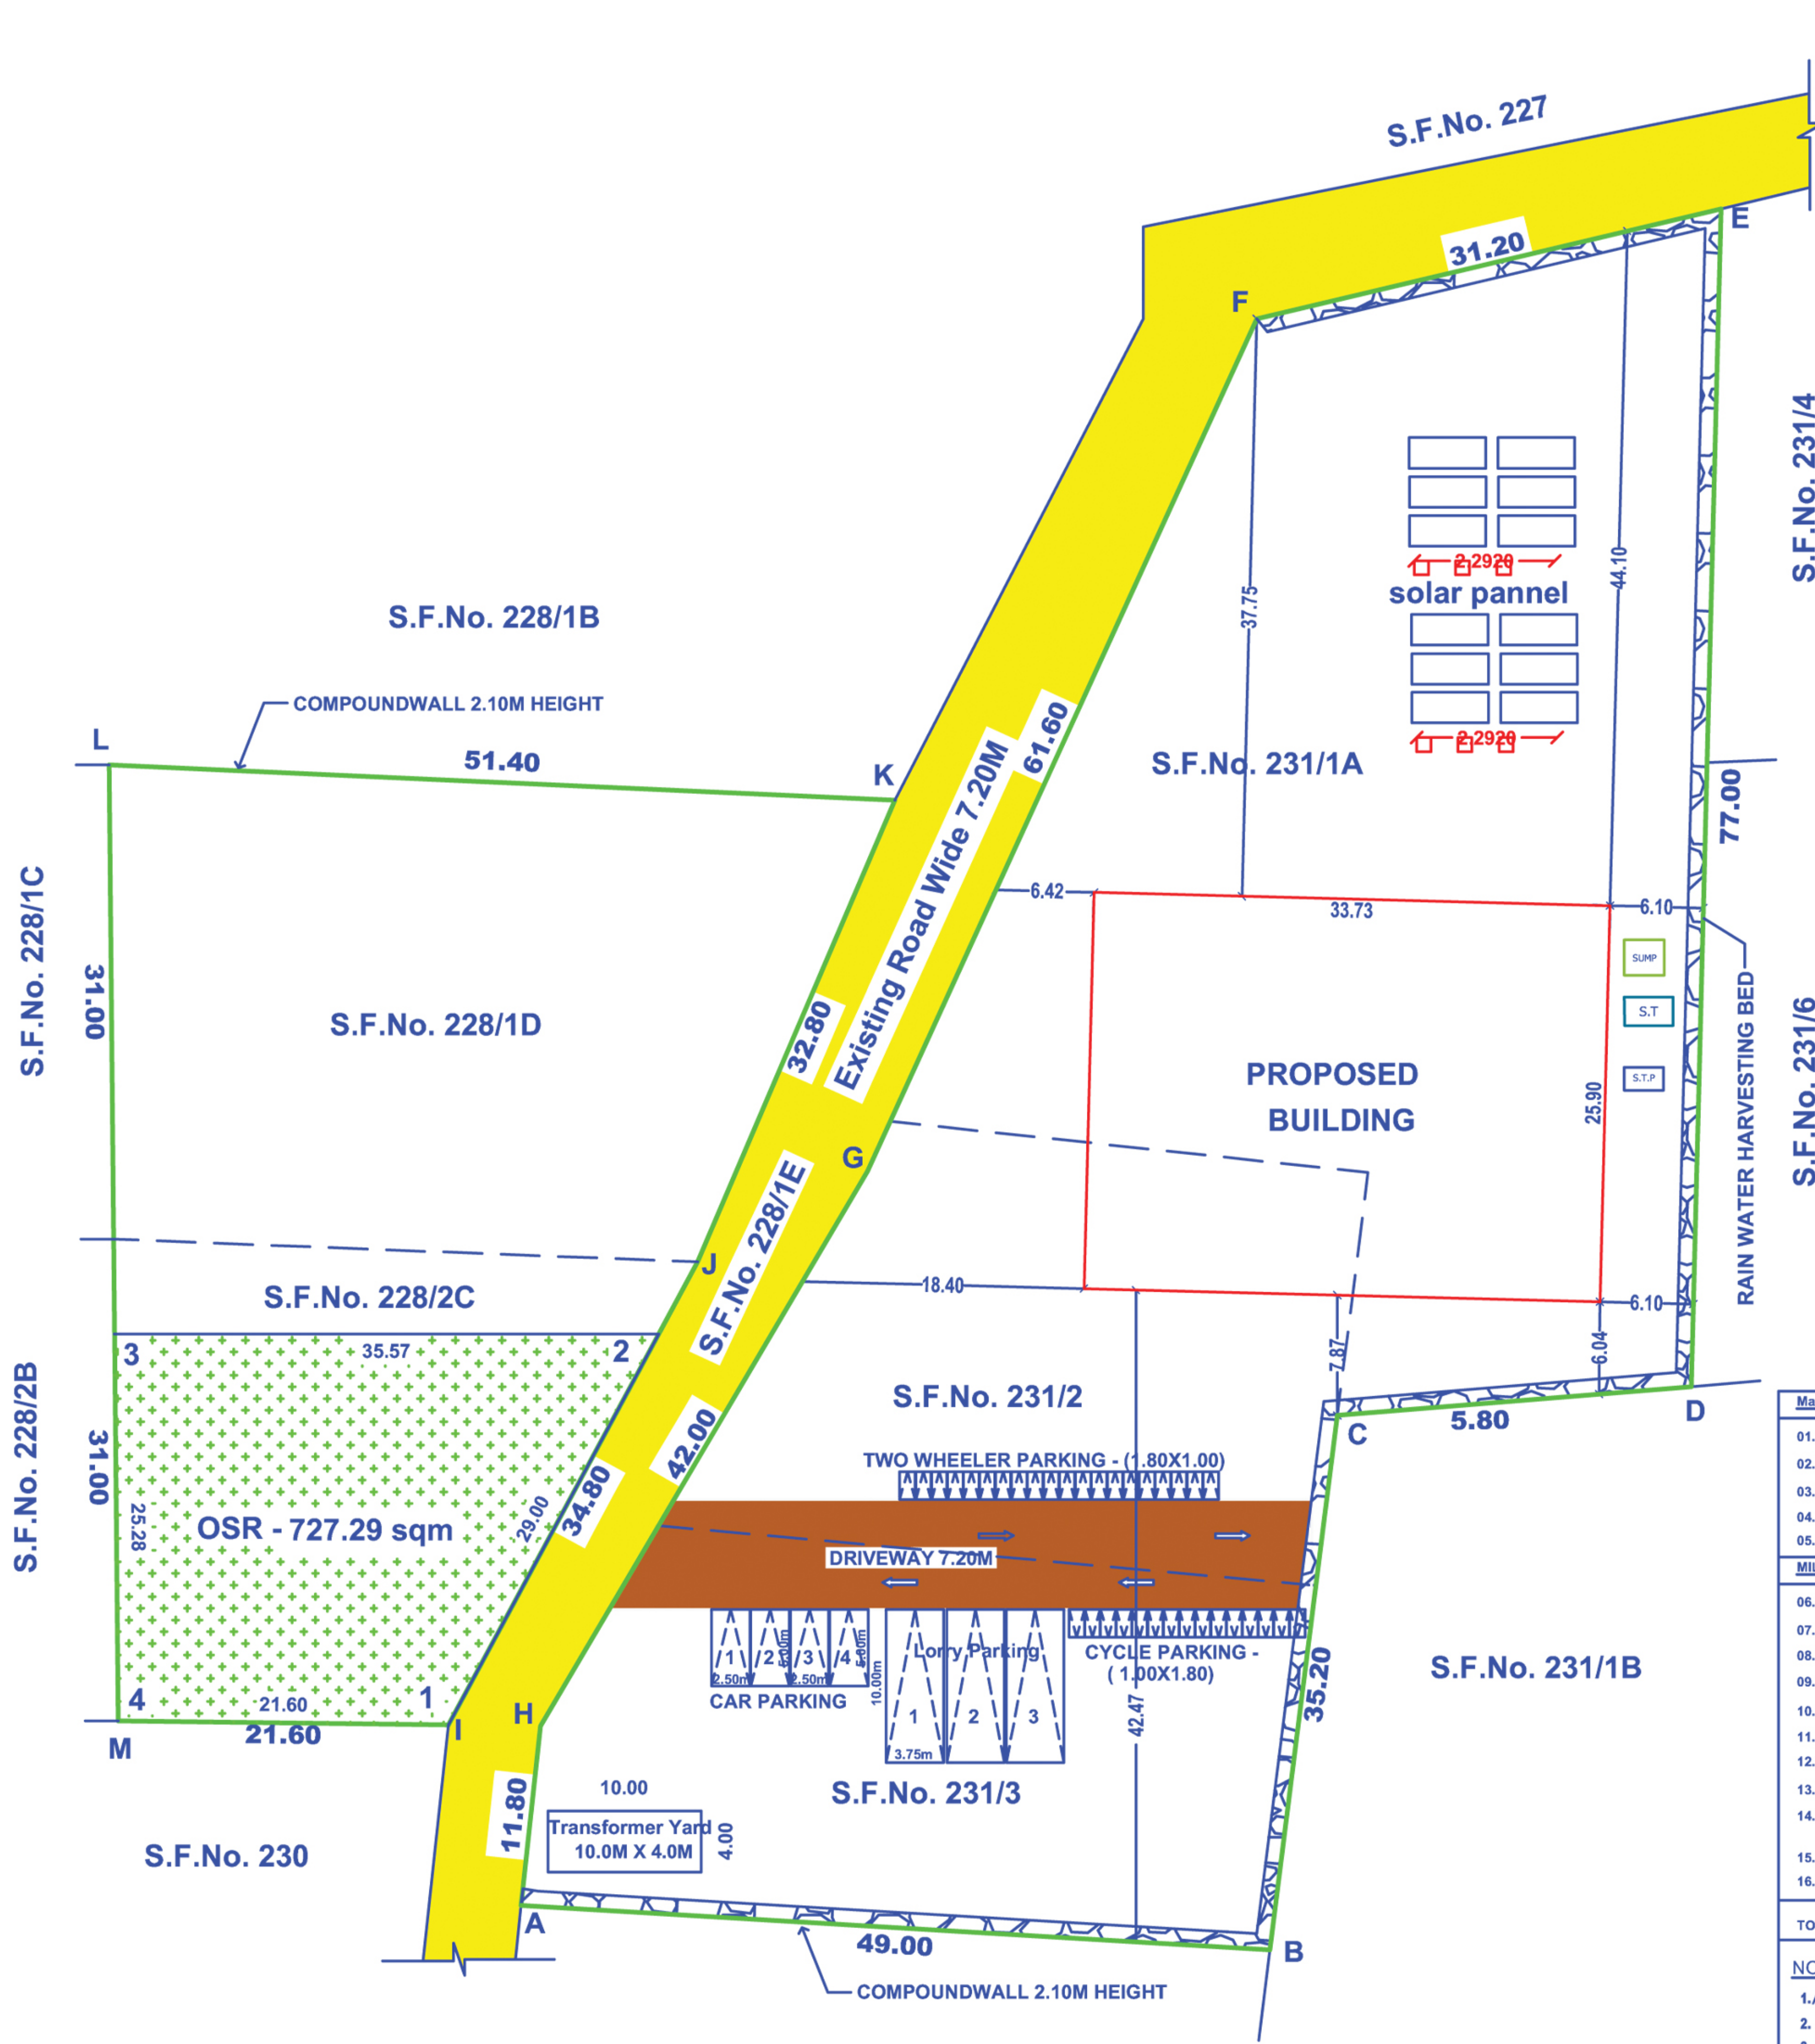

SITE PLAN
SCALE 1:400

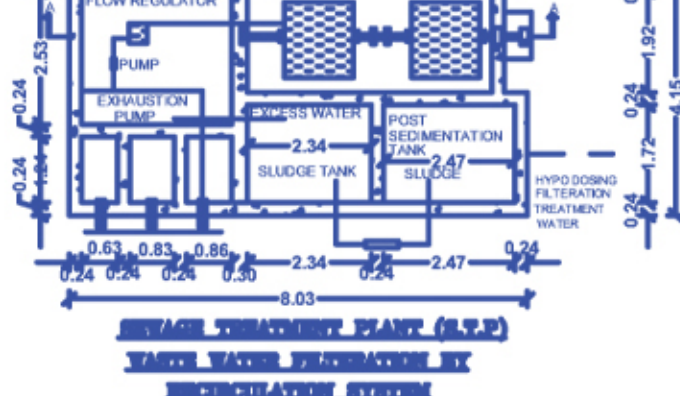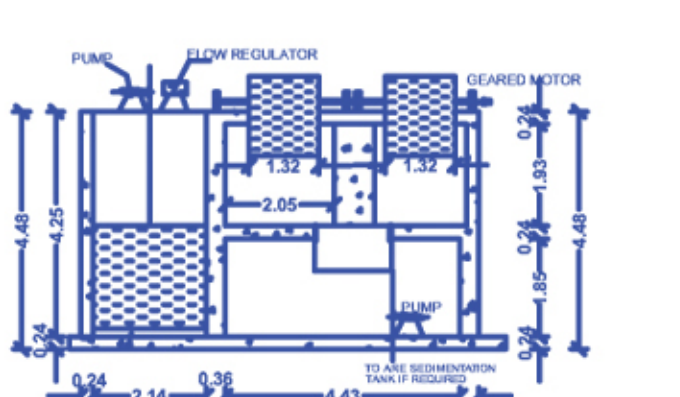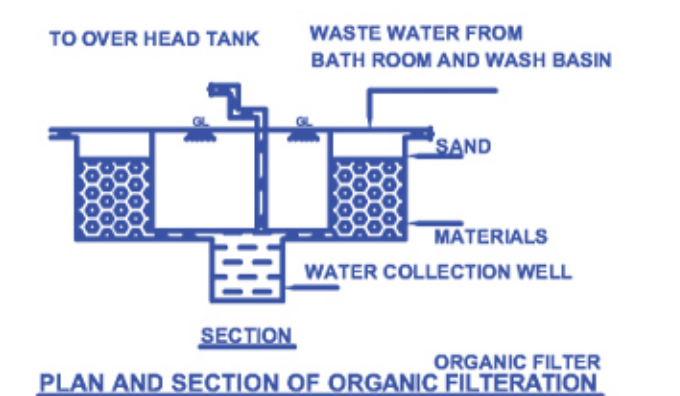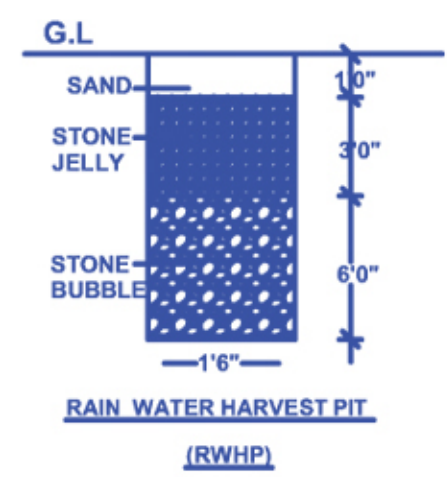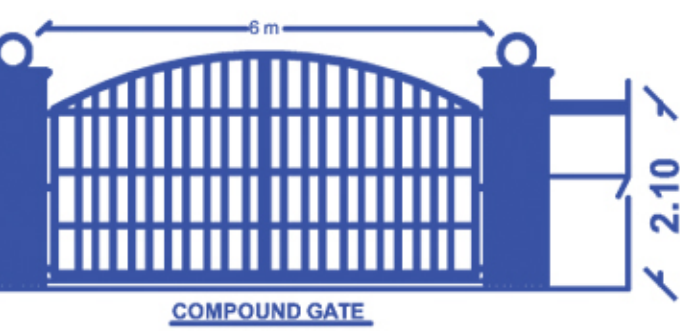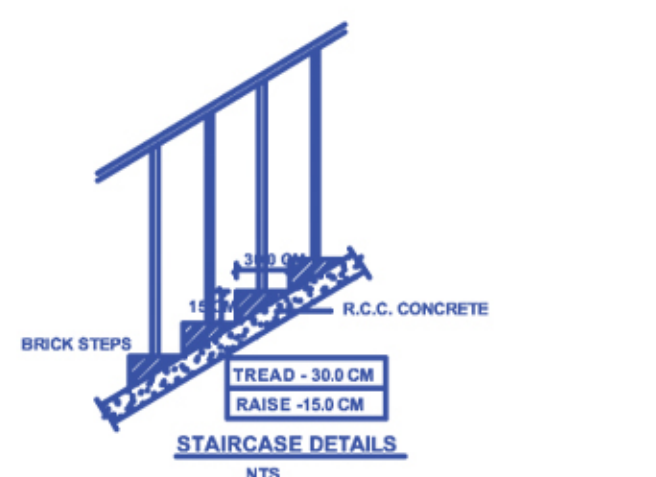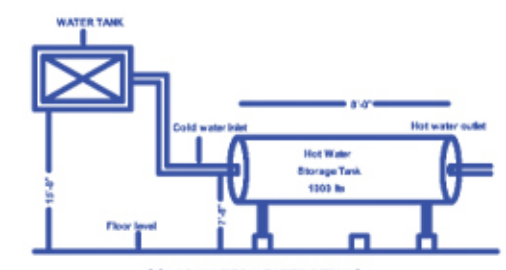

Machinery details	Numbers	HP	TOTAL HP
01. Puggalo Blower	1 No.	15 HP	15 HP
02. Elevator (B)	1 No.	5 HP	5 HP
03. Dust Blower	1 No.	3 HP	3 HP
04. Feed Roller	1 No.	2 HP	2 HP
05. Elevator	1 No.	3 HP	3 HP
MILL UNIT			
06. Paddy Selver With Aspirator	1 No.	5 HP	5 HP
07. Paddy Cleaner With Dust Blower	1 No.	5 HP	5 HP
08. Rubber Sheller	1 No.	10 HP	10 HP
09. Husk Aspirator	1 No.	3 HP	3 HP
10. Huller	1 No.	25 HP	25 HP
11. Cone	1 No.	40 HP	40 HP
12. Rice Selver With Aspirator	1 No.	2 HP	2 HP
13. Single Elevator	8 Nos.	6 HP	6 HP
14. BB10 X BB8 Ban Blower With Cyclone and Pipes	1 No.	2 HP	2 HP
15. Boiler	1 No.	18.5 HP	18.5 HP
16. Bore	1 No.	3 HP	3 HP
TOTAL			147.50 HP

- NOTES:
1. ALL DIMENSIONS ARE IN FEET & METRE
 2. RAINWATER COLLECTION WELLS WILL BE PROVIDED
 3. FIRE FIGHTING ARRANGEMENTS WILL BE PROVIDED
 4. EMERGENCY ALARMS WILL BE PROVIDED
 5. DRINKING WATER WILL BE PROVIDED
 6. GROUND WATER PUMPS WILL BE PROVIDED
 7. FILTERED RAIN WATER PUMPS WILL BE PROVIDED
 8. EXHAUST FAN PROVISION IS MADE AT TOILET & WASH
 9. SOLAR WATER HEATING SYSTEM PROVIDED.
 10. RAINWATER HARVESTING FACILITIES PROVIDED.
 11. WASTE WATER RECYCLING TRENCH AND TANK PROVIDED.
 12. SEWAGE TREATMENT PLANT PROVIDED.
 13. SEPTIC TANK PROVIDED.
 14. WATER FACILITIES PROVIDED.
 15. TRANSFORMER YARD PROVIDED.
 16. FA - FIRE ALARM PROVIDED
 17. F.E - FIRE SAFETY MEASURES PROVIDED.
 18. SB - SAND BUCKET PROVIDED

OFFICE USE

மாண்புமிகு நகர் ஊரமைப்பு அலுவலகம்
தஞ்சாவூர் மாவட்டம்
ந.க.எண் - SWP/BPA/0043984/2023
உத்தரவில் கண்டுள்ளவாறு மனையிடத்திற்கு
'A' TO 'M' என எல்லாமிடத்து அம்மனையிடத்திற்கு
அமைப்பும் கட்டிட வரைபடத்திற்கு
SWP/DTCP/TNJ/R/BP NO - 35 /2023
என எண்ணிடப்பட்டு செயலாணை கடிதம்
ந.க.எண் - SWP/BPA/0043984/2023
தொலித்துள்ள நபருக்காகவுடன் மனையிட
ஒப்பந்தம் மற்றும் கட்டிட வரைபடத்திற்கு
தொழில்நுட்ப ஒப்பந்தம் வழங்கப்படுகிறது.

Note : The OSR Site has been Marked as (1 to 4) (727.29 sqm - 10.24%)
must be maintained & owned by applicant as said in Rule No : 41
Exp (i) TNCBR - 2019

SWP / DTCP / TNJ / R / BPA NO : 35/2023

Surveyor -Ramar
Draughtman - Kannagi
Supervisor - Shanthi

ASST. DIRECTOR
TOWN & COUNTRY PLANNING
THANJAVUR DISTRICT