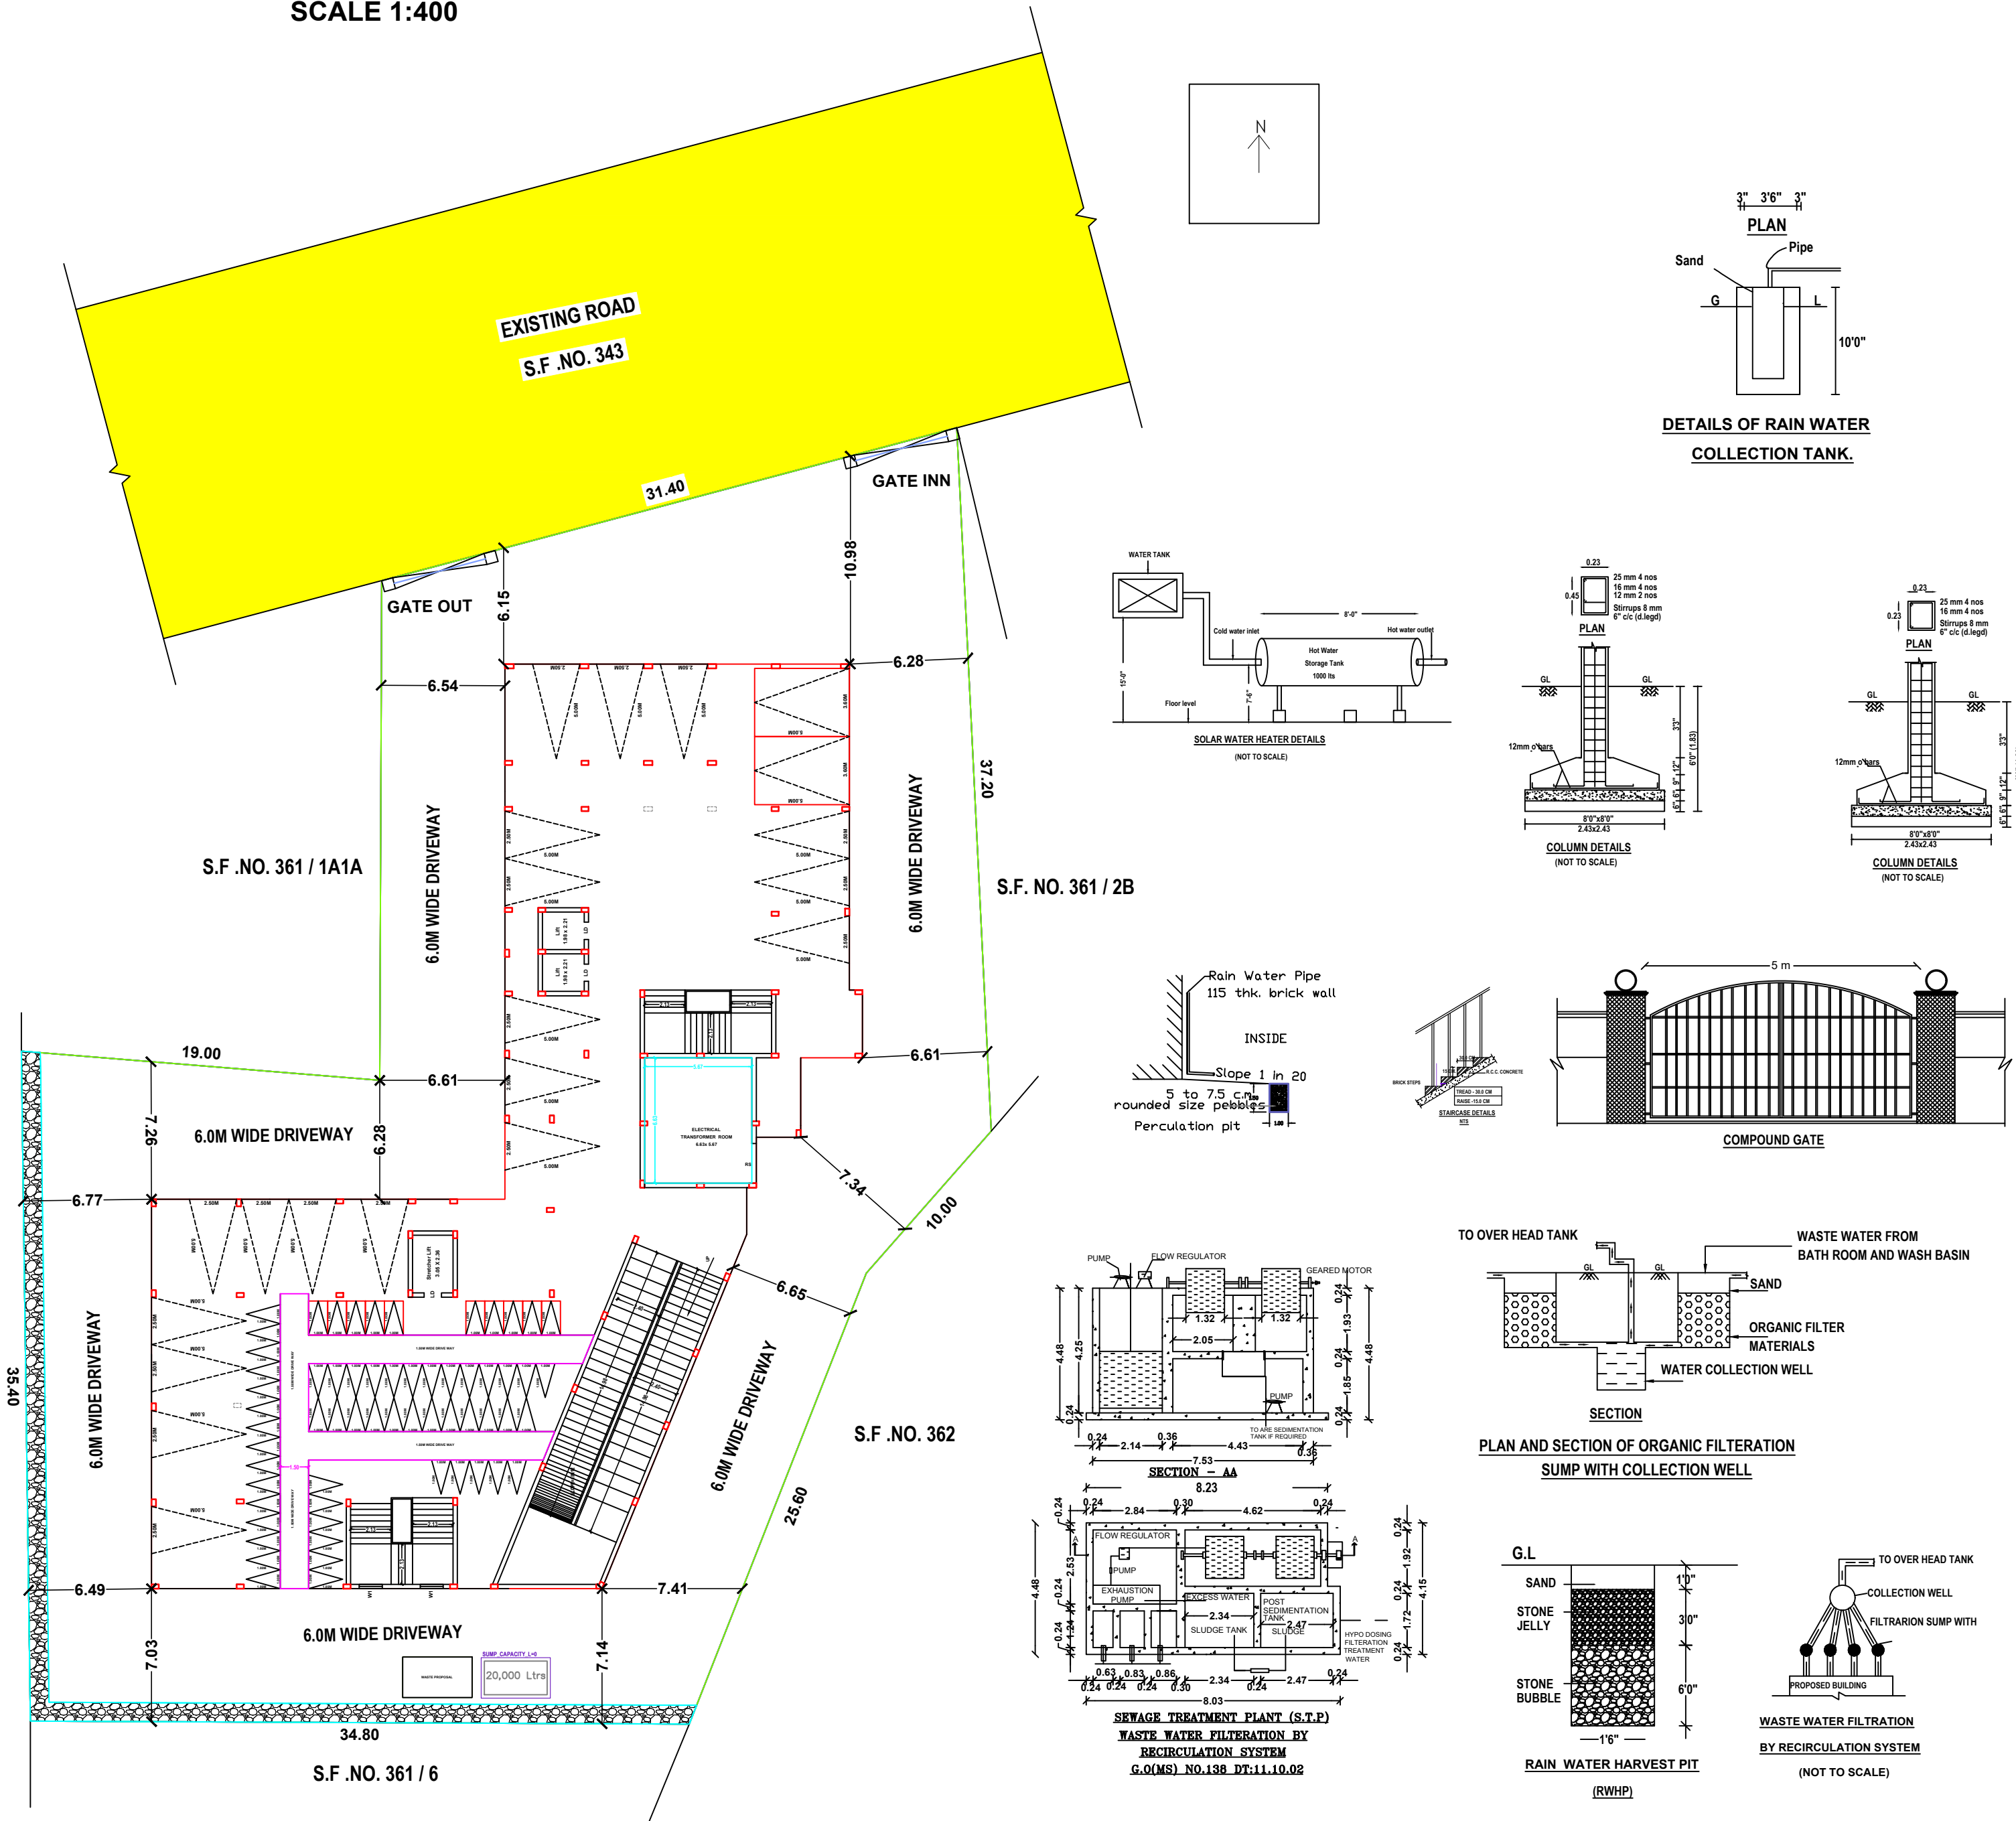


SITE PLAN SHOWING THE PROPOSED CONSTRUCTION OF HOSPITAL BUILDING IN S.F .NO. 361 / 1A1B, 1B, 2A, 3A AT THIRUVALAJULI VILLAGE & PANCHAYAT, KUMBAKONAM TALUK, THANJAVUR DISTRICT.

SCALE 1:400



AREA DETAILS	SQ.MT.	
AREA OF SITE	2250	
AREA OF STILT FLOOR AREA OF FIRST FLOOR AREA OF SECOND FLOOR AREA OF THIRD FLOOR AREA OF FOURTH FLOOR AREA OF HEADROOM TOTAL	F.S.I	NON F.S.I
		1065.03
	1063.88	
	1085.39	
	1085.16	
	433.19	47.42
		49.00
	3667.62	96.42

FLOOR SPACE INDEX (FSI) = 3667.62 / 2250 - 1.63

NUMBER OF CAR PARKING (2.50 X 5.00) = 19 NOS.

PHYSICALLY HANDICAPED PARKING (3.60 X 5.00) = 2 NOS.

NUMBER OF TWO WHEELER PARKING (1.0 X 1.80) = 61 NOS.

COLOUR INDEX

SITE BOUNDARY

EXISTING ROAD

PROPOSED BUILDING

PROPOSED DRIVE WAY

RAIN WATER PERCOLATION BED ☐

APPLICANT

L. Sivakum

B. habili

Dr.K.Sivakumar & Dr.B.Lakshmi

ENGINEER

Er. S. SELVA SUGUMARAN, B.E.
Registered Engineer Grade-II
Reg. No. NGT/RE-II/2021/012
DTCP., NAGAPATTINAM,
No. 2, Kenikarai, Thiruvananthapuram Road,
Mayiladuthurai-605 001,
Cell: 9080750852.

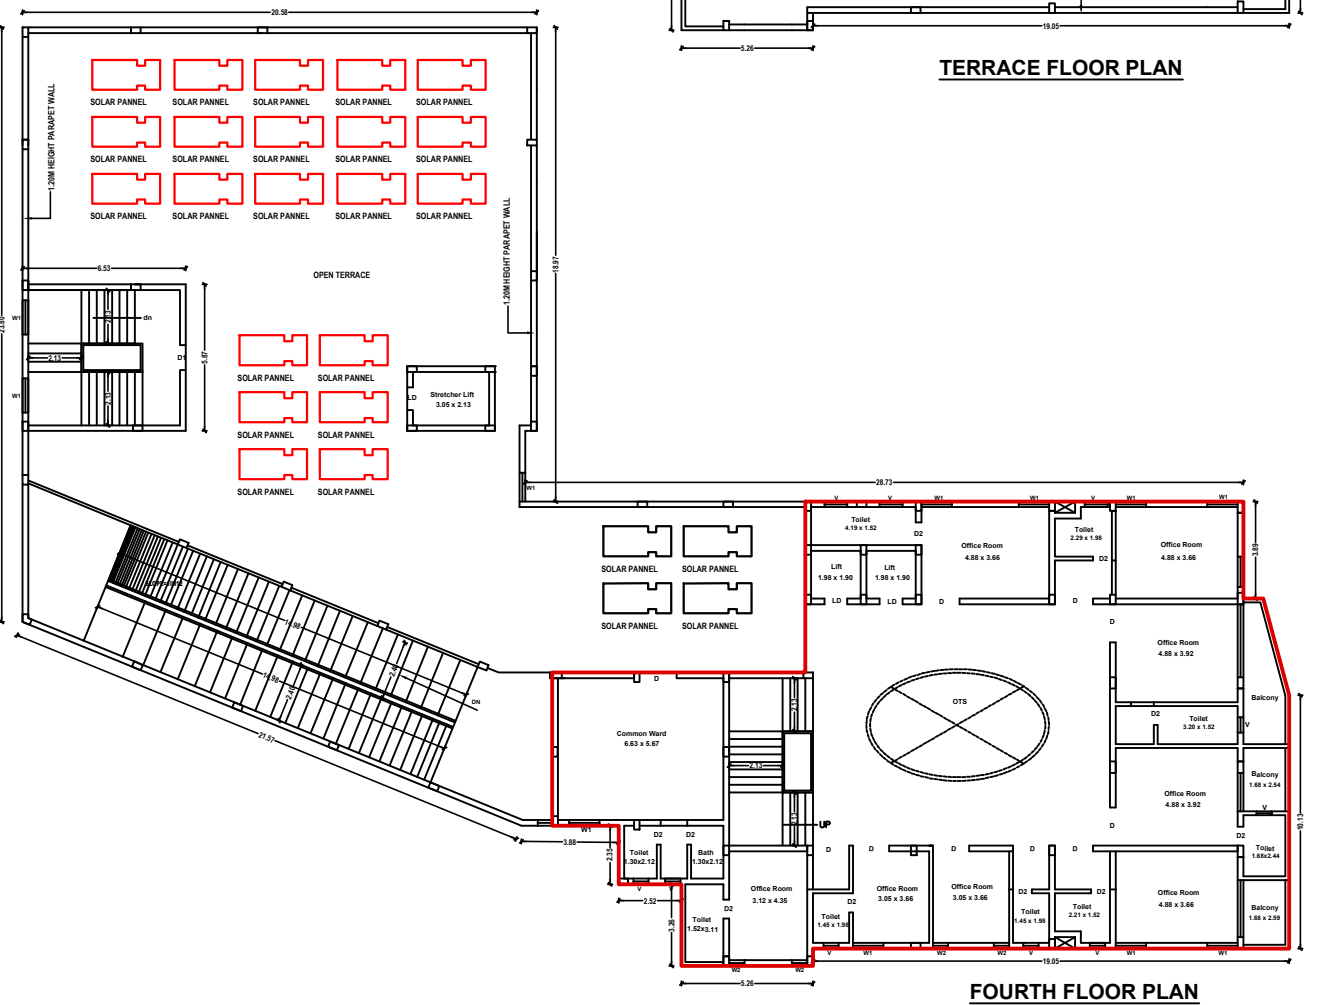
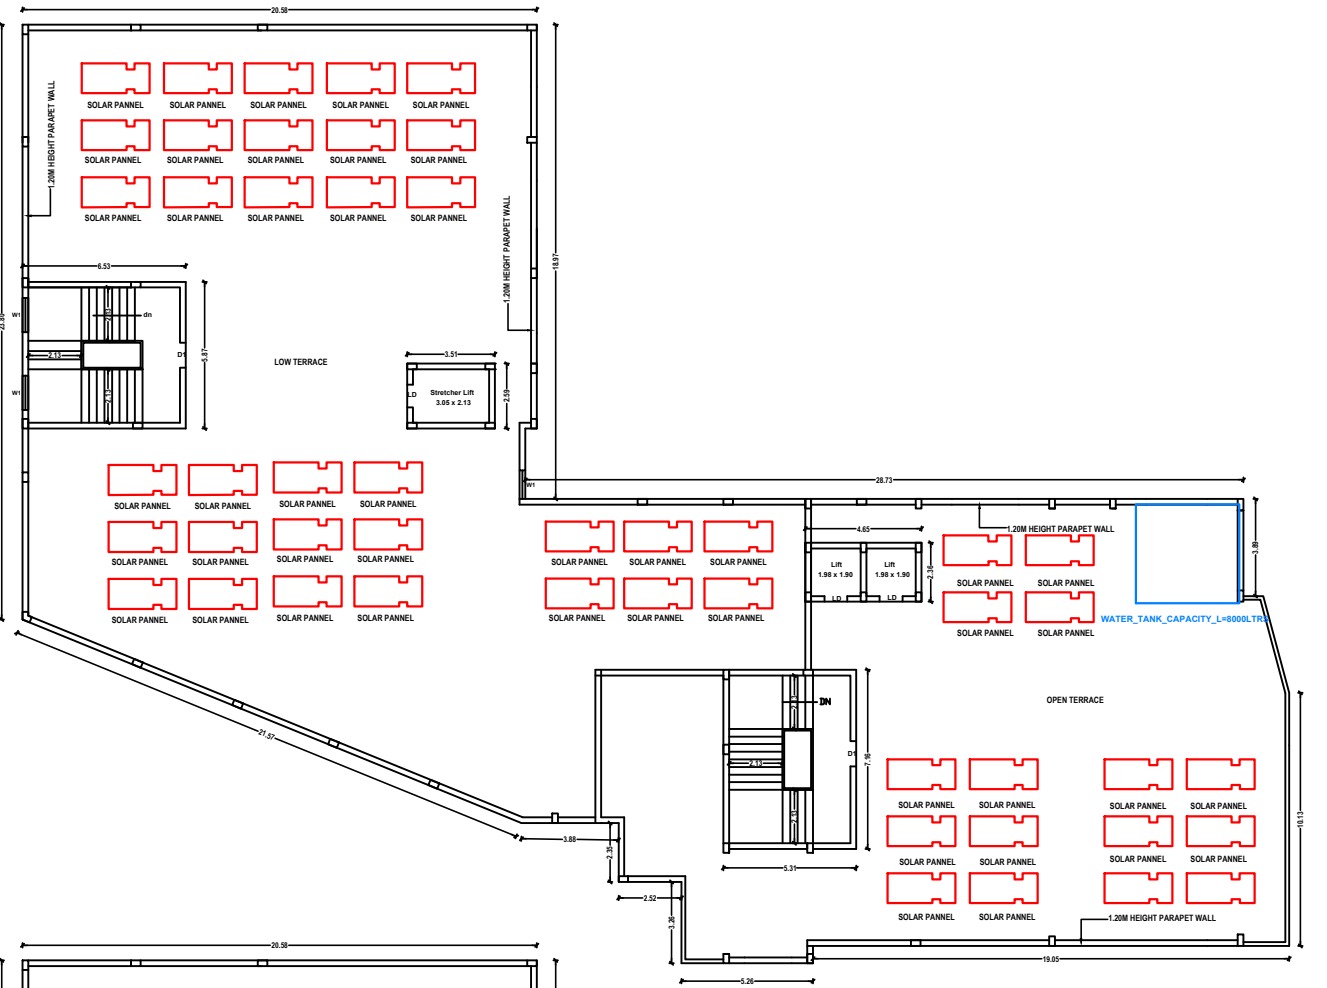
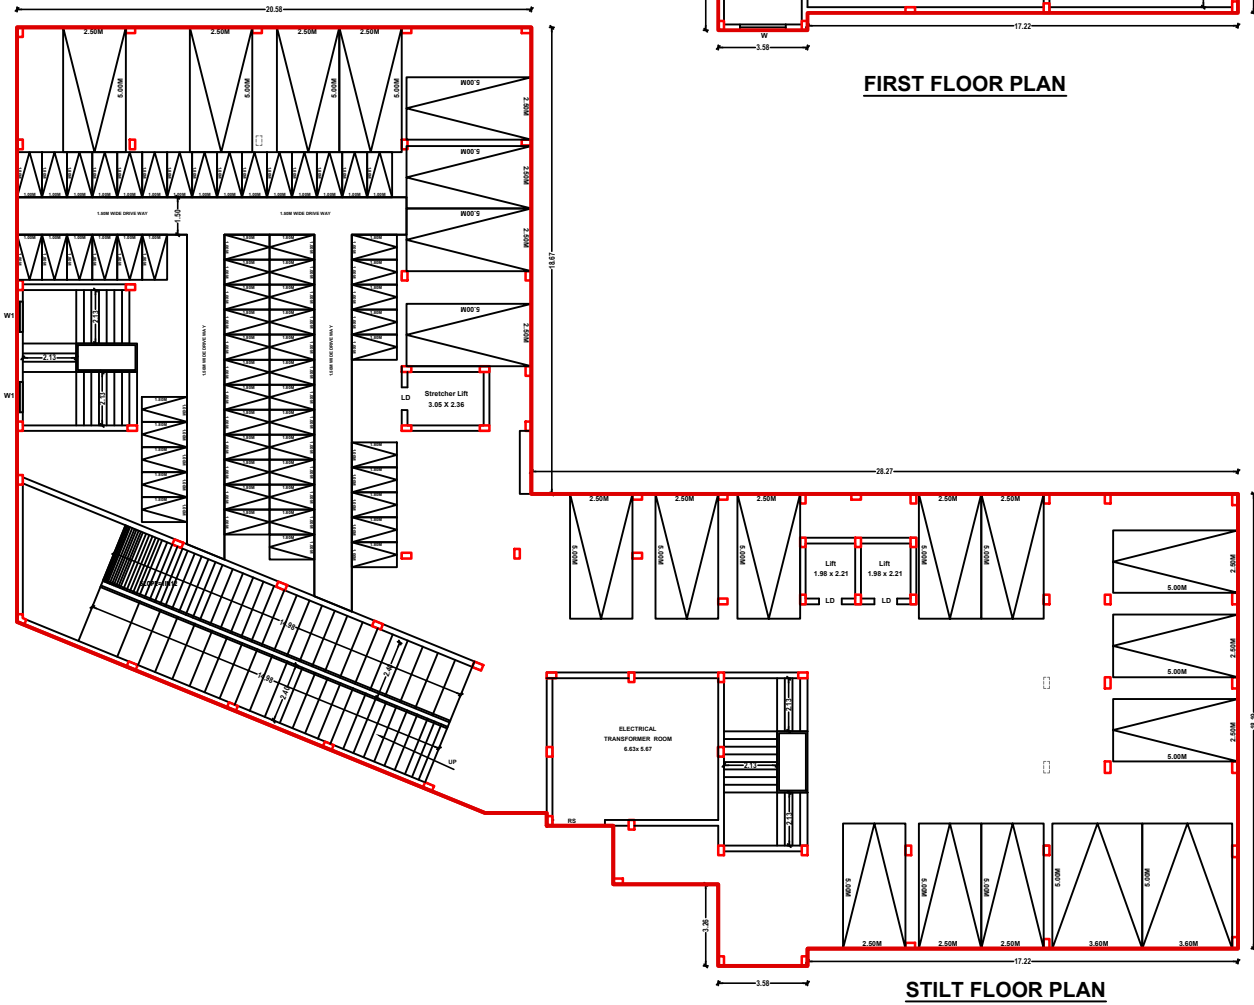
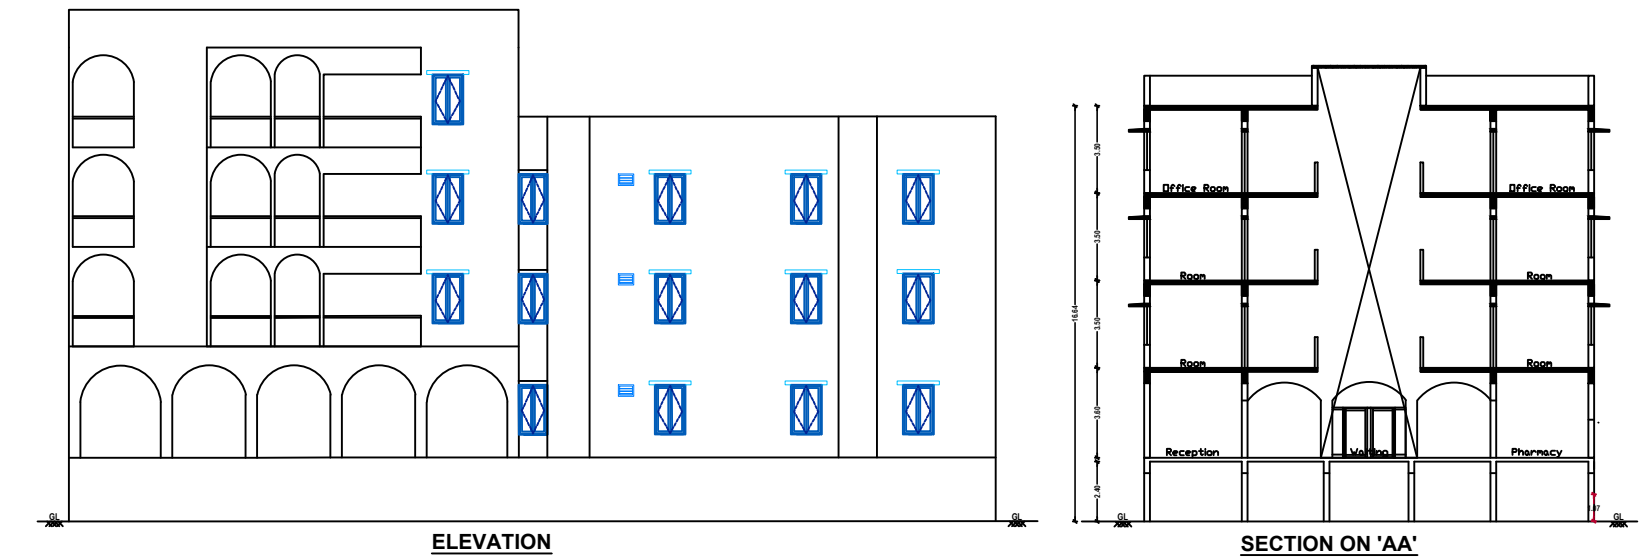

Er.V.ARIVAZHAGAN, BE.,
Registered Structural Engineer Grade-II
Reg.No.MYD/RSE-II/2024/036,
No.21/56B, Kotha Street,
Mayiladuthurai-609001.
Cell:7502568598

R. Muthu
Er. R. MUTHUKUMAR, M.E.
Registered Construction Engineer,
Reg. No. MYD/RCE/2023/018
DTCP MAYILADUTHURAI DISTRICT,
No. 10, Punuheetwarar East Street,
Mayiladuthurai-609 001,
Cell: 9994245276.

Er.A. Victor Samson Raj,M.E(Soil)
Regd.Geo Tech Engineer
Reg.No: GTE 001/2020
Techlead Consultant & Engineers
Iyer Bungalow, Madurai
Cell: 9500271927

PLAN SHOWING THE PROPOSED CONSTRUCTION OF HOSPITAL BUILDING IN S.F. NO. 361 / 1A1B, 1B, 2A, 3A AT THIRUVALAJULI VILLAGE & PANCHAYAT, KUMBAKONAM TALUK, THANJAVUR DISTRICT.

SCALE 1:100



SCHEDULE OF JOINERIES		
MD	- MAIN DOOR	- 2.21 X 2.40M
D	- DOOR	- 1.50 X 2.10M
D1	- DOOR	- 1.00 X 2.10M
D1	- DOOR	- 0.76 X 2.10M
W	- WINDOW	- 1.80 X 1.20M
W1	- WINDOW	- 1.20 X 1.20M
W2	- WINDOW	- 0.61 X 1.20M
V	- VENTILATOR	- 0.91 X 0.91M

AREA DETAILS		
	SQ. MT.	SQ. FT.
AREA OF STILT FLOOR	1062.88	1145.03
AREA OF FIRST FLOOR	1062.88	1145.03
AREA OF SECOND FLOOR	1062.88	1145.03
AREA OF THIRD FLOOR	1062.88	1145.03
AREA OF FOURTH FLOOR	433.18	47.42
AREA OF HEADROOM		49.00

- NOTES:
1. ALL DIMENSIONS ARE IN METRE
 2. RAINWATER COLLECTION WELLS WILL BE PROVIDED
 3. FIRE FIGHTING ARRANGEMENTS WILL BE PROVIDED
 4. EMERGENCY ALARMING WILL BE PROVIDED
 5. DRINKING WATER WILL BE PROVIDED
 6. GROUND WATER BUMPERS WILL BE PROVIDED
 7. FILTERED RAIN WATER BUMPERS WILL BE PROVIDED
 8. EXHAUST FAN PROVISION IS MADE AT TOILET & WASH
 9. SOLAR WATER HEATING SYSTEM PROVIDED.
 10. RAINWATER HARVESTING FACILITIES PROVIDED.
 11. WASTE WATER RECYCLING TRENCH AND TANK PROVIDED.
 12. SEWAGE TREATMENT PLANT PROVIDED.
 13. SEPTIC TANK PROVIDED.
 14. WATER FACILITIES PROVIDED.
 15. TRANSFORMER YARD PROVIDED.
 16. FA - FIRE ALARM PROVIDED
 17. F.E - FIRE SAFETY MEASURES PROVIDED.
 18. SB - SAND BUCKET PROVIDED

APPLICANT
Dr.K.Sivakumar & Dr.S.Lakshmi

Dr. S. SELVA SUGUMARAN, M.E.,
Registered Engineer Grade-II
Reg. No. MYD/RCE/2023/012
DTCP - NAGAPATTINAM,
No. 2, Kumbakonam, Thanjavur, Tamil Nadu,
Mayiladuthurai-605 001,
Cell: 9600750052.

Dr. V. Arinjan
Dr. V. ARIVAZHAGAN, BE,
Registered Structural Engineer Grade-II
Reg. No. MYD/RSE-II/2024/036,
No.21/56B, Kotha Street,
Mayiladuthurai-609001,
Cell: 7502568598

Dr. R. Muthukumar
Dr. R. MUTHUKUMAR, M.E.,
Registered Construction Engineer,
Reg. No. MYD/RCE/2023/018,
DTCP MAYILADUTHURAI DISTRICT,
No. 10, Puniheswarar East Street,
Mayiladuthurai-609 001,
Cell: 9994245276.

Dr. A. Victor Samson Raj, M.E.(S)
Dr. A. Victor Samson Raj, M.E.(S),
Regd. Geo Tech Engineer
Reg. No. GTE 001/2020
Technical Consultant & Engineers
Iyer Bungalow, Madurai
Cell: 9500271927

ENGINEER

Signature Not
Verified
Signed by Village Panchayat
President
Location: Thanjavur
Date: 2024.10.19 09:48:10