


PLAN SHOWING THE PROPOSED CONSTRUCTION OF R.C.C. ROOF RESIDENTIAL BUILDING IN GROUND AND FIRST FLOOR IN PATTa NO:- 232, OLD SURVEY NO:- 405/ 5B, NEW SURVEY NO:- 405/ 5B1, PLOT NO:- 4Pt AT WEST MANTHAI PULAM, MELACHOKKANATHAPURAM TOWN PANCHAYT, BODINAYAKANUR TALUK, THENI DISTRICT.


APPLICANT:- Mr:-S.VIGNESHRAJ., S/o Mr:- SELVARAJ..

SCALE 1:100

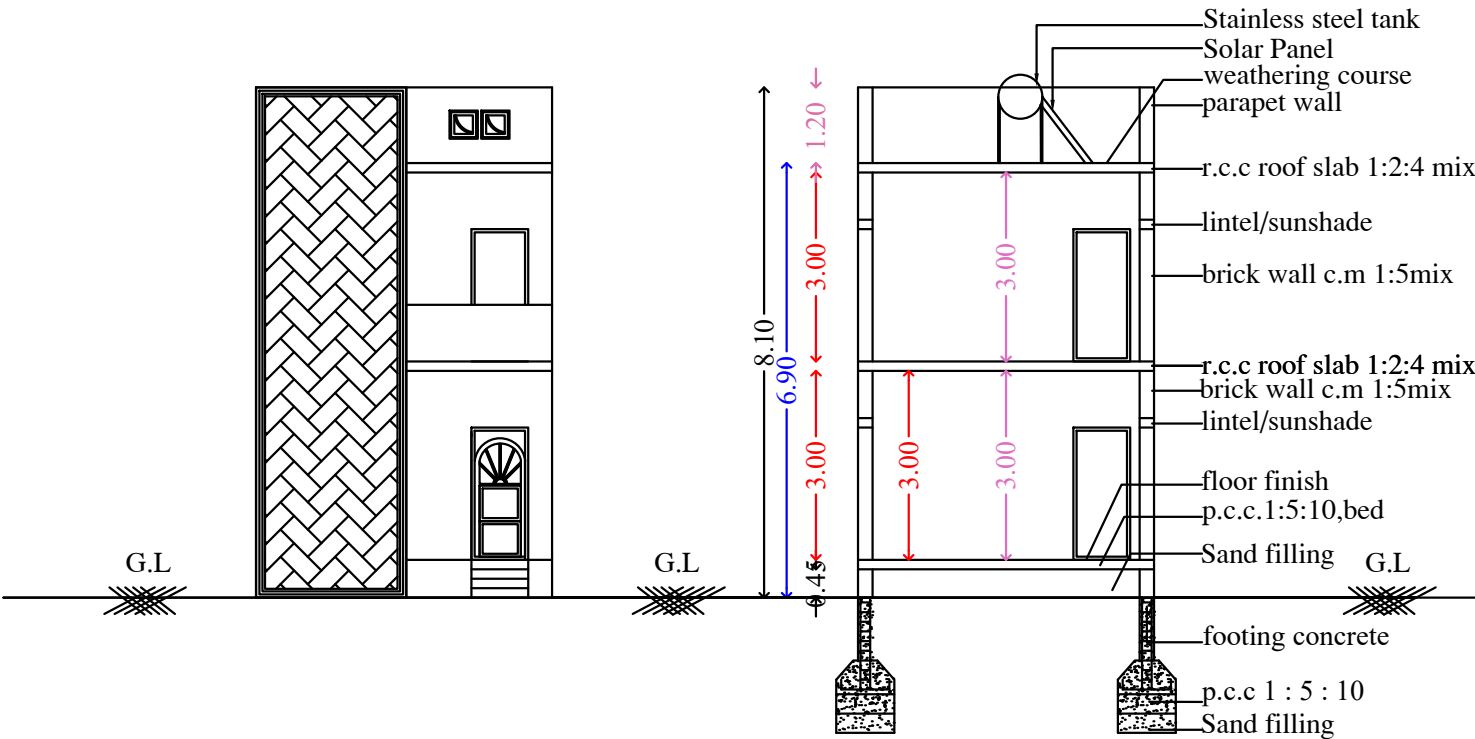


FRONT ELEVATION


SECTION ON A-A

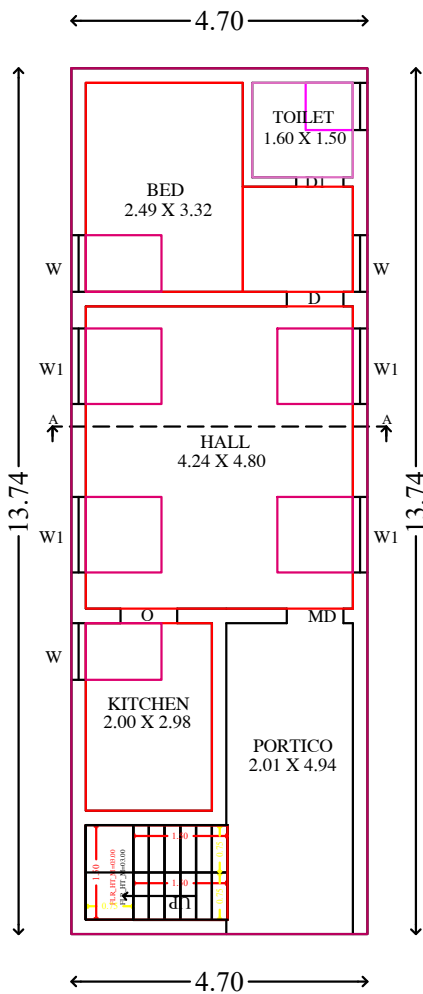

GROUND FLOOR PLAN
(East Facing)

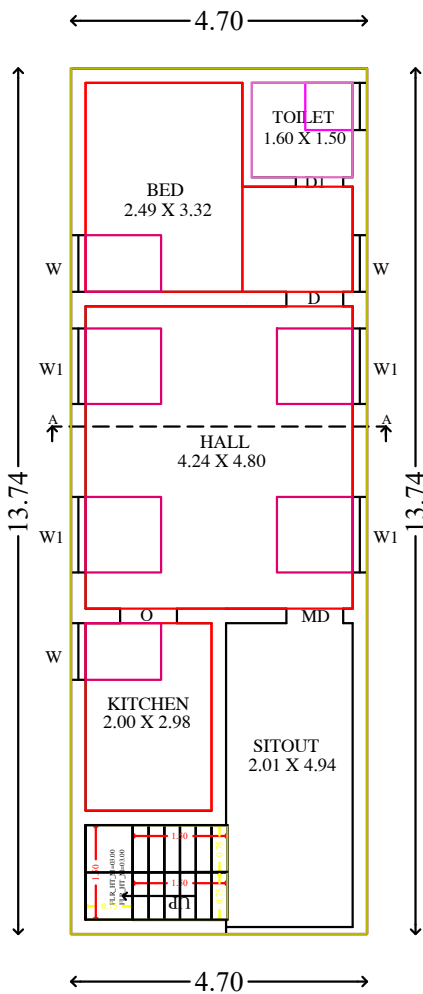


FIRST FLOOR PLAN
(East Facing)

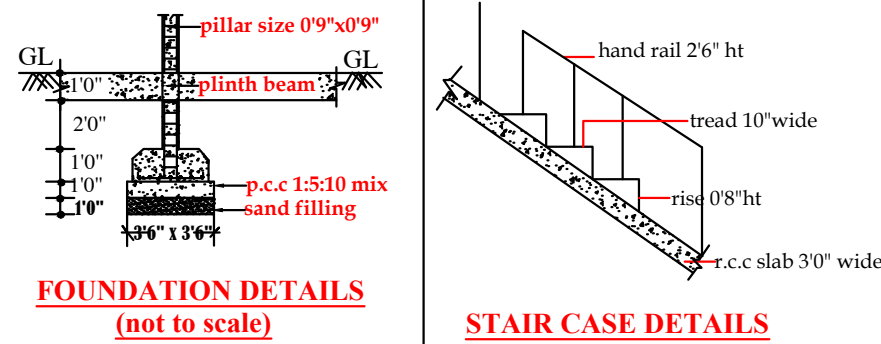

FOUNDATION DETAILS
(not to scale)



STAIR CASE DETAILS

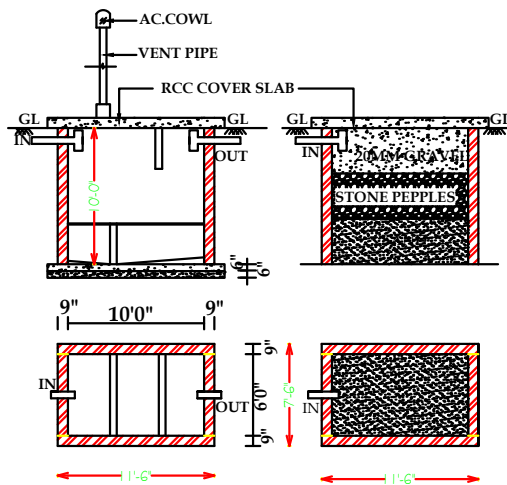

SEPTIC TANK

SOAK PIT

RAIN WATER STORAGE TANK
(not to scale)

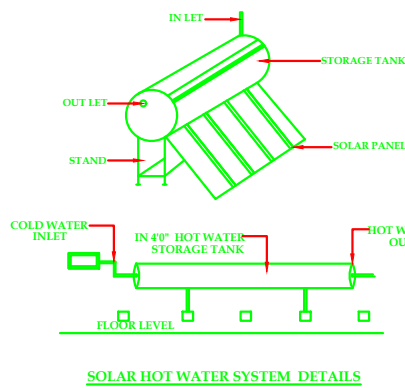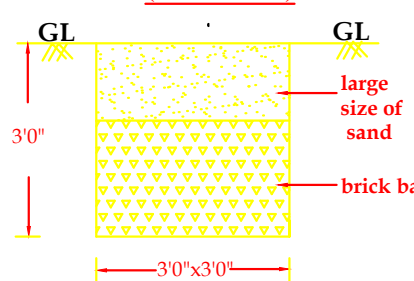

SOLAR HOT WATER SYSTEM DETAILS


AREA DETAILS	SQ.FT	SQ.M
AREA OF THE SITE	1042.75	96.87
AREA OF PROPOSED IN G.F	695.24	64.59
AREA OF PROPOSED IN F.F	695.24	64.59
AREA OF OPEN SPACE	347.51	32.28

COLOUR SCHEDULE	REFERENCE	FEET	METER
☐ PROPOSED	D-Door	3'3" x 7'0"	1.00 x 2.10
☐ BOUNDARY	D1-Door	2'6" x 7'0"	0.76 x 2.10
☐ EXISTING	W-Window	4'0" x 4'0"	1.22 x 1.22
☐ ROAD	V- Ventilator	4'0" x 2'0"	1.22 x 0.61
	Gate	4'0" x 7'0"	1.22 x 2.10

- 1.Rain water storage tank is provided.
- 2.Solor water heater system is provided.
- 3.One no of stair case is provided.
- 4.Bore well and motor fittings are provided.
- 5.Rain water to be connected with R.W.H tank.
- 6.Two no of toilet is provided.
- 7.One no of septic tank provided.

SRI SIGARAM CONSTRUCTIONS
Er.S.MANIVANNAN.,DCE.,LBS.,AutoCAD
Registered engineer/ Consulting Engineer
95/9w Maduraiveeran street
Bodinayakanur-625513.
cell:- 8248750171, 8148742757

SITE PLAN
SCALE :- 1:200

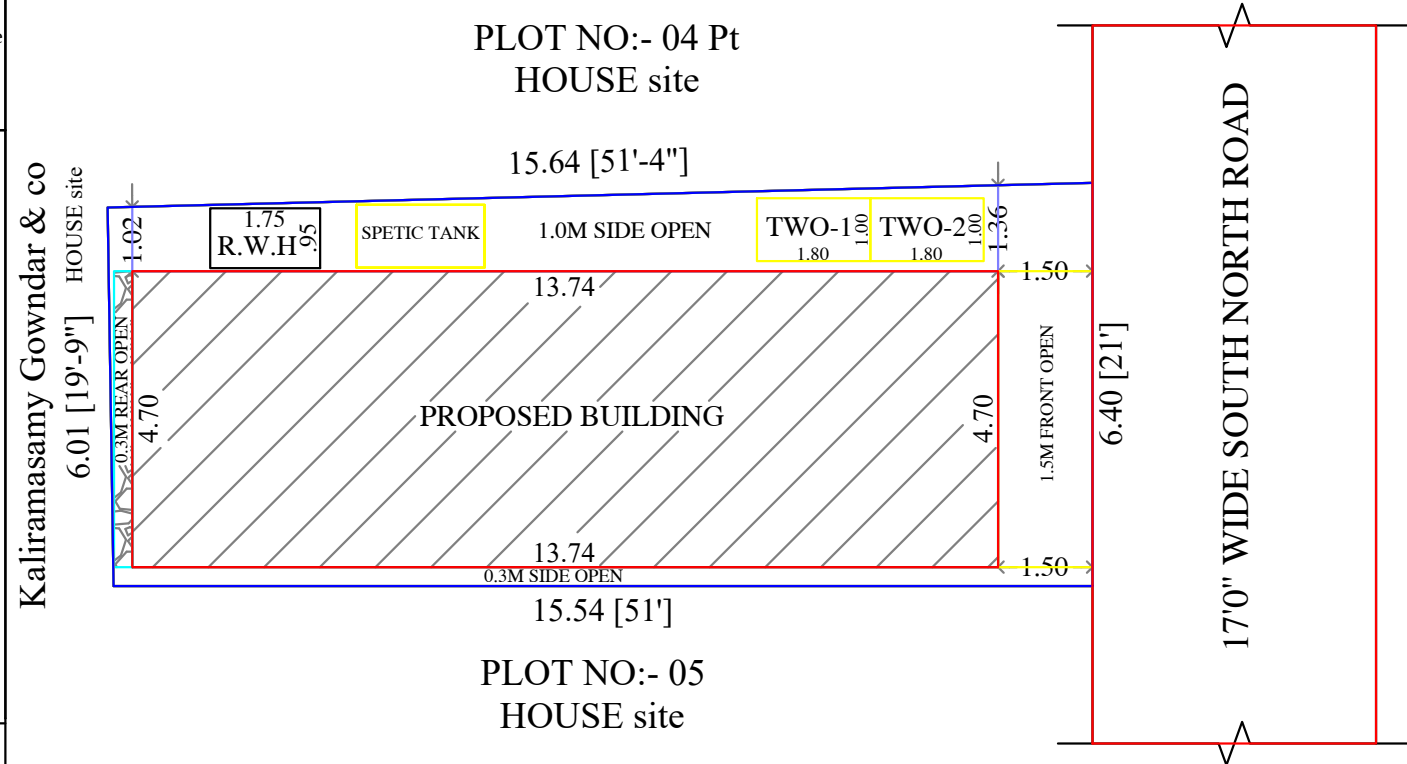

APPLICANT

ENGINEER

FOR OFFICE USE