




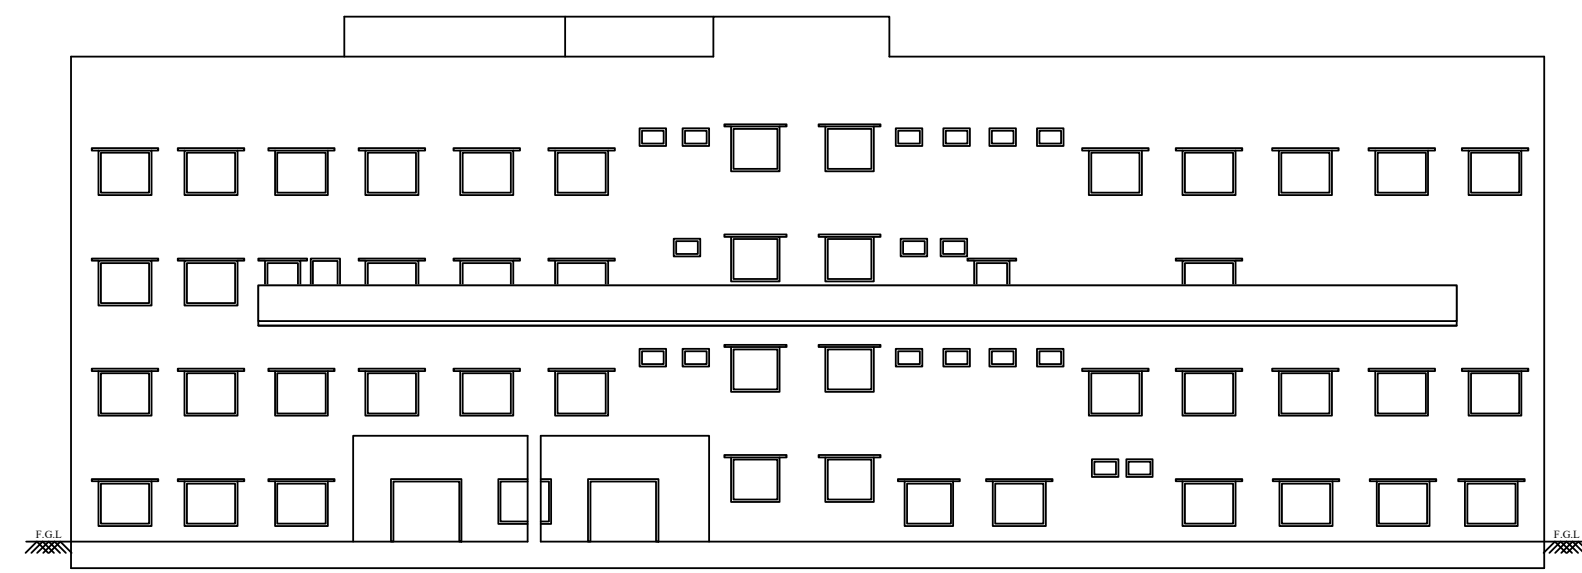


ELEVATION

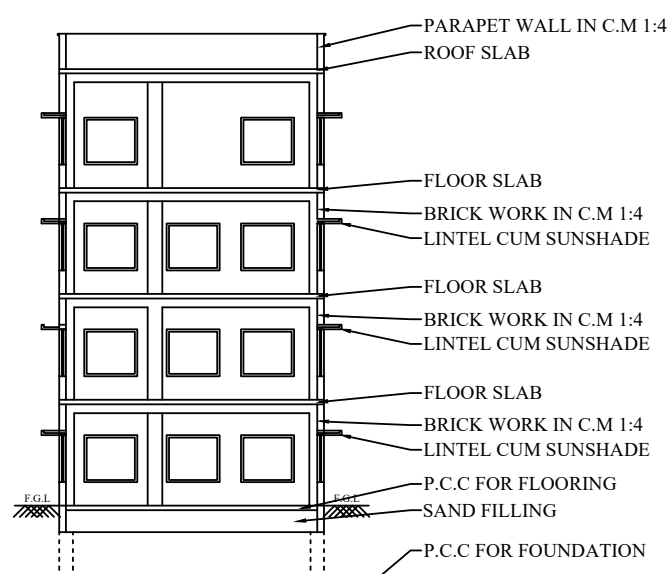


SECTION AA

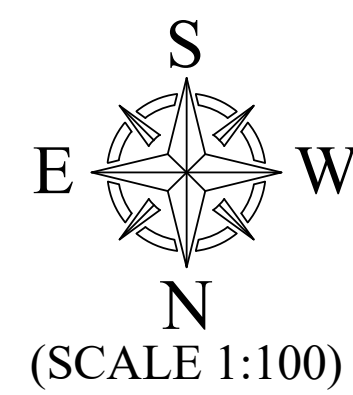


(SCALE 1:100)

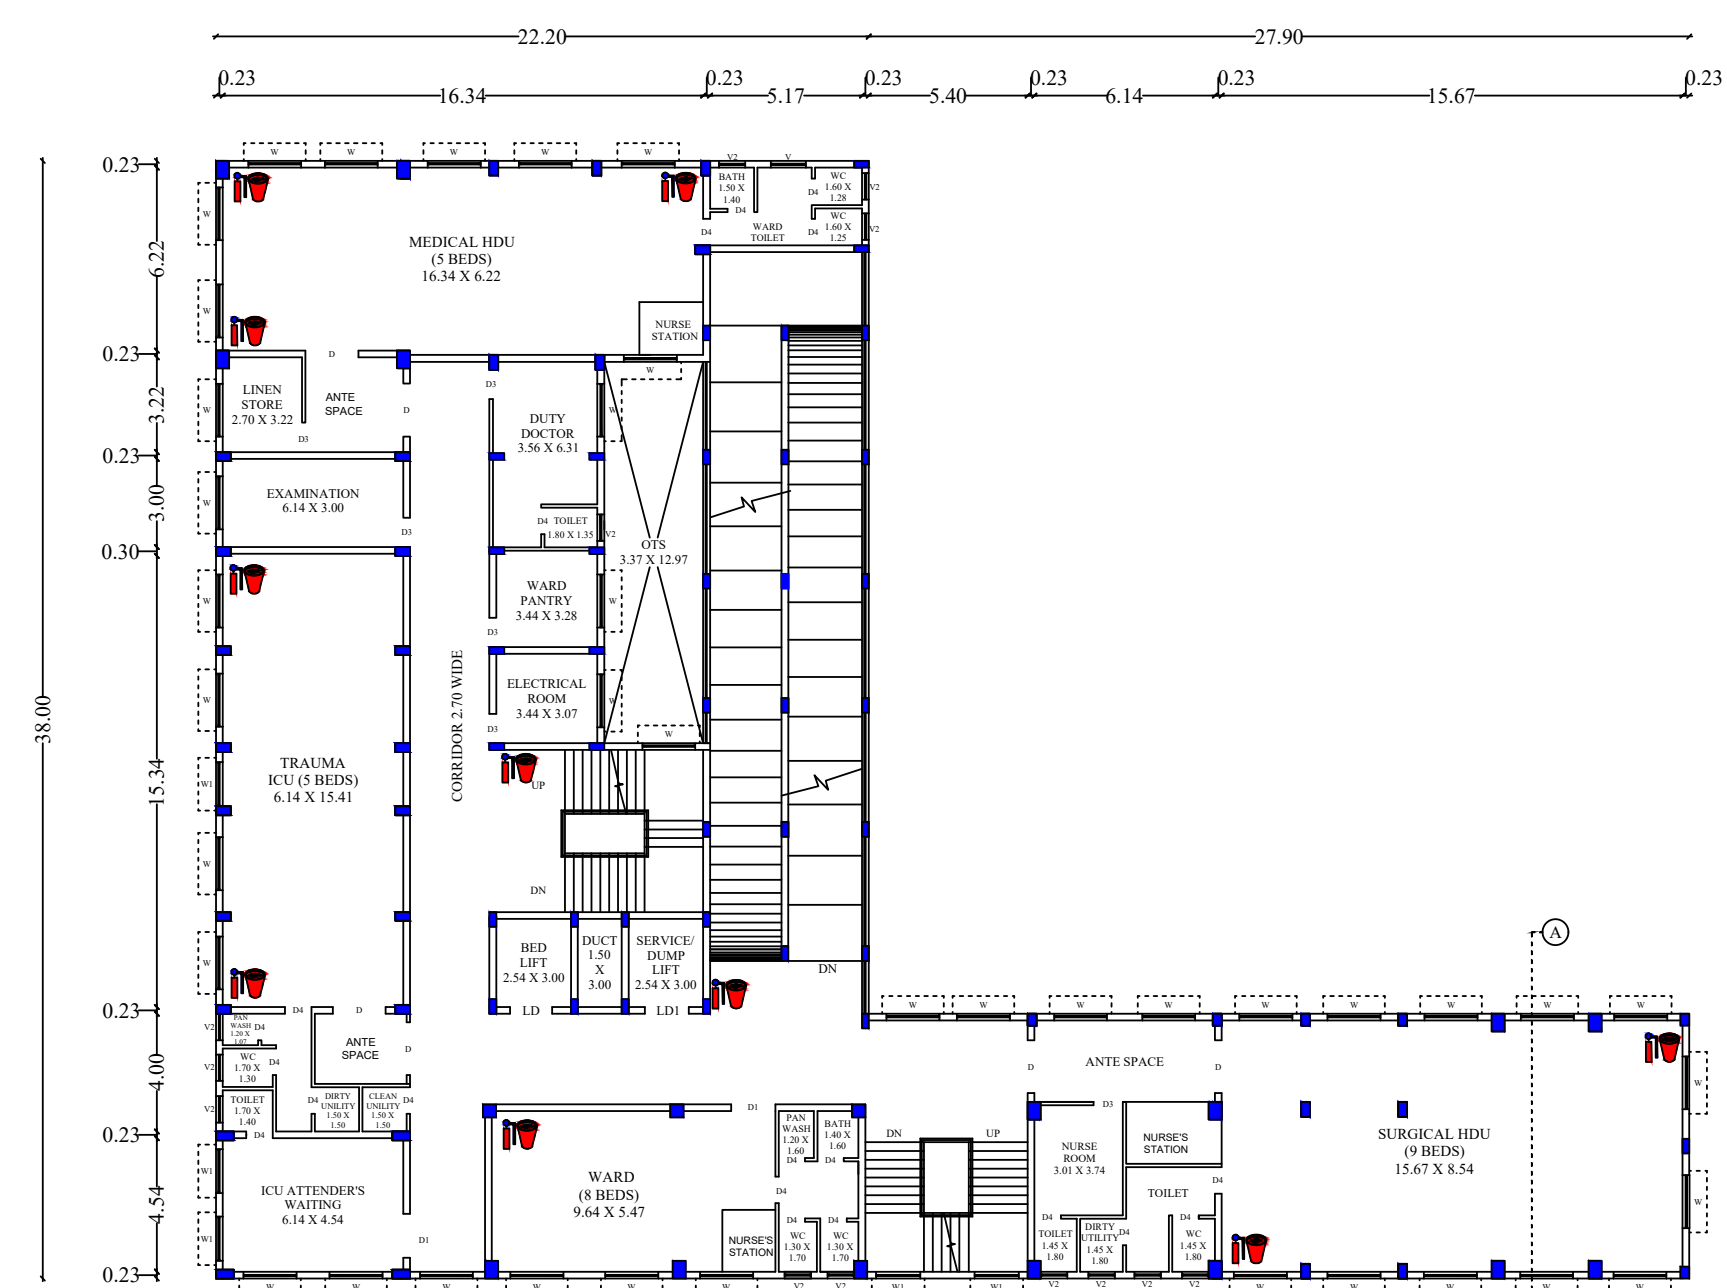


THIRD FLOOR

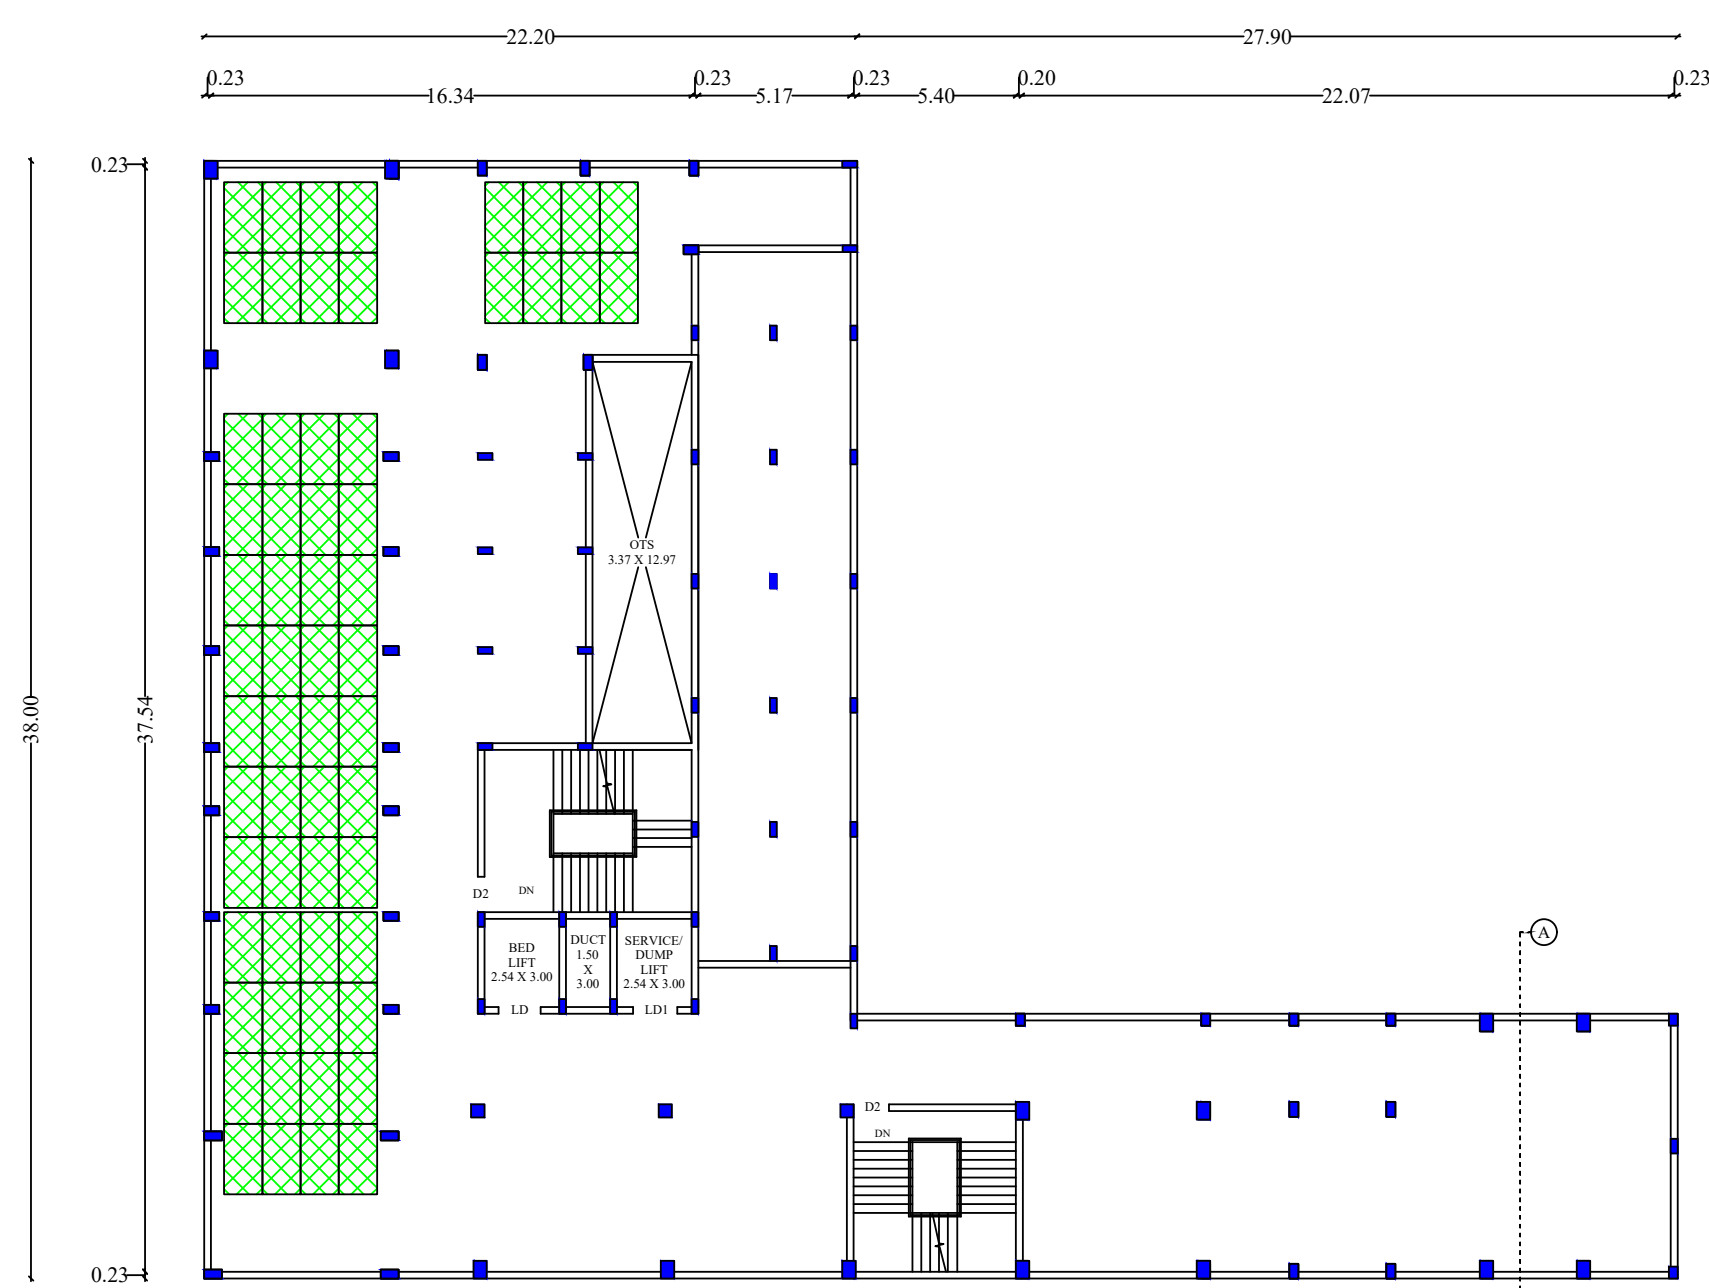


TERRACE FLOOR

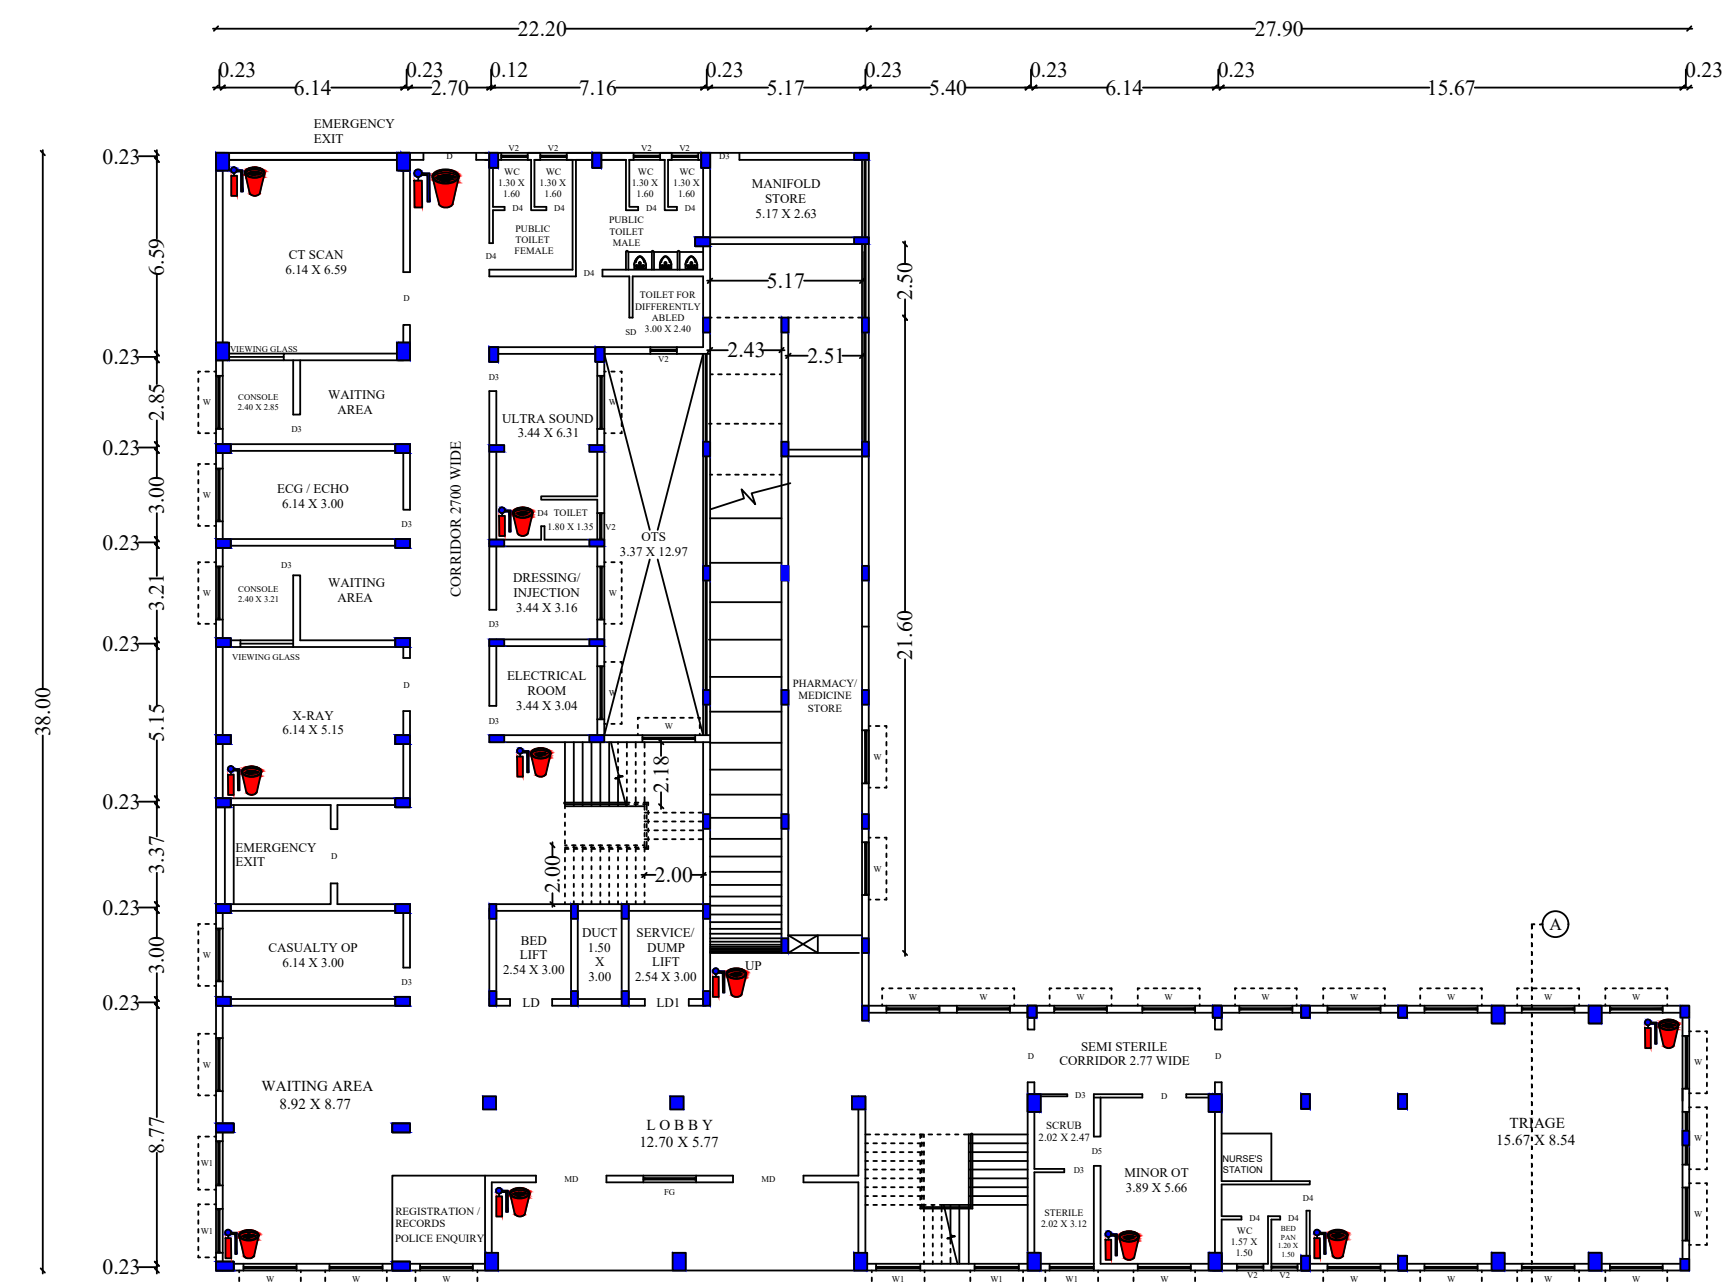


GROUND FLOOR

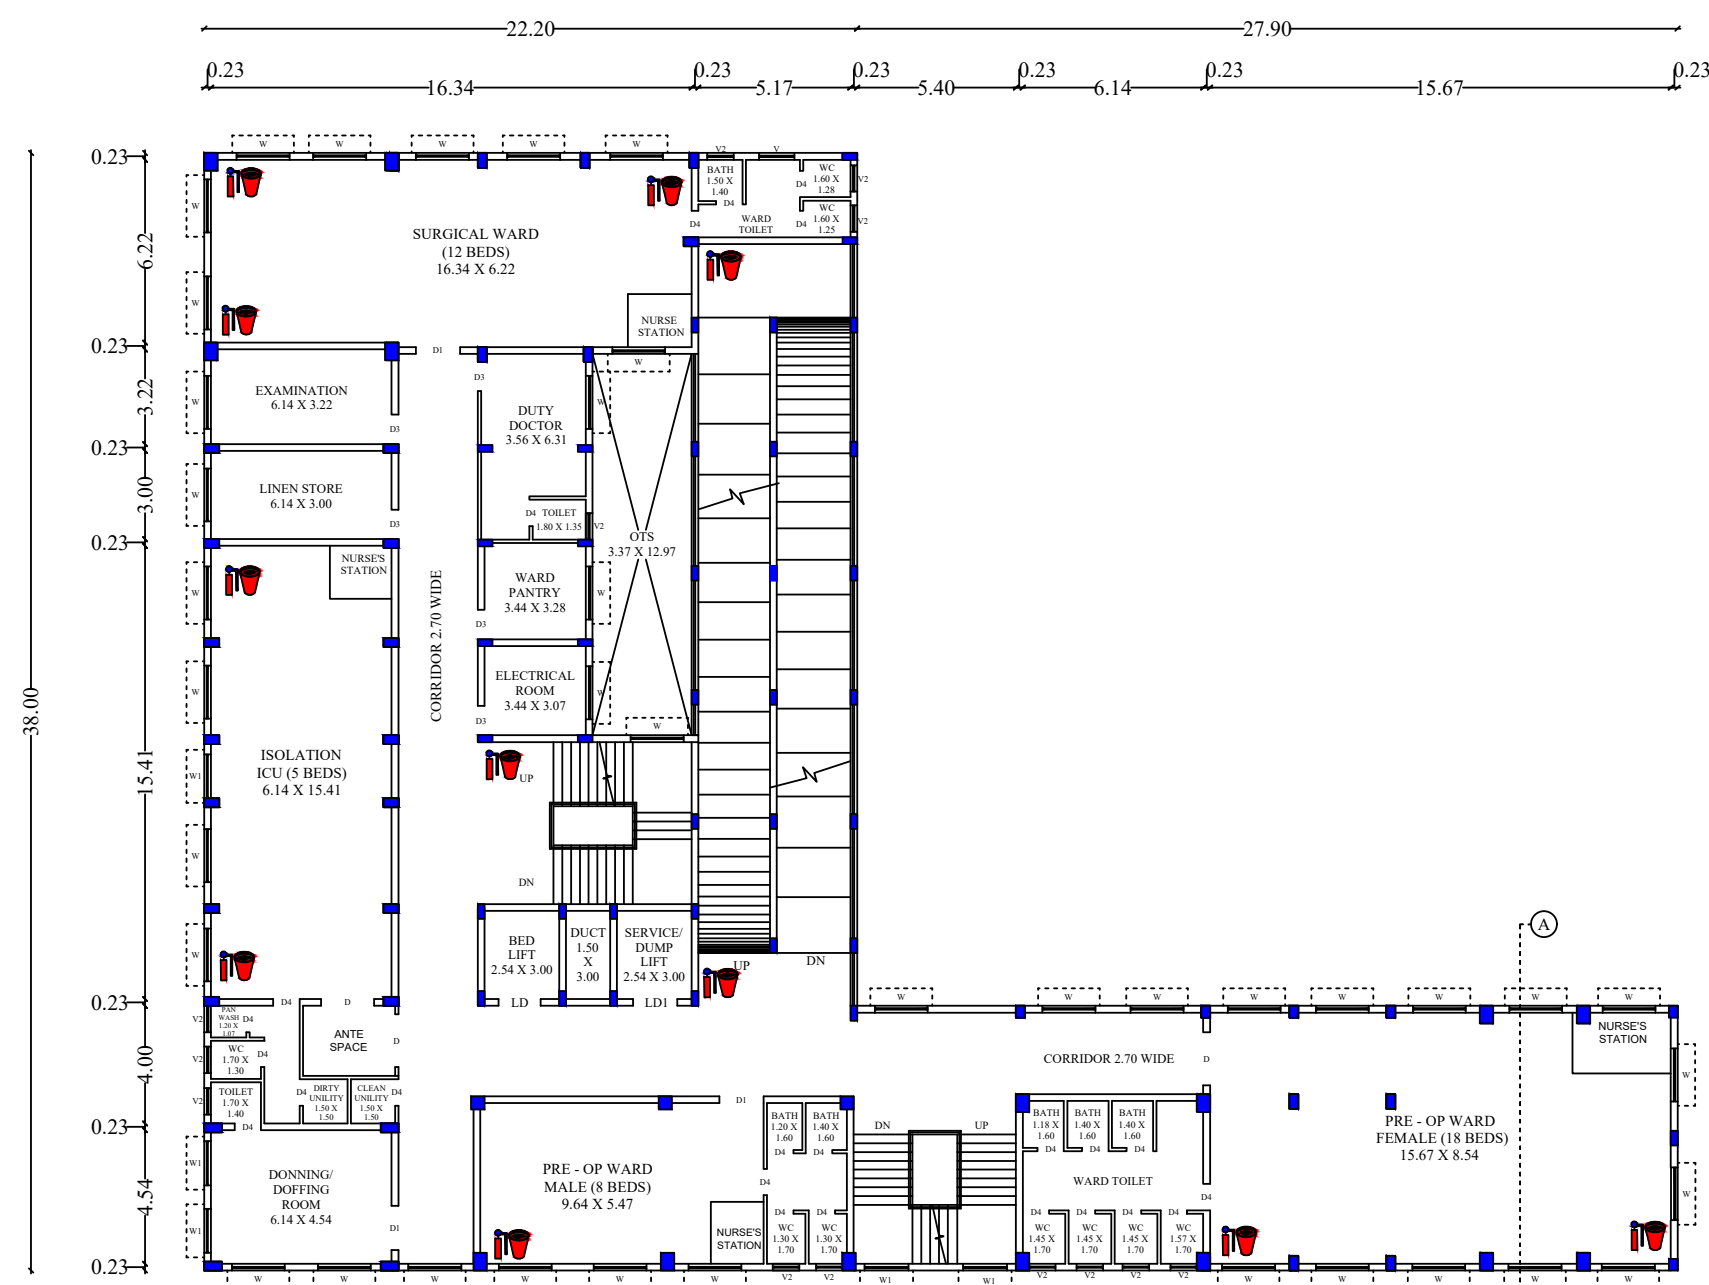

FIRST FLOOR

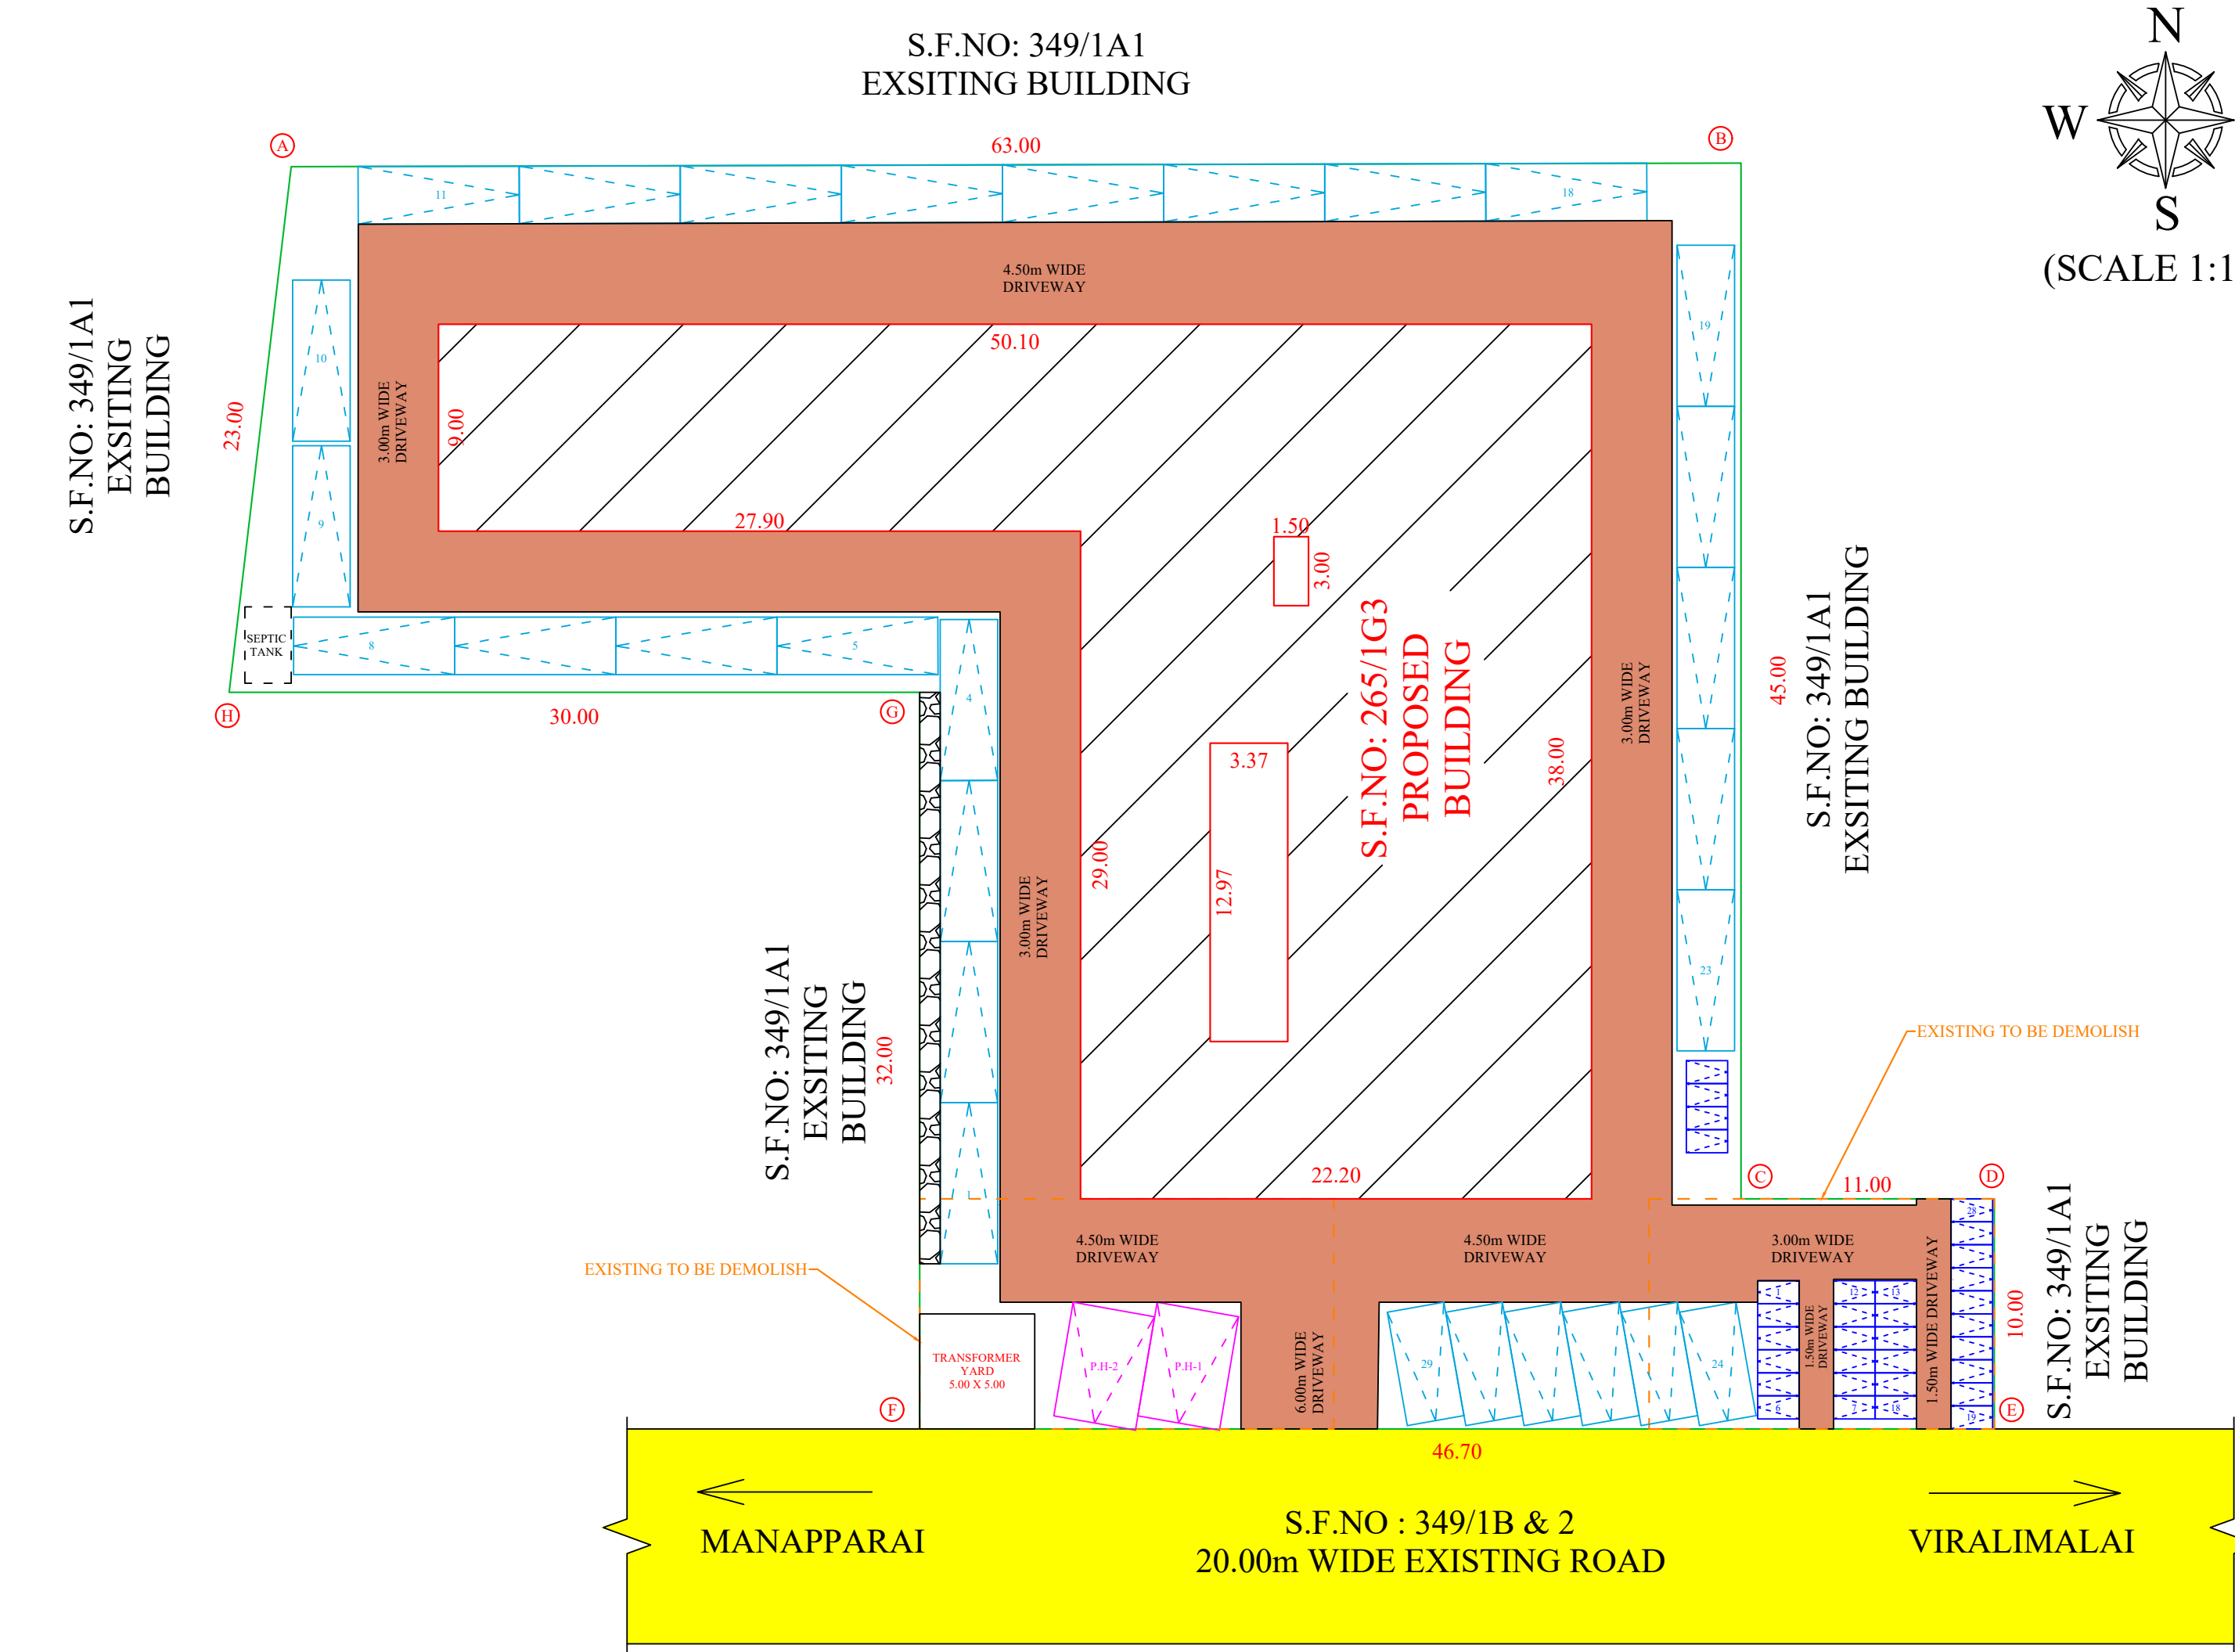

SITE PLAN

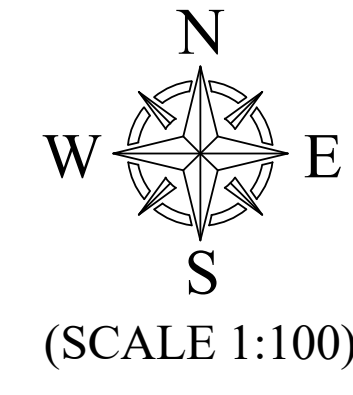

(SCALE 1:100)

PLAN SHOWING PROPOSED CONSTRUCTION OF (G+3) R.C.C ROOF HOSPITAL BUILDING IN S.F.NO 349/1A2 AT KANNUDAIYANPATTY VILLAGE, MANAPPARAI PANCHAYAT UNION, MANAPPARAI TALUK AND TIRUCHIRAPPALLI DISTRICT.

AREA DETAILS	IN Sq.M
S.F.NO 349/1A2 (AS PER DOCUMENT)	2733.00
S.F.NO 349/1A2 (PATTI)	2733.00

DETAIL OF PROPOSED HOSPITAL BUILDING			
PROPOSED FLOOR DETAILS	F.S.I in sq.m	NON-F.S.I in sq.m	TOTAL AREA
PROPOSED GROUND FLOOR	1046.49	-	1046.49
PROPOSED FIRST FLOOR	1046.49	-	1046.49
PROPOSED SECOND FLOOR	1046.49	-	1046.49
PROPOSED THIRD FLOOR	1046.49	-	1046.49
PROPOSED HEAD ROOM	-	104.43	104.43
TOTAL FLOOR AREA	4185.96	104.43	4290.39
TOTAL BUILT-UP AREA	-	4290.39	-
F.S.I	-	4185.96/2733.00 = 1.55-2.0	-
PLOT COVERAGE	-	(1046.49/2733.00) X 100 = 38.29%	-

NOTATION	JOURNEY DETAILS	SIZE IN M
M.D	MAIN DOOR	2.40 X 2.40
D	DOOR	1.80 X 2.40
D1	DOOR	1.50 X 2.40
D2	DOOR	1.20 X 2.40
D3	DOOR	1.00 X 2.40
D4	DOOR	0.90 X 2.40
SD	DOOR	0.90 X 2.40
LD	LIFT DOOR	1.43 X 2.40
LD1	LIFT DOOR	1.50 X 2.40
W	WINDOW	1.80 X 1.60
W1	WINDOW	1.50 X 1.60
W2	WINDOW	1.20 X 1.60
FG	WINDOW	1.80 X 1.60
V	VENTILATOR	1.20 X 0.60
V2	VENTILATOR	0.90 X 0.60

SITE DETAILS :	
PROPOSED SITE (A to H)	
PROPOSED BUILDING	
EXISTING ROAD	
DRIVEWAY	
RAIN WATER HARVESTING TRENCH	
EXISTING TO BE DEMOLISH	

- NOTES:-
1. ALL DIMENSIONS ARE IN METER.
 2. FIRE FIGHTING ARRANGEMENTS WILL BE PROVIDED.
 3. SOLAR WATER HEATING SYSTEM PROVIDED.
 4. RAINWATER HARVESTING FACILITIES PROVIDED.
 5. WATER FACILITIES PROVIDED.
 6. DRAINAGE TO BE CONNECTED WITH PUBLIC SEWER WITH NECESSARY PERMISSION.
 7. F E - FIRE SAFETY MEASURES PROVIDED.
 8. CENTRALIZED AC TO BE PROVIDED AT REQUIRED PLACE

PARKING DETAILS	STALL SIZE (m)	REQUIRED	PROVIDED
TWO WHEELER PARKING (per 100sq.m)	1.00 X 1.80	31	31
CAR PARKING (per 100sq.m)	2.70 X 7.20	31	31
P.H - CAR PARKING	3.60 X 5.00	3	3

APPLICANT:-

P. J. Sathish
HOSPITAL SUPERINTENDENT
GOVT. DIST. HEAD QUARTERS HOS.
MANAPPARAI, TRICHY DIST. - 6213


REGISTERED ENGINEER

G. S. Sathish
EXECUTIVE ENGINEER, P.W.D.
BUILDINGS (C&M) DIVISION,
TIRUCHIRAPPALLI - 17.


REGISTERED STRUCTURAL ENGINEER

A. Sathish
Assistant Executive Engineer, P.W.D.
Building (C&M) Sub Division
Manapparai.


NOT TO SCALE

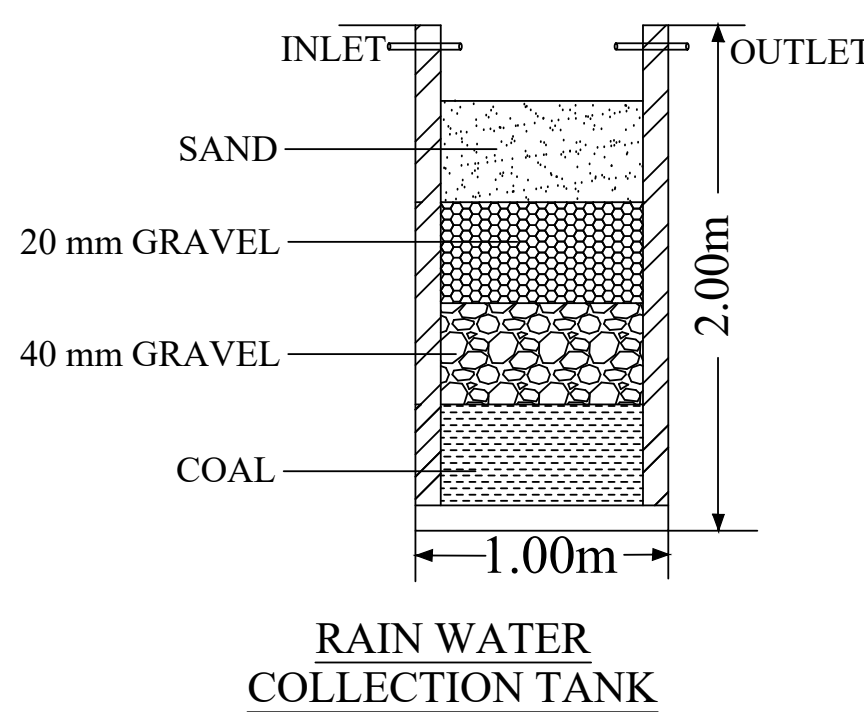


RAIN WATER COLLECTION TANK

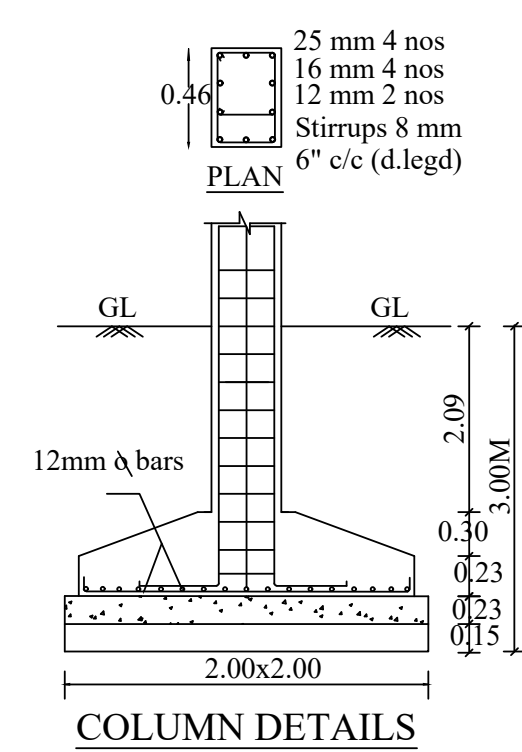


COLUMN DETAILS

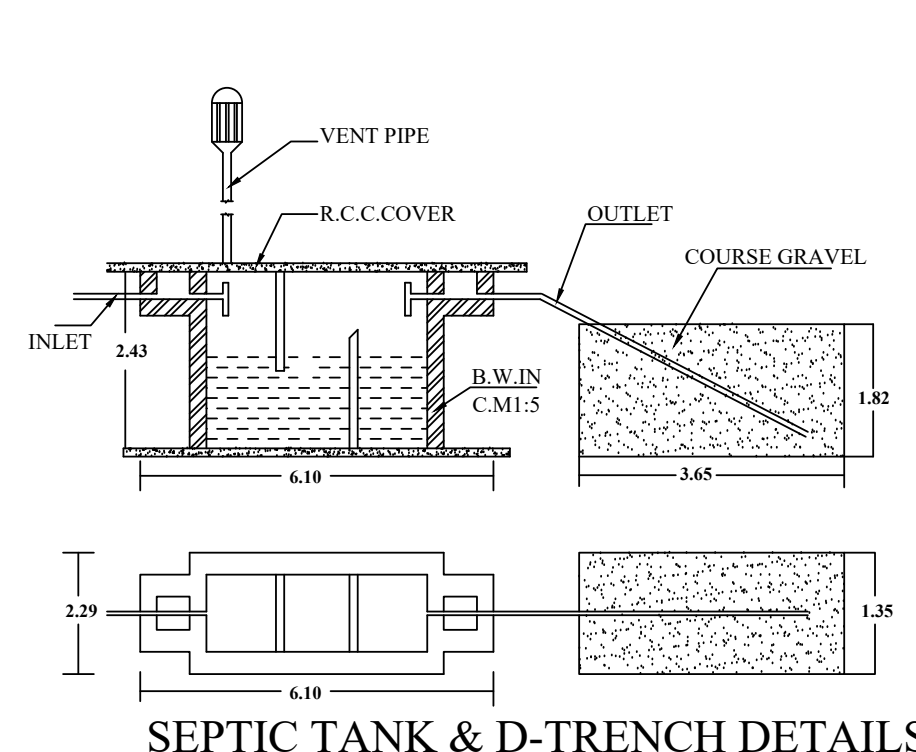


SEPTIC TANK & D-TRENCH DETAILS

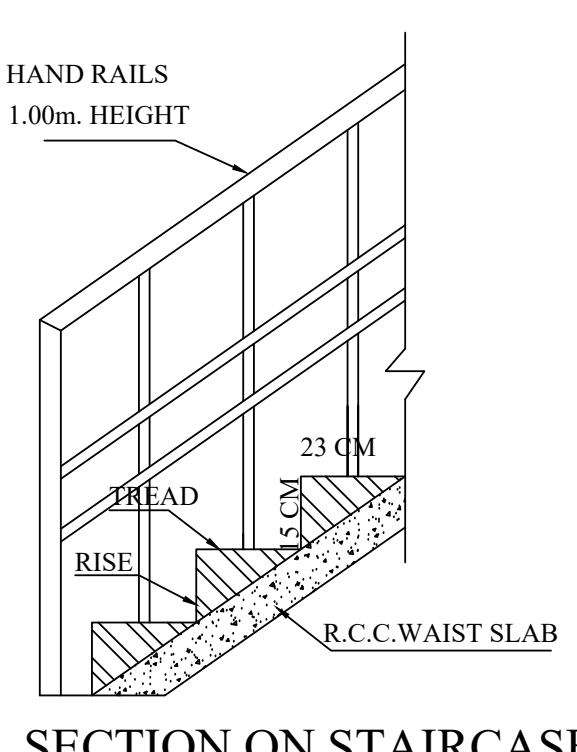


SECTION ON STAIRCASE

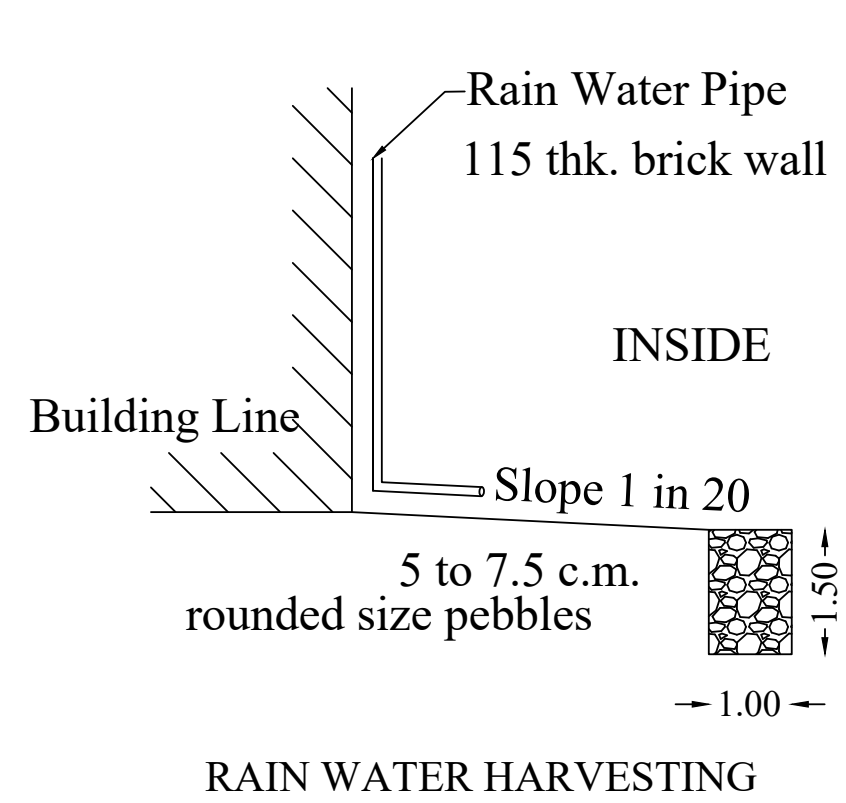

RAIN WATER HARVESTING

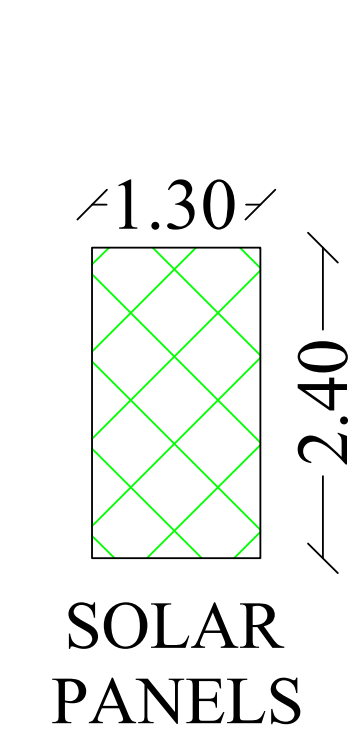

SOLAR PANELS

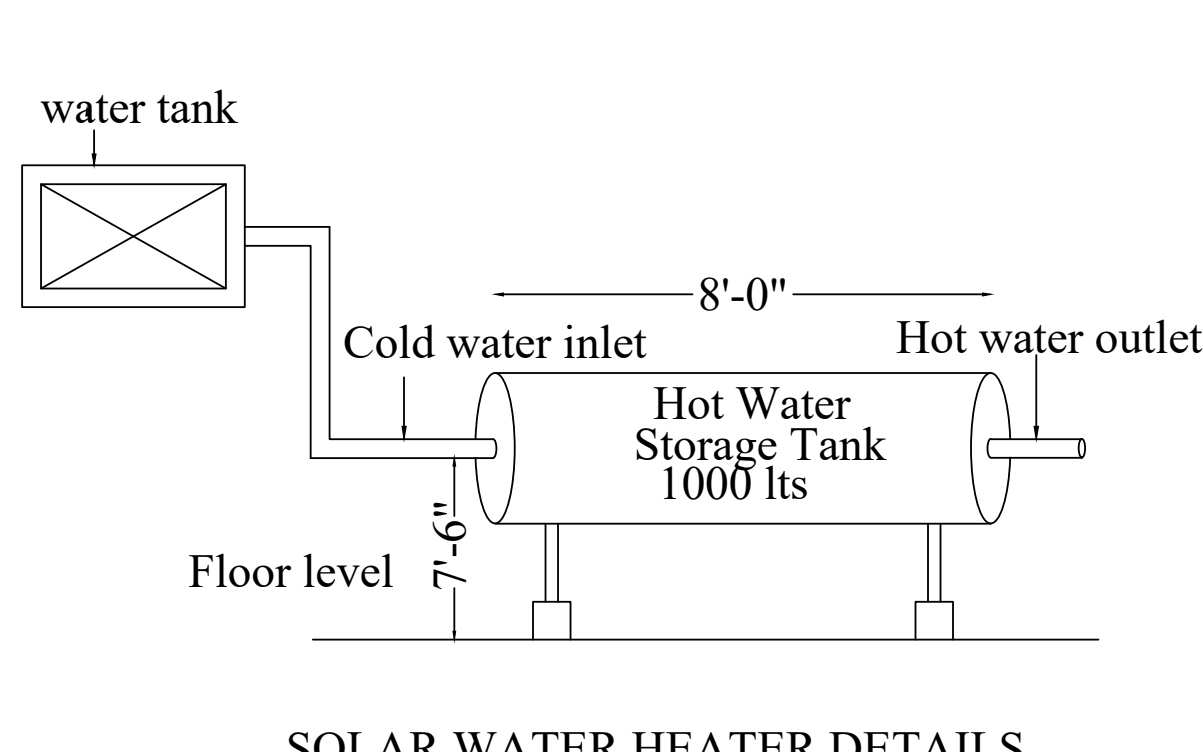

SOLAR WATER HEATER DETAILS