




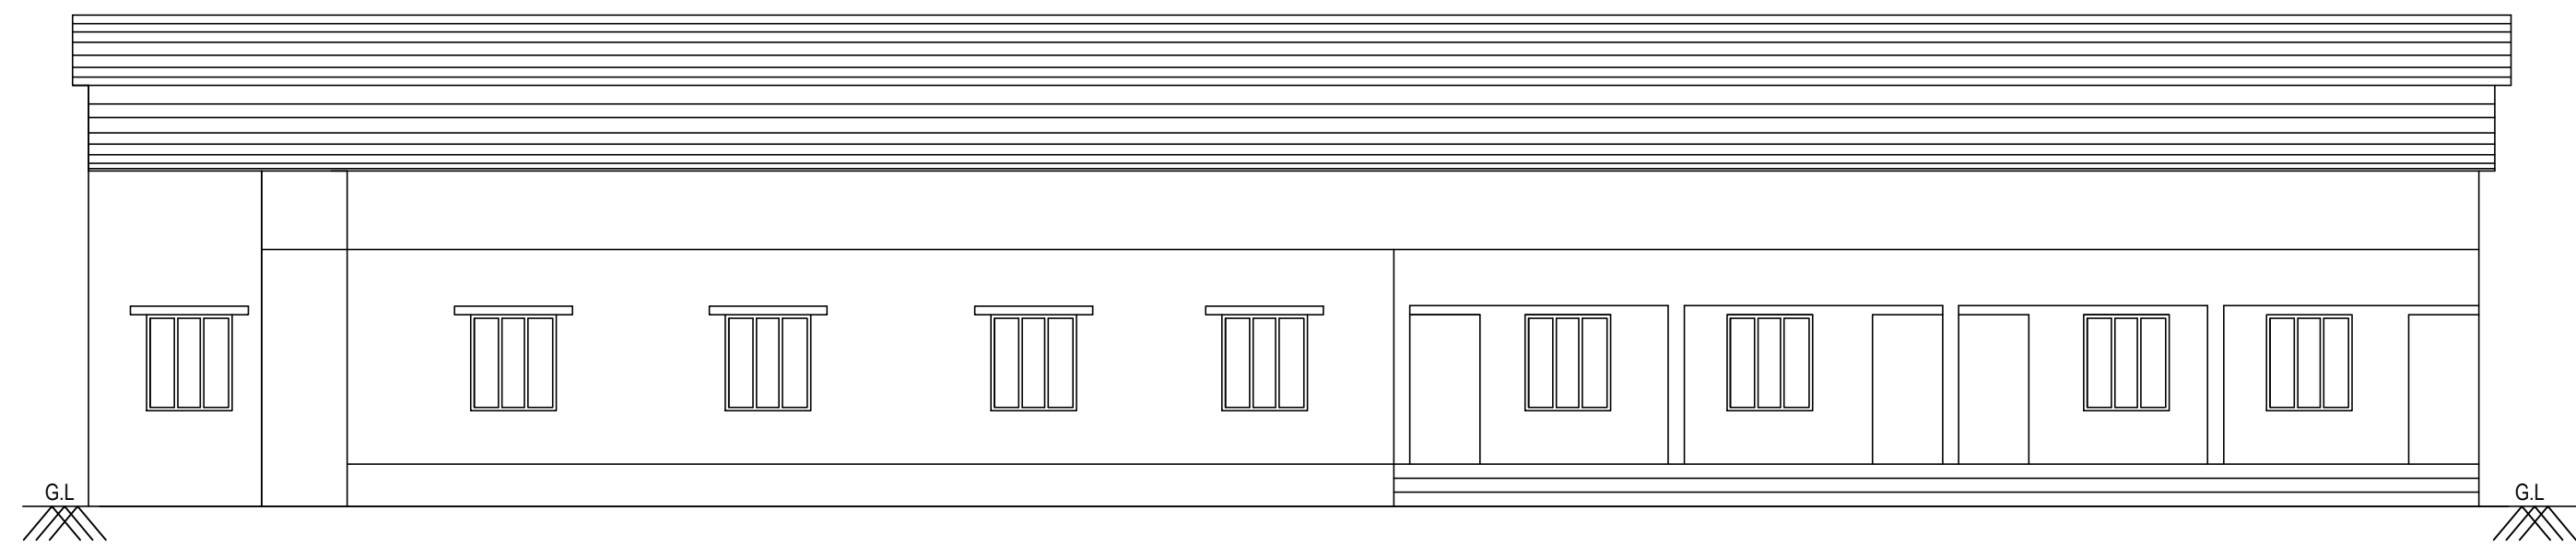


ELEVATION

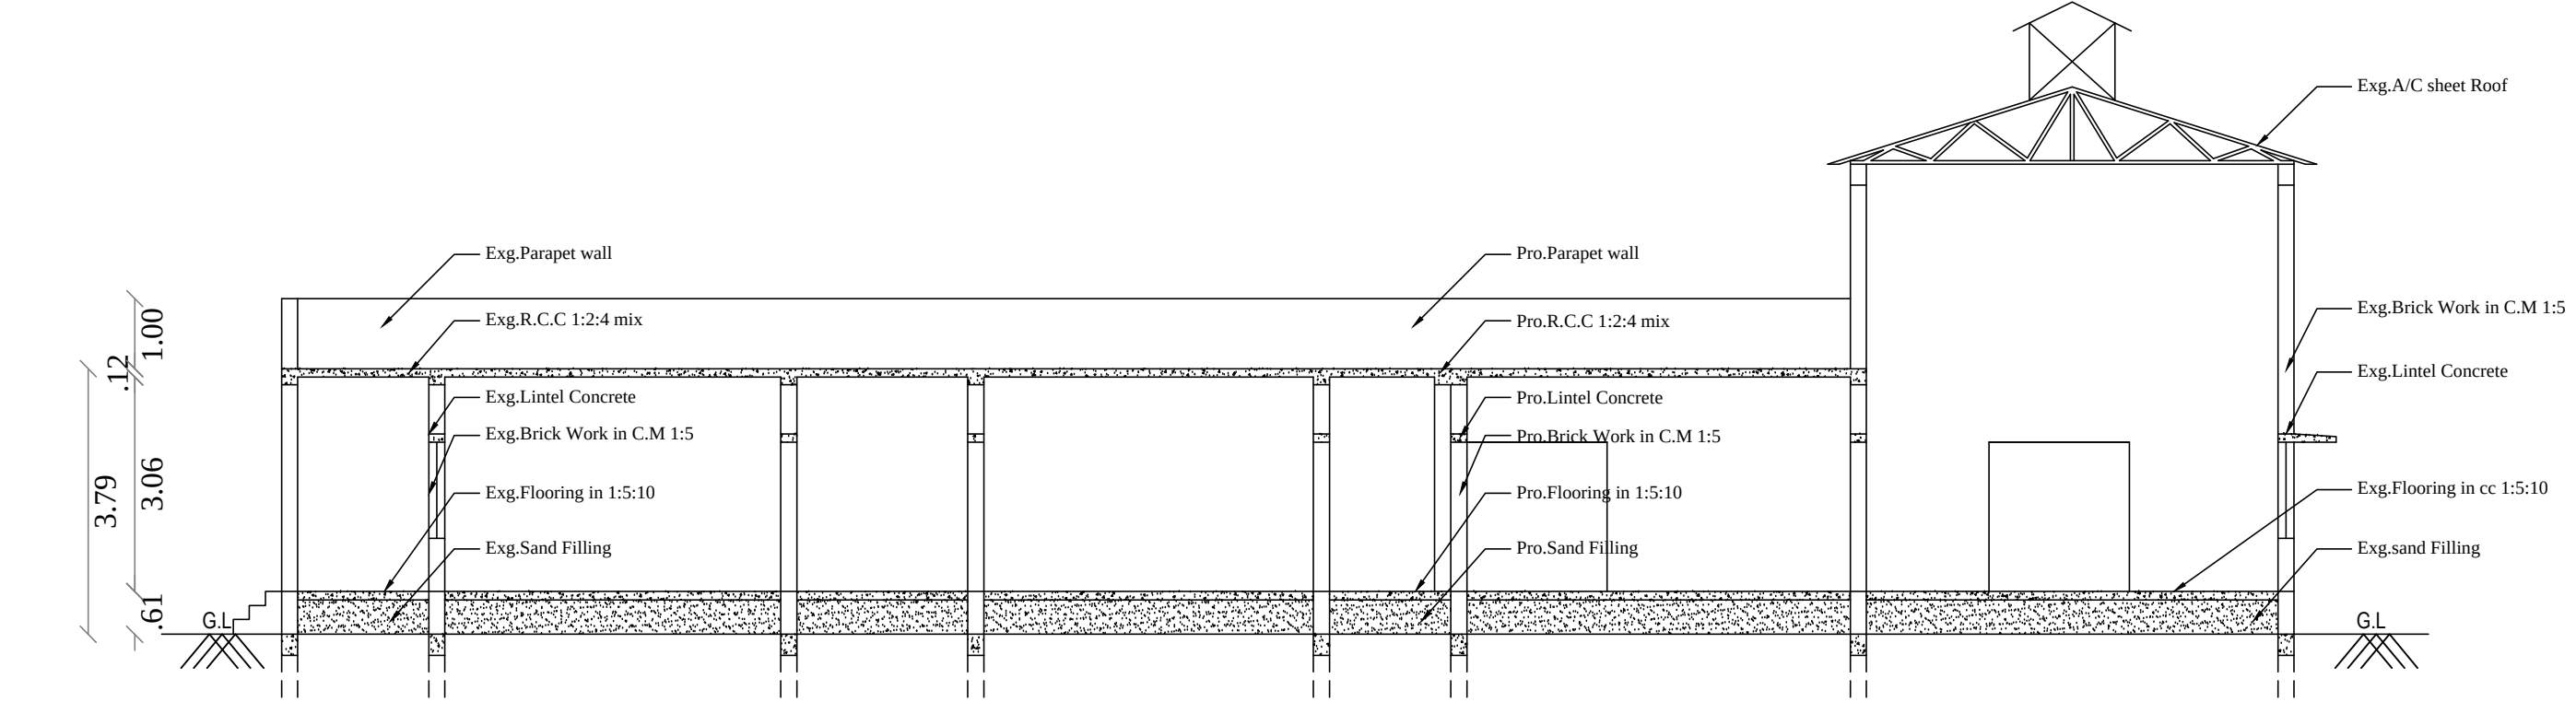


SECTION A-A

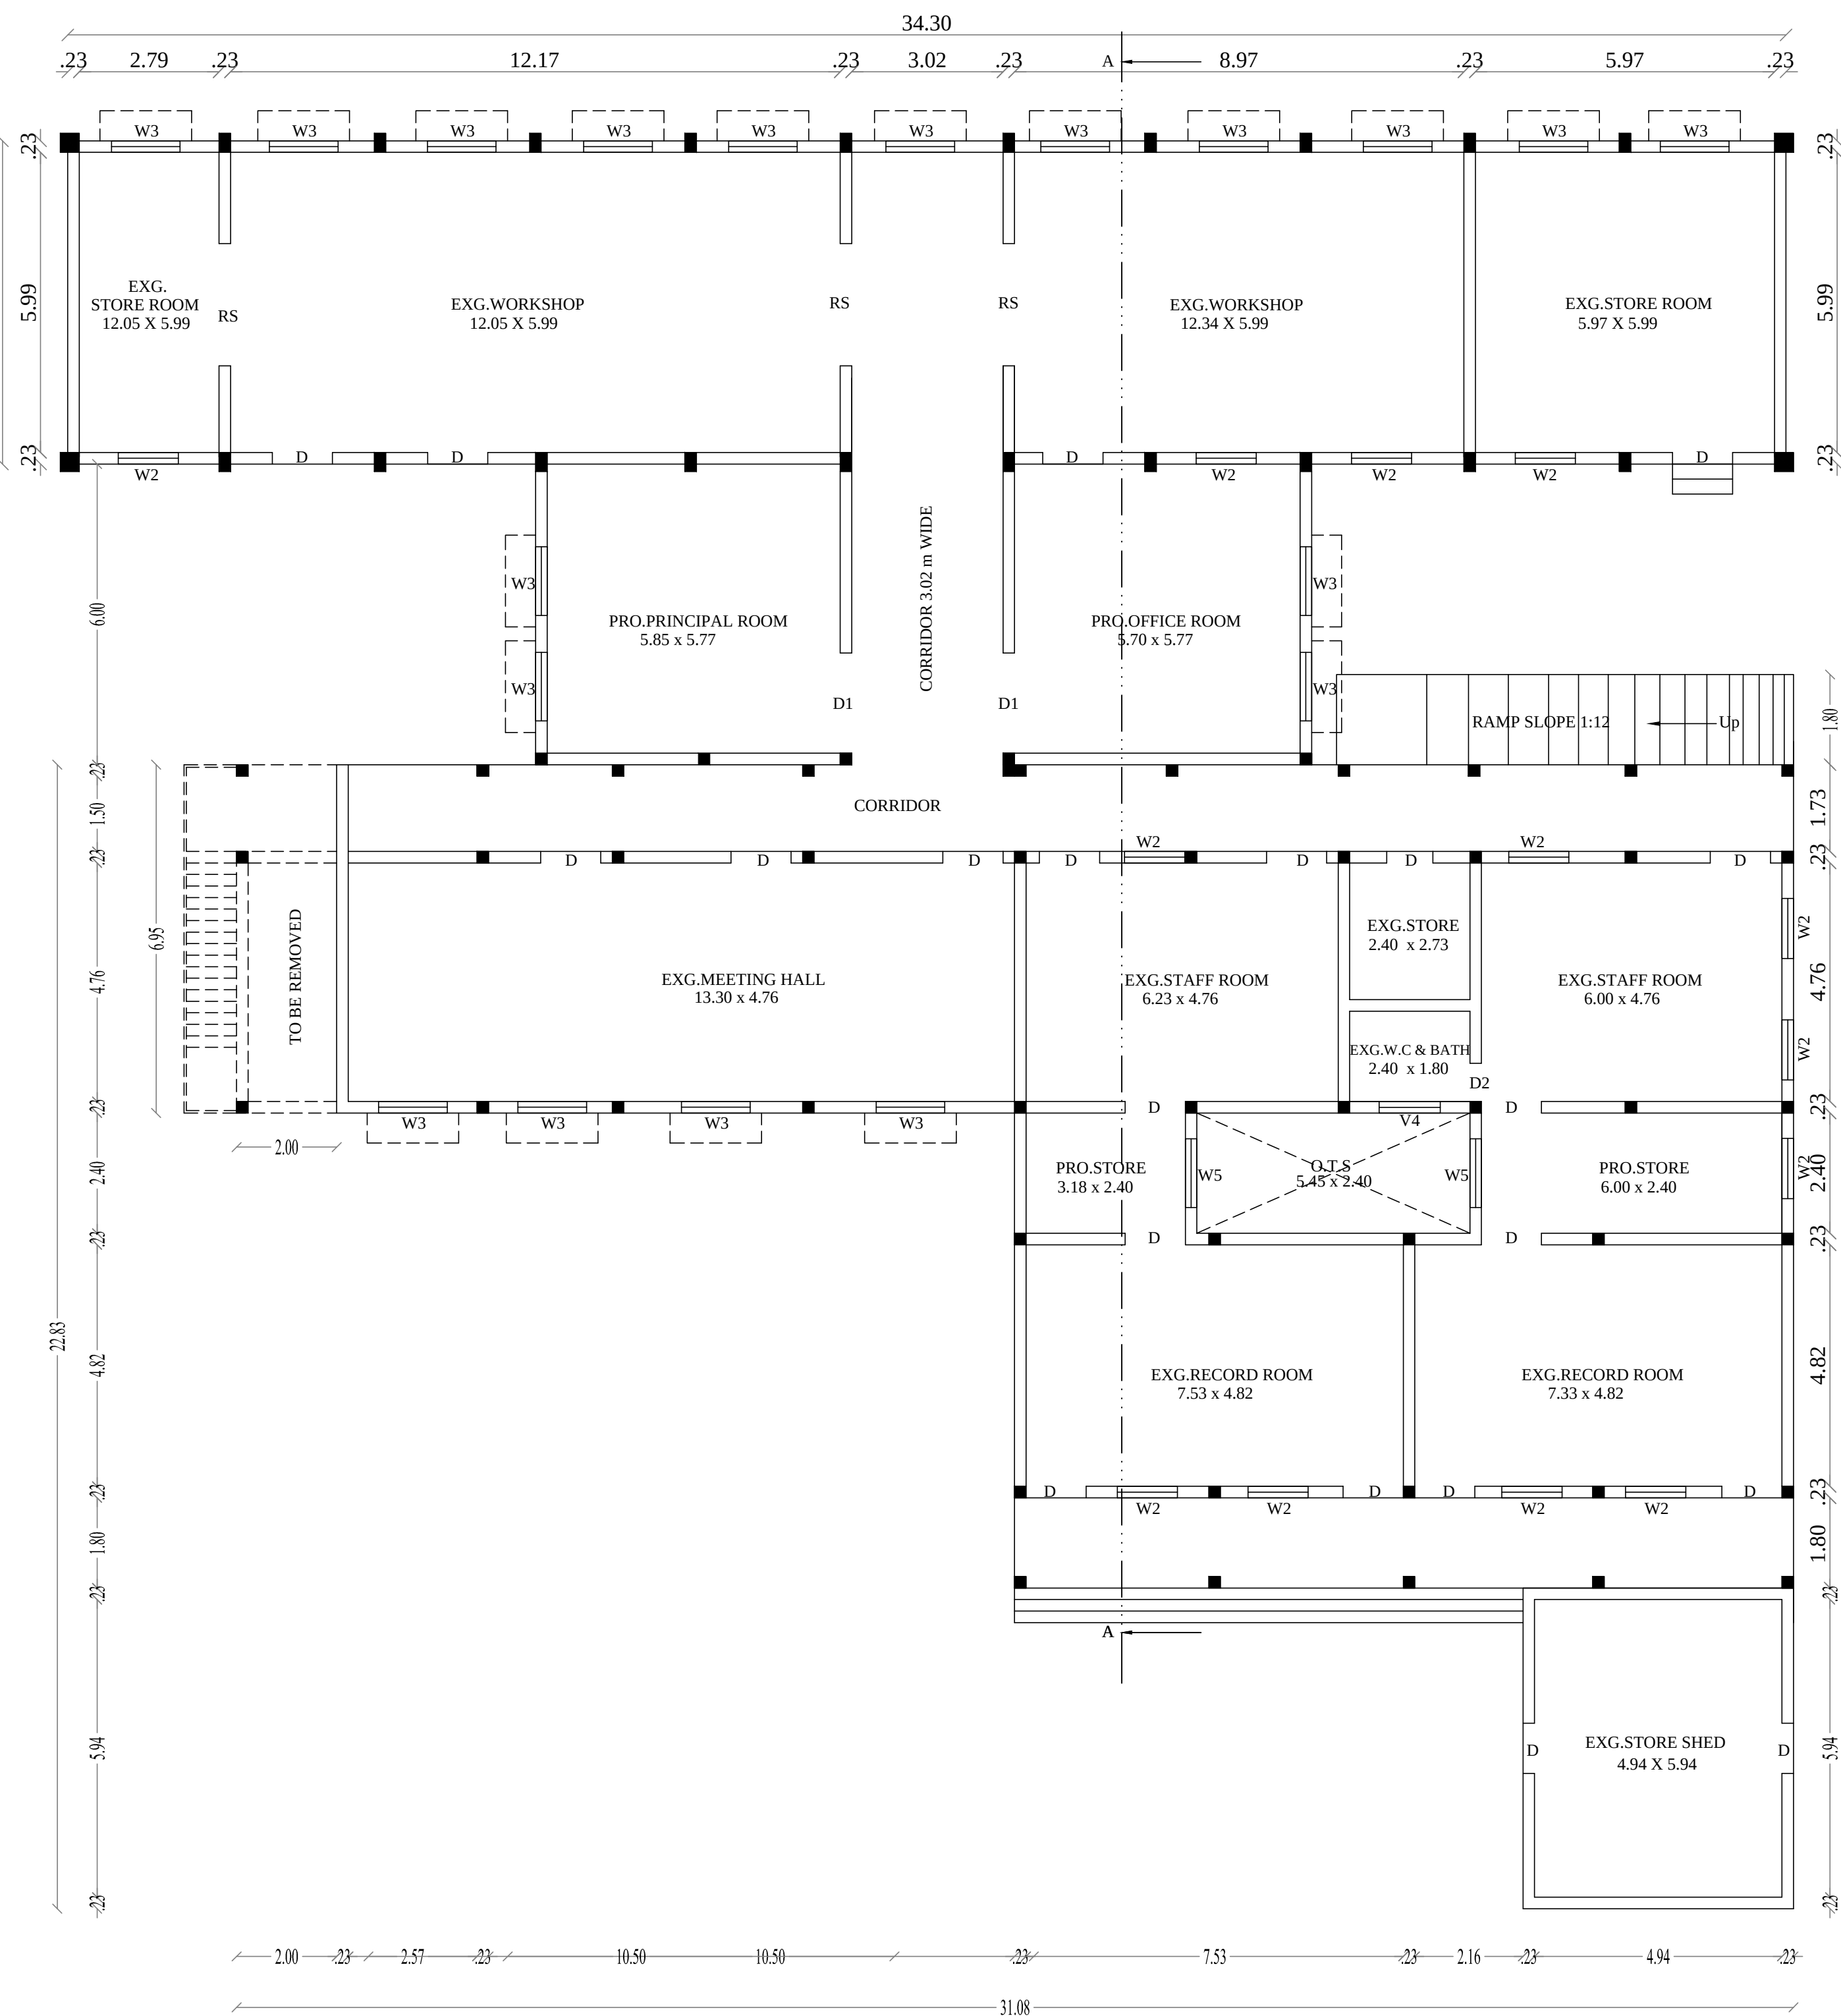


BLOCK 6 EXG & PRO.GROUND FLOOR PLAN (WORKSHOP BLOCK)

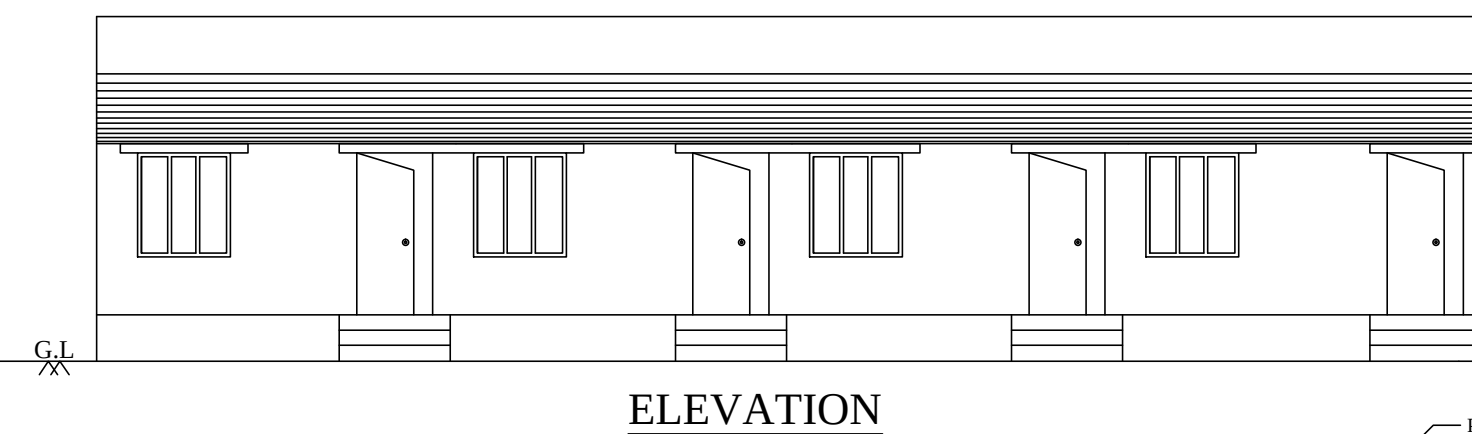


ELEVATION

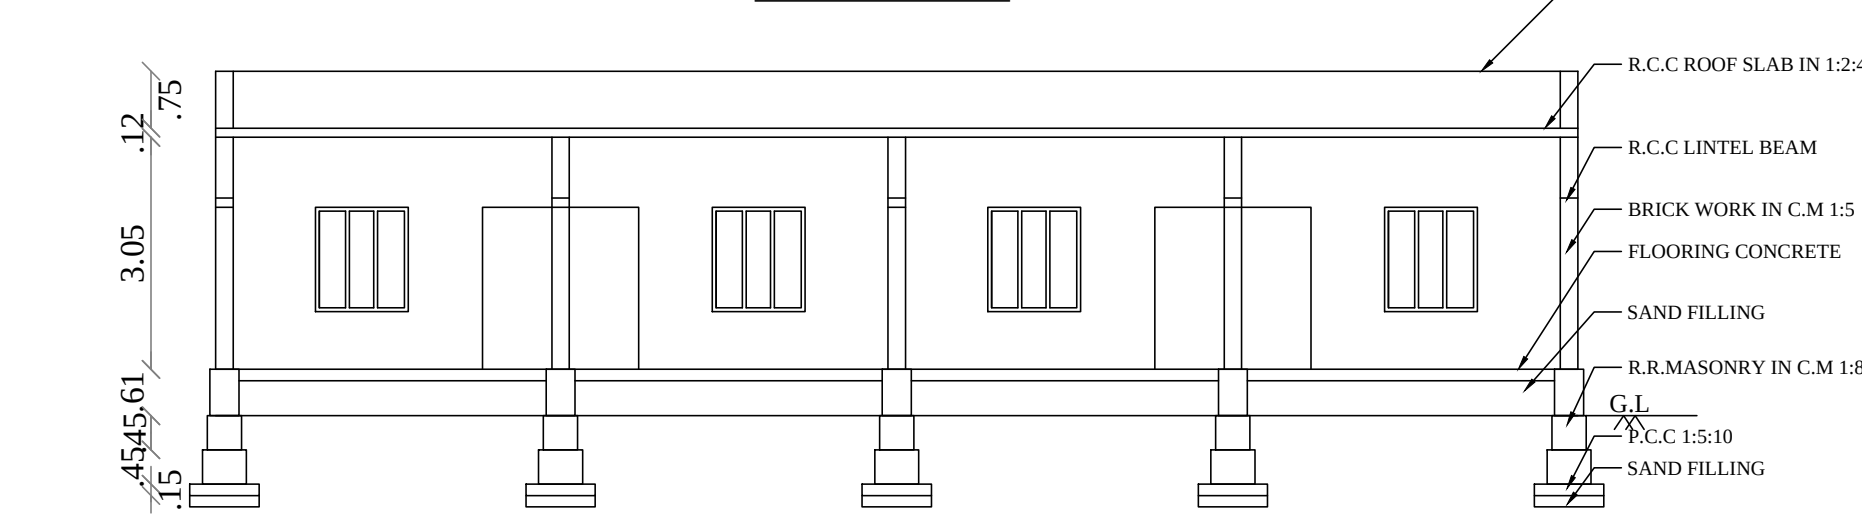


SECTION A-A

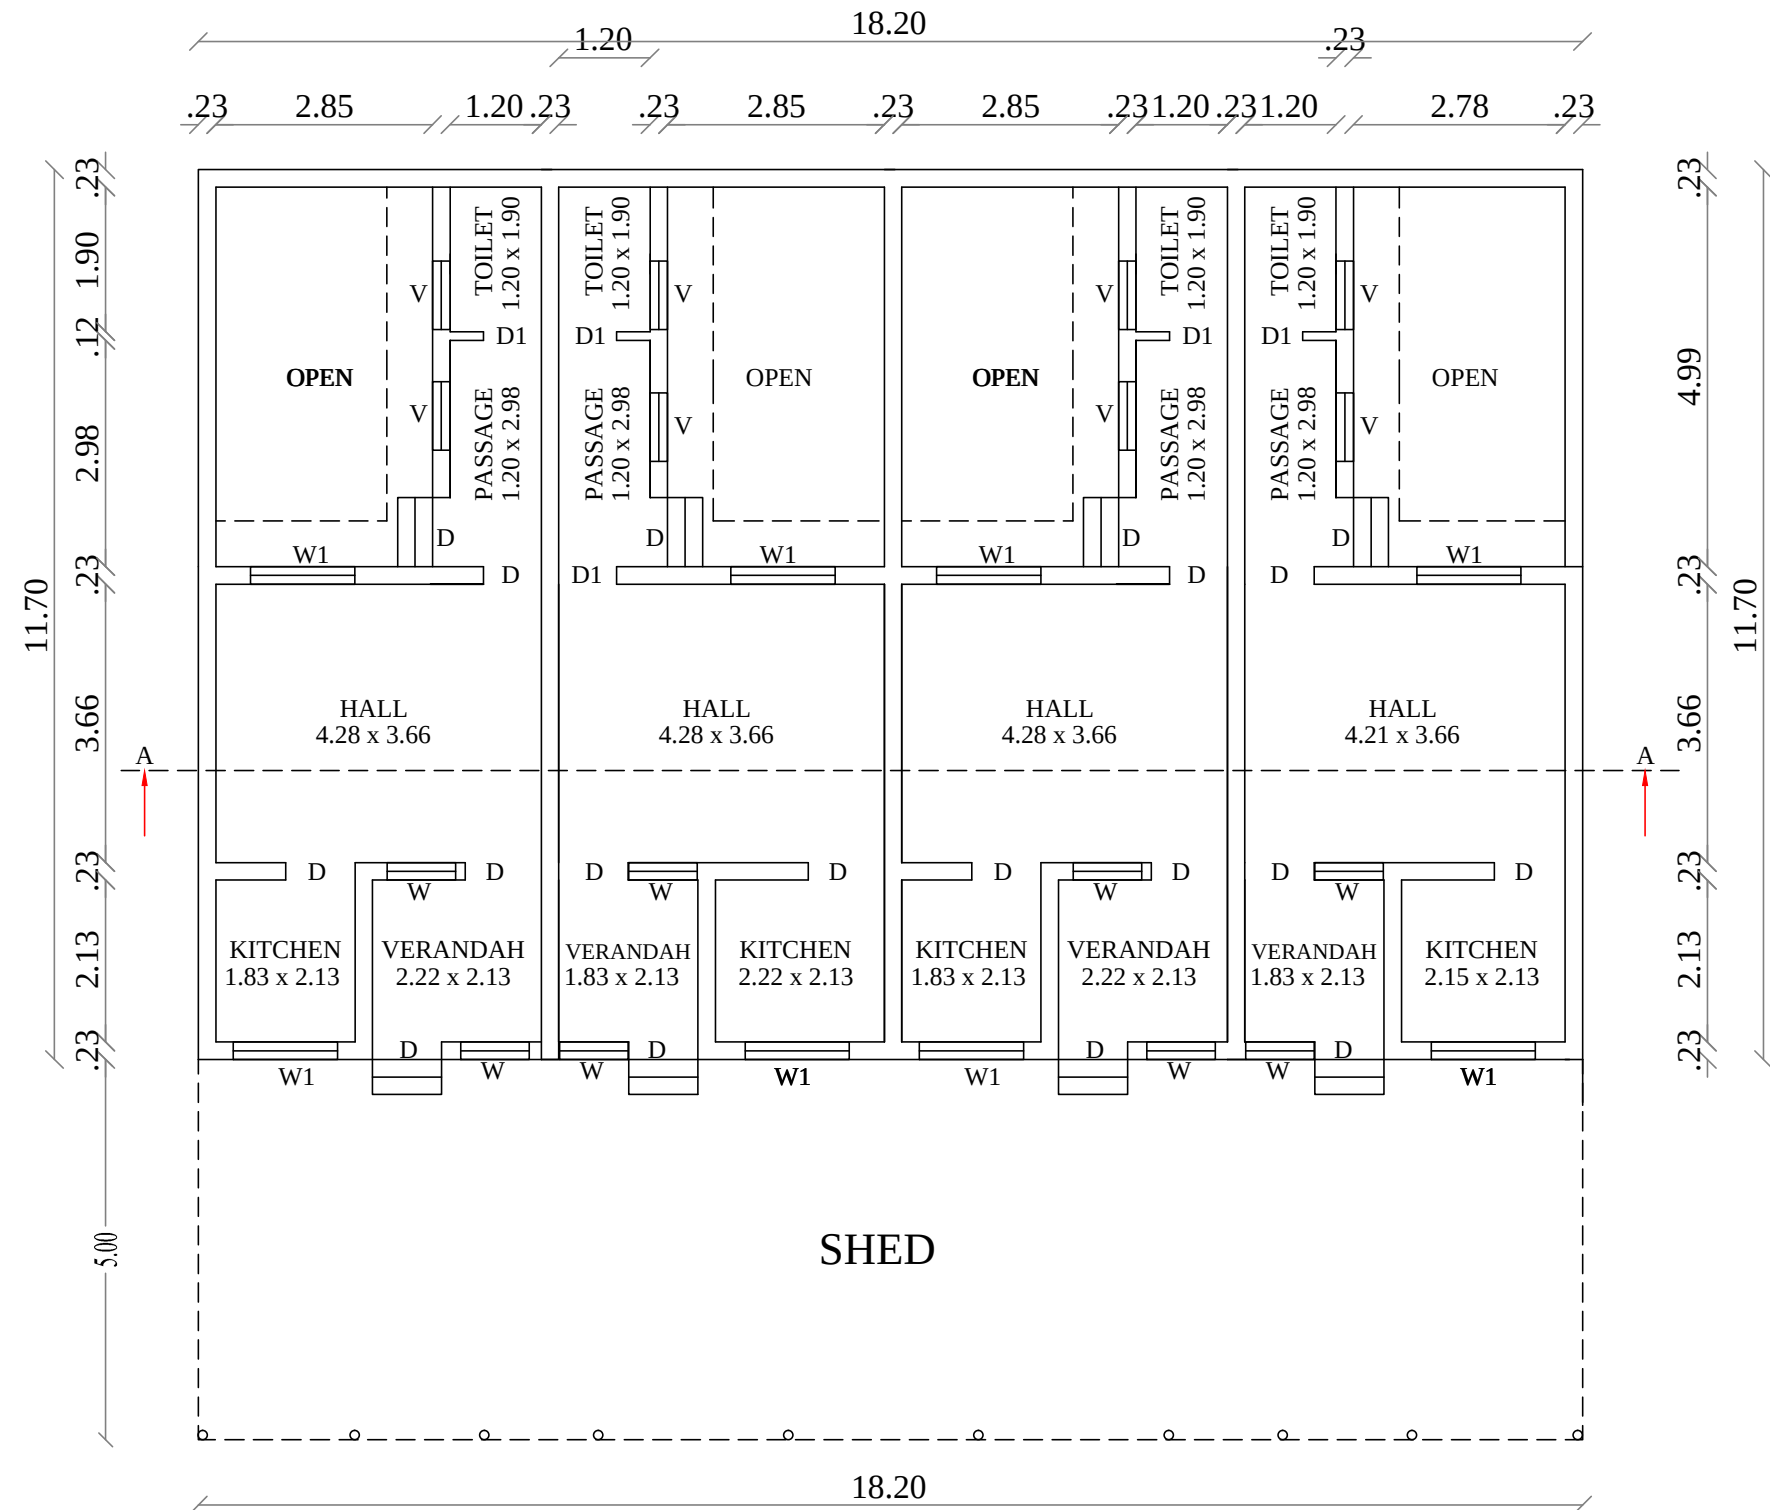


BLOCK 7 EXG.GROUND FLOOR PLAN (STAFF QUARTERS -II)

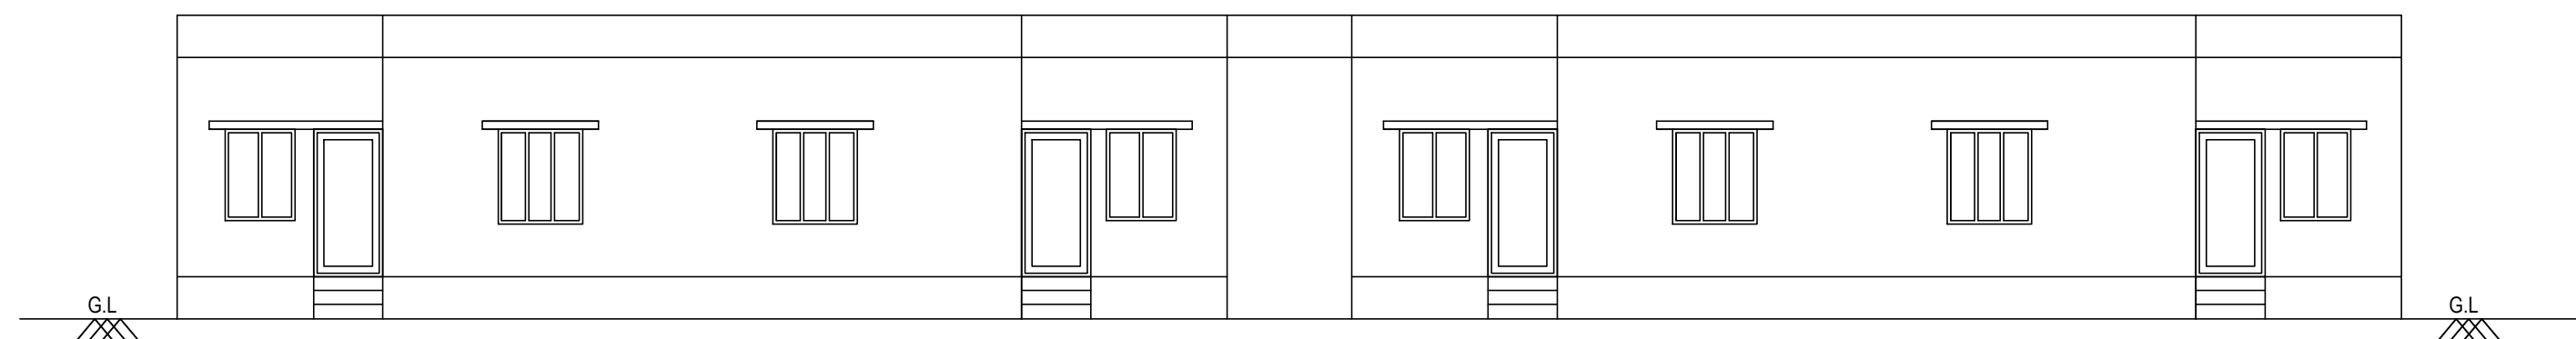


ELEVATION

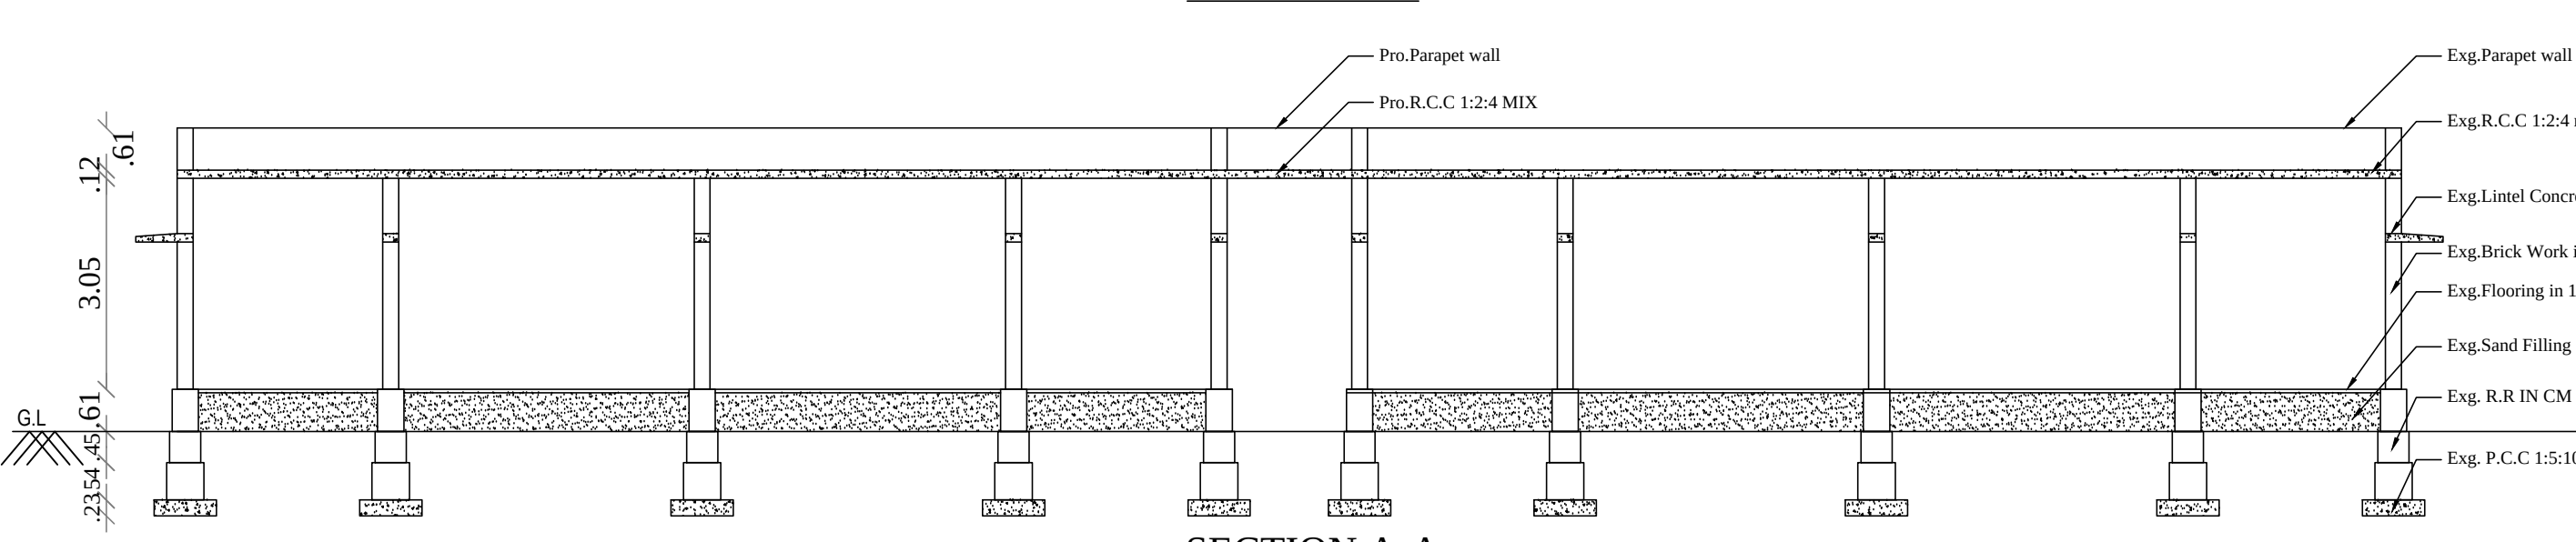


SECTION A-A

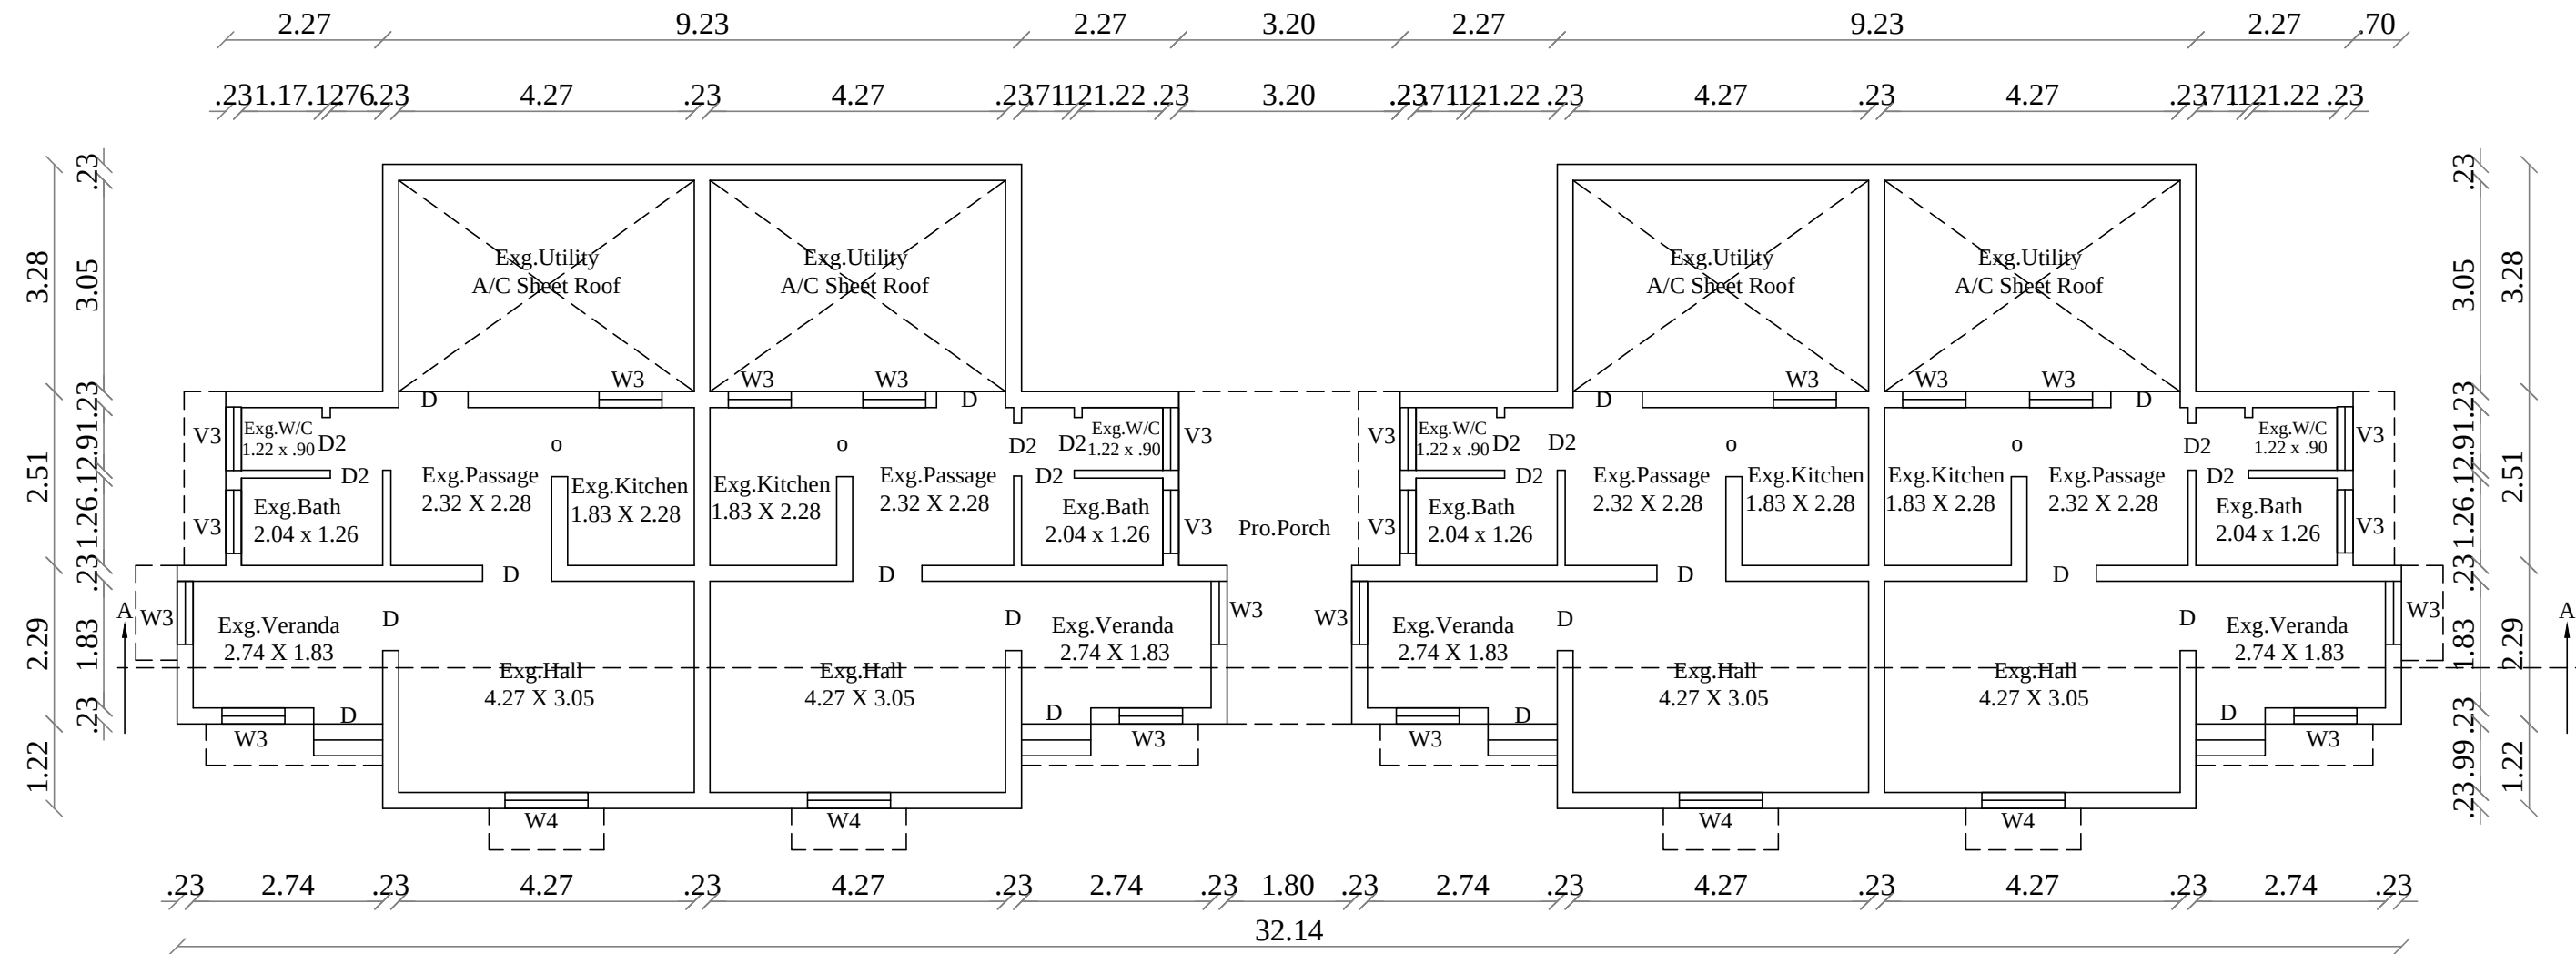


BLOCK 8 EXG & PRO.GROUND FLOOR PLAN (STAFF QUARTERS -I)

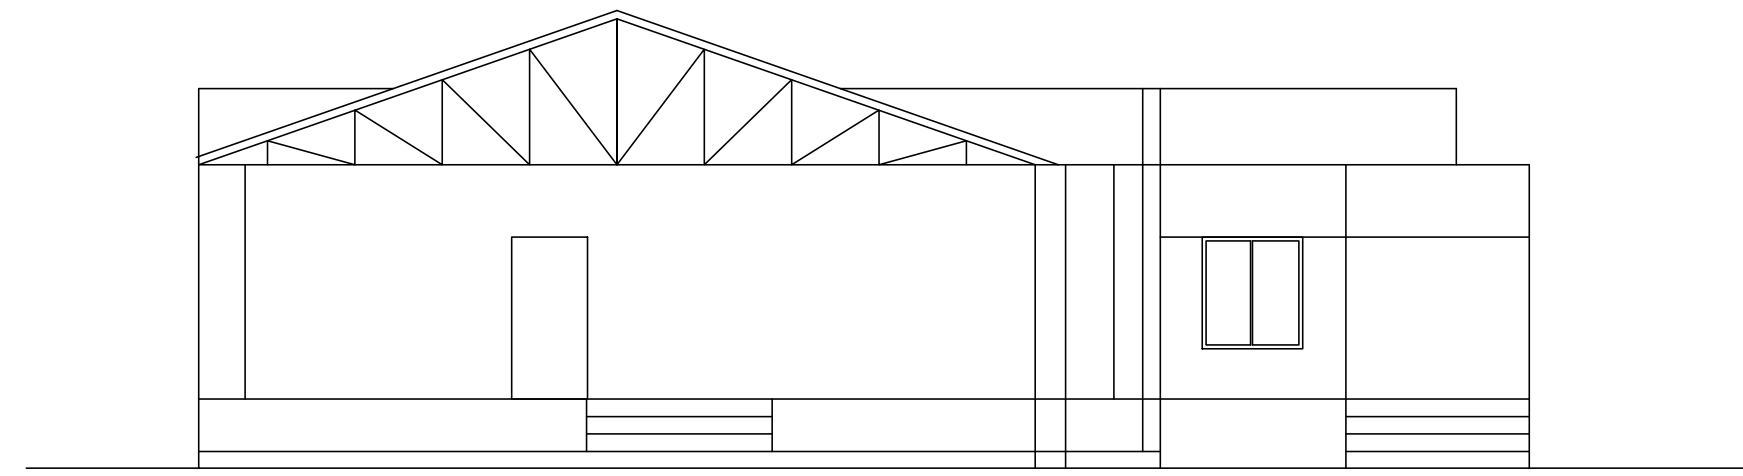

ELEVATION

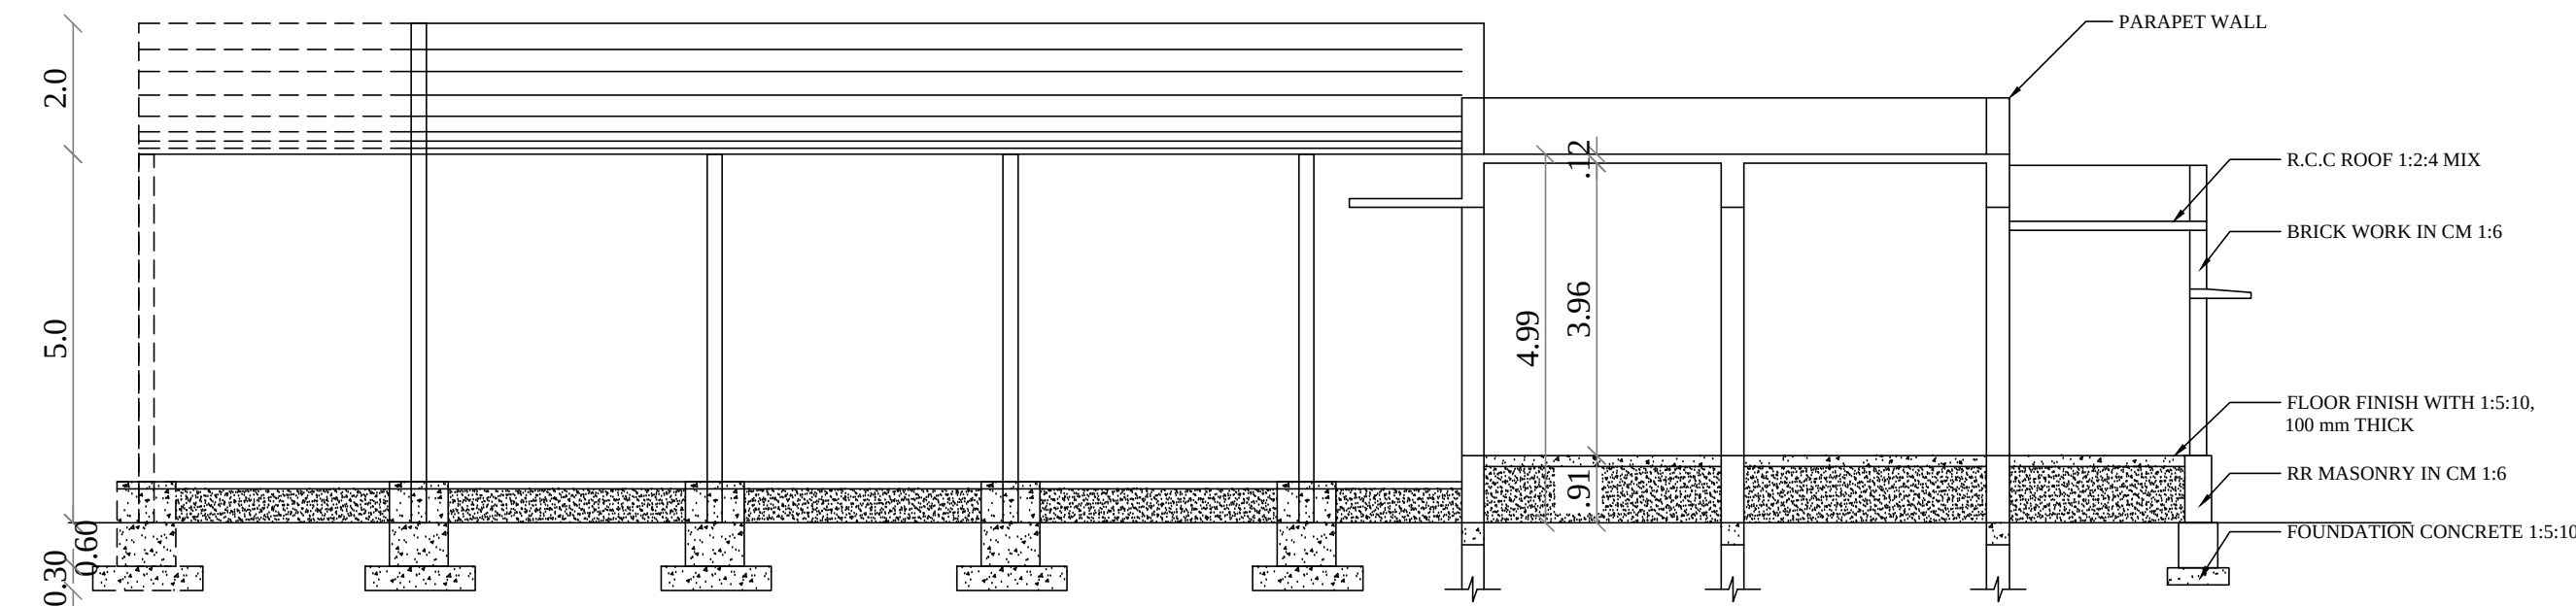

SECTION A-B

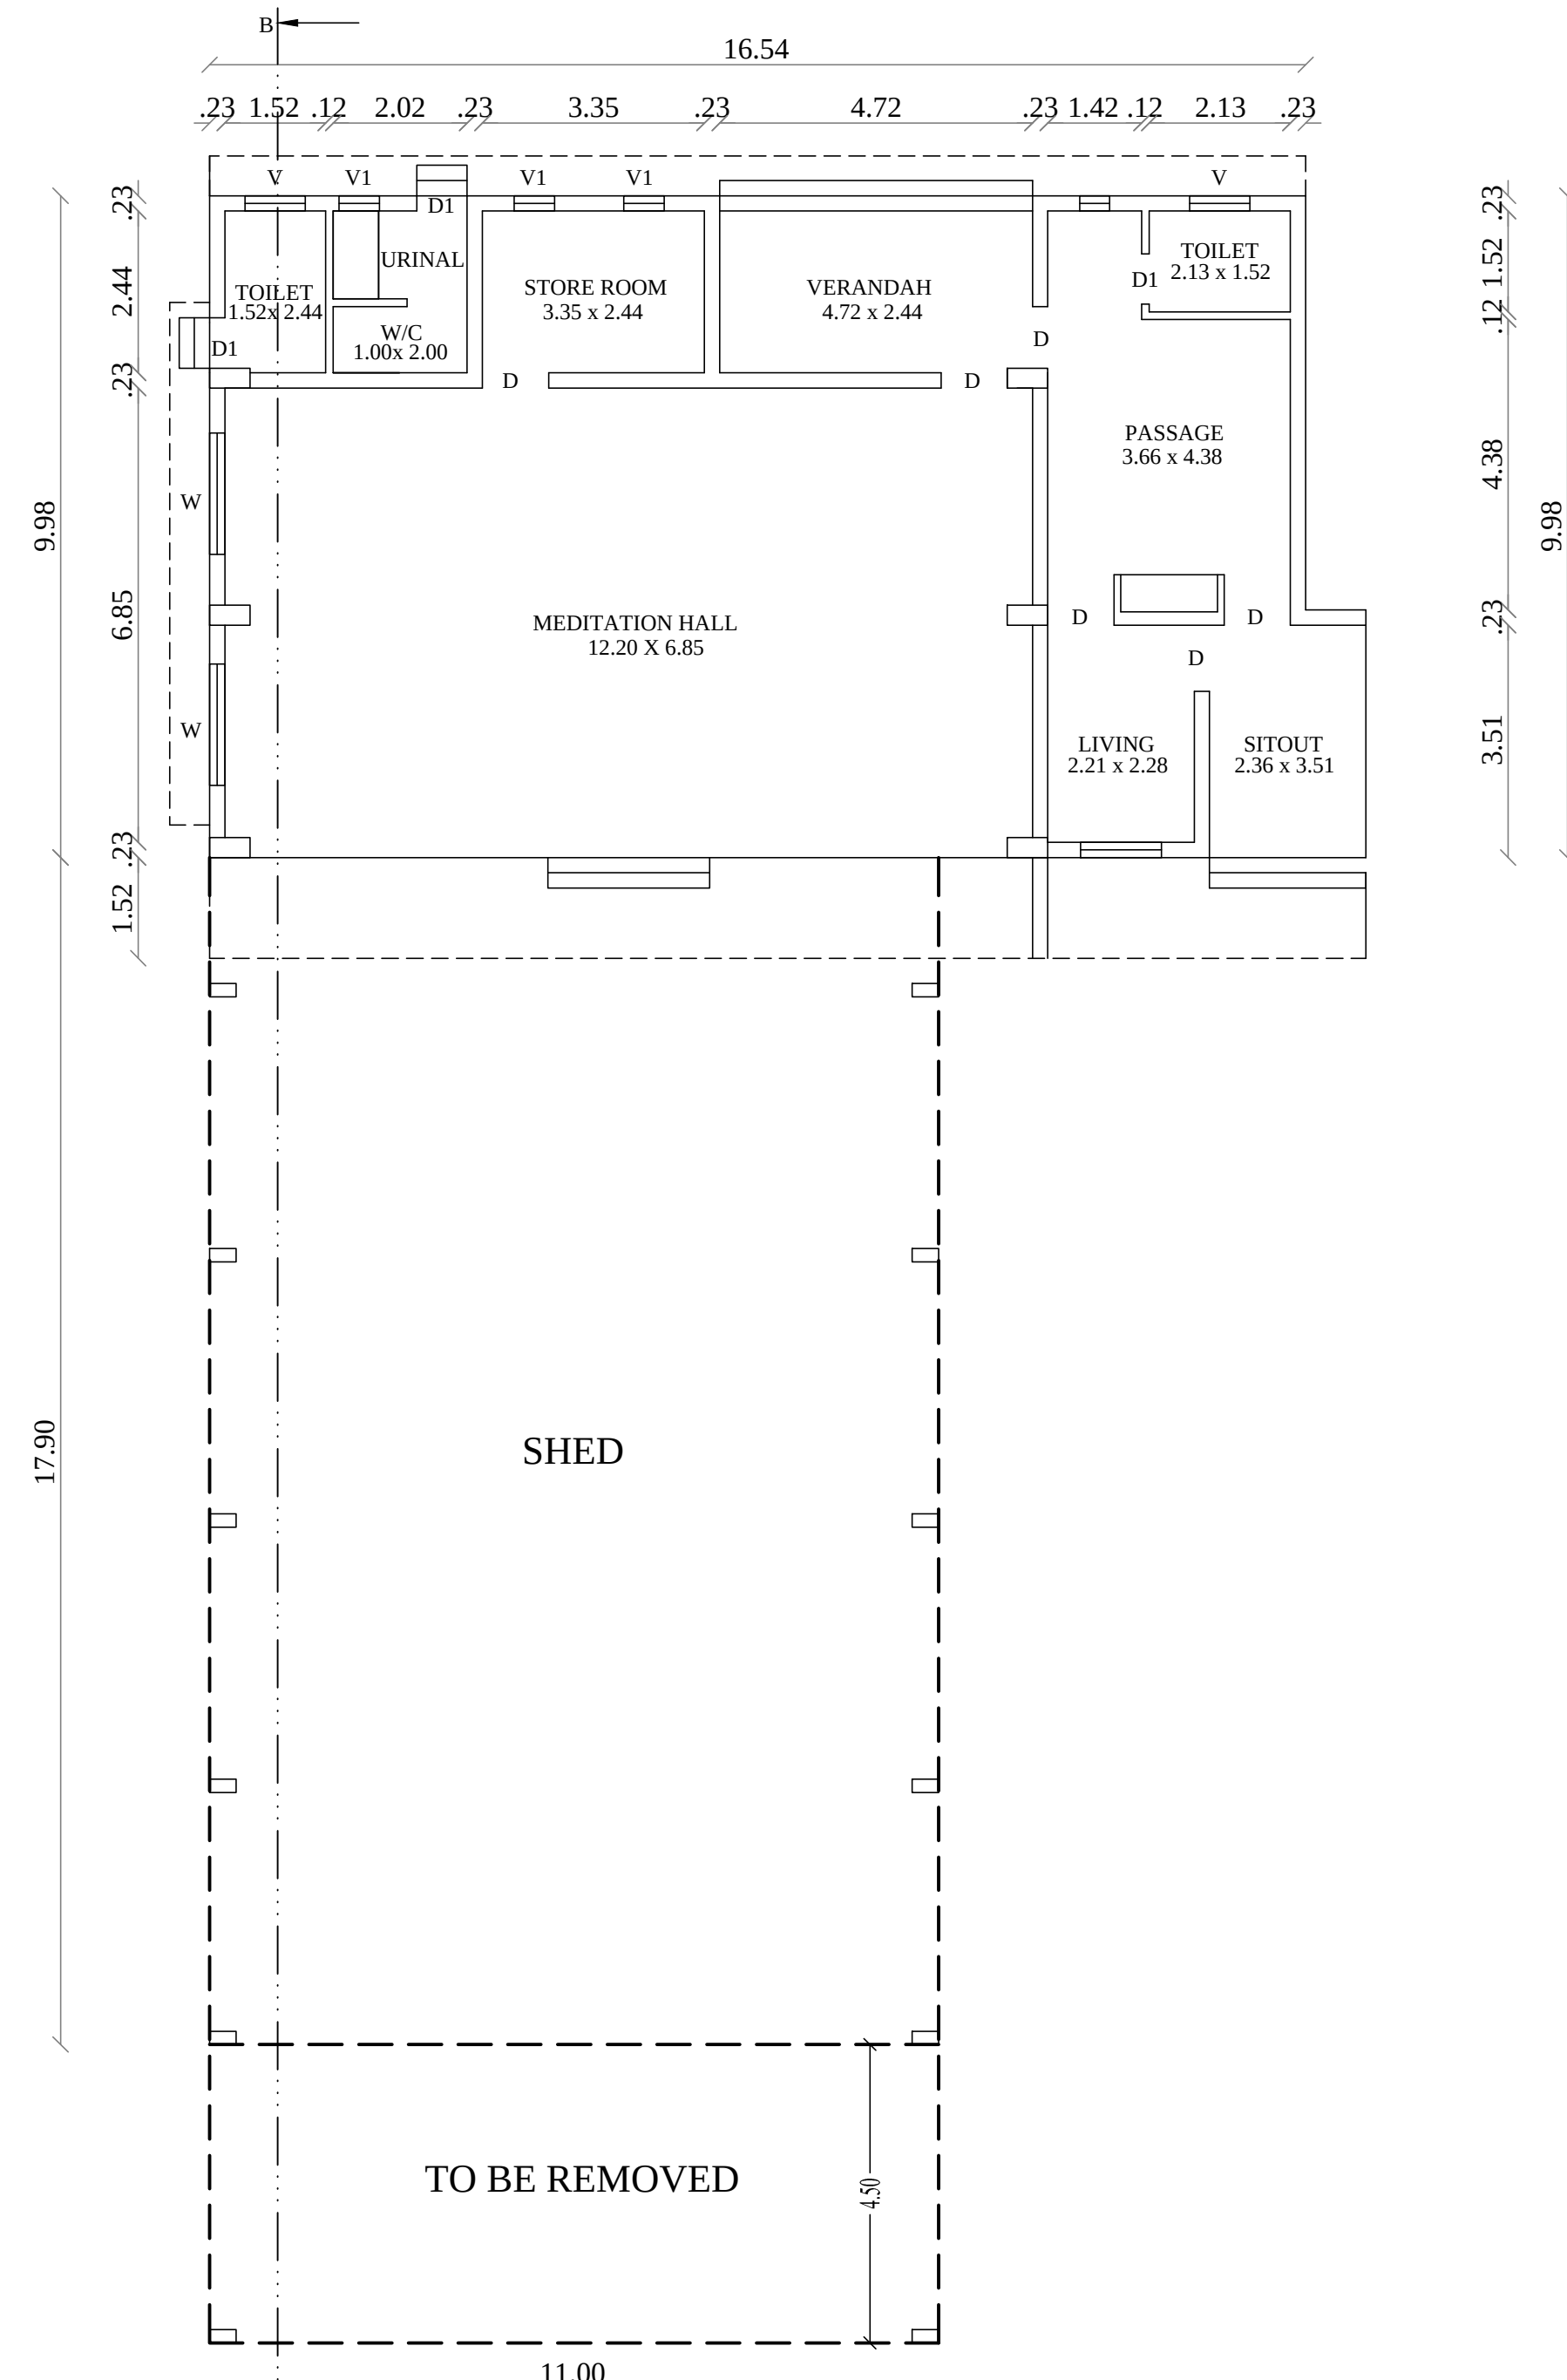

EXG.GROUND FLOOR BLOCK 9 (MEDITATION HALL)

PLAN SHOWING THE EXISTING
CONSTRUCTED COLLEGE BUILDING (Block-6,7,8,9)
DAYALBAGH EDUCATIONAL INSTITUTE OFF
CAMPUS IN S.NO:170/1A,170/1Cpart OF
MELATHIRUVENGADANATHAPURAM VILLAGE
AND PANCHAYAT, PALAYAMKOTTAI TALUK,
TIRUNELVELI DISTRICT.

ALL DIMENSIONS ARE IN METER, SCALE 1:100 | SHEET NO.2

APPLICANT NAME:
Mr.JEYARAM SINGH
DAYALBAGH EDUCATIONAL INSTITUTE OFF CAMPUS
MELA THIRUVENGADANATHAPURAM VILLAGE,
PALAYAMKOTTAI TALUK, TIRUNELVELI DISTRICT.

AREA DETAILS	Existing Building Isue Approved Area in Sq.m F.S.I AREA Sq.mt	Proposed Building Area in Sq.m F.S.I AREA Sq.mt	Total Area F.S.I AREA Sq.mt
BLOCK 6 (WORKSHOP)	568.00	189.95	757.95
GROUND FLOOR AREA	247.66	---	247.66
BLOCK 7 (STAFF QUARTERS -II)	---	---	---
GROUND FLOOR AREA	221.68	---	223.83
BLOCK 8 (STAFF QUARTERS -I)	---	---	---
GROUND FLOOR AREA	375.12	---	375.12
BLOCK 9 (MEDITATION HALL)	---	---	---
GROUND FLOOR AREA	---	---	---

JOINERY DETAILS

D	Door	1.00 x 2.10
D1	Door	2.00 x 2.10
D2	Door	0.76 x 2.10
W2	Window	0.91 X 1.50
W3	Window	1.20 X 1.50
W5	Window	1.80 X 1.50
V4	Ventilator	1.20 X 0.90
RS	Rolling Shutter	2.00 X 2.10

SWP/BPA/011758/2023
B.P/DTCP No:417/2023

V.K. Ashok Kumaravel, B.E., M.E., A.I.A., P.W.E.
Civil & Structural Engineer
Registered Construction Engineer
Reg No. RCE/TVJ/January/2020/018

CONSTRUCTION ENGINEER

V.K. Ashok Kumaravel, B.E., M.E., A.I.A., P.W.E.
Civil & Structural Engineer
Registered Structural Engineer Grade I
Reg No. RSE/Gr-I/TVJ/January/2020/019


STRUCTURAL ENGINEER

Mr DAYALBAGH EDUCATIONAL INSTITUTE OFF CAMPUS
CO-ORDINATOR


APPLICANT

Er. P. K. THAMEEMUL ANSARI B.E.
Reg. No. : RE/Gr II/TVL/March/2019/006
35 / 13-2, Firthous Complex, Ambai Road,
Melapalayam, (Sub-Registrar Office Building)
Tirunelveli - 627 005. Cell : 9488237454.


REG.ENGINEER

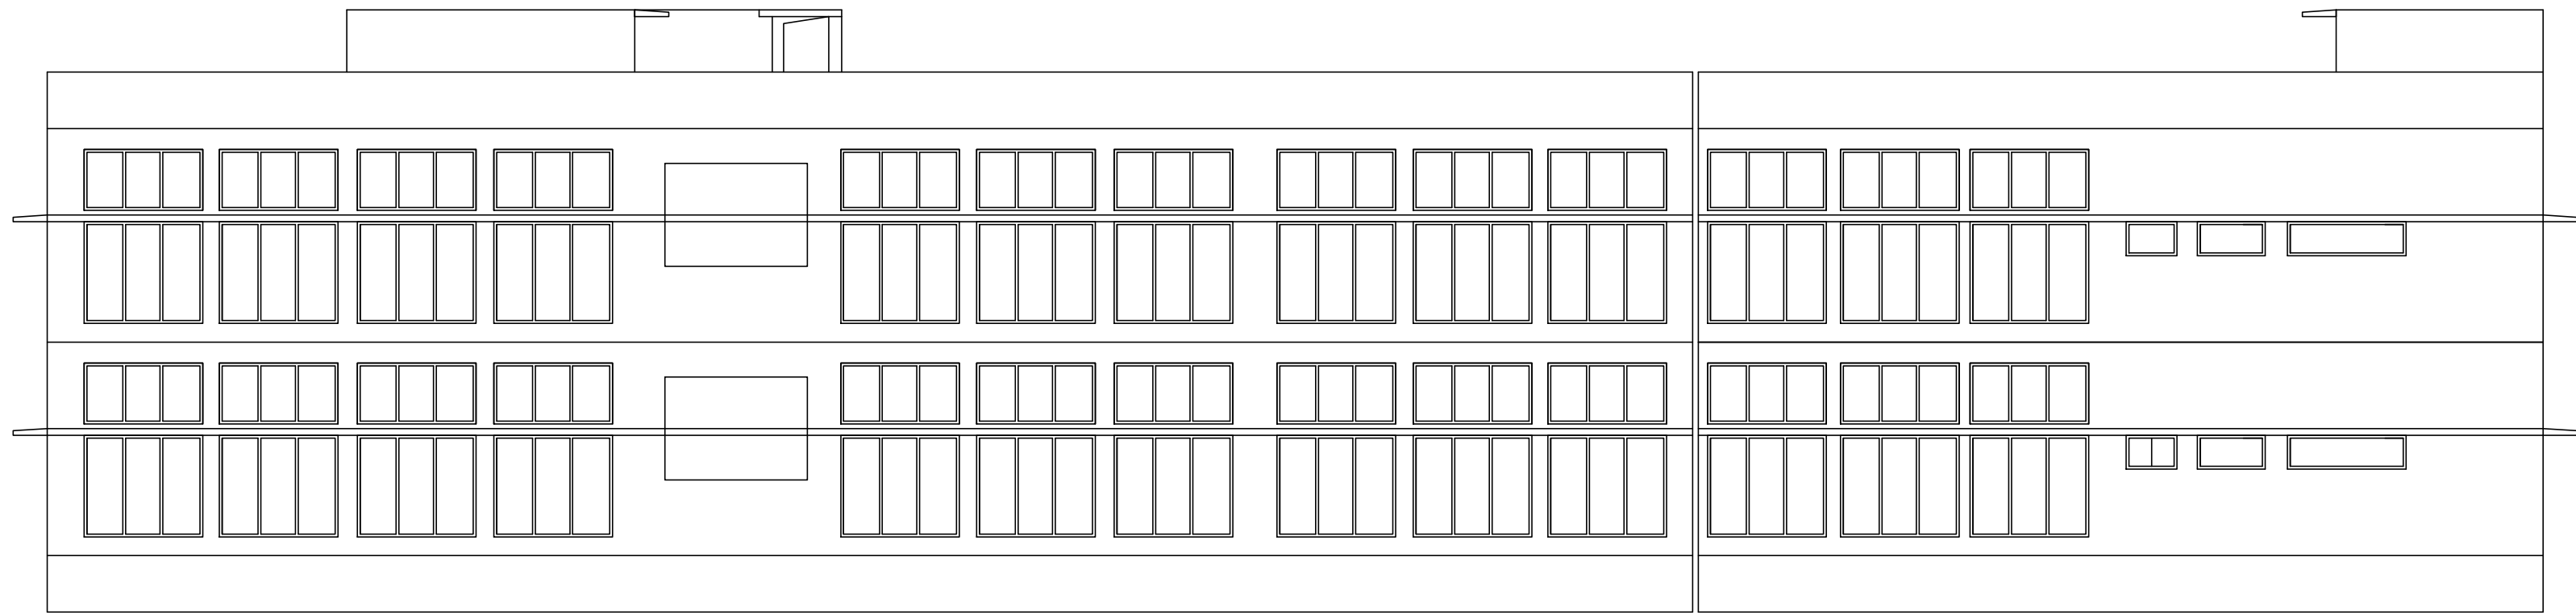

ELEVATION BLOCK 1

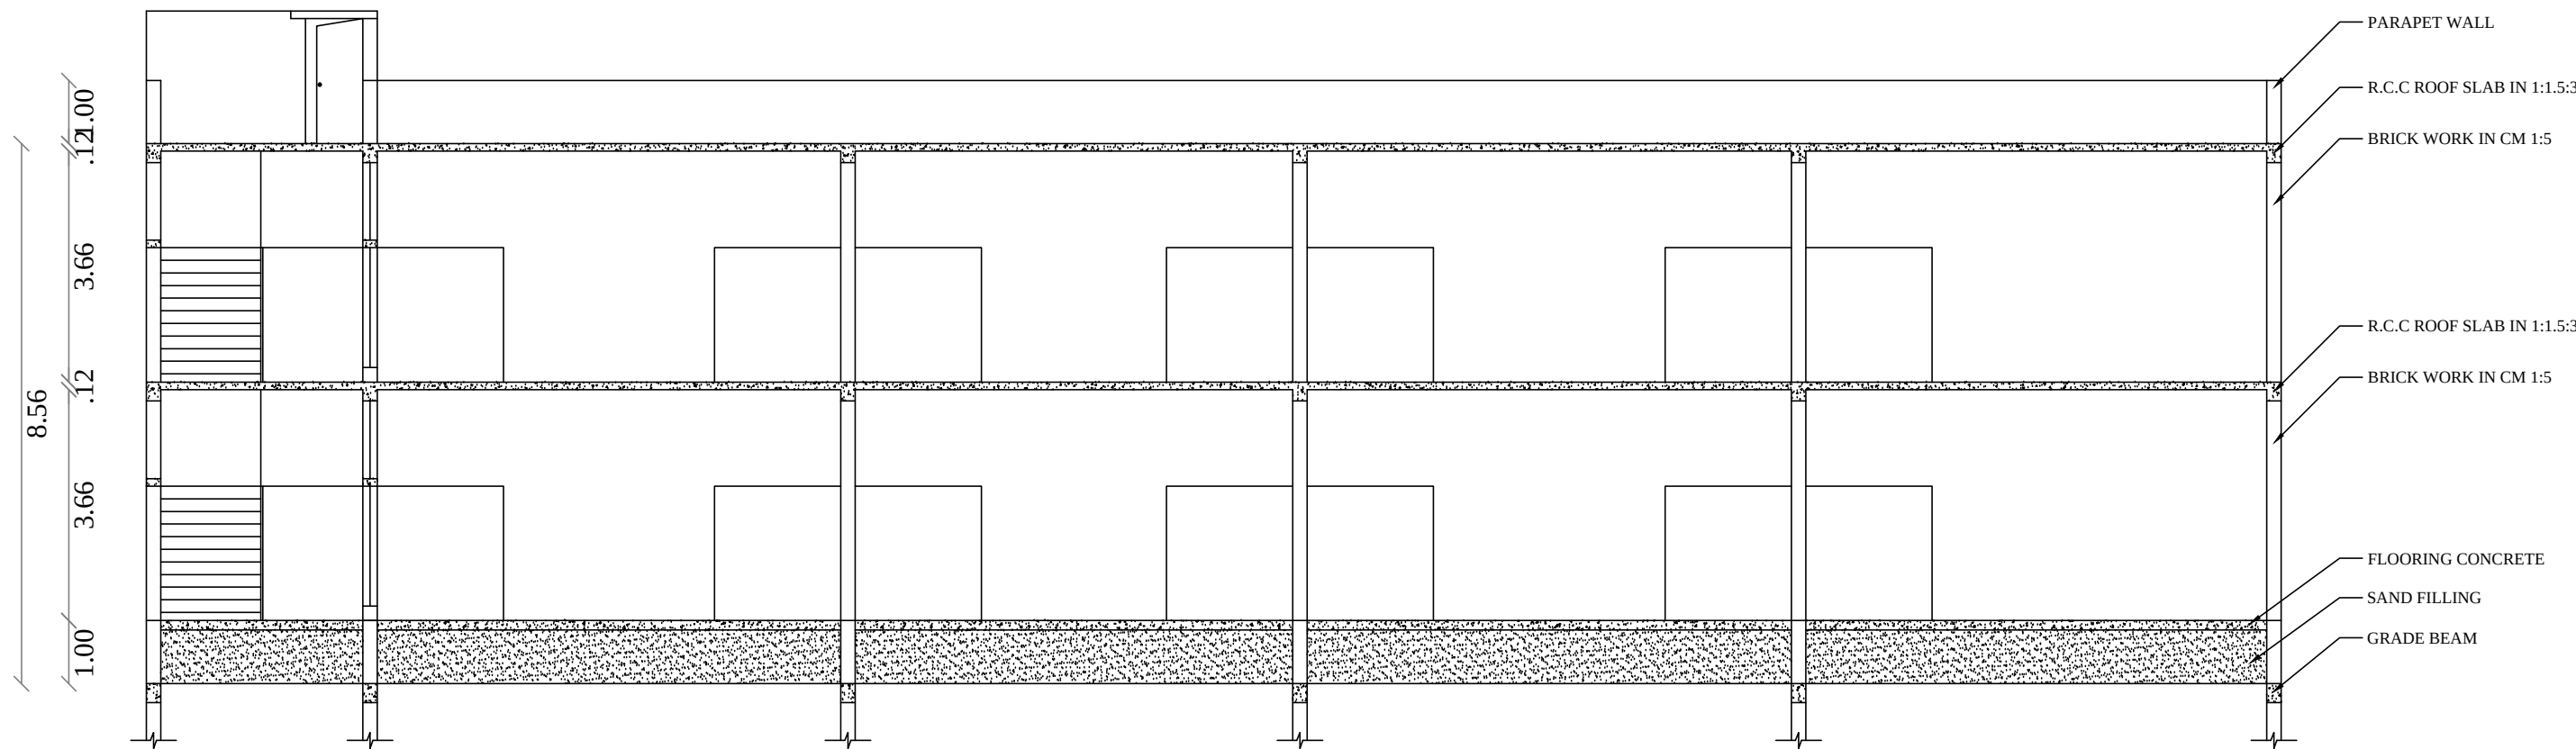

SECTION ON "C-D" BLOCK 1

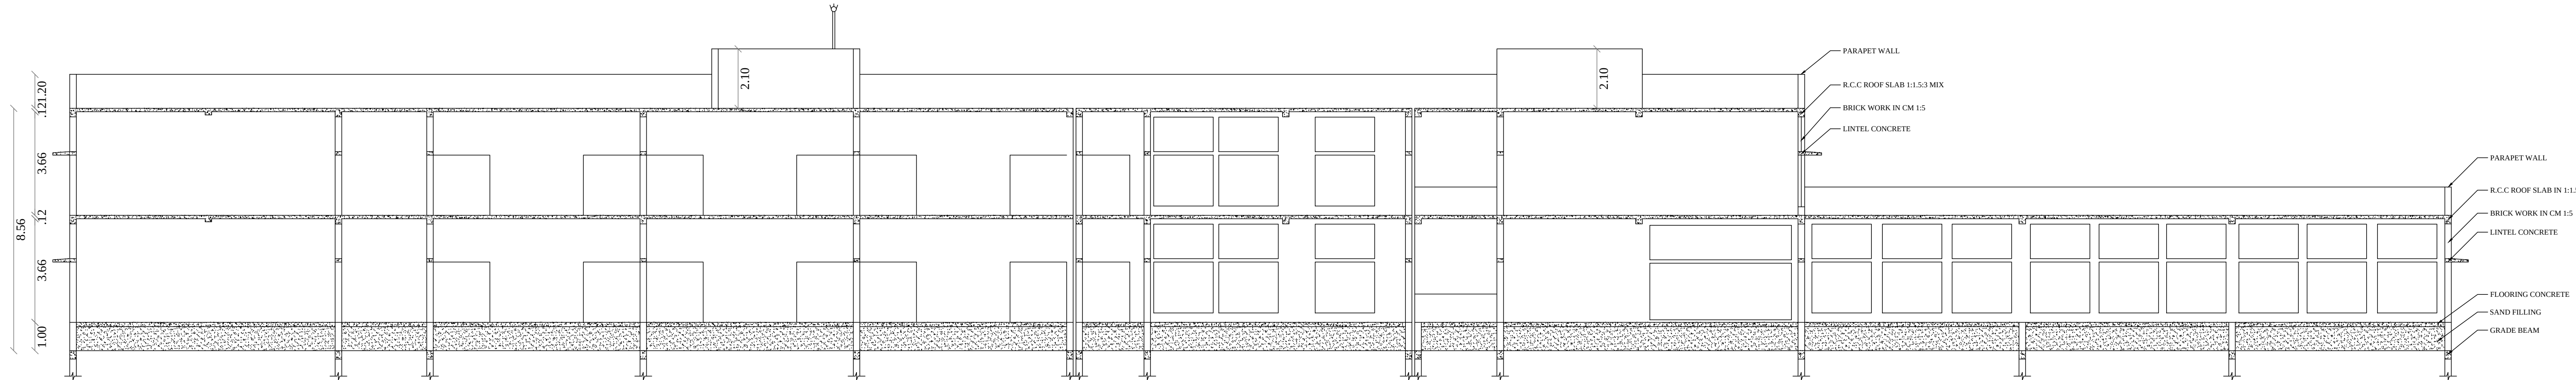

BLOCK 1 SECTION ON "A-B"

PLAN SHOWING THE PROPOSED CONSTRUCTION OF COLLEGE BUILDING FOR DAYALBAGH EDUCATIONAL INSTITUTE OFF CAMPUS IN S.NO:170/1A,170/1Cpart OF MELATHIRUVENGADANATHAPURAM VILLAGE AND PANCHAYAT, PALAYAMKOTTAI TALUK, TIRUNELVELI DISTRICT.

ALL DIMENSIONS ARE IN METER, SCALE 1:100 | SHEET NO: 3


APPLICANT NAME:
Mr.JEYARAM SINGH
DAYALBAGH EDUCATIONAL INSTITUTE OFF CAMPUS
MELA THIRUVENGADANATHAPURAM VILLAGE,
PALAYAMKOTTAI TALUK, TIRUNELVELI DISTRICT.

AREA DETAILS	F.S.I AREA Sq.mt	NON F.S.I AREA Sq.mt	TOTAL AREA Sq.mt
CLASS ROOM BLOCK BLOCK 1 AREA			
GROUND FLOOR	2410.58	---	2410.58
FIRST FLOOR	1833.59	---	1833.59
HEAD ROOM	---	131.11	131.11
TOTAL FLOOR	4244.17	131.11	4375.28

SWP/BPA/011758/2023
B.P/DTCP No:417/2023

 V.K. Ashok Kumaravel, B.E., M.E., A.I.X.(P.W.), Civil & Structural Engineer Registered Construction Engineer Reg.No. RCE/TVL/January/2020/018	 V.K. Ashok Kumaravel, B.E., M.E., A.I.X.(P.W.), Civil & Structural Engineer Registered Structural Engineer Grade I Reg.No. RSEGr-TV/L/January/2020/019
CONSTRUCTION ENGINEER	STRUCTURAL ENGINEER

 Er. P. K. THAMEEMUL ANSARI B.E. Reg. No.: RE/Gr/I/TVL/March/2019/006 35 / 13-2, Firdous Complex, Ambai Road, Melpalayam, (Sub-Registrar Office Building) Tirunelveli - 627 005. Cell : 9488237454. CO-ORDINATOR	APPLICANT
	REG.ENGINEER

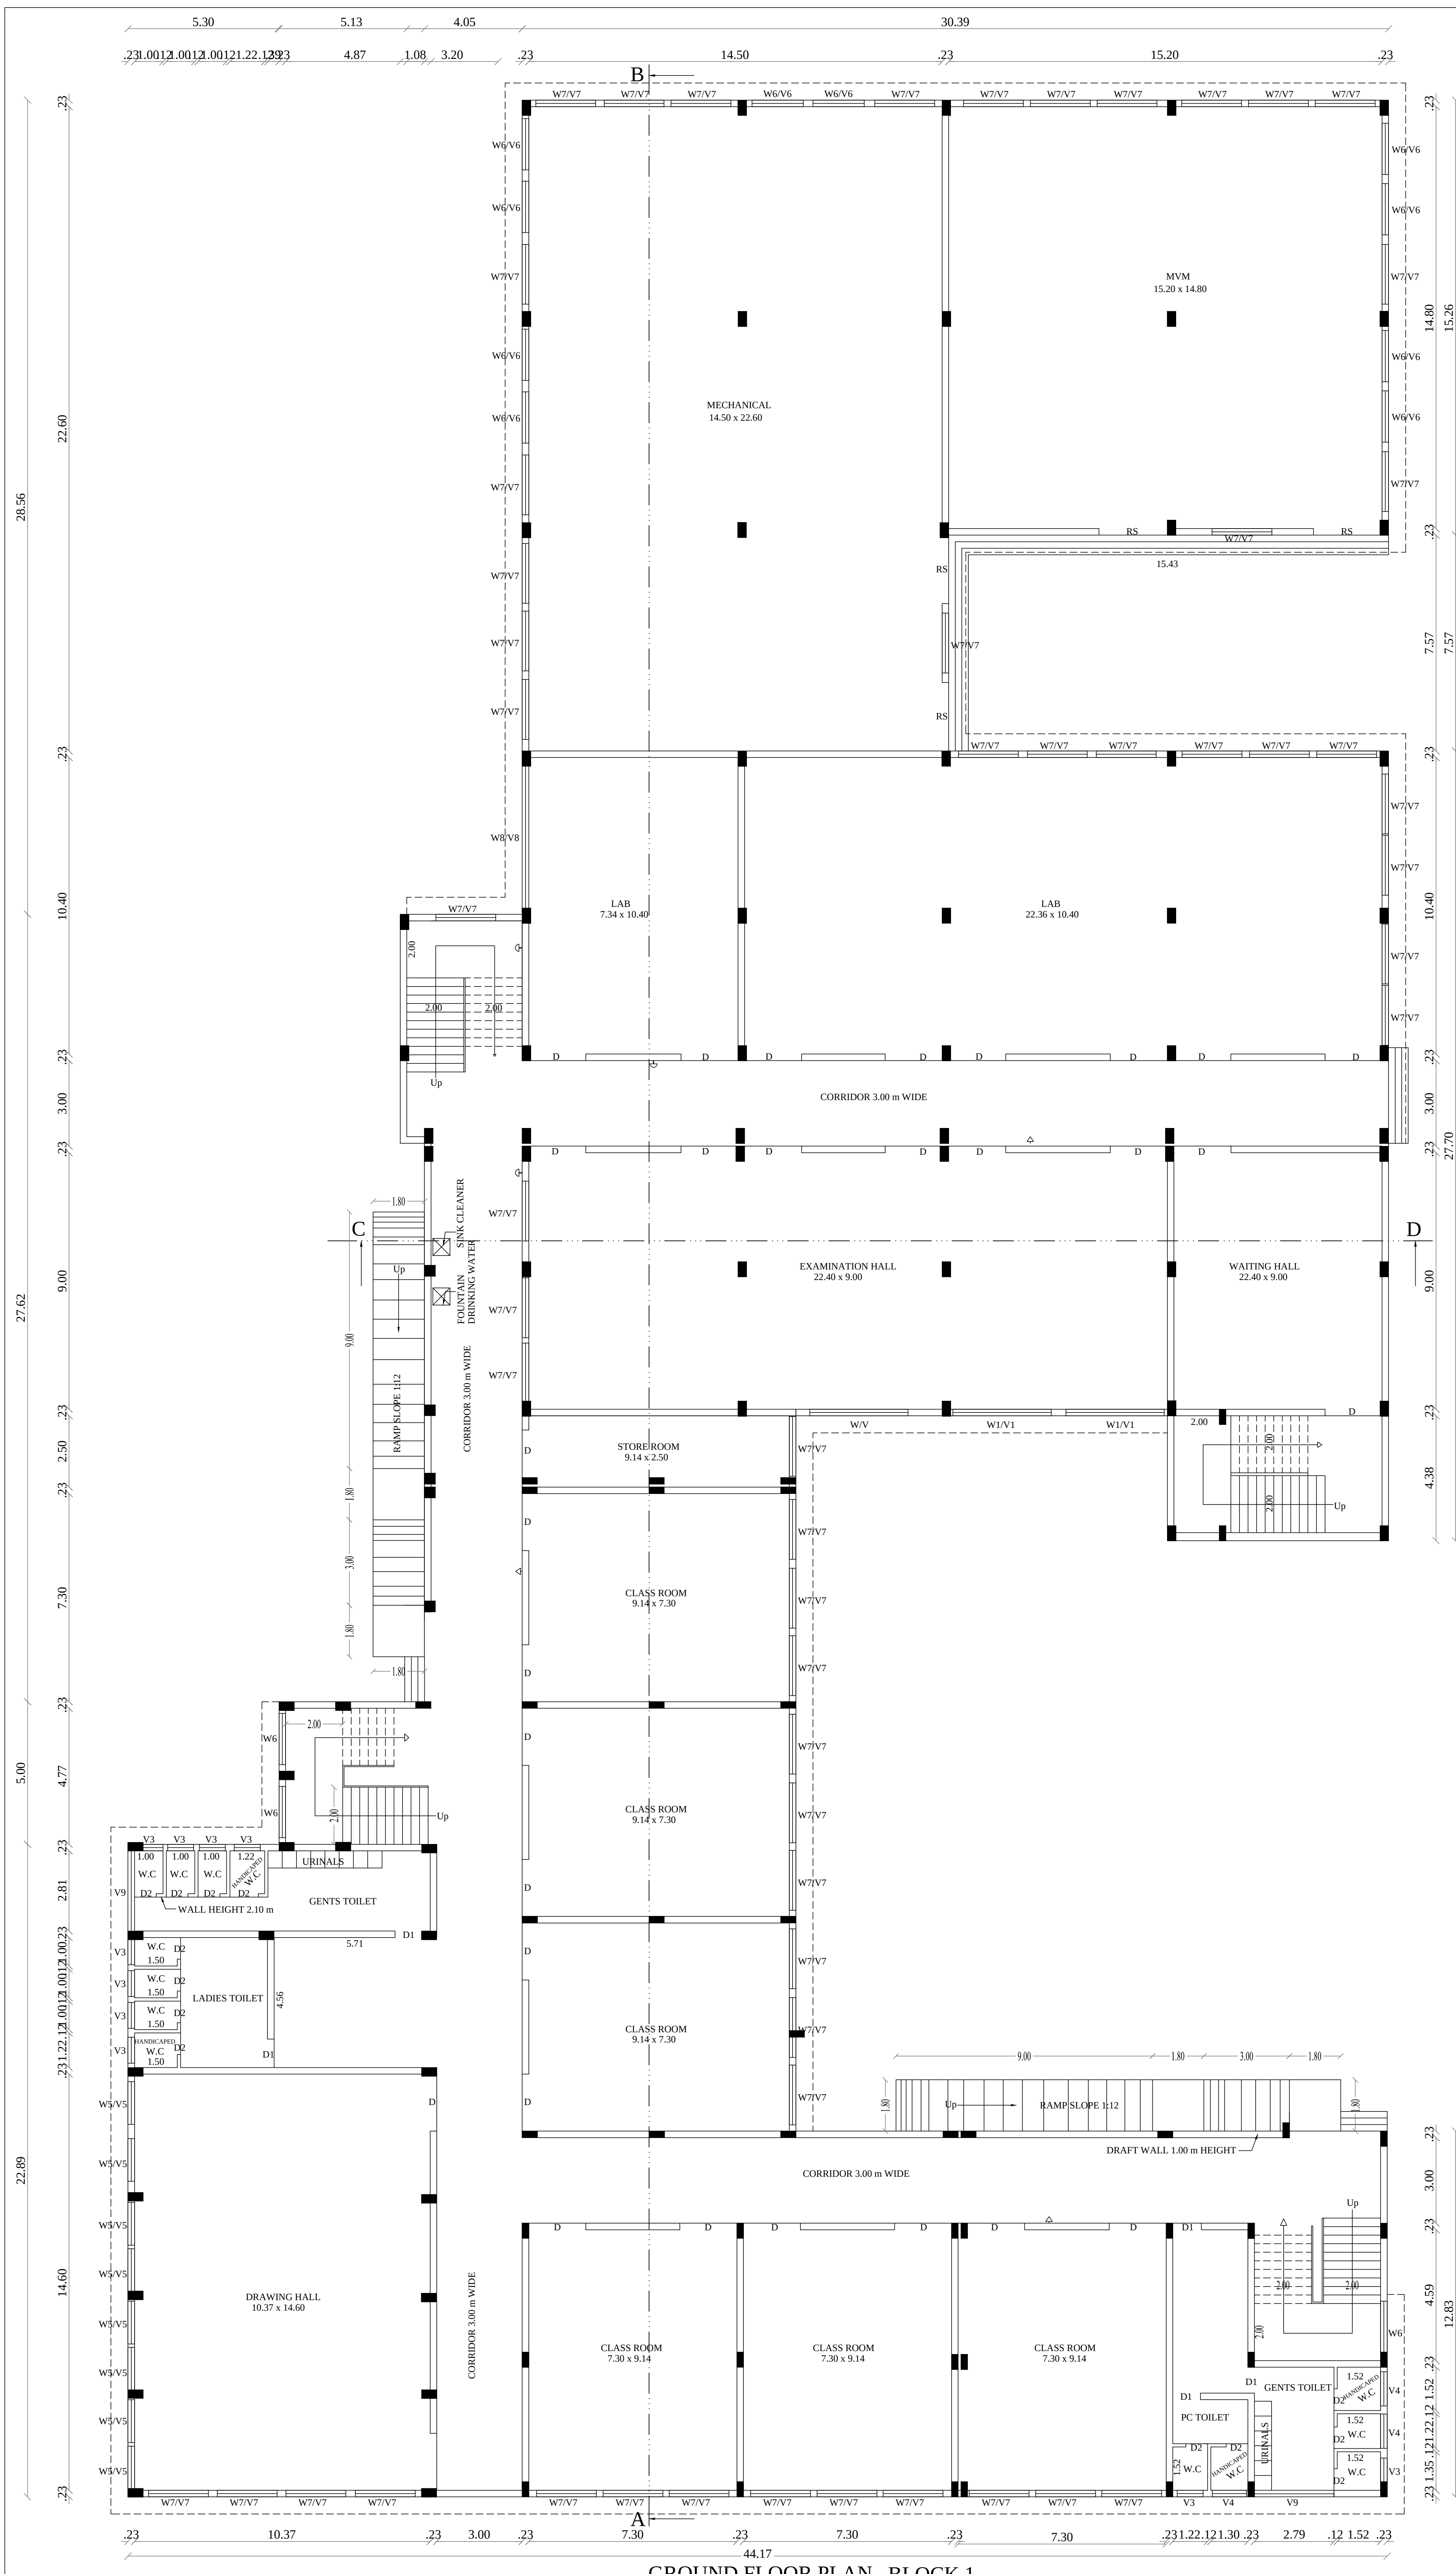

PLAN SHOWING THE PROPOSED CONSTRUCTION OF COLLEGE BUILDING FOR DAYALBAGH EDUCATIONAL INSTITUTE OFF CAMPUS IN S.NO:170/1A,170/1Cpart OF MELATHIRUVENGADANATHAPURAM VILLAGE AND PANCHAYAT, PALAYAMKOTTAI TALUK, TIRUNELVELI DISTRICT.

ALL DIMENSIONS ARE IN METER, SCALE 1:100 | SHEET NO: 4

APPLICANT NAME:
Mr.JEYARAM SINGH
DAYALBAGH EDUCATIONAL INSTITUTE OFF CAMPUS
MELA THIRUVENGADANATHAPURAM VILLAGE,
PALAYAMKOTTAI TALUK, TIRUNELVELI DISTRICT.

AREA DETAILS	F.S.I AREA Sq.mt	NON F.S.I AREA Sq.mt	TOTAL AREA Sq.mt
CLASS ROOM BLOCK			
BLOCK 1 AREA			
GROUND FLOOR	2410.58	---	2410.58
FIRST FLOOR	1833.59	---	1833.59
HEAD ROOM	---	131.11	131.11
TOTAL FLOOR	4244.17	131.11	4375.28

JOINERY DETAILS

D	Door	2.00 x 2.10
D1	Door	0.91 x 2.10
D2	Door	0.76 x 2.10
W4	Window	1.20 x 1.50
W5	Window	1.50 x 1.80
W6	Window	1.80 X 1.50
W7	Window	2.10 X 1.80
W8	Window	5.00 x 2.00
V3	Ventilator	0.90 X 0.60
V4	Ventilator	1.20 x 0.90
V5	Ventilator	1.50 x 1.08
V6	Ventilator	1.80 x 1.05
V7	Ventilator	2.10 x 1.08
V8	Ventilator	5.00 x 1.08
V9	Ventilator	2.80 x 1.08
RS	Rolling Shutter	2.00 x 2.10
W	Window	5.50 x 2.00
W1	Window	3.45 x 2.00
V	Ventilator	5.50 x 1.40
V7	Ventilator	3.45 x 1.40

SWP/BPA/011758/2023
B.P/DTCP No:417/2023

V.K. Ashok Kumaravel
V.K. Ashok Kumaravel, B.E., M.E., A.I.V., (P&C),
Civil & Structural Engineer
Registered Construction Engineer
Reg.No. RCE/TVL/January/2020/018

CONSTRUCTION ENGINEER

V.K. Ashok Kumaravel
V.K. Ashok Kumaravel, B.E., M.E., A.I.V., (P&C),
Civil & Structural Engineer
Registered Structural Engineer Grade I
Reg.No. RSE/Gr-I/TVL/January/2020/019


STRUCTURAL ENGINEER

for DAYALBAGH EDUCATIONAL INSTITUTE OFF CAMPUS
S. K. ANAND
CO-ORDINATOR

APPLICANT

Er. P. K. THAMEEMUL ANSARI B.E.
Reg. No. : RE/Gr II/TVL/March/2019/006
35 / 13-2, Firthous Complex, Ambai Road,
Melapalayam, (Sub-Registrar Office Building)
Tirunelveli - 627 005. Cell: 9488237454.

REG.ENGINEER

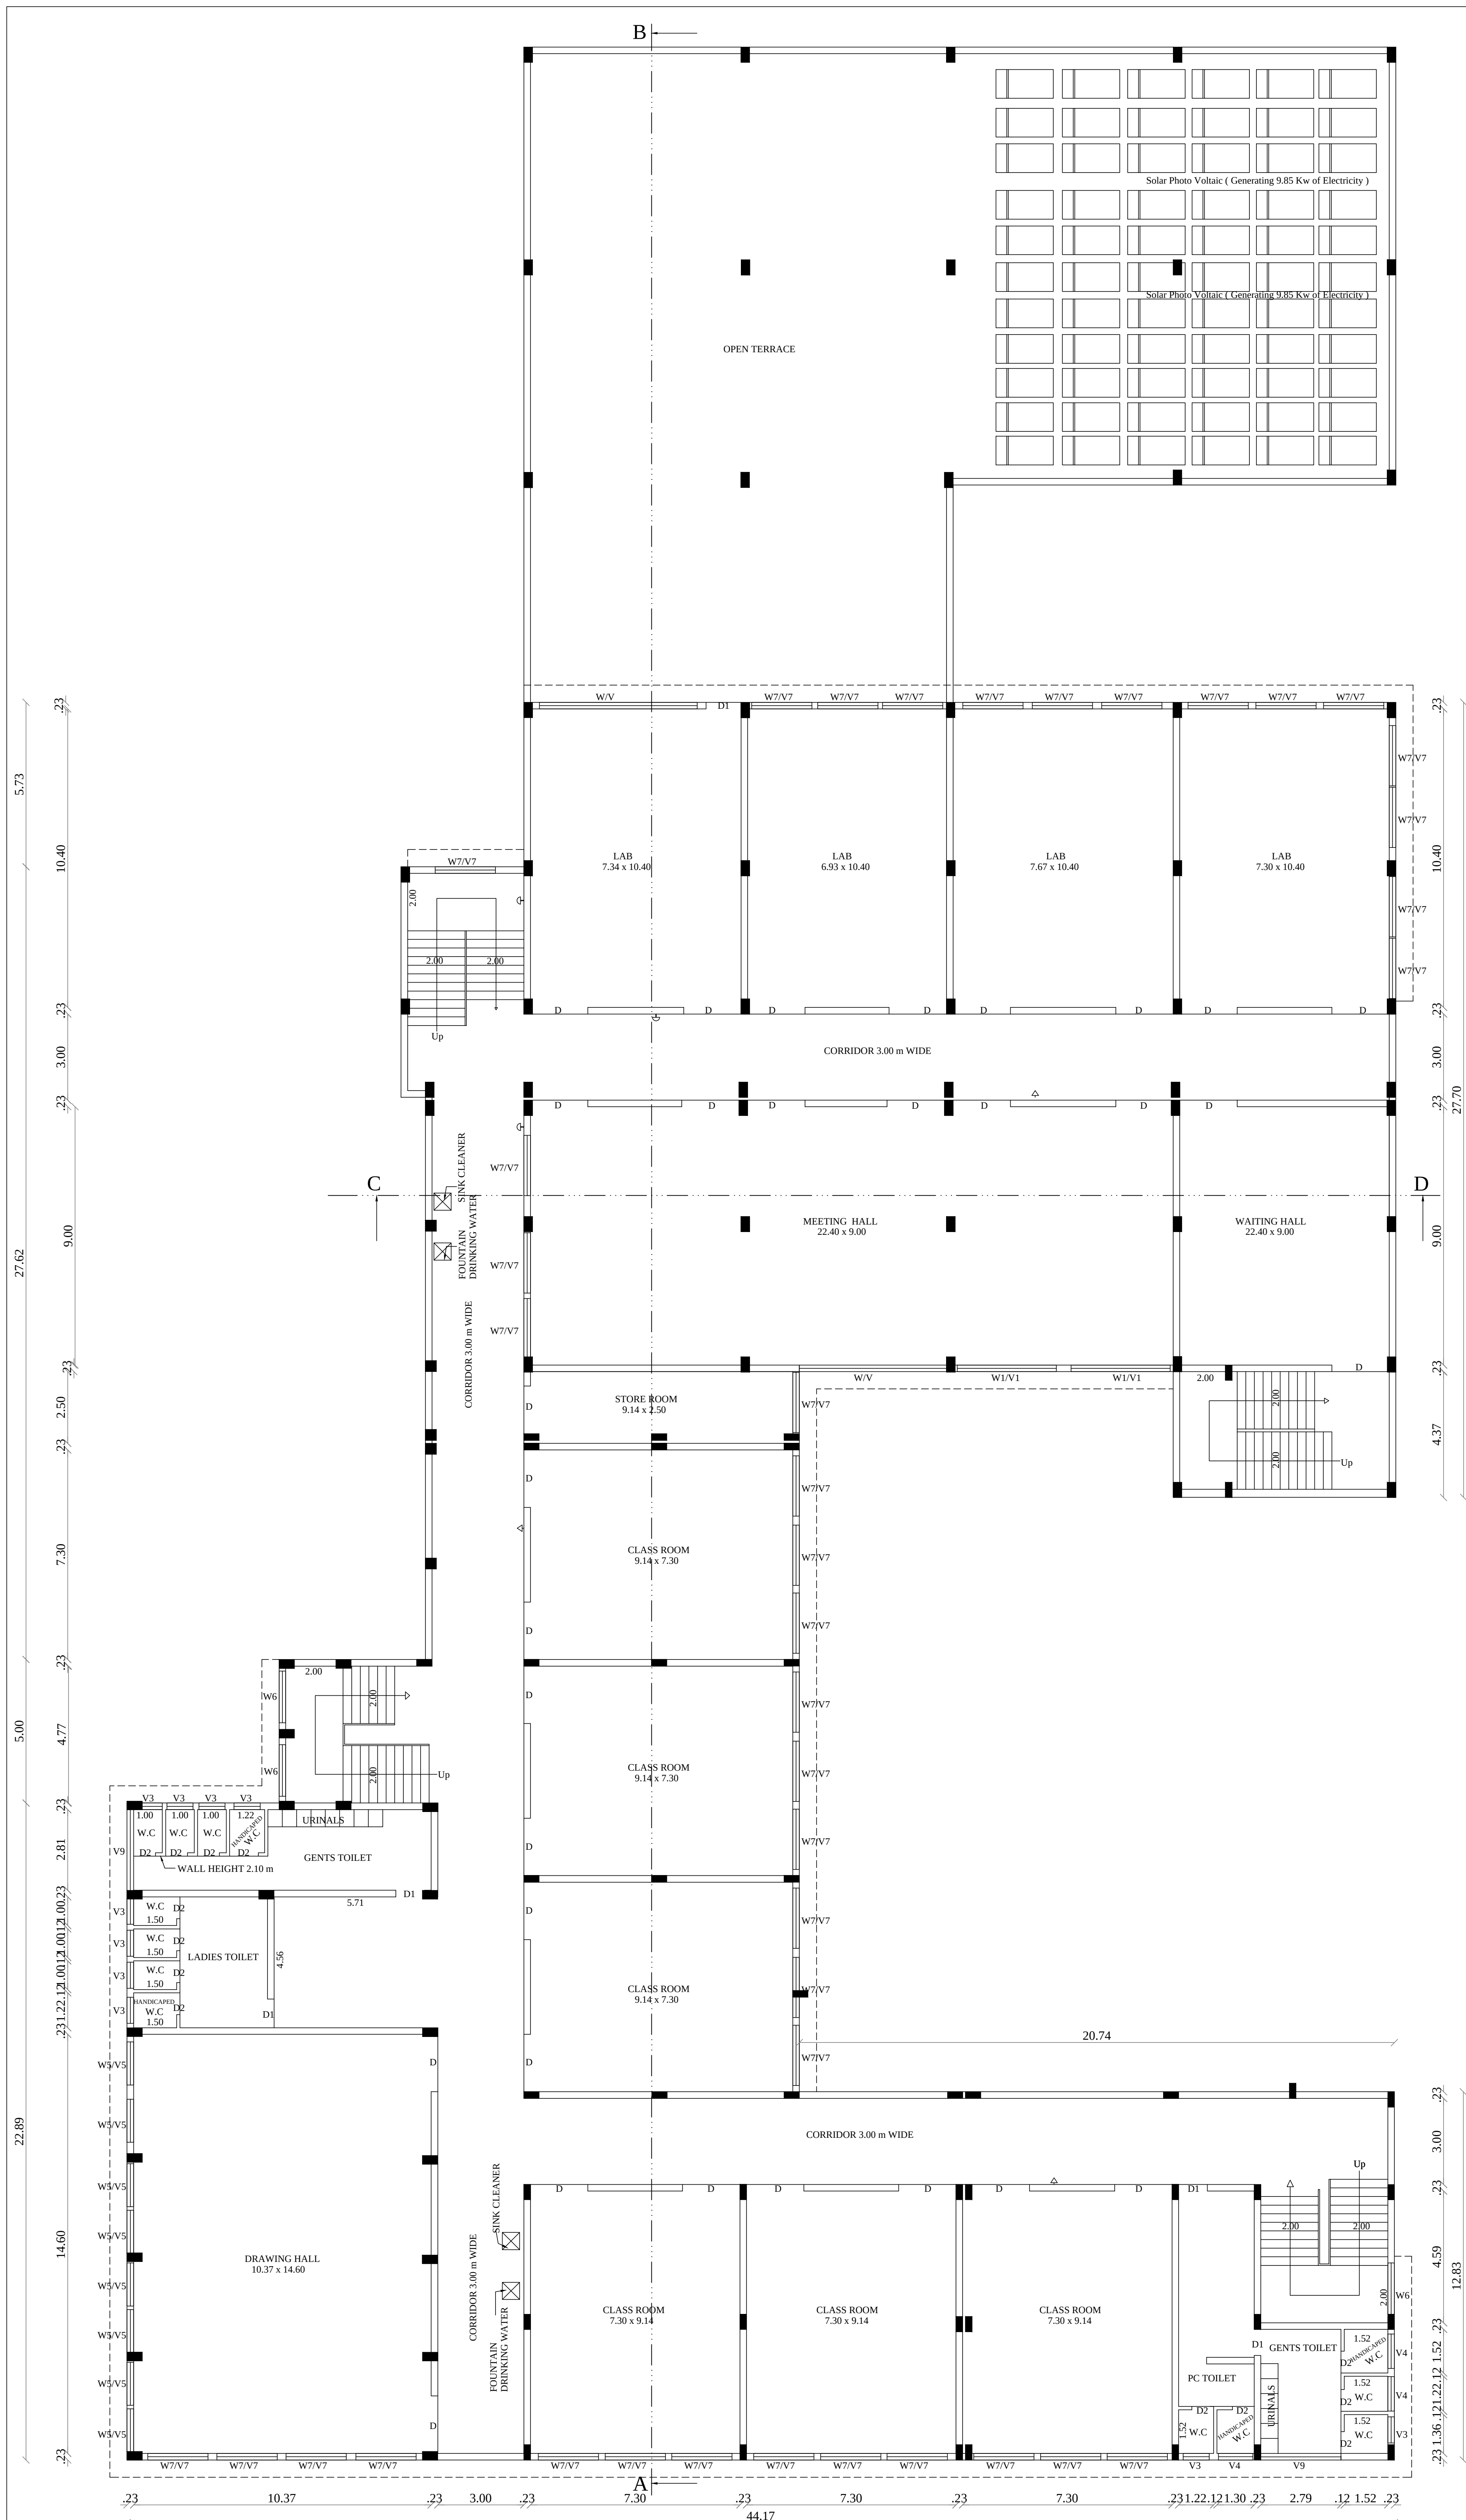

FIRST FLOOR PLAN BLOCK 1

PLAN SHOWING THE PROPOSED CONSTRUCTION OF COLLEGE BUILDING FOR DAYALBAGH EDUCATIONAL INSTITUTE OFF CAMPUS IN S.NO:170/1A,170/1Cpart OF MELATHIRUVENGADANATHAPURAM VILLAGE AND PANCHAYAT, PALAYAMKOTTAI TALUK, TIRUNELVELI DISTRICT.

ALL DIMENSIONS ARE IN METER, SCALE 1:100 SHEET NO: 5

APPLICANT NAME: Mr.JEYARAM SINGH DAYALBAGH EDUCATIONAL INSTITUTE OFF CAMPUS MELA THIRUVENGADANATHAPURAM VILLAGE, PALAYAMKOTTAI TALUK, TIRUNELVELI DISTRICT.

AREA DETAILS	F.S.I AREA Sq.mt	NON F.S.I AREA Sq.mt	TOTAL AREA Sq.mt
CLASS ROOM BLOCK BLOCK 1 AREA			
GROUND FLOOR	2410.58	---	2410.58
FIRST FLOOR	1833.59	---	1833.59
HEAD ROOM	---	131.11	131.11
TOTAL FLOOR	4244.17	131.11	4375.28

JOINERY DETAILS

D	Door	2.00 x 2.10
D1	Door	0.91 x 2.10
D2	Door	0.76 x 2.10
W4	Window	1.20 x 1.50
W5	Window	1.50 x 1.80
W6	Window	1.80 x 1.50
W7	Window	2.10 x 1.80
W8	Window	5.00 x 2.00
V3	Ventilator	0.90 x 0.60
V4	Ventilator	1.20 x 0.90
V5	Ventilator	1.50 x 1.08
V6	Ventilator	1.80 x 1.05
V7	Ventilator	2.10 x 1.08
V8	Ventilator	5.00 x 1.08
V9	Ventilator	2.80 x 1.08
RS	Rolling Shutter	2.00 x 2.10
W	Window	5.50 x 2.00
W1	Window	3.45 x 2.00
V	Ventilator	5.50 x 1.40
V7	Ventilator	3.45 x 1.40

SWP/BPA/011758/2023
B.P/DTCP No:417/2023

V.K. Ashok Kumaravel, B.E., M.E., A.I.Y. (Pw.),
Civil & Structural Engineer
Registered Construction Engineer
Reg.No. RCE/TVL/January/2020/018

CONSTRUCTION ENGINEER

V.K. Ashok Kumaravel, B.E., M.E., A.I.Y. (Pw.),
Civil & Structural Engineer
Registered Structural Engineer Grade I
Reg.No. RSE/Gr-I/TVL/January/2020/019

STRUCTURAL ENGINEER

For DAYALBAGH EDUCATIONAL INSTITUTE OFF CAMPUS
CO-ORDINATOR

APPLICANT

Er. P. K. THAMEEMUL ANSARI B.E.
Reg. No. : RE/Gr II/TVL/ March/2019/006
35 / 13-2, Firthous Complex, Ambai Road,
Melapalayam, (Sub-Registrar Office Building)
Tirunelveli - 627 005. Cell : 9488237454.

REG.ENGINEER

PLAN SHOWING THE PROPOSED CONSTRUCTION OF COLLEGE BUILDING FOR DAYALBAGH EDUCATIONAL INSTITUTE OFF CAMPUS IN S.NO:170/1A,170/1Cpart OF MELATHIRUVENGADANATHAPURAM VILLAGE AND PANCHAYAT, PALAYAMKOTTAI TALUK, TIRUNELVELI DISTRICT.

ALL DIMENSIONS ARE IN METER, SCALE 1:100 | SHEET NO: 6

APPLICANT NAME:
Mr.JEYARAM SINGH
DAYALBAGH EDUCATIONAL INSTITUTE OFF CAMPUS
MELA THIRUVENGADANATHAPURAM VILLAGE,
PALAYAMKOTTAI TALUK, TIRUNELVELI DISTRICT.

AREA DETAILS	F.S.I AREA Sq.mt	NON F.S.I AREA Sq.mt	TOTAL AREA Sq.mt
CLASS ROOM BLOCK			
BLOCK 1 AREA			
GROUND FLOOR	2410.58	---	2410.58
FIRST FLOOR	1833.59	---	1833.59
HEAD ROOM	---	131.11	131.11
TOTAL FLOOR	4244.17	131.11	4375.28

JOINERY DETAILS

D	Door	2.00 x 2.10
D1	Door	0.91 x 2.10
D2	Door	0.76 x 2.10
W4	Window	1.20 x 1.50
W5	Window	1.50 x 1.80
W6	Window	1.80 X 1.50
W7	Window	2.10 X 1.80
W8	Window	5.00 x 2.00
V3	Ventilator	0.90 X 0.60
V4	Ventilator	1.20 x 0.90
V5	Ventilator	1.50 x 1.08
V6	Ventilator	1.80 x 1.05
V7	Ventilator	2.10 x 1.08
V8	Ventilator	5.00 x 1.08
V9	Ventilator	2.80 x 1.08
RS	Rolling Shutter	2.00 x 2.10
W	Window	5.50 x 2.00
W1	Window	3.45 x 2.00
V	Ventilator	5.50 x 1.40
V7	Ventilator	3.45 x 1.40

SWP/BPA/011758/2023
B.P/DTCP No:417/2023

V.K. Ashok Kumaravel, B.E., M.E., A.I.V., (P.W.),
Civil & Structural Engineer
Registered Construction Engineer
Reg.No. RCE/TVL/January/2020/018

CONSTRUCTION ENGINEER

V.K. Ashok Kumaravel, B.E., M.E., A.I.V., (P.W.),
Civil & Structural Engineer
Registered Structural Engineer Grade I
Reg.No. RSE/Gr-I/TVL/January/2020/019


STRUCTURAL ENGINEER

for DAYALBAGH EDUCATIONAL INSTITUTE OFF CAMPUS
CO-ORDINATOR

APPLICANT

Er. P. K. THAMEEMUL ANSARI B.E.
Reg. No. : RE/Gr-II/TVL/March/2019/006
35 / 13-2, Firthous Complex, Ambai Road,
Melapalayam, (Sub-Registrar Office Building)
Tirunelveli - 627 005. Cell : 9488237454.


REG.ENGINEER

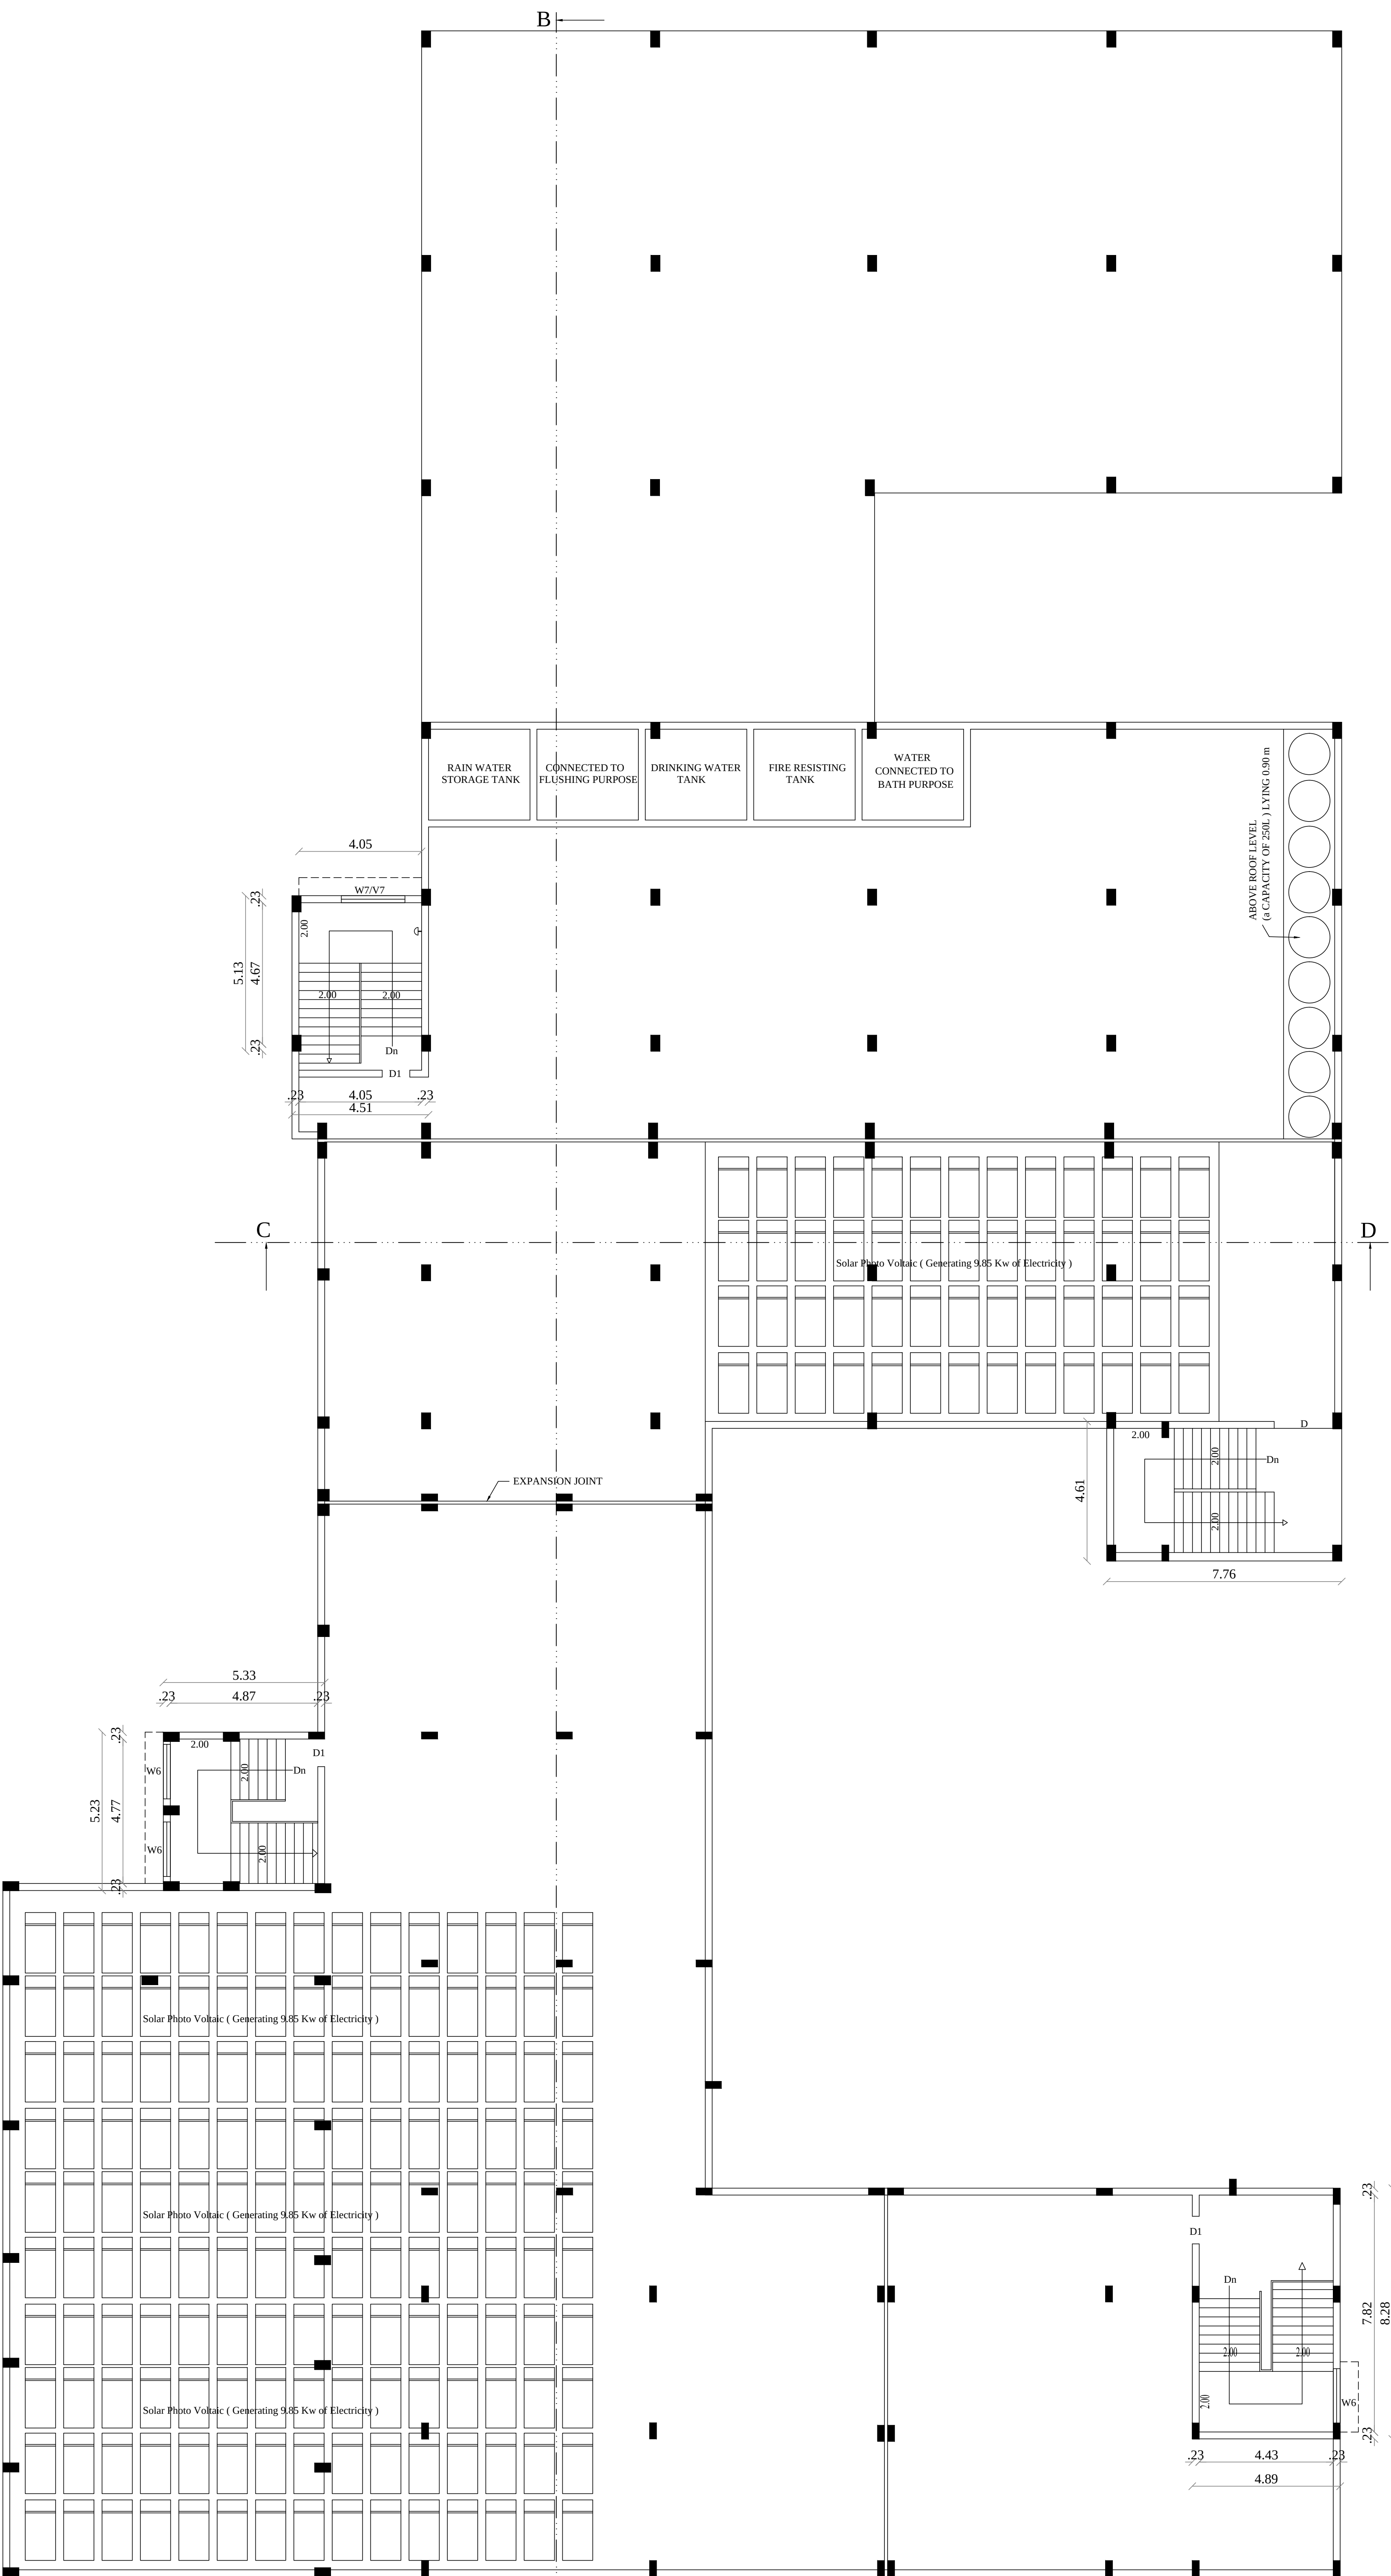


HEAD FLOOR PLAN BLOCK 1



REG.ENGINEER

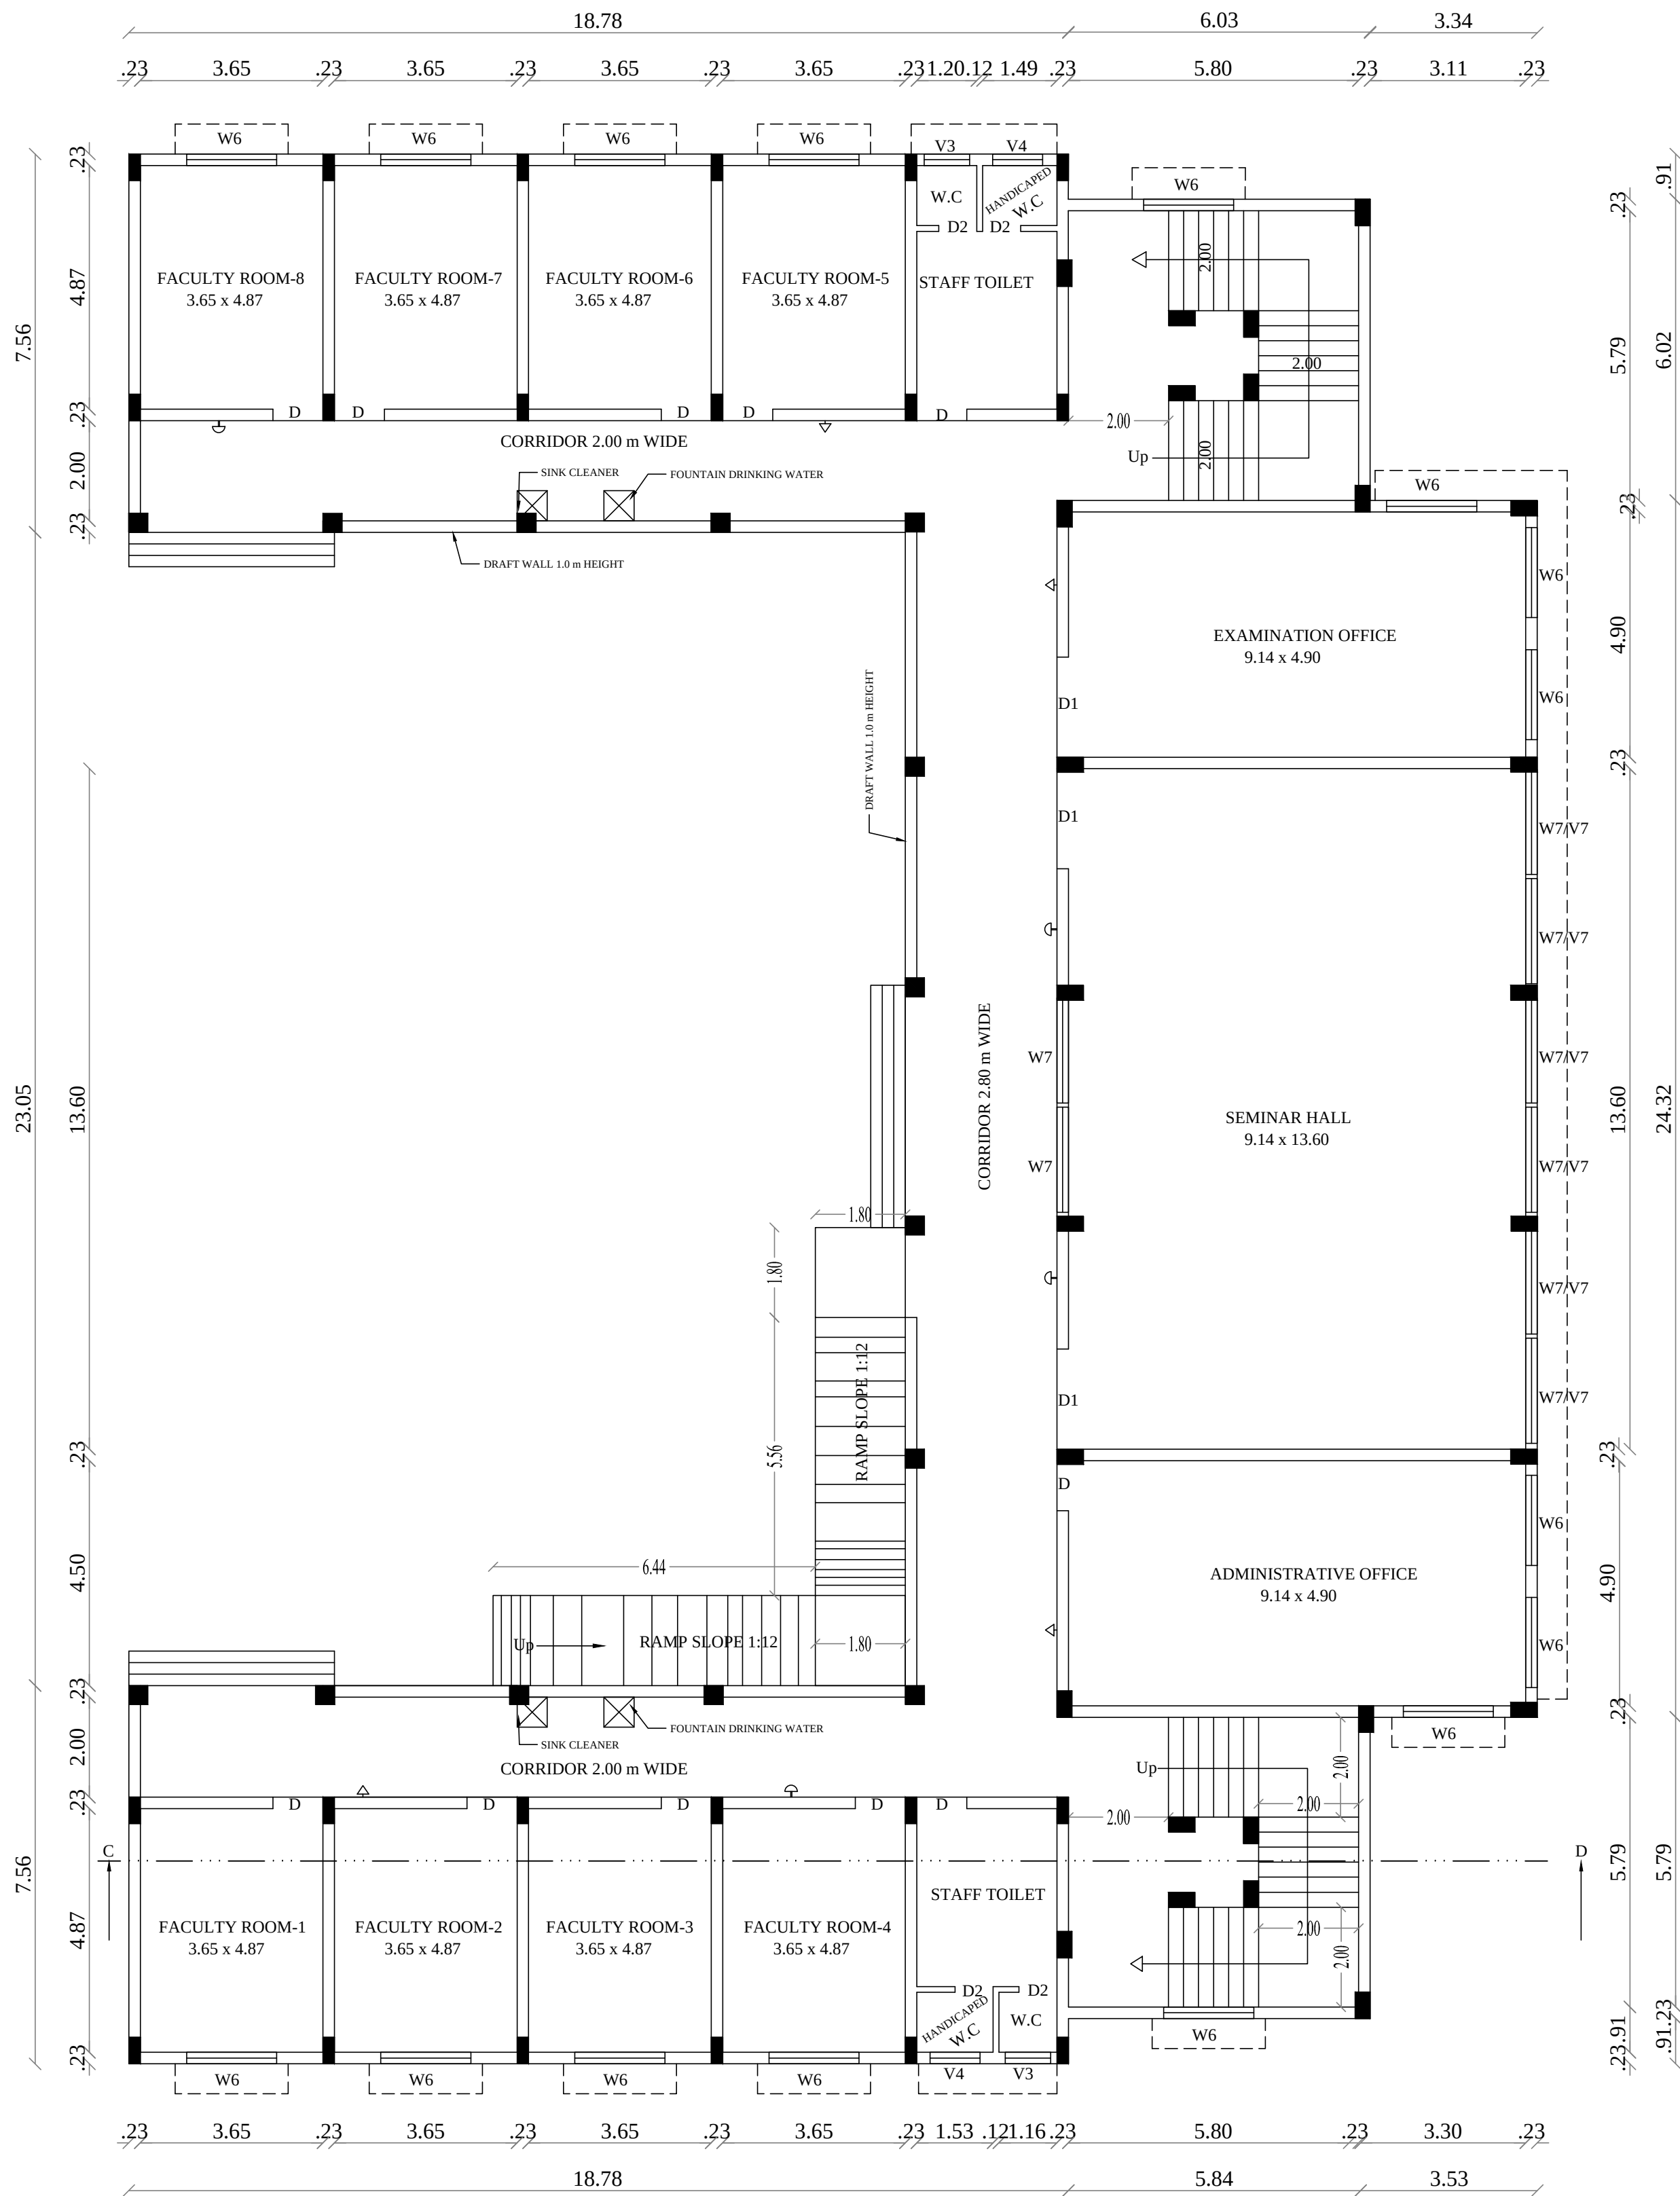

BLOCK 2 GROUND FLOOR PLAN

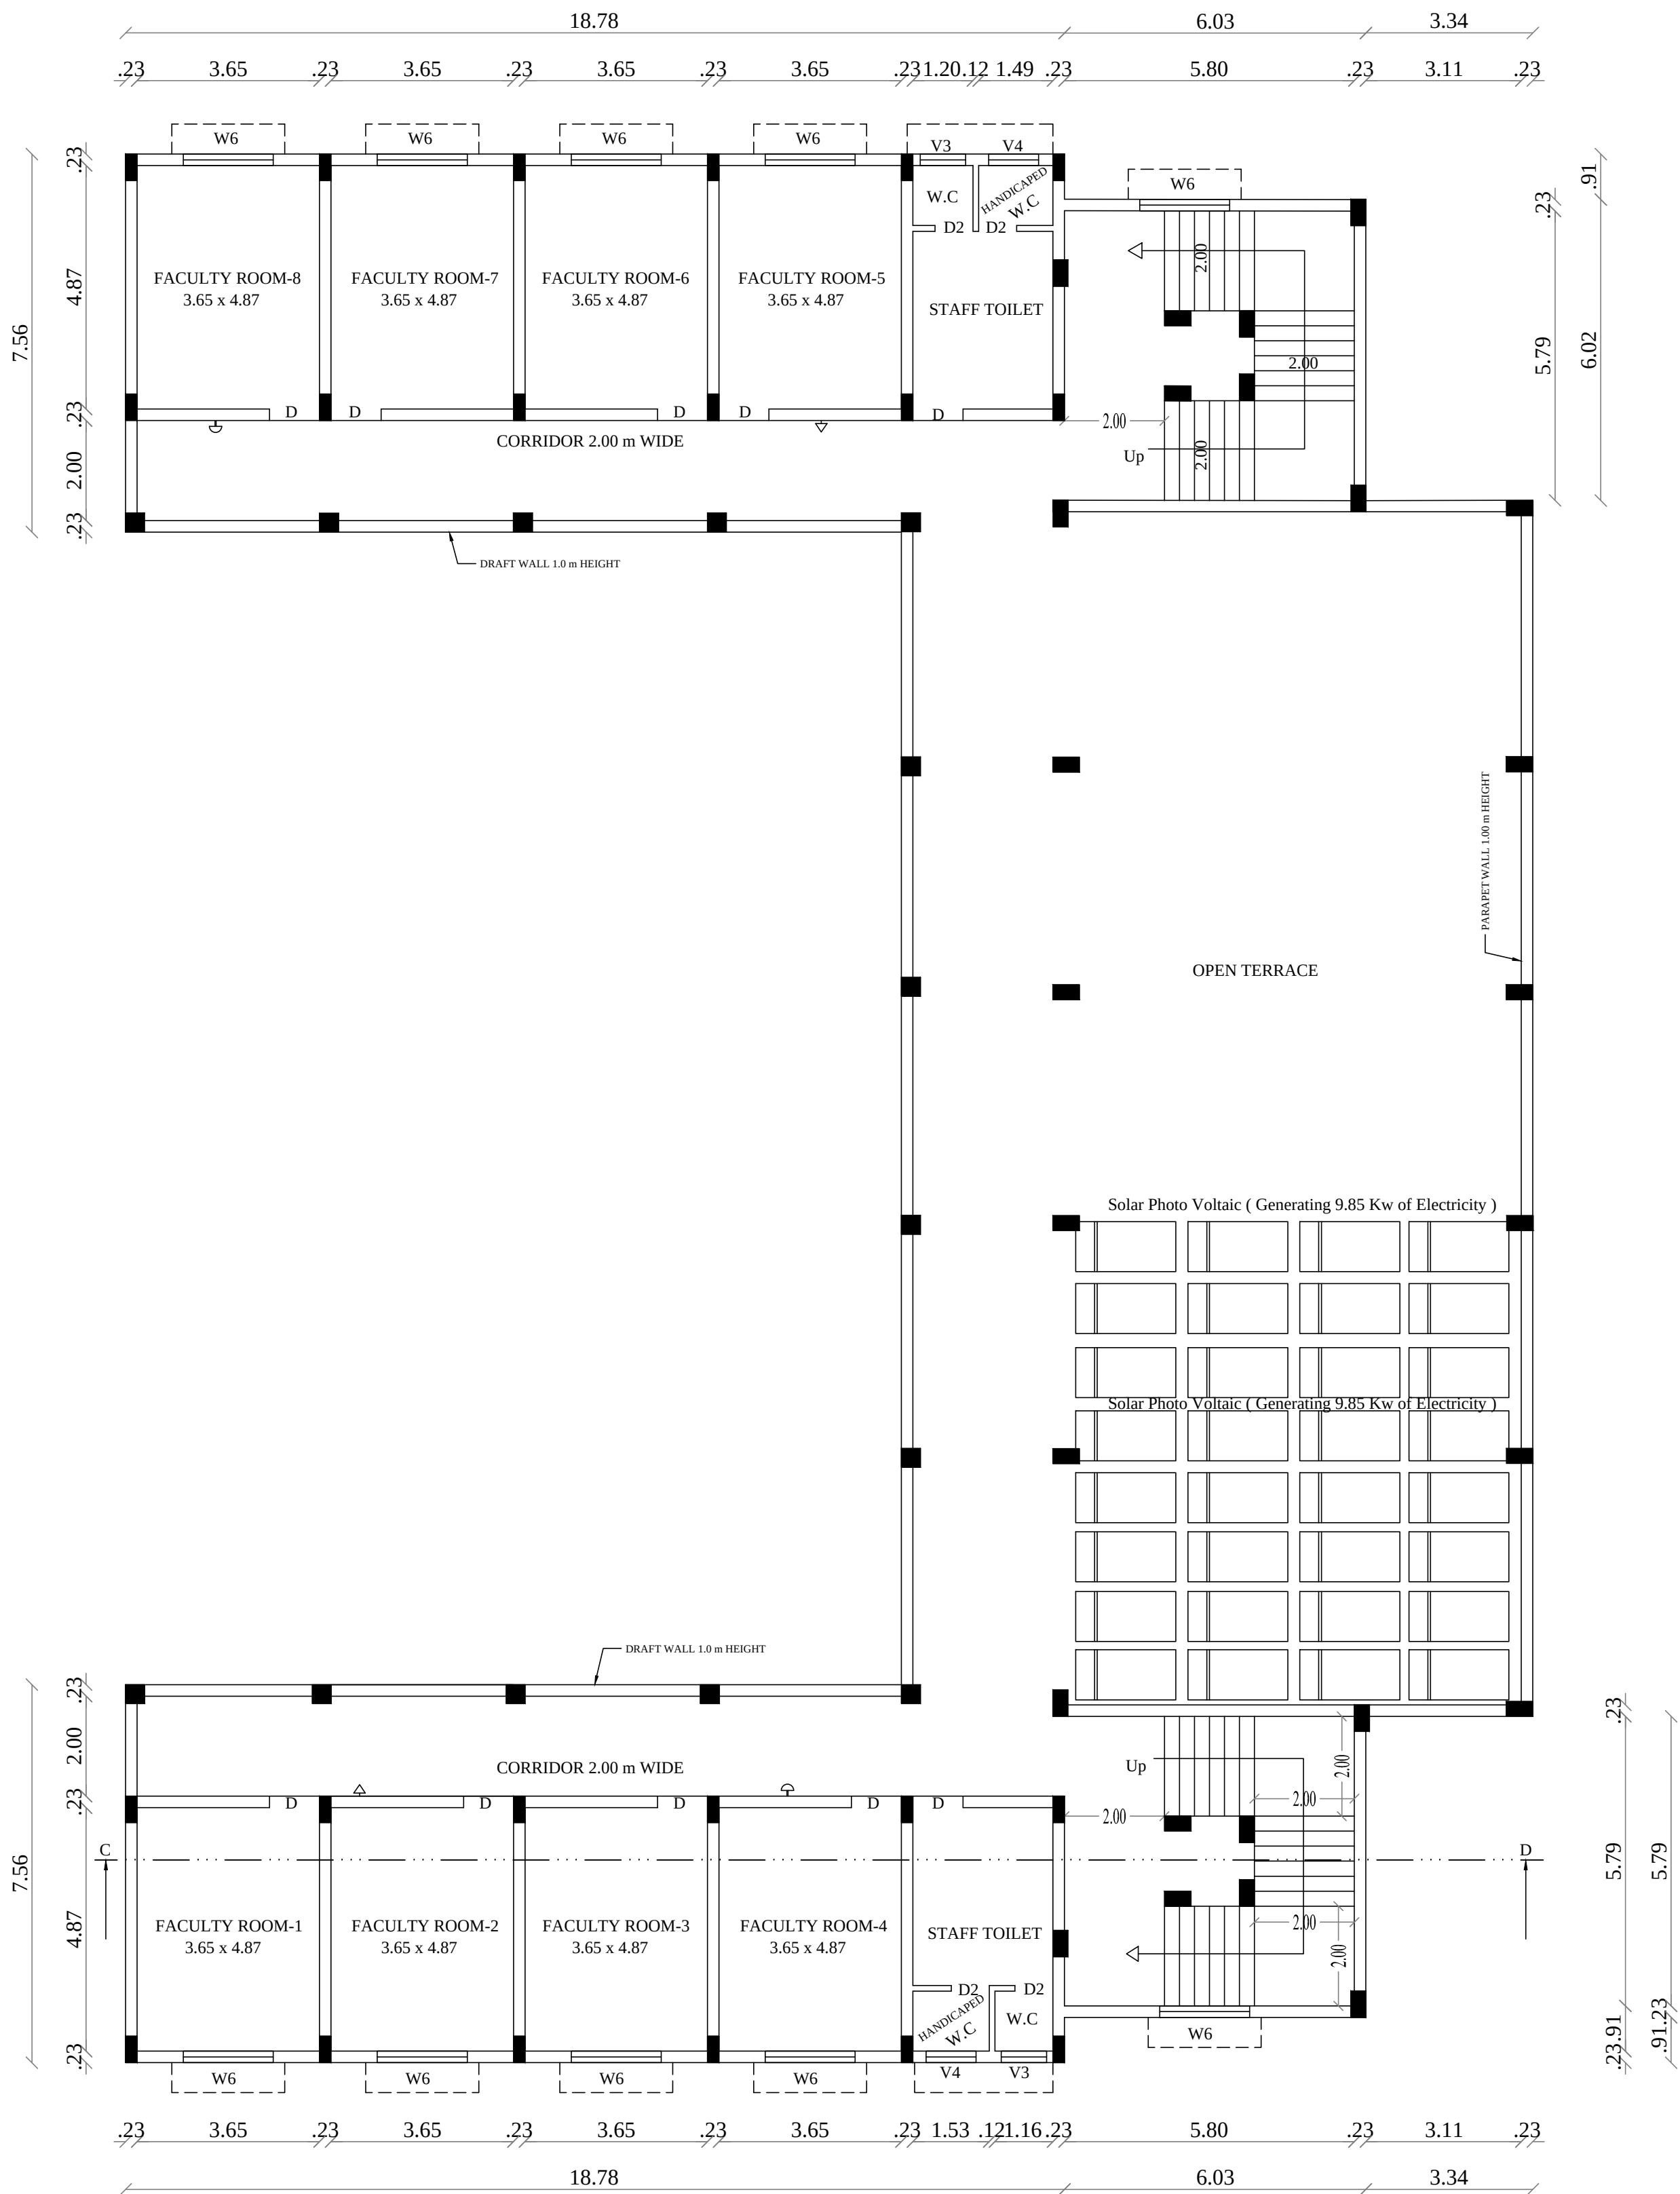

BLOCK 2 FIRST FLOOR PLAN

PLAN SHOWING THE PROPOSED
CONSTRUCTION OF COLLEGE BUILDING FOR
DAYALBAGH EDUCATIONAL INSTITUTE OFF
CAMPUS IN S.NO:170/1A,170/1Cpart OF
MELATHIRUVENGADANATHAPURAM VILLAGE
AND PANCHAYAT, PALAYAMKOTTAI TALUK,
TIRUNELVELI DISTRICT.

ALL DIMENSIONS ARE IN METER, SCALE 1:100 SHEET NO: 8

APPLICANT NAME:
Mr.JEYARAM SINGH
DAYALBAGH EDUCATIONAL INSTITUTE OFF CAMPUS
MELA THIRUVENGADANATHAPURAM VILLAGE,
PALAYAMKOTTAI TALUK, TIRUNELVELI DISTRICT.

AREA DETAILS	F.S.I AREA Sq.mt	NON F.S.I AREA Sq.mt	TOTAL AREA Sq.mt
(ADMINISTRATIVE BLOCK) BLOCK 2 AREA GROUND FLOOR	659.57	---	659.57
FIRST FLOOR	359.12	---	359.12
HEAD ROOM	---	78.24	131.11
TOTAL FLOOR	1018.69	78.24	1096.93

JOINERY DETAILS

D	Door	1.00 x 2.10
D1	Door	2.00 x 2.10
D2	Door	0.76 x 2.10
W6	Window	1.80 x 1.50
W7	Window	2.10 x 1.80
V3	Ventilator	0.90 x 0.60
V4	Ventilator	1.20 x 0.90
V7	Ventilator	2.00 x 2.10

SWP/BPA/011758/2023
B.P/DTCP No:417/2023

V.K. Ashok Kumaravel, B.E., M.E., A.I.V., (P.W.D.),
Civil & Structural Engineer
Registered Construction Engineer
Reg.No. RCE/TVL/January/2020/018

CONSTRUCTION ENGINEER

V.K. Ashok Kumaravel, B.E., M.E., A.I.V., (P.W.D.),
Civil & Structural Engineer
Registered Structural Engineer Grade I
Reg.No. RSE/Gr-TVL/January/2020/019





STRUCTURAL ENGINEER

for DAYALBAGH EDUCATIONAL INSTITUTE OFF CAMPUS
CO-ORDINATOR

APPLICANT

Er. P. K. THAMEEMUL ANSARI B.E.
Reg. No. : RE/Gr II/TVL/March/2019/006
35 / 13-2, Firthous Complex, Ambai Road,
Melapalayam, (Sub-Registrar Office Building)
Tirunelveli - 627 005. Cell : 9488237454.

REG.ENGINEER

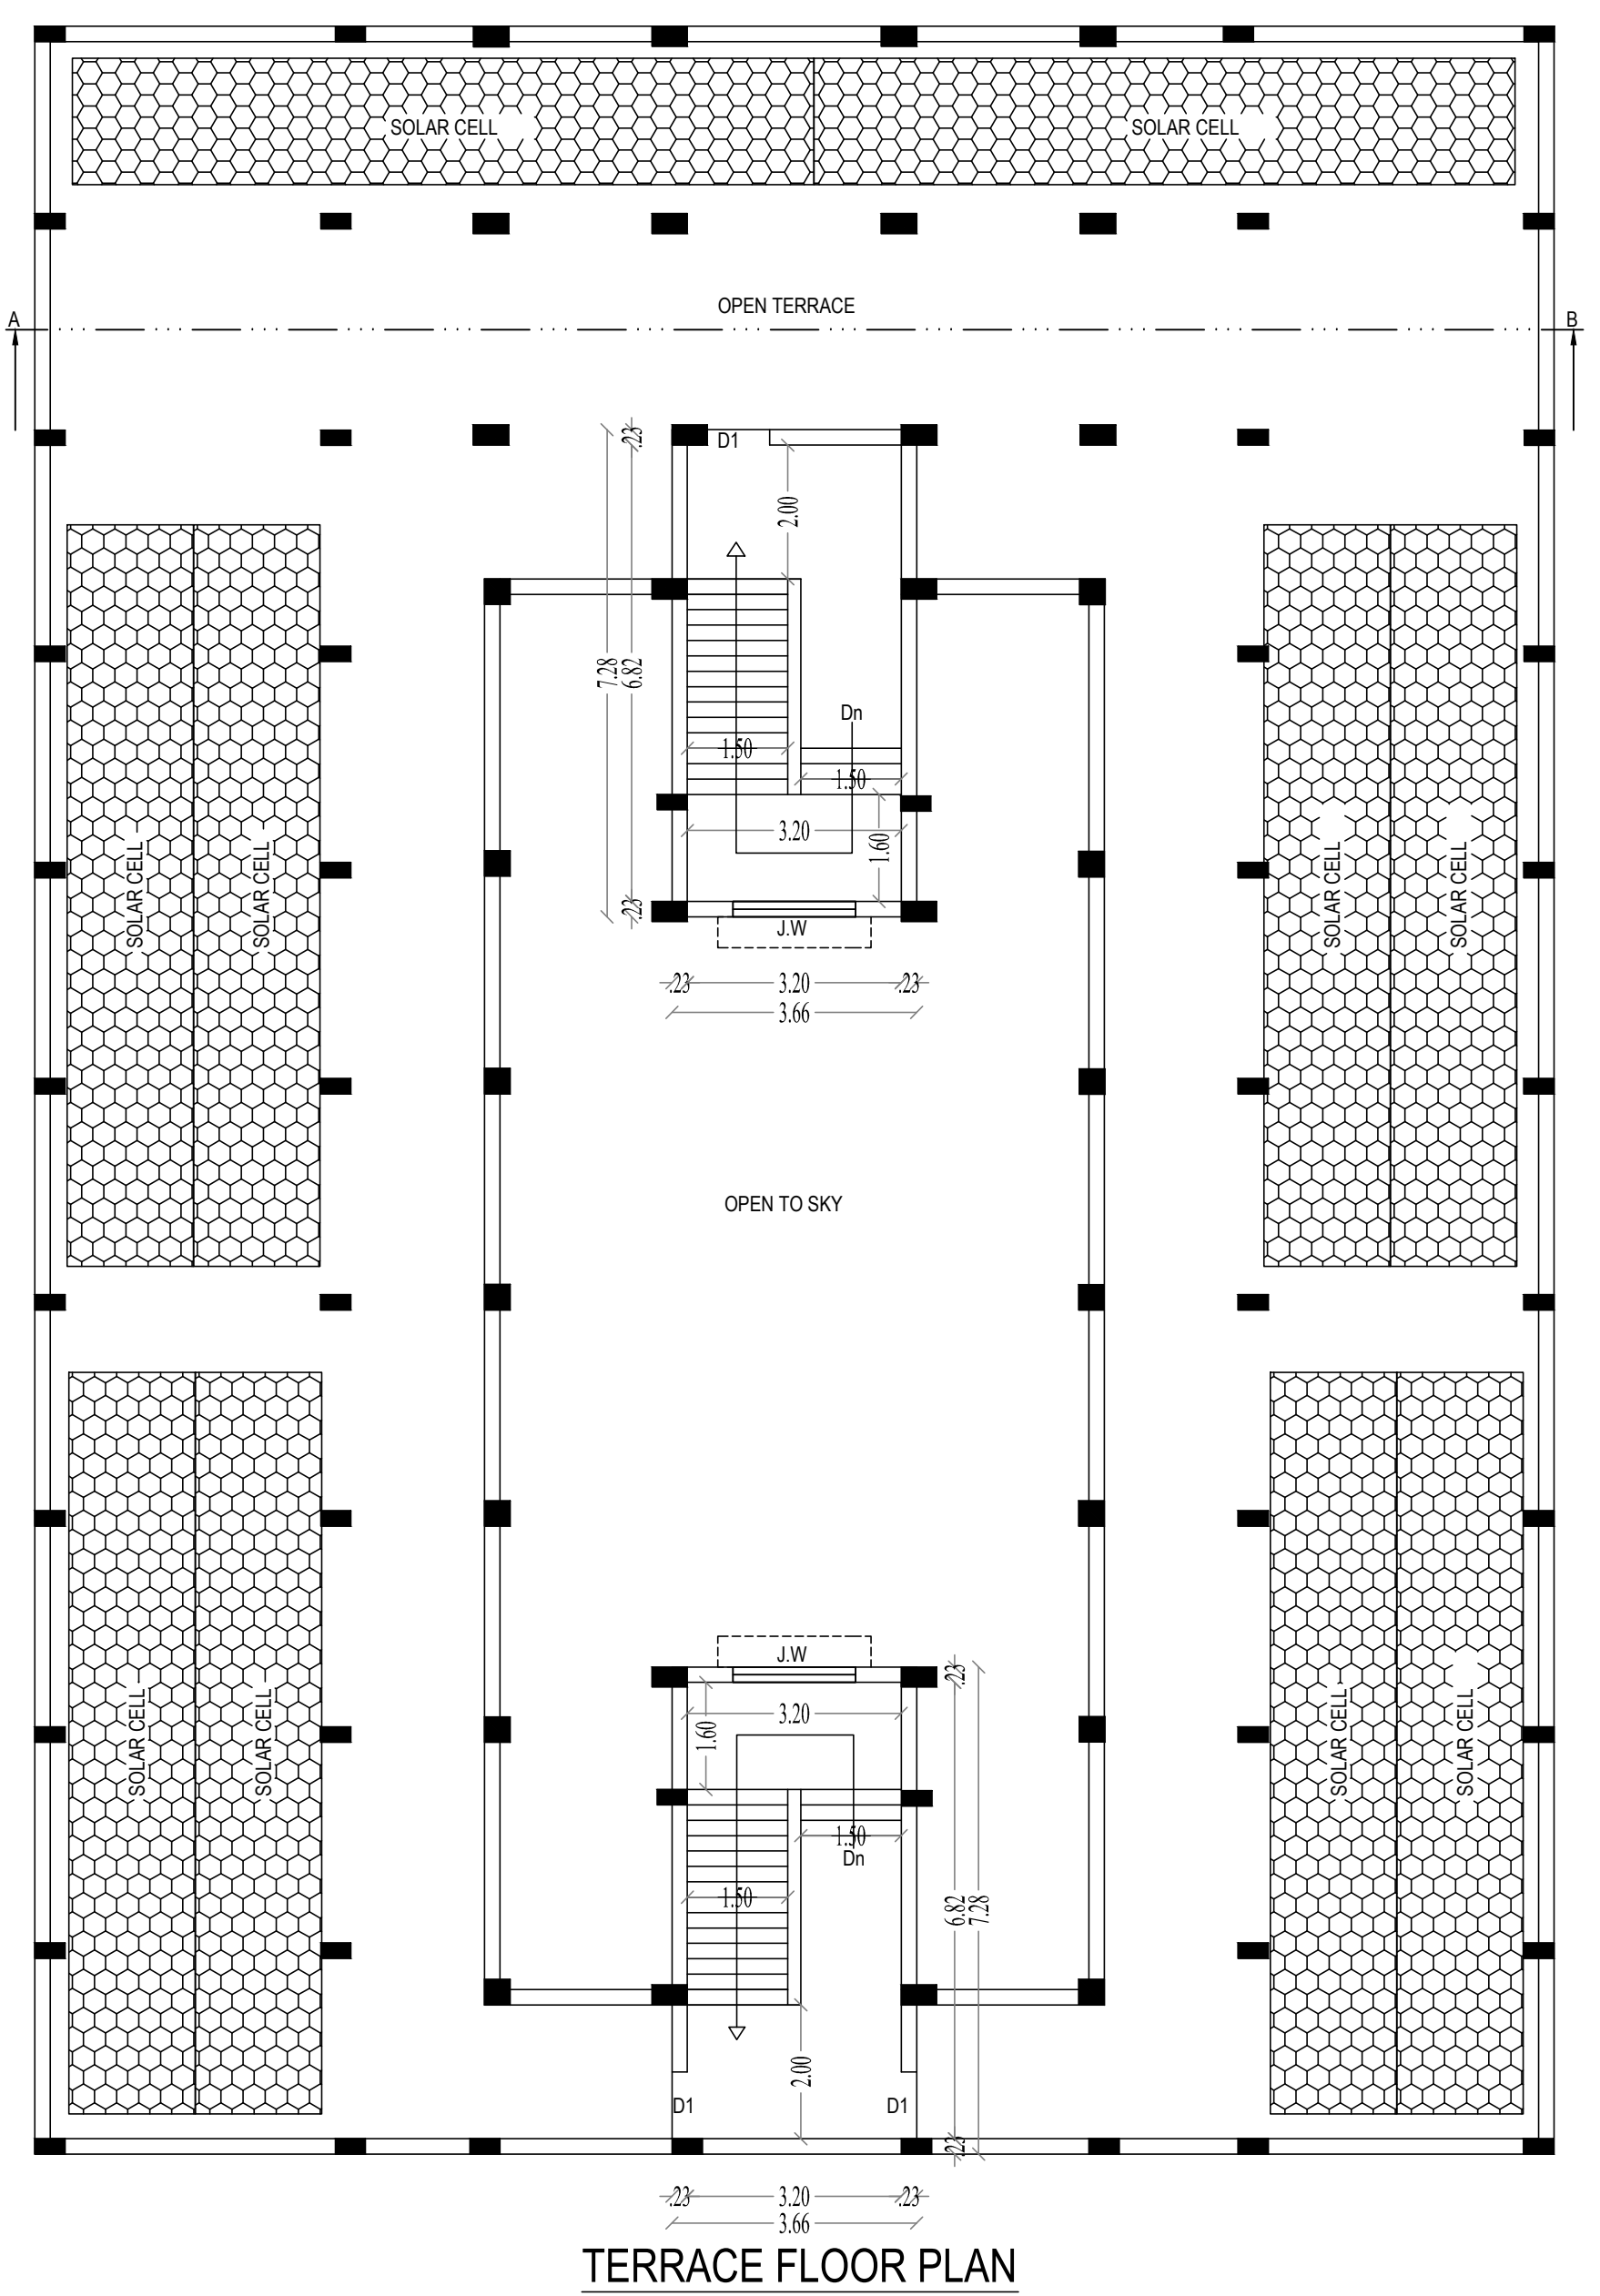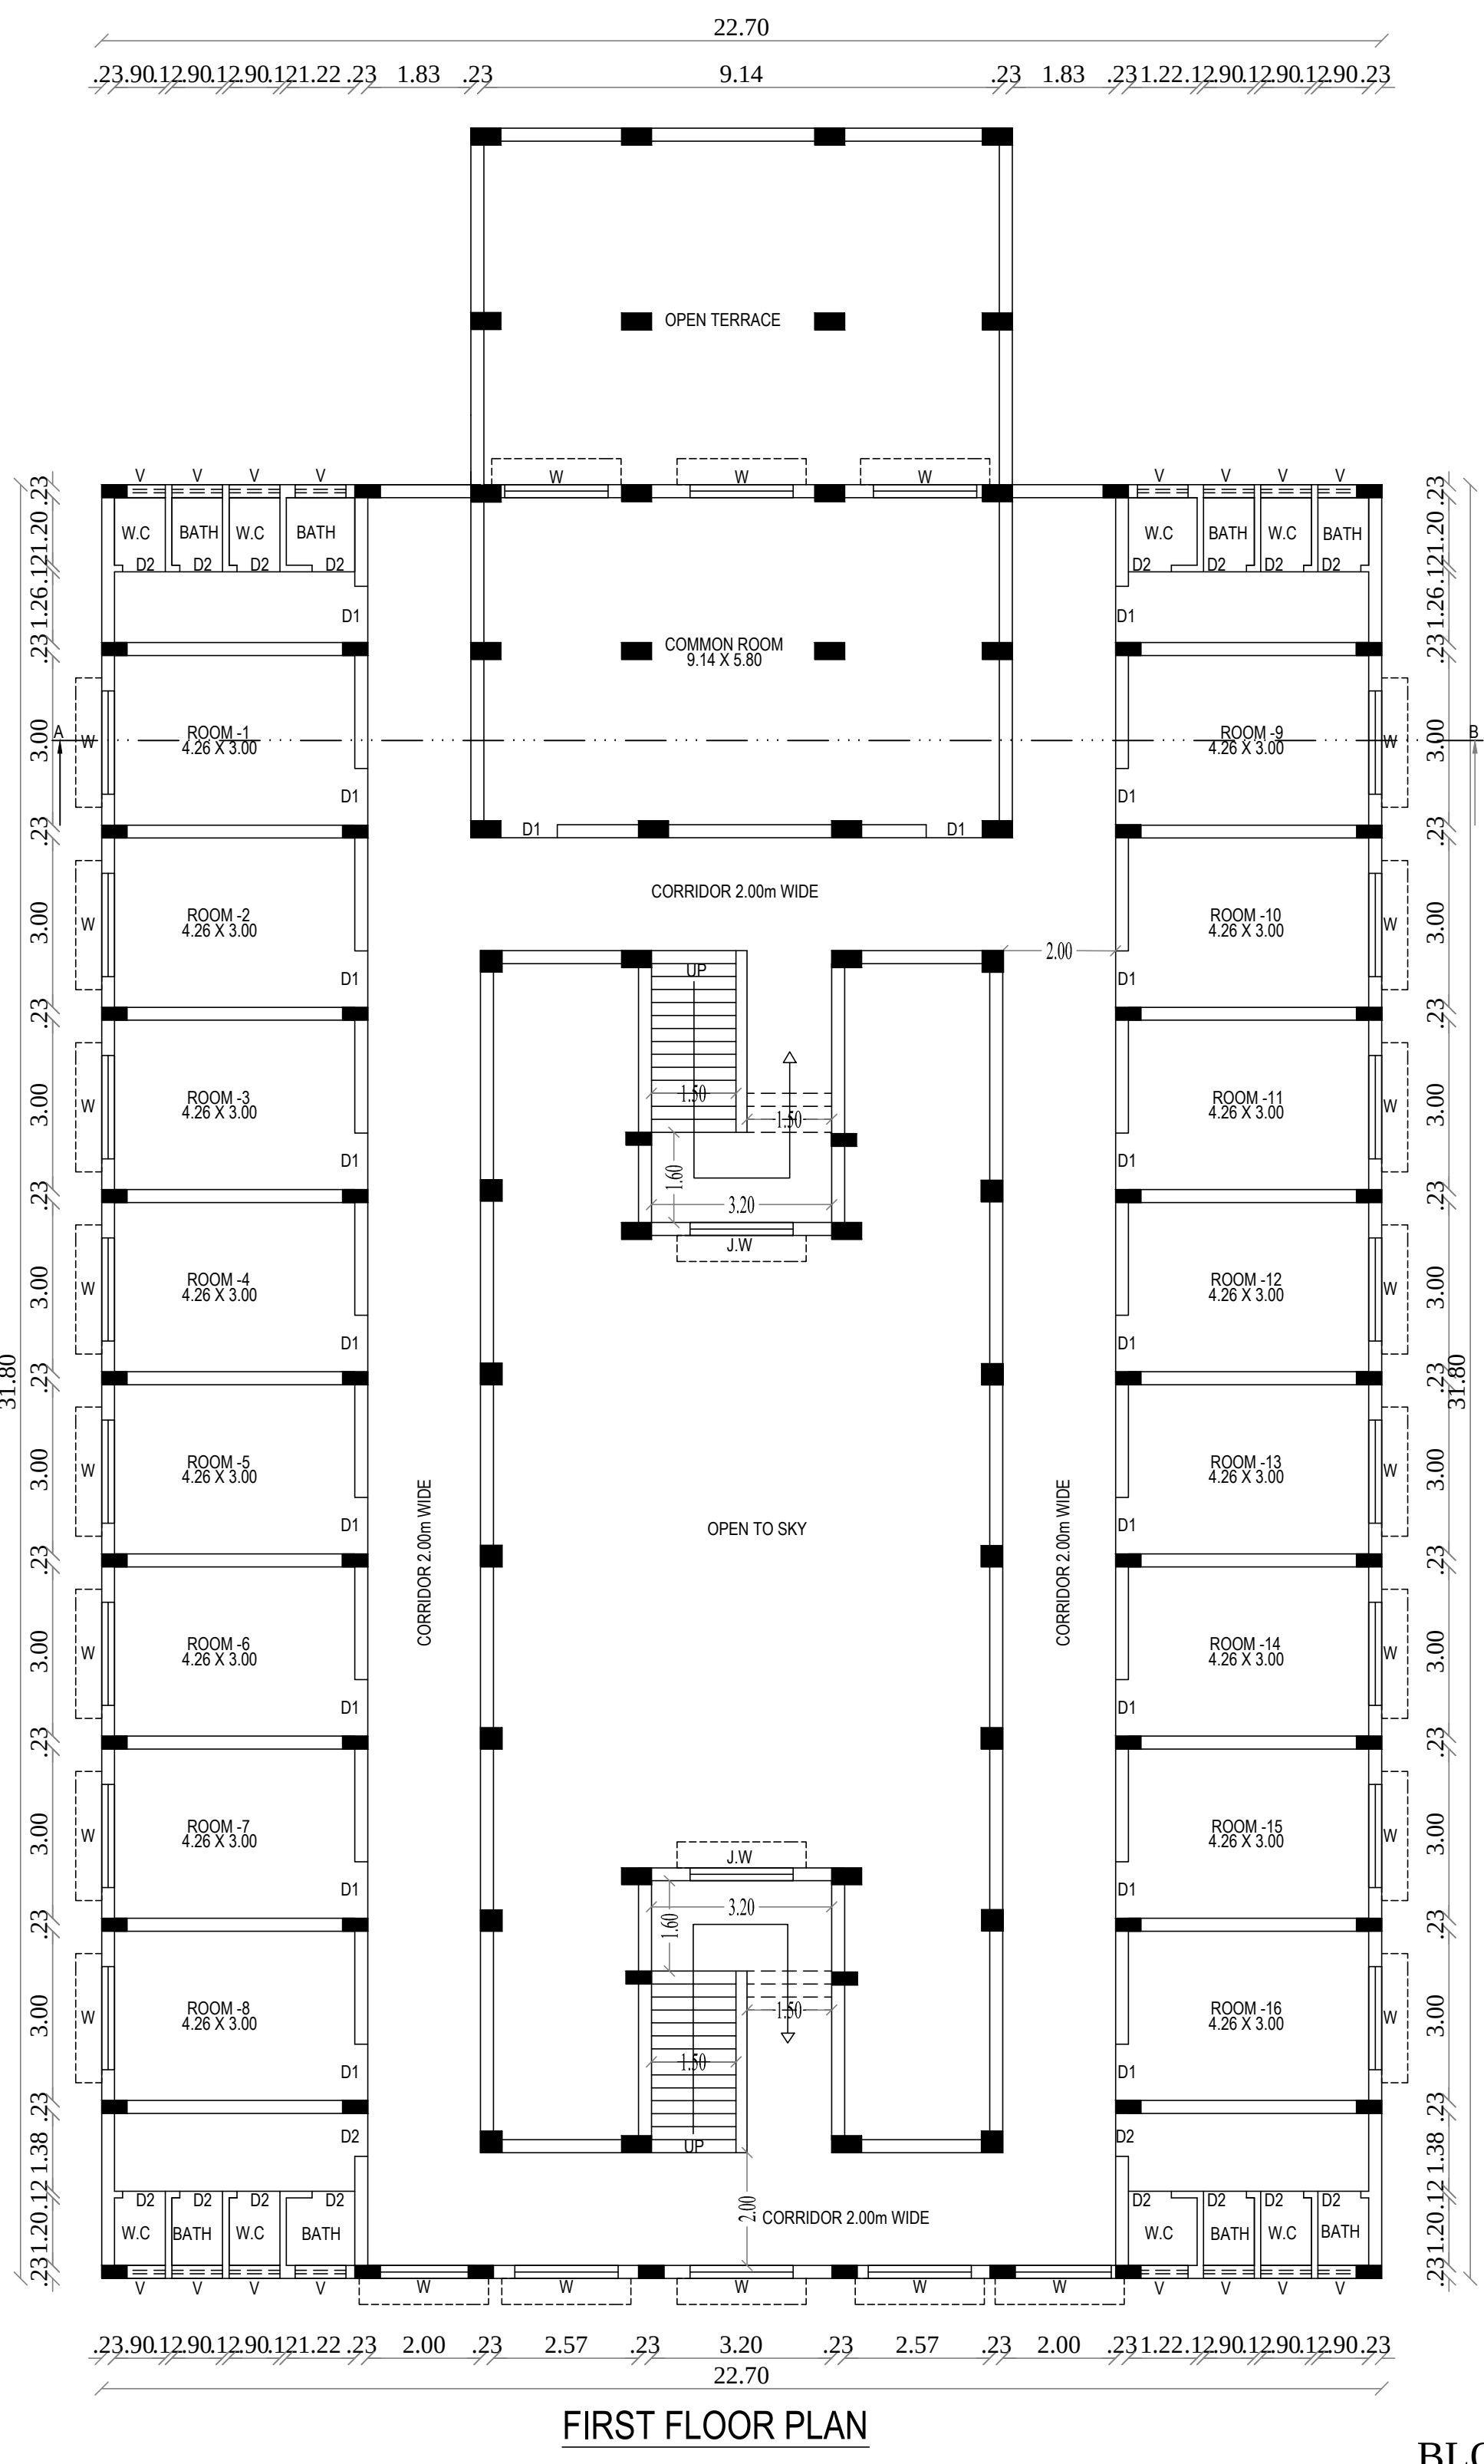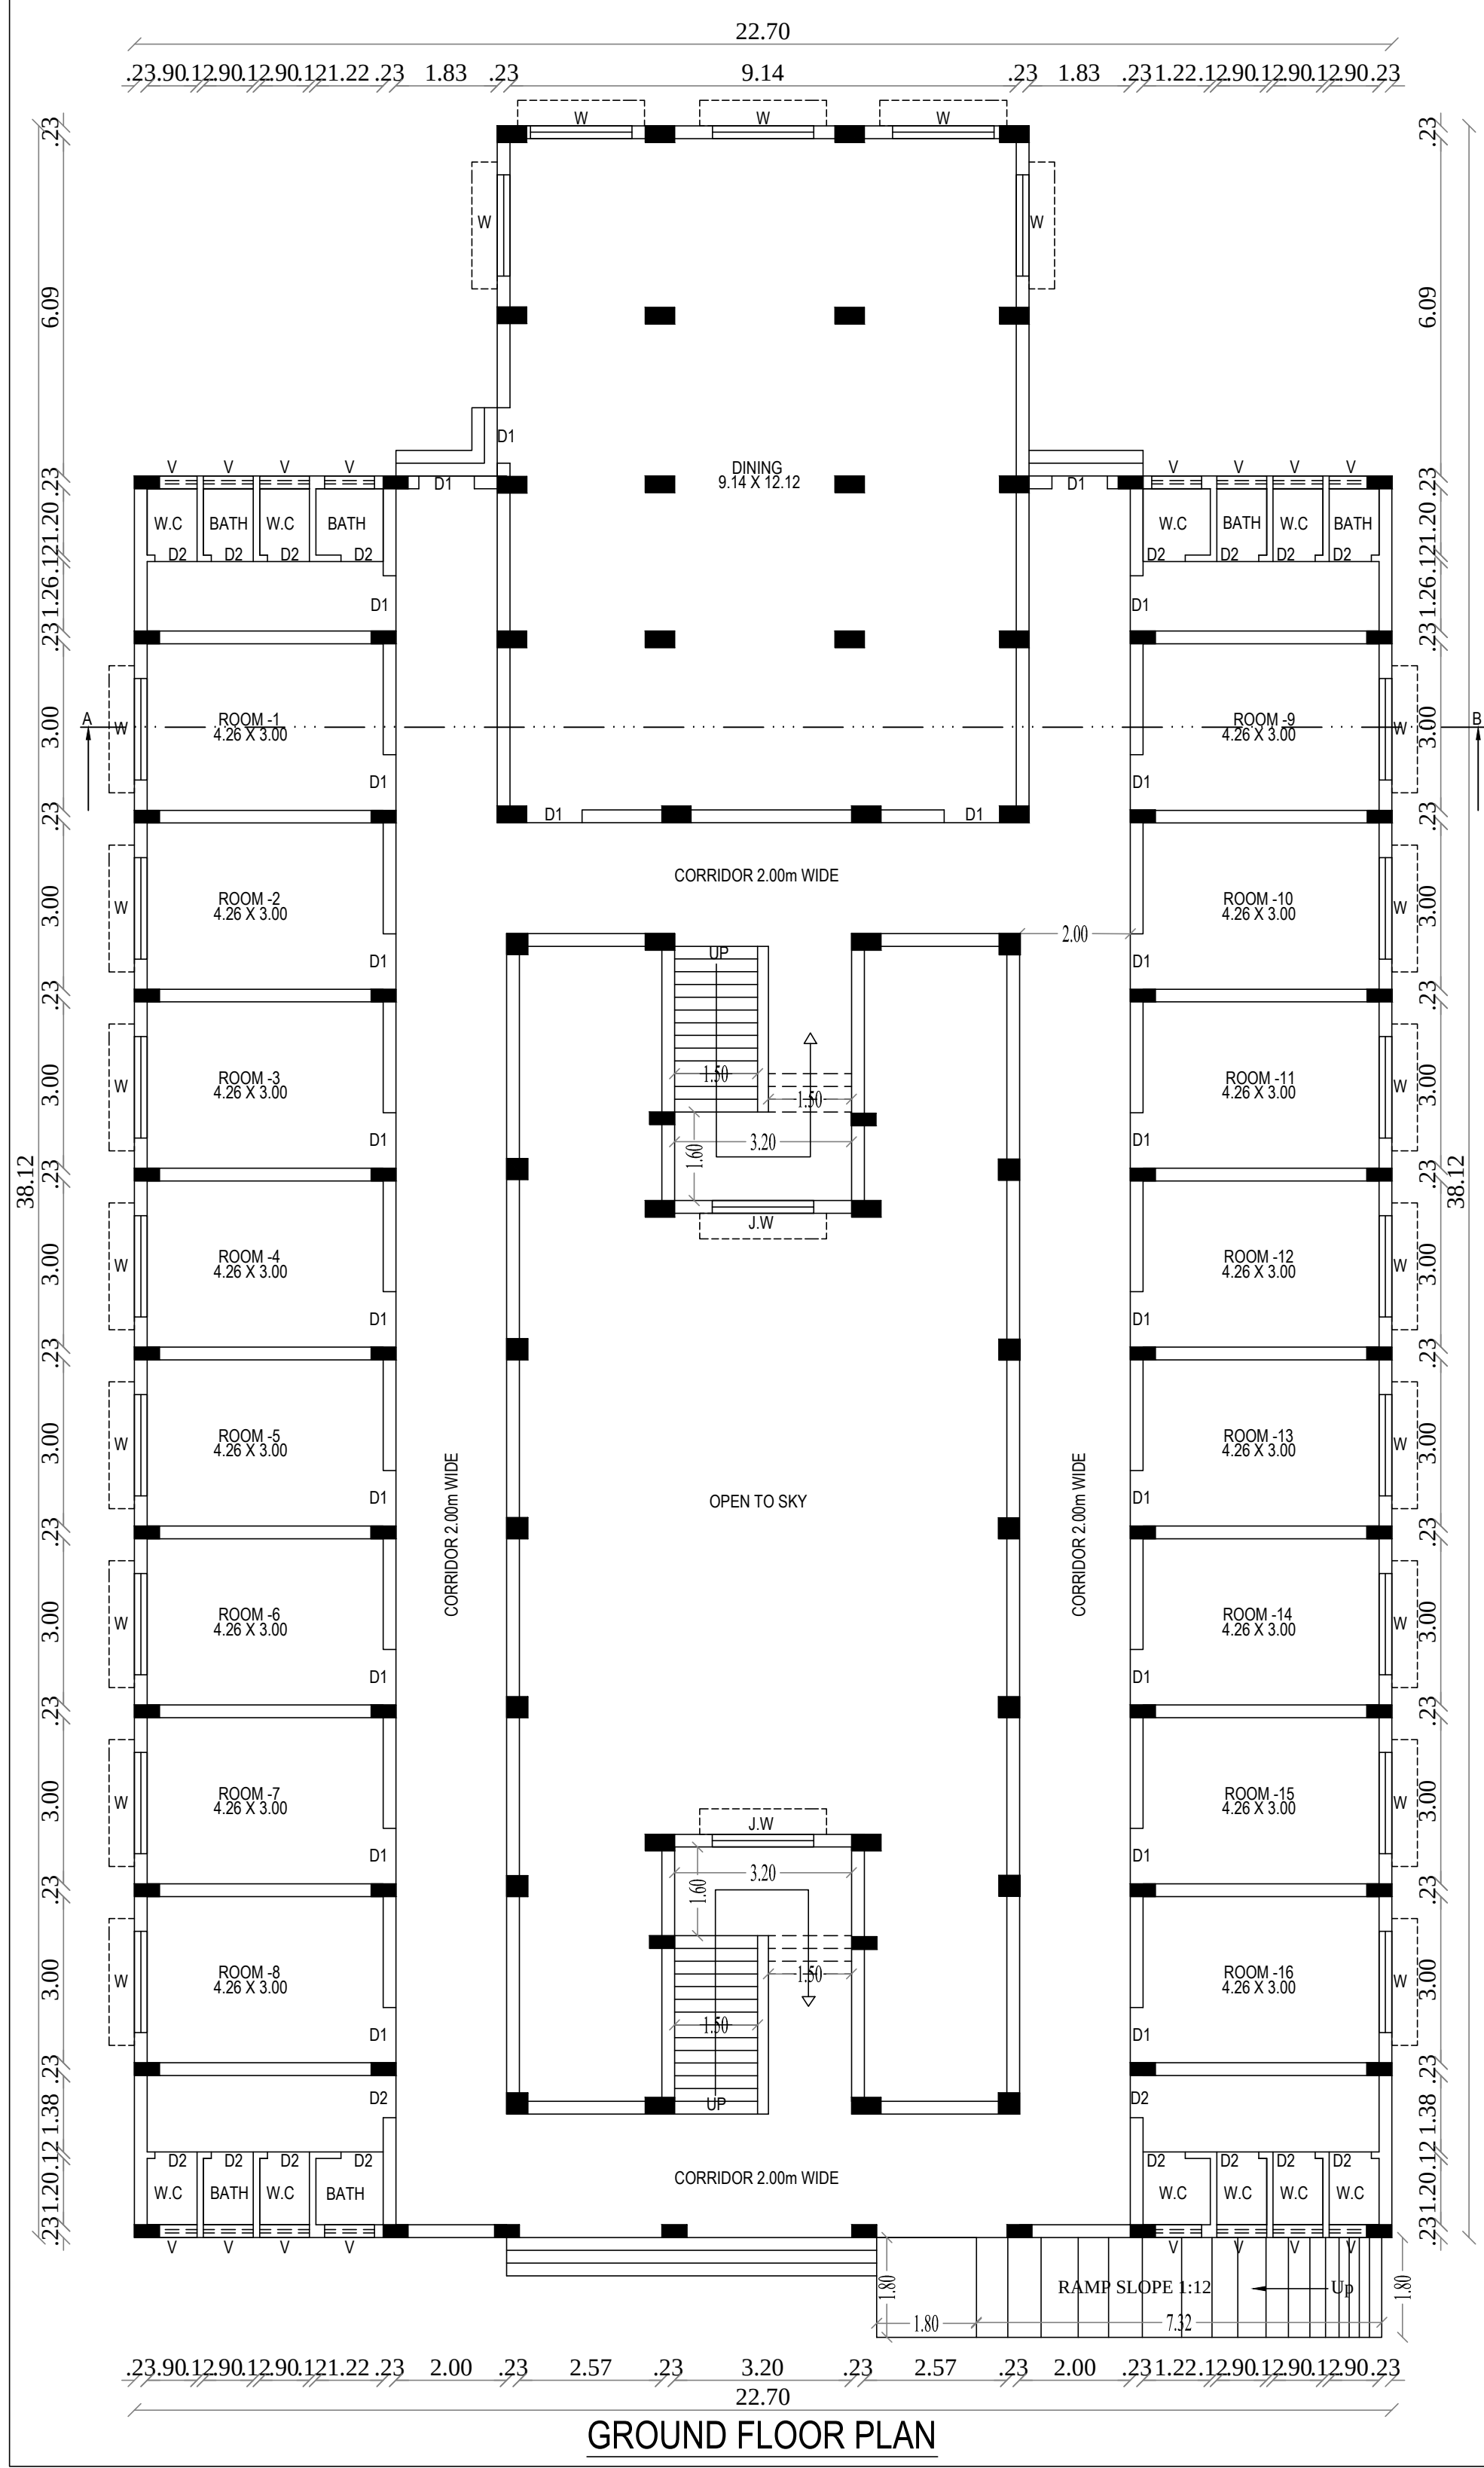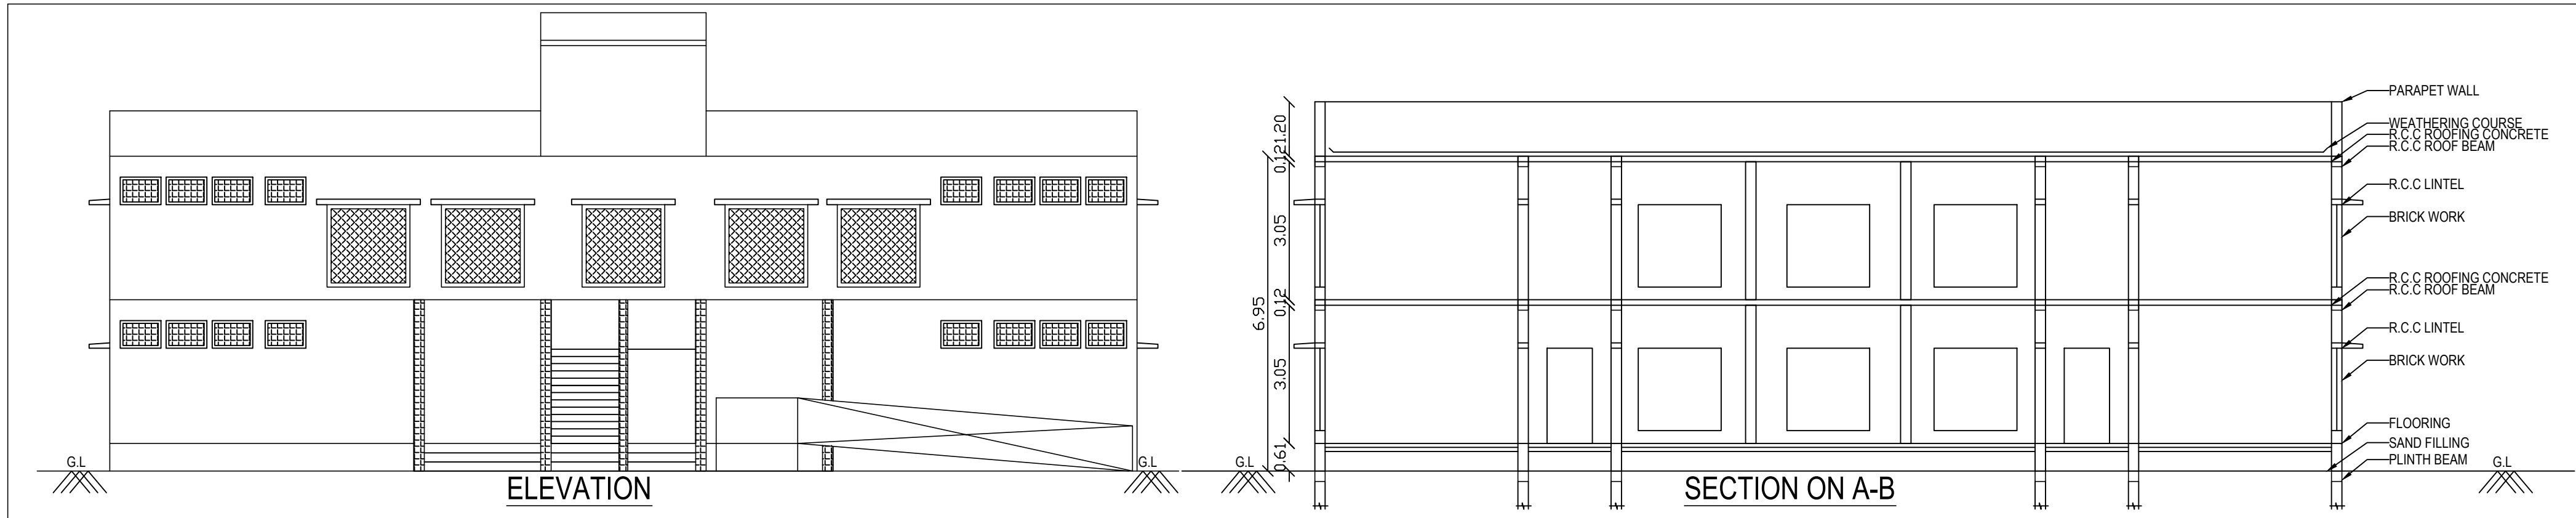

PLAN SHOWING THE PROPOSED
CONSTRUCTION OF COLLEGE BUILDING FOR
DAYALBAGH EDUCATIONAL INSTITUTE OFF
CAMPUS IN S.NO:170/1A,170/1Cpart OF
MELATHIRUVENGADANATHAPURAM VILLAGE
AND PANCHAYAT, PALAYAMKOTTAI TALUK,
TIRUNELVELI DISTRICT.

ALL DIMENSIONS ARE IN METER, SCALE 1:100 | SHEET NO: 9

APPLICANT NAME:
Mr.JEYARAM SINGH
DAYALBAGH EDUCATIONAL INSTITUTE OFF CAMPUS
MELA THIRUVENGADANATHAPURAM VILLAGE,
PALAYAMKOTTAI TALUK, TIRUNELVELI DISTRICT.

AREA DETAILS	F.S.I AREA Sq.mt	NON F.S.I AREA Sq.mt	TOTAL AREA Sq.mt
BOYS HOSTEL BLOCK			
BLOCK 3 AREA			
GROUND FLOOR	634.29	---	634.29
FIRST FLOOR	573.62	---	573.62
HEAD ROOM	---	53.22	53.22
TOTAL FLOOR	1207.91	53.22	1261.13

JOINERY DETAILS			
D1	-	DOOR	- 1.00 x 2.10
D2	-	DOOR	- 0.76 x 2.10
W	-	WINDOW	- 1.80 x 1.80
V	-	VENTILATOR	- 1.00 x 0.61

NOTE:-

- * ALL DIMENSIONS ARE IN "METRE", SCALE 1:100
- * WASTE WATER USED TO GARDEN
- * DRINKING WATER TO BE PROVIDED
- * FIRE EXTINGUISHER TO BE PROVIDE
- * RAIN WATER HARVESTING TANK TO BE PROVIDE
- * SOLAR SYSTEM WATER TANK TO BE PROVIDE
- * PERCUATION PIT TO BE PROVIDE
- * EMERGENCY ALARM TO BE PROVIDE

SWP/BPA/011758/2023
B.P/DTCP No:417/2023

V.K. Ashok Kumaravel, B.E., M.E., A.I.A., (P.W.),
Civil & Structural Engineer
Registered Construction Engineer
Reg.No. RCE/TV/L/January/2020/018
CONSTRUCTION ENGINEER

V.K. Ashok Kumaravel, B.E., M.E., A.I.A., (P.W.),
Civil & Structural Engineer
Registered Structural Engineer Grade I
Reg.No. RSE/Gr-I/TV/L/January/2020/019
STRUCTURAL ENGINEER

for DAYALBAGH EDUCATIONAL INSTITUTE OFF CAMPUS
CO-ORDINATOR
APPLICANT

Er. P. K. THAMEEMUL ANSARI B.E.
Reg. No. : RE/Gr-I/TV/L/ March/2019/006
35 / 13-2, Firdous Complex, Ambai Road,
Melapalayam, (Sub-Registrar Office Building)
Tirunelveli - 627 005. Cell : 9488237454.
REG.ENGINEER

PLAN SHOWING THE PROPOSED
CONSTRUCTION OF COLLEGE BUILDING FOR
DAYALBAGH EDUCATIONAL INSTITUTE OFF
CAMPUS IN S.NO:170/1A,170/1Cpart OF
MELATHIRUVENGADANATHAPURAM VILLAGE
AND PANCHAYAT, PALAYAMKOTTAI TALUK,
TIRUNELVELI DISTRICT.

ALL DIMENSIONS ARE IN METER, SCALE 1:100 SHEET NO:10

APPLICANT NAME:
Mr.JEYARAM SINGH
DAYALBAGH EDUCATIONAL INSTITUTE OFF CAMPUS
MELA THIRUVENGADANATHAPURAM VILLAGE,
PALAYAMKOTTAI TALUK, TIRUNELVELI DISTRICT.

AREA DETAILS	F.S.I AREA Sq.mt	NON F.S.I AREA Sq.mt	TOTAL AREA Sq.mt
STAFF QUARTERS III BLOCK 4 AREA GROUND FLOOR	519.07	---	519.07
FIRST FLOOR HEAD ROOM	---	---	---
TOTAL FLOOR	1038.14	---	1038.14

JOINERY DETAILS			
D1	- DOOR	-	1.00 x 2.10
D2	- DOOR	-	0.76 x 2.10
W	- WINDOW	-	1.80 x 1.80
V	- VENTILATOR	-	1.00 x 0.61
NOTE:-			
* ALL DIMENSIONS ARE IN "METRE", SCALE 1:100			
* WASTE WATER USED TO GARDEN			
* DRINKING WATER TO BE PROVIDED			
* FIRE EXTINGUISHER TO BE PROVIDE			
* RAIN WATER HARVESTING TANK TO BE PROVIDE			
* SOLAR SYSTEM WATER TANK TO BE PROVIDE			
* PERCOLATION PIT TO BE PROVIDE			
* EMERGENCY ALARM TO BE PROVIDED			

SWP/BPA/011758/2023
B.P/DTCP No:417/2023

V.K. Ashok Kumaravel, B.E., M.E., A.I.A., (P.W.),
Civil & Structural Engineer
Registered Construction Engineer
Reg.No. RCE/TVL/January/2020/018

CONSTRUCTION ENGINEER

V.K. Ashok Kumaravel, B.E., M.E., A.I.A., (P.W.),
Civil & Structural Engineer
Registered Structural Engineer Grade I
Reg.No. RSE/G-ITVL/January/2020/019

STRUCTURAL ENGINEER

for DAYALBAGH EDUCATIONAL INSTITUTE OFF CAMPUS
CO-ORDINATOR

APPLICANT

Er. P. K. THAMEEMUL ANSARI B.E.
Reg. No.: RE/Gr II/TVL/March/2019/006
35 / 13-2, Flrthous Complex, Ambai Road,
Melapalayam, (Sub-Registrar Office Building
Tirunelveli - 627 005. Cell : 9488237454.

REG.ENGINEER

ELEVATION

SECTION ON A-B






TERRACE FLOOR PLAN

FIRST FLOOR PLAN

BLOCK 4

GROUND FLOOR PLAN

BLOCK 4

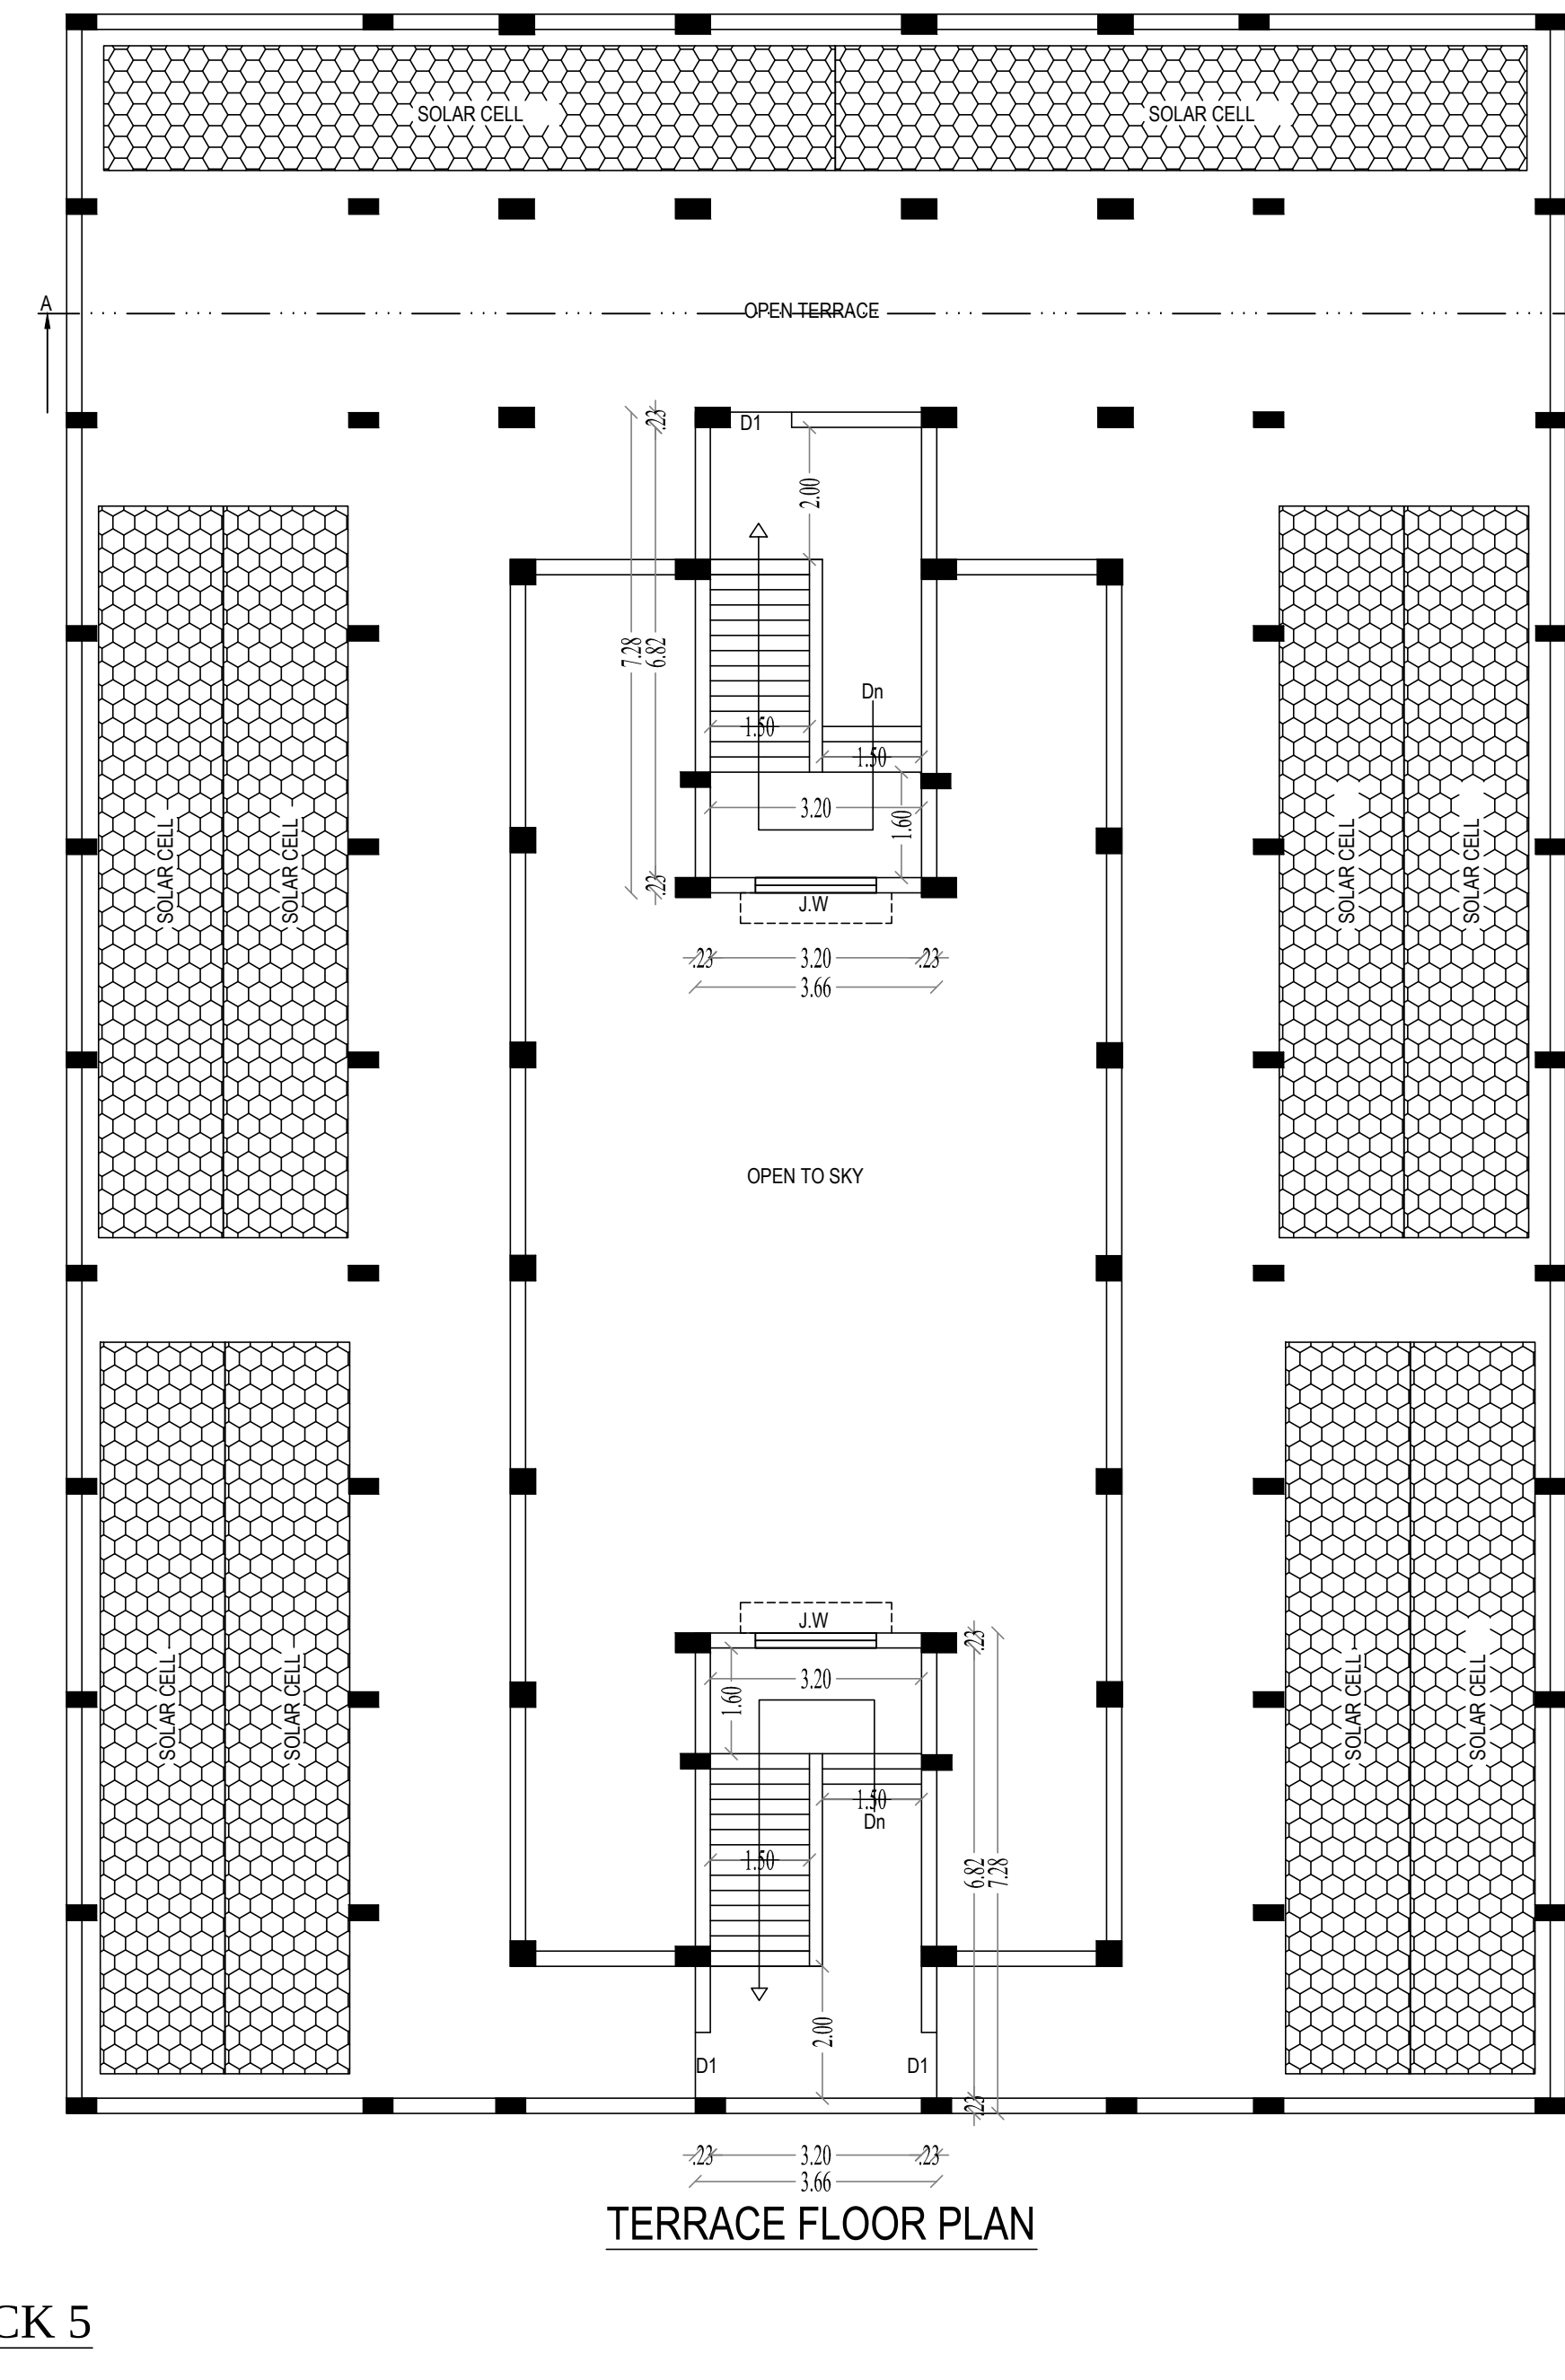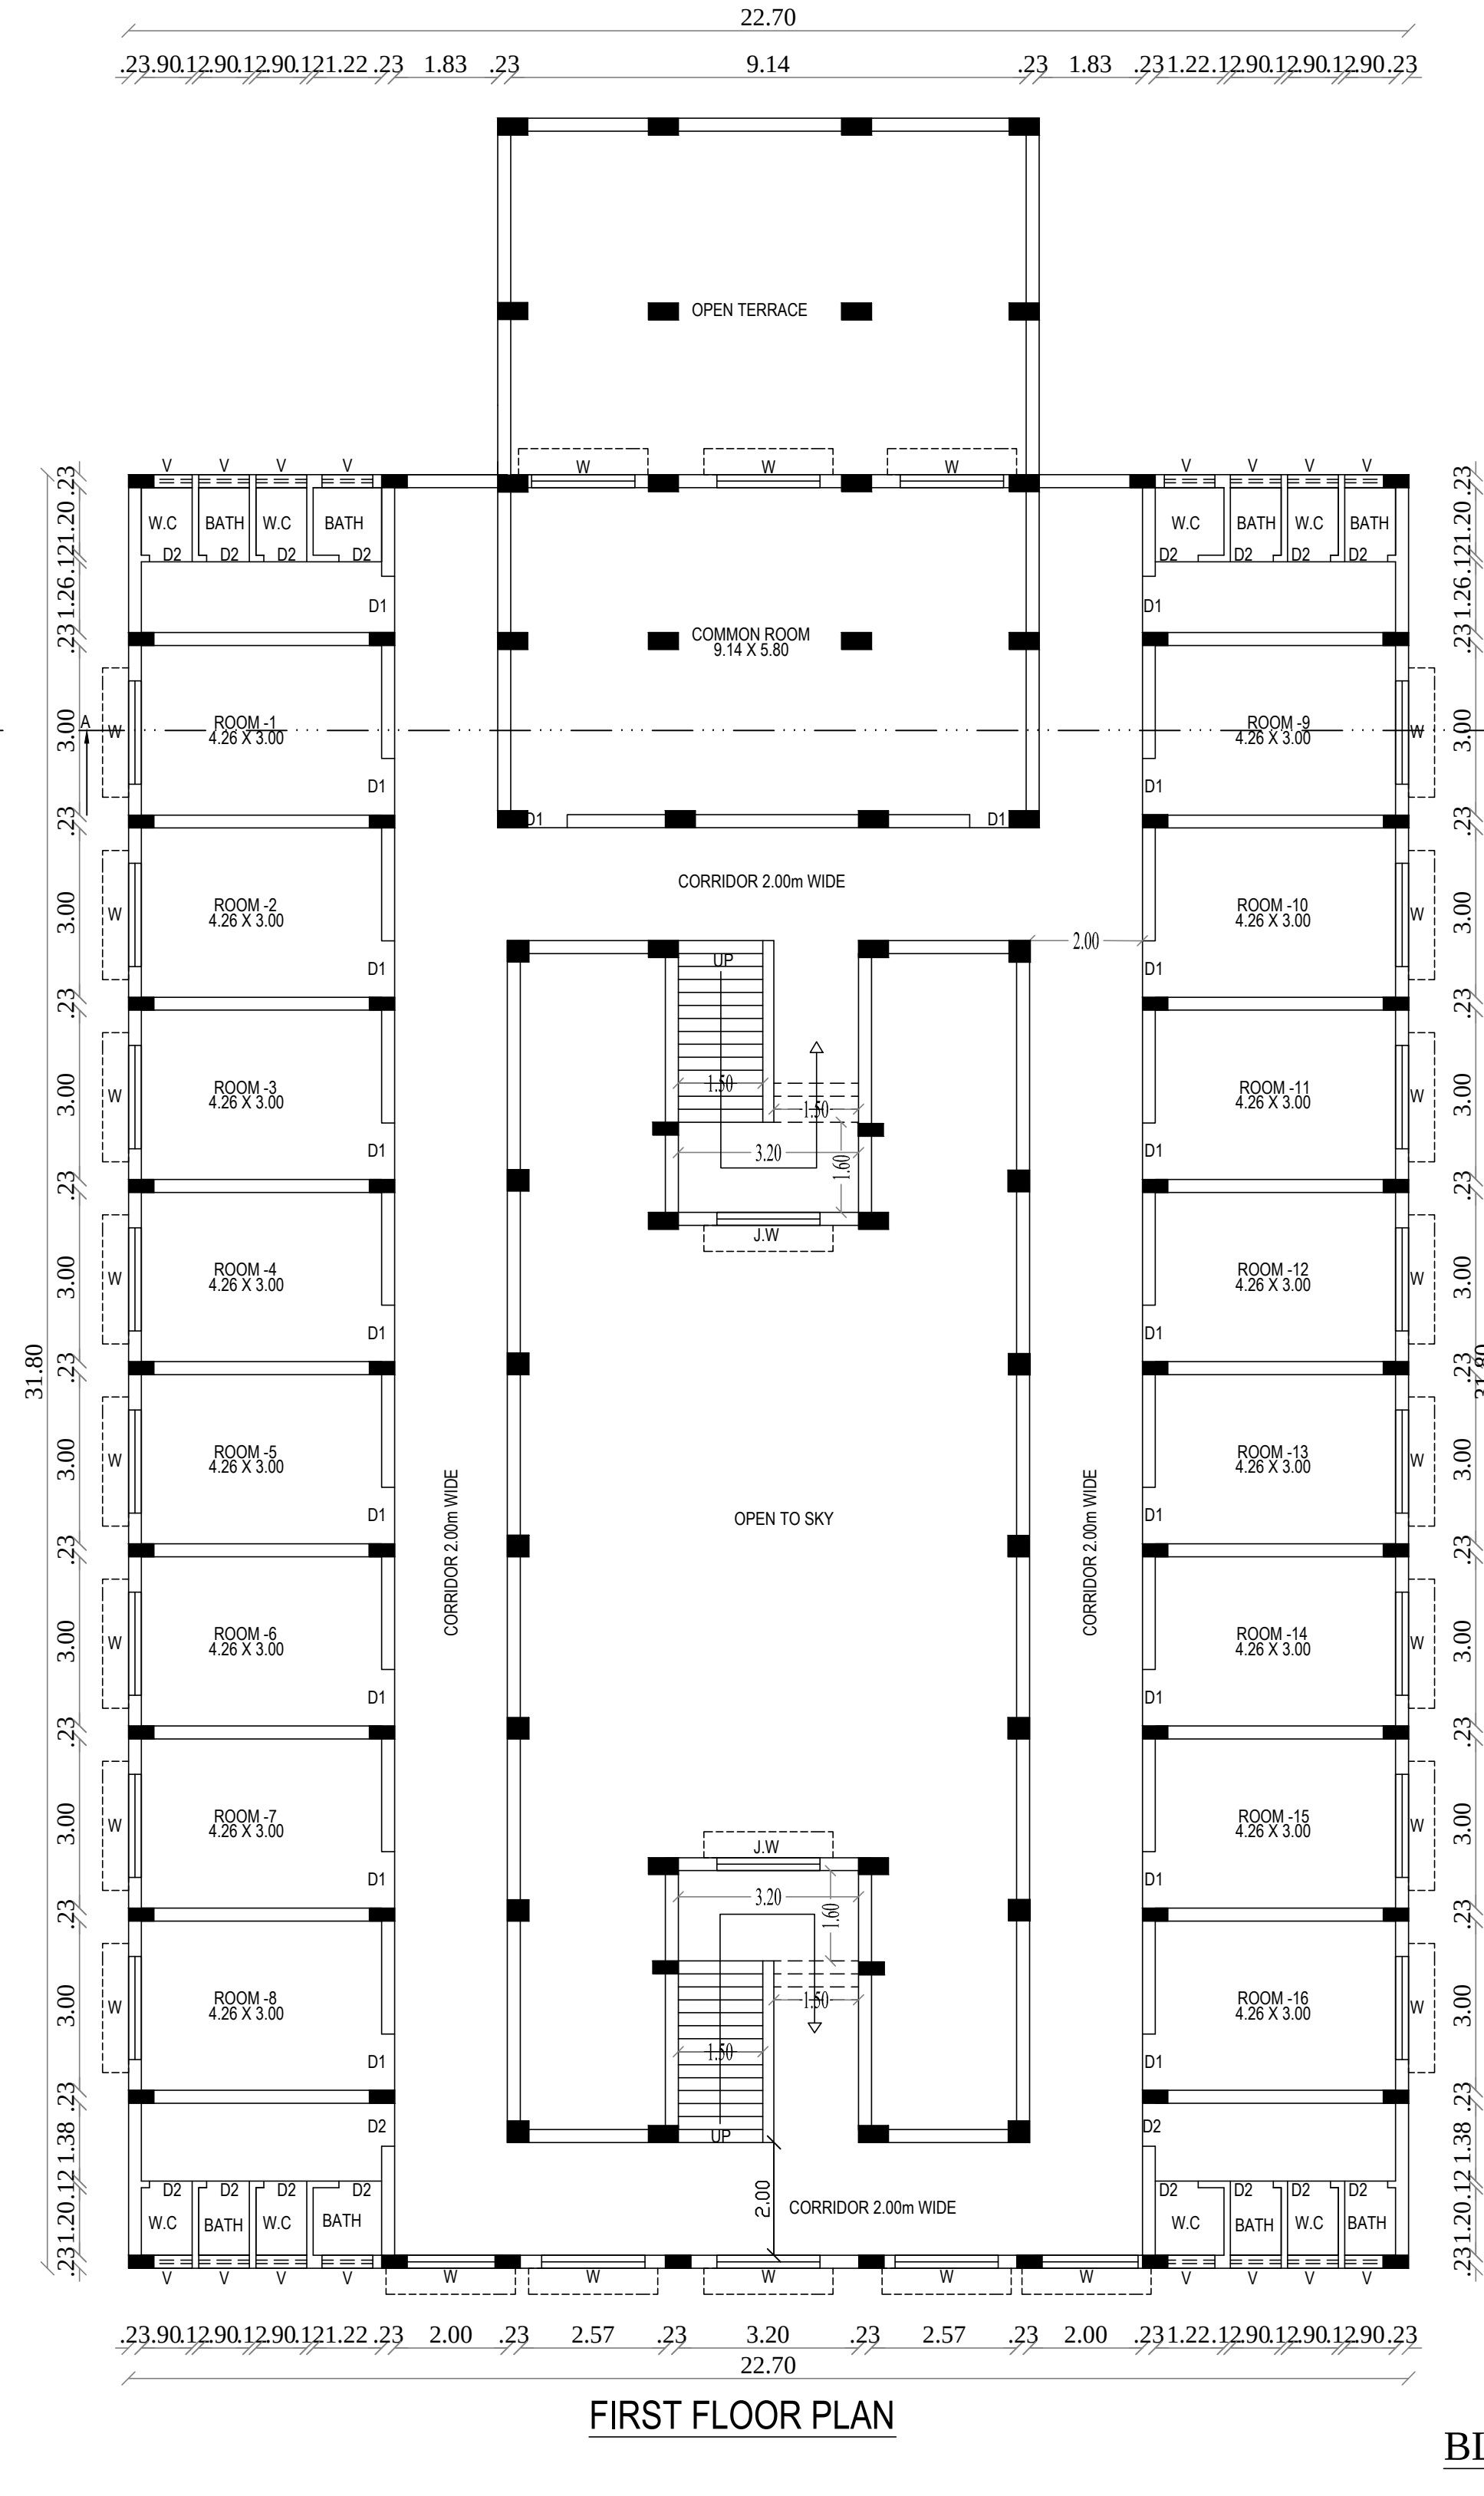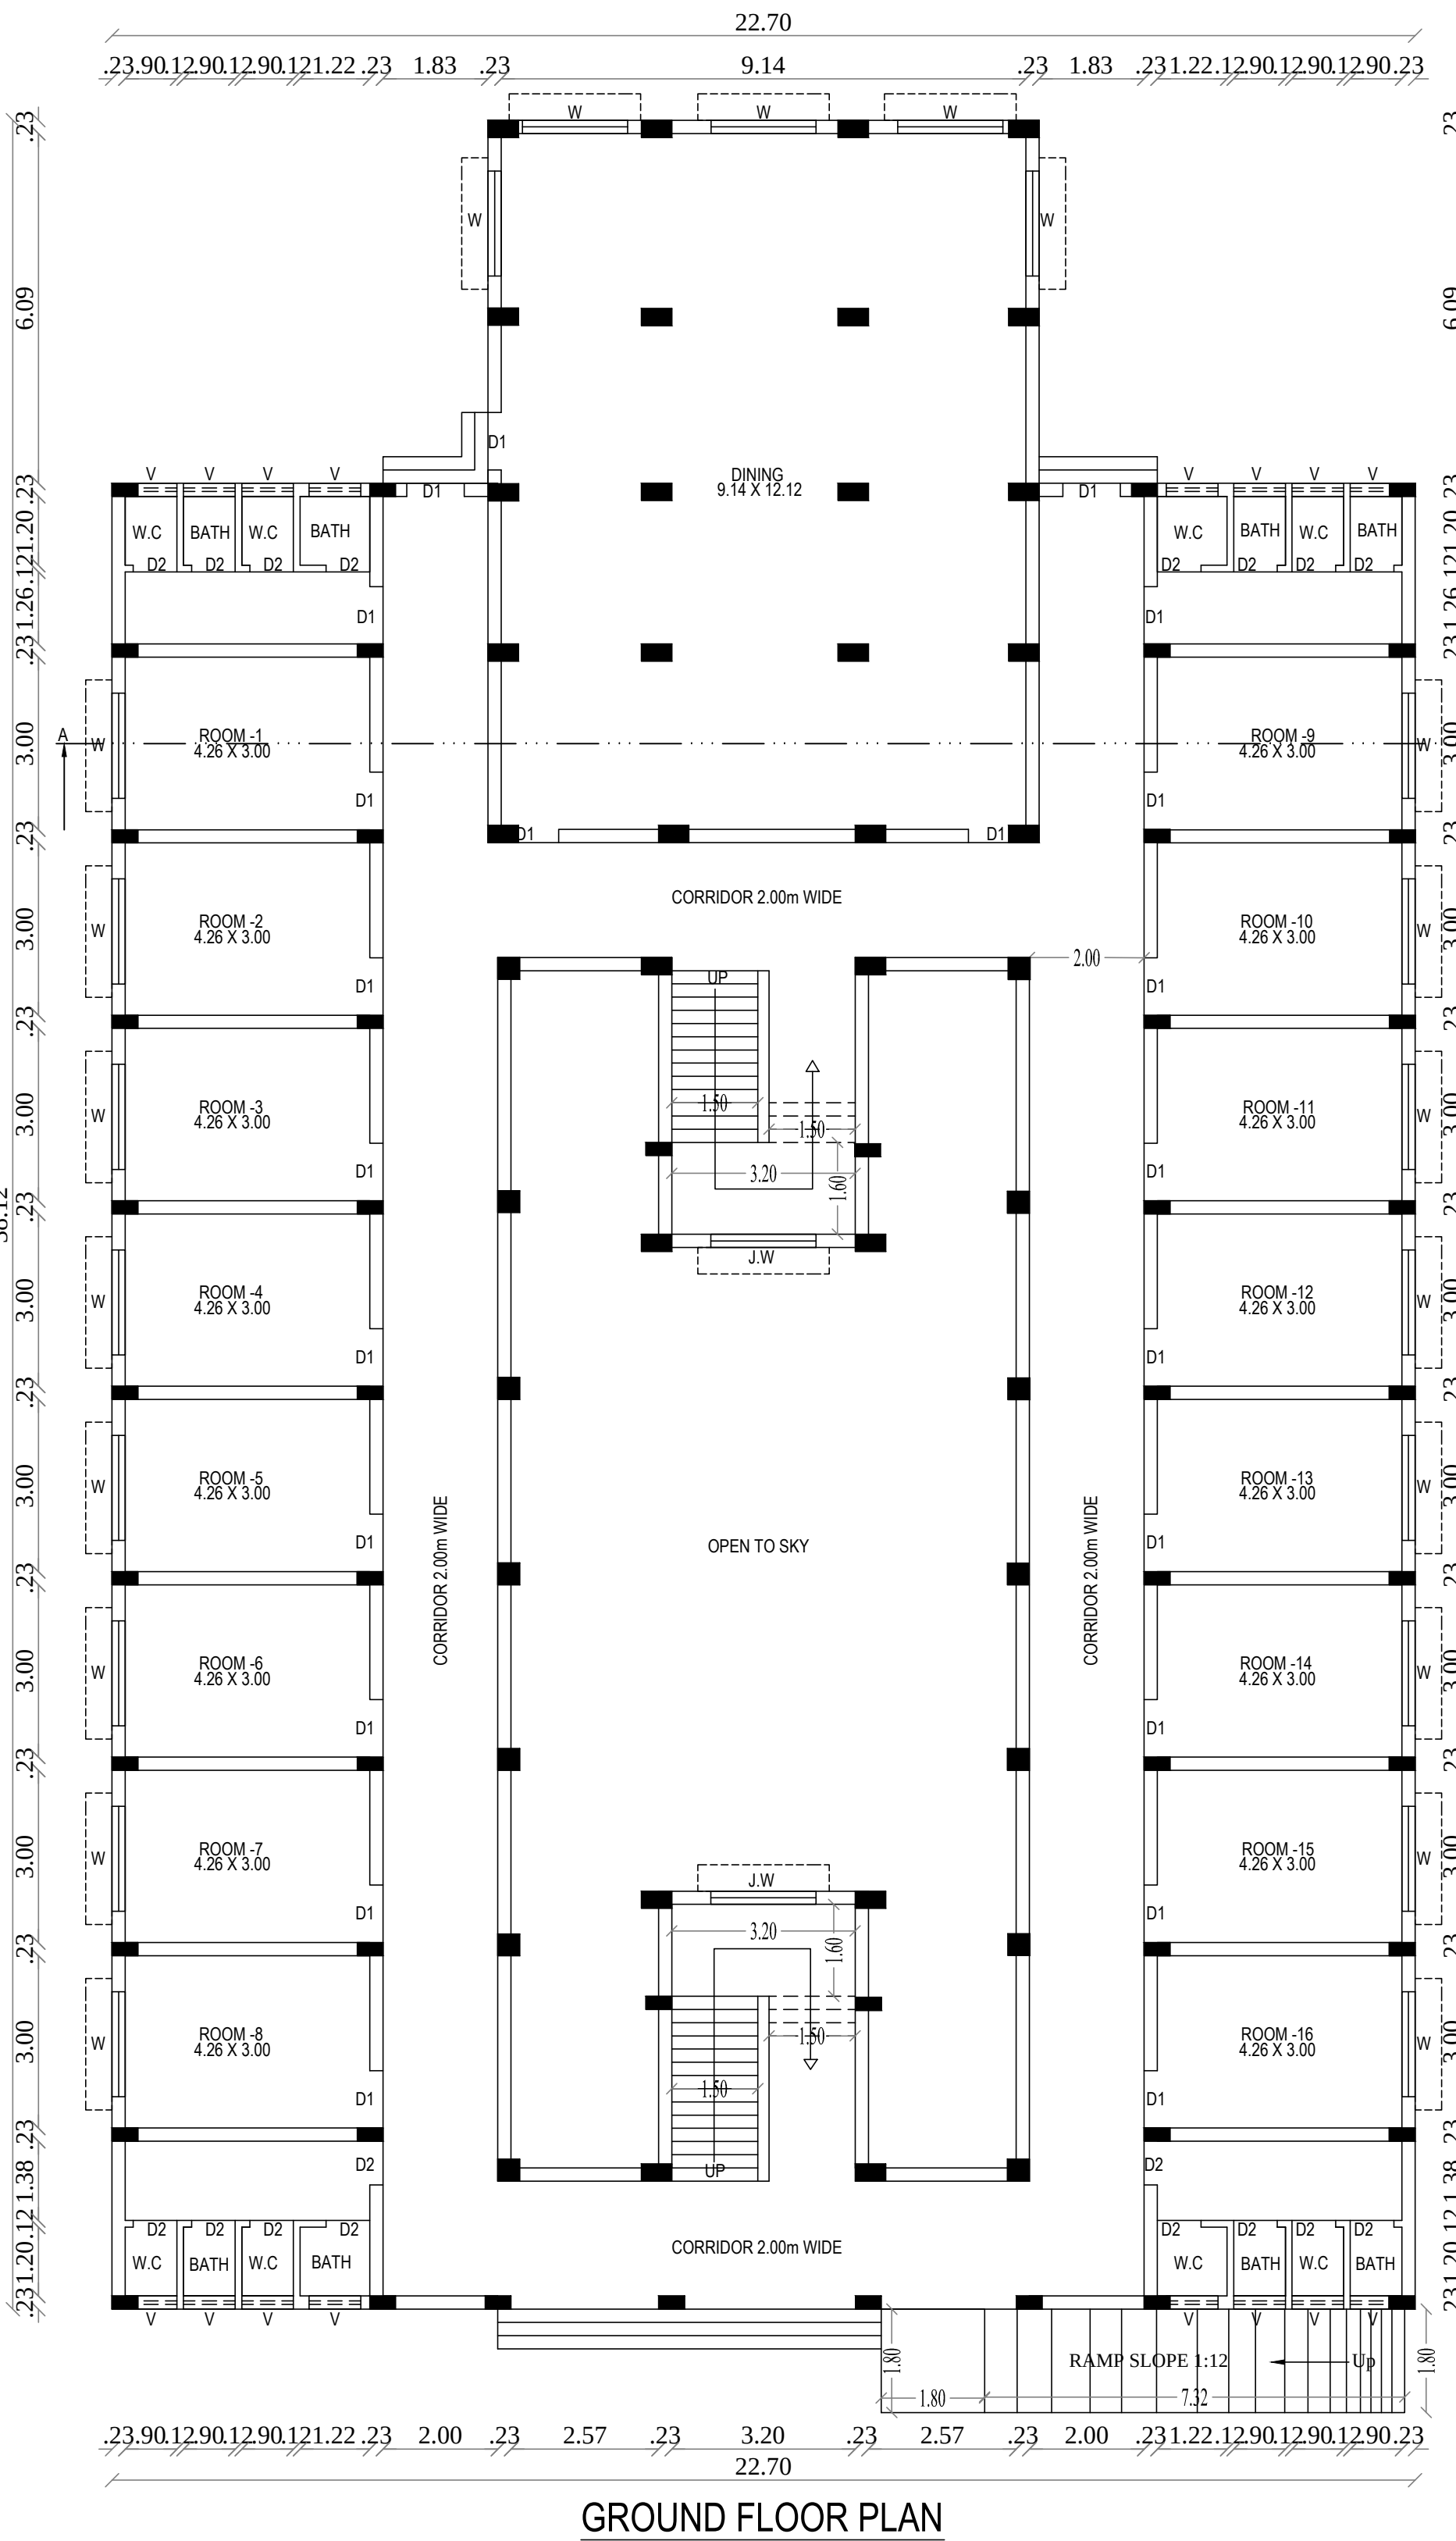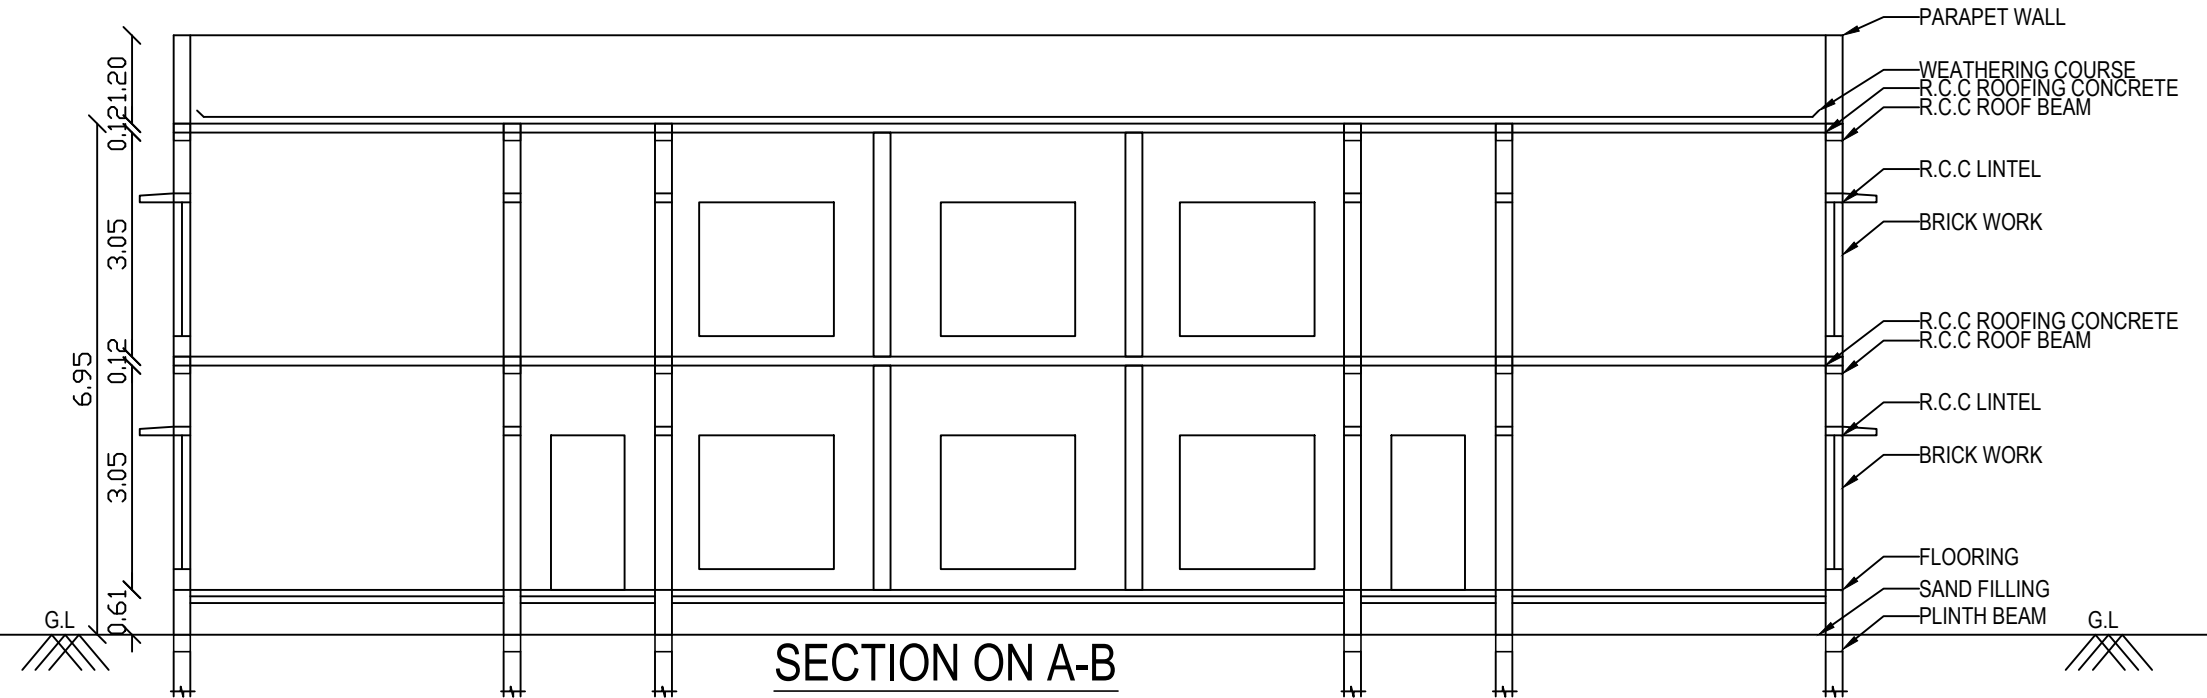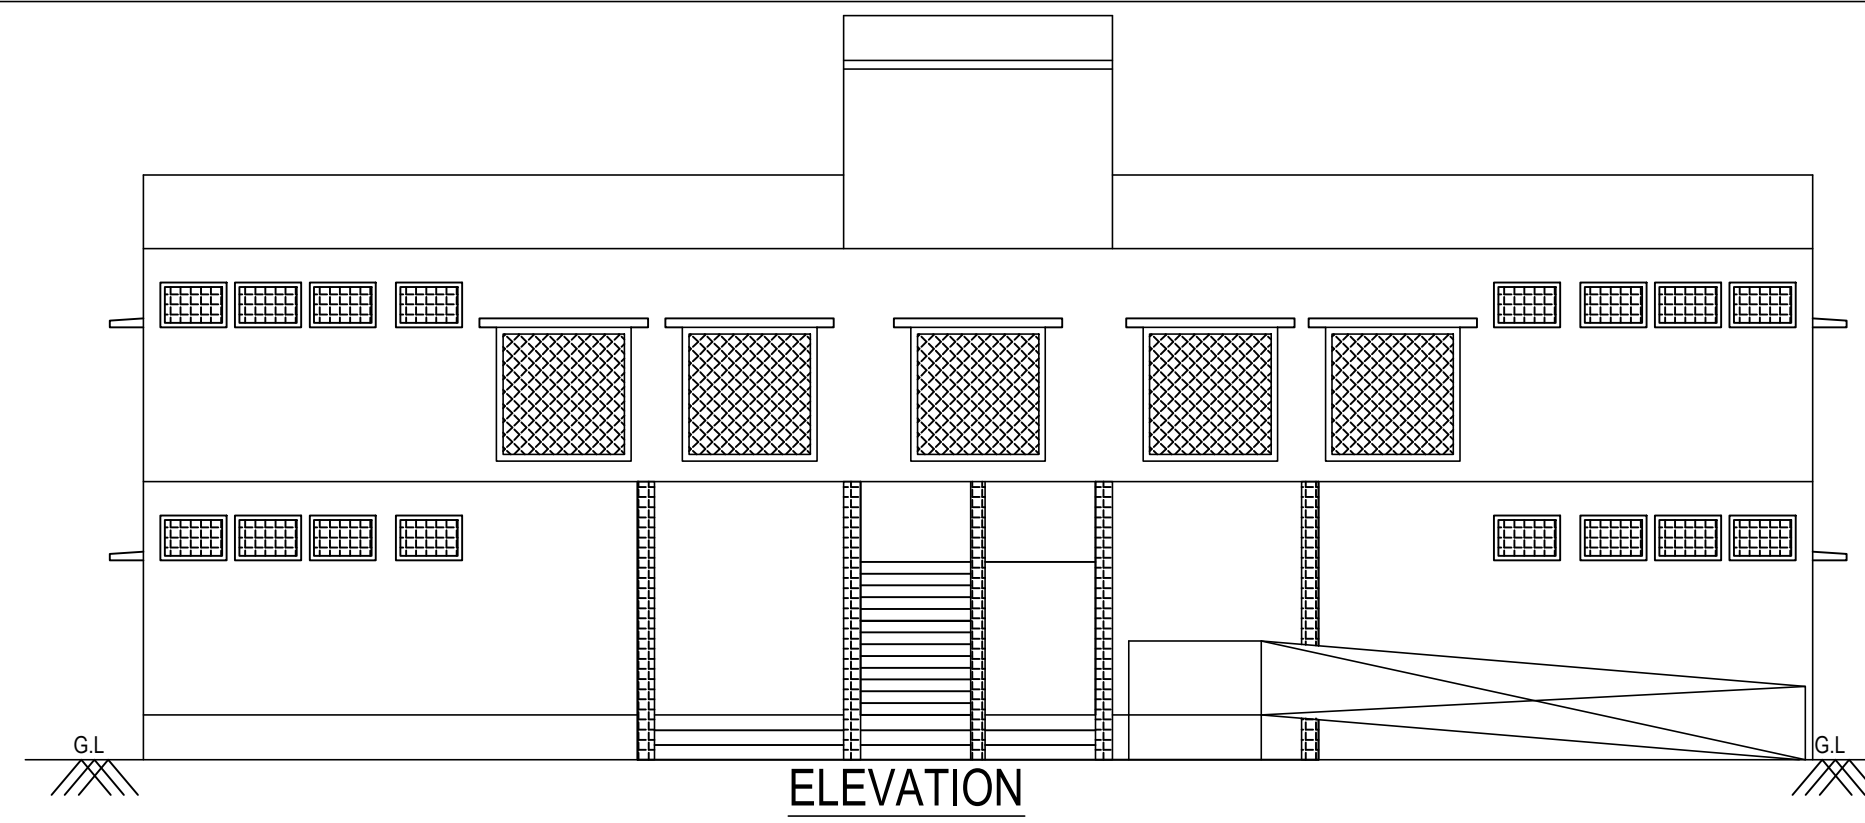

PLAN SHOWING THE PROPOSED CONSTRUCTION OF COLLEGE BUILDING FOR DAYALBAGH EDUCATIONAL INSTITUTE OFF CAMPUS IN S.NO:170/1A,170/1Cpart OF MELATHIRUVENGADANATHAPURAM VILLAGE AND PANCHAYAT, PALAYAMKOTTAI TALUK, TIRUNELVELI DISTRICT.

ALL DIMENSIONS ARE IN METER, SCALE 1:100 | SHEET NO:11

APPLICANT NAME:
Mr.JEYARAM SINGH
DAYALBAGH EDUCATIONAL INSTITUTE OFF CAMPUS
MELA THIRUVENGADANATHAPURAM VILLAGE,
PALAYAMKOTTAI TALUK, TIRUNELVELI DISTRICT.

AREA DETAILS	F.S.I AREA Sq.mt	NON F.S.I AREA Sq.mt	TOTAL AREA Sq.mt
GIRLS HOSTEL BLOCK			
BLOCK 5 AREA			
GROUND FLOOR	634.29	---	634.29
FIRST FLOOR	573.62	---	573.62
HEAD ROOM	---	53.22	53.22
TOTAL FLOOR	1207.91	53.22	1261.13

JOINERY DETAILS			
D1	- DOOR	-	1.00 x 2.10
D2	- DOOR	-	0.76 x 2.10
W	- WINDOW	-	1.80 x 1.80
V	- VENTILATOR	-	1.00 x 0.61

- NOTE:-
- ALL DIMENSIONS ARE IN "METRE", SCALE 1:100
 - WASTE WATER USED TO GARDEN
 - DRINKING WATER TO BE PROVIDED
 - FIRE EXTINGUISHER TO BE PROVIDED
 - RAIN WATER HARVESTING TANK TO BE PROVIDE
 - SOLAR SYSTEM WATER TANK TO BE PROVIDE
 - PERCULATION PIT TO BE PROVIDE
 - EMERGENCY ALARM TO BE PROVIDED


SWP/BPA/011758/2023
B.P/DTCP No:417/2023

V.K. Ashok Kumaravel, B.E., M.E., A.I.Y. (P),
Civil & Structural Engineer
Registered Construction Engineer
Reg.No. RCE/TV/J/January/2020/018
CONSTRUCTION ENGINEER

V.K. Ashok Kumaravel, B.E., M.E., A.I.Y. (P),
Civil & Structural Engineer
Registered Structural Engineer Grade I
Reg.No. RSE/Gr-I/TV/J/January/2020/019
STRUCTURAL ENGINEER

for DAYALBAGH EDUCATIONAL INSTITUTE OFF CAMPUS
CO-ORDINATOR
APPLICANT

Er. P. K. THAMEEMUL ANSARI B.E.
Reg. No. : RE/Gr II/TVL/ March/2019/006
35 / 13-2, Firdous Complex, Ambai Road,
Melapalayam, (Sub-Registrar Office Building)
Tirunelveli - 627 005. Cell : 9488237454.
REG.ENGINEER

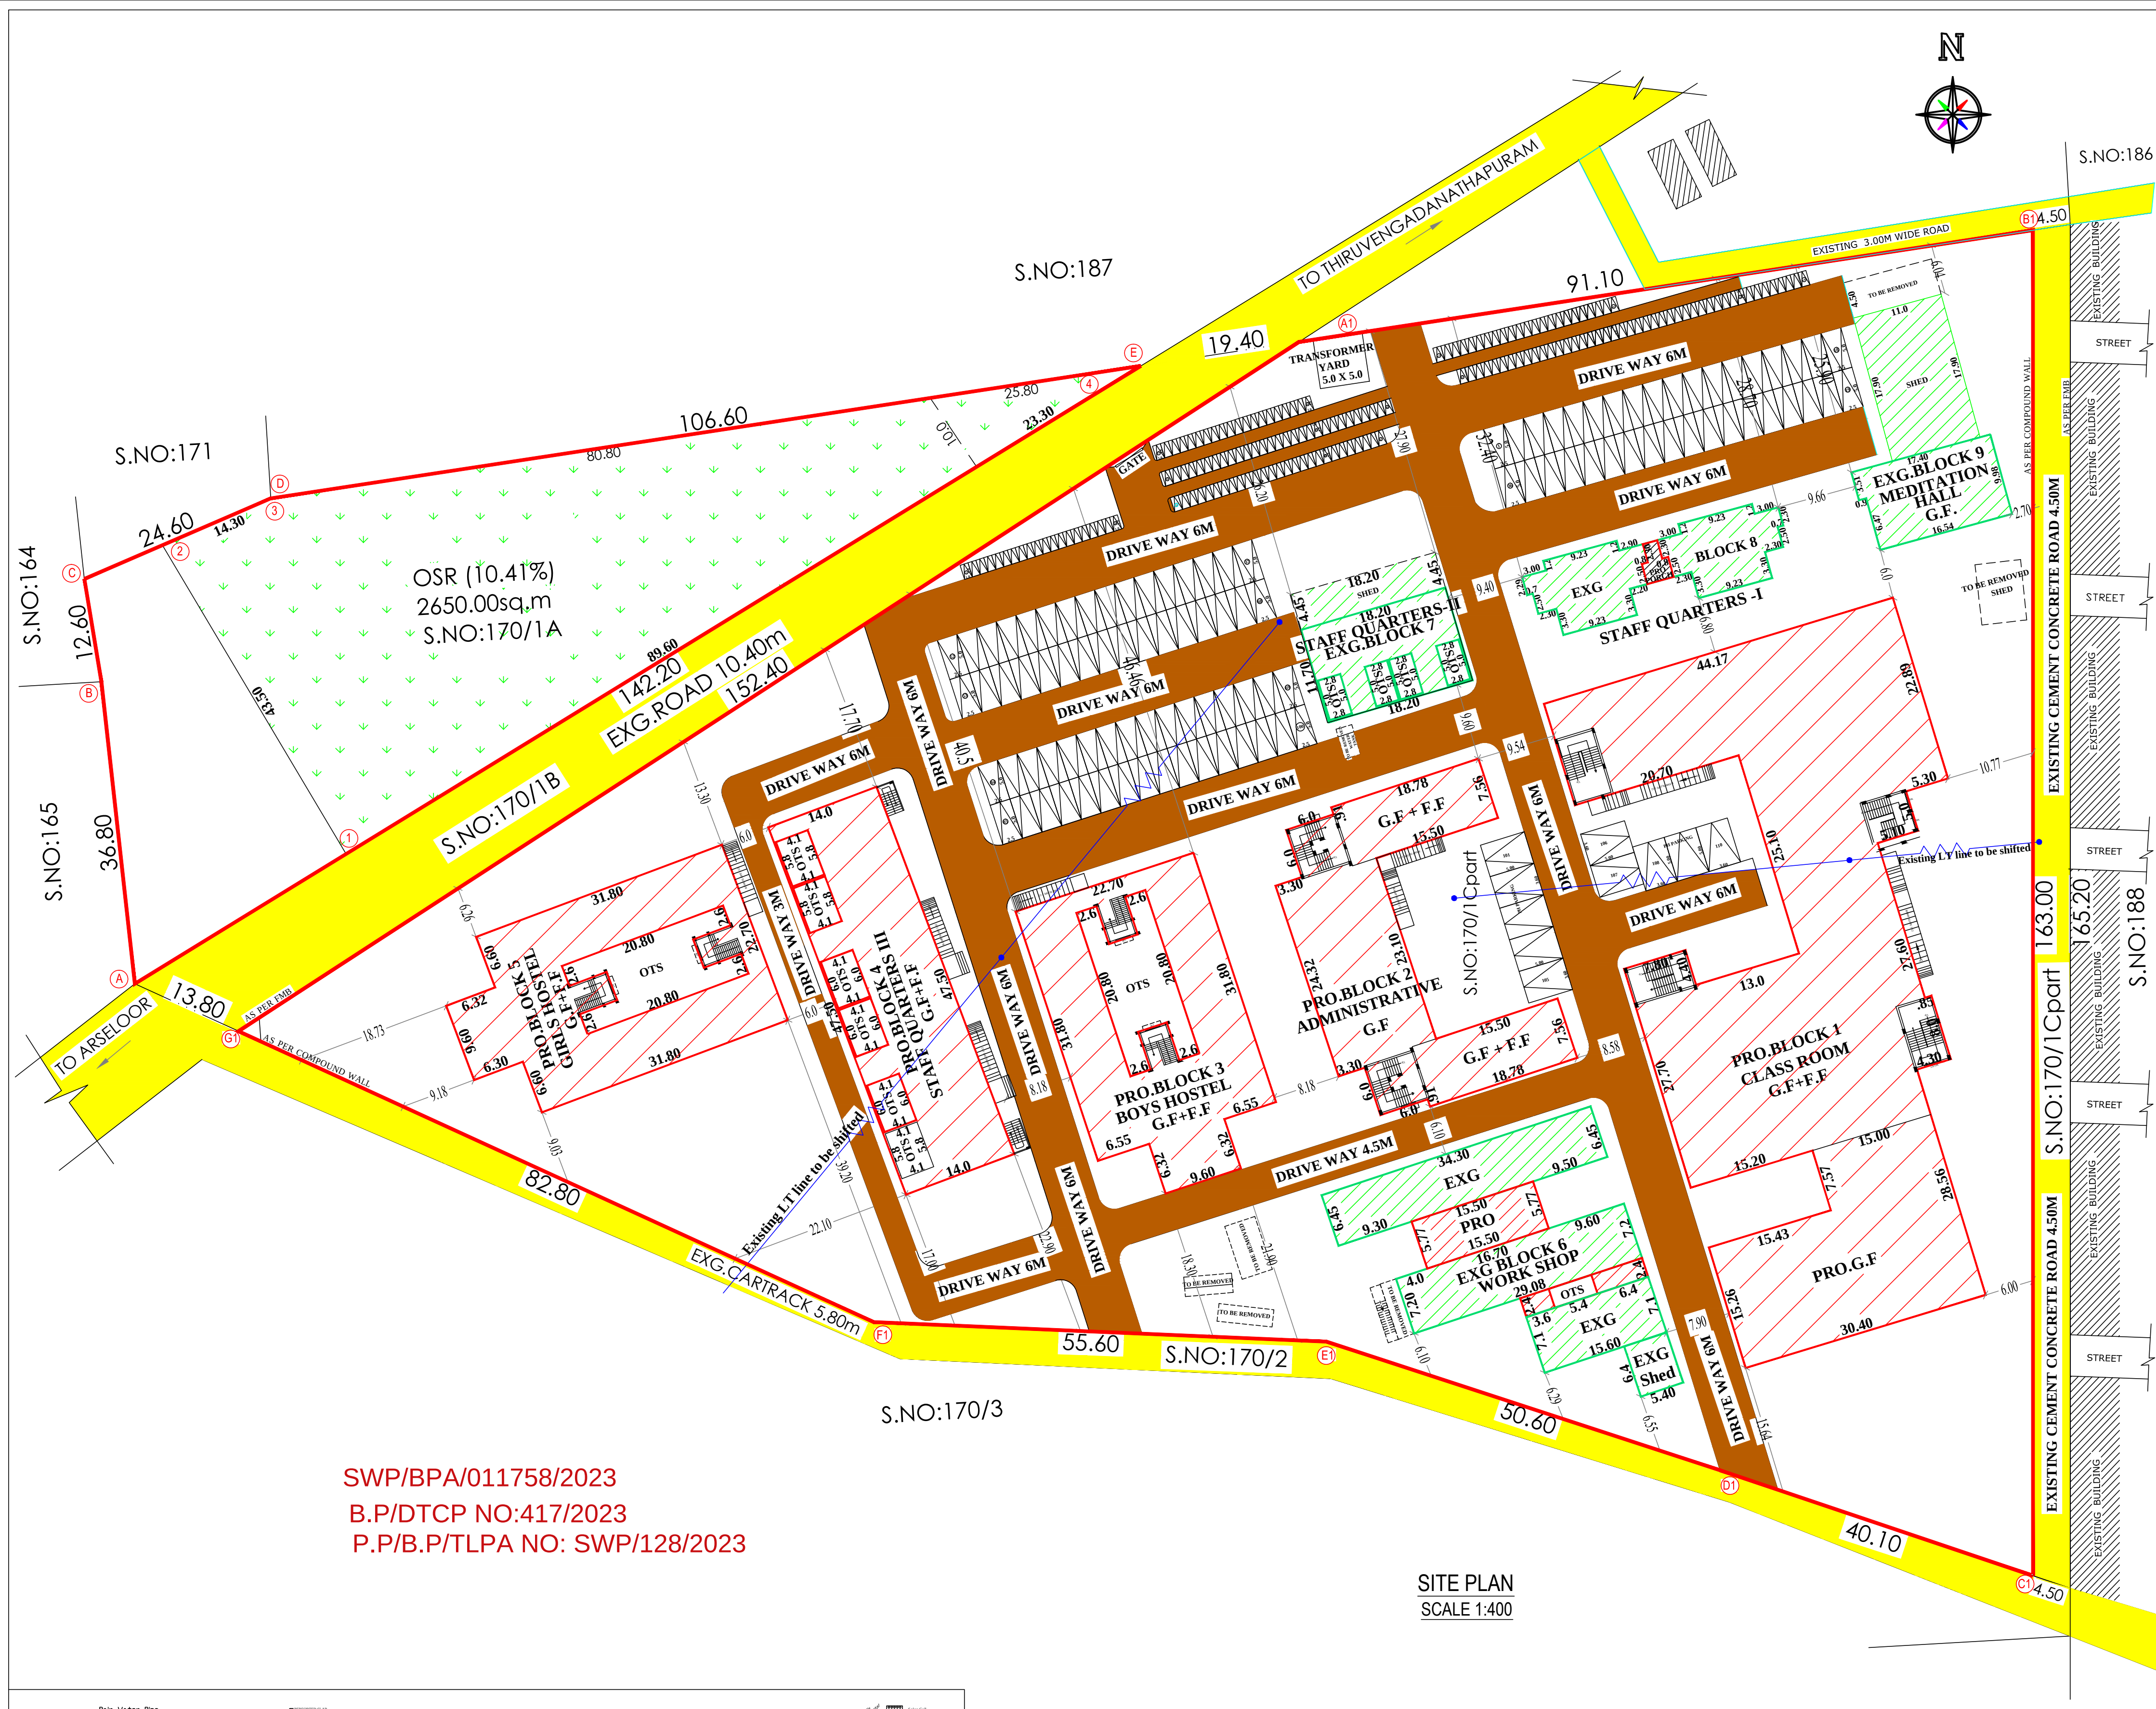

SWP/BPA/011758/2023
B.P/DTCP NO:417/2023
P.P/B.P/TLPA NO: SWP/128/2023

SITE PLAN
SCALE 1:400

SITE PLAN SHOWING THE EXISTING
CONSTRUCTED BUILDING (BLOCK-6,7,8,9) AND
PROPOSED CONSTRUCTION (BLOCK-1,2,3,4,5)
OF COLLEGE BUILDING FOR DAYALBAGH
EDUCATIONAL INSTITUTE OFF CAMPUS IN
S.NO: 170/1A,170/1Cpart OF
MELATHIRUVENGADANATHAPURAM VILLAGE
AND PANCHAYAT, PALAYAMKOTTAI TALUK,
TIRUNELVELI DISTRICT.

ALL DIMENSIONS ARE IN METER, SCALE 1:400 | SHEET NO: 1

APPLICANT NAME:
Mr. JEYARAM SINGH
DAYALBAGH EDUCATIONAL INSTITUTE OFF CAMPUS
MELA THIRUVENGADANATHAPURAM VILLAGE,
PALAYAMKOTTAI TALUK, TIRUNELVELI DISTRICT.


SITE AREA DETAILS		SQ.M
SITE AREA S.NO:170/1A S.NO:170/1C		3500.00
		21127.00
TOTAL SITE AREA		24627.00

BUILDING AREA STATEMENT						
AREA DETAILS	Existing Building to be Approved Area in Sq.m		Proposed Building Area in Sq.m		Total Area	
	F.S.I AREA Sq.mt	NON F.S.I AREA Sq.mt	F.S.I AREA Sq.mt	NON F.S.I AREA Sq.mt	F.S.I AREA Sq.mt	NON F.S.I AREA Sq.mt
BLOCK 1 (CLASS ROOM BLOCK)						
GROUND FLOOR AREA	---	---	2410.58	---	2410.58	---
FIRST FLOOR AREA	---	---	1833.59	---	1833.59	---
HEAD ROOM AREA	---	---	---	131.11	---	131.11
BLOCK 2 (ADMINISTRATIVE BLOCK)						
GROUND FLOOR AREA	---	---	659.57	---	659.57	---
FIRST FLOOR AREA	---	---	359.12	---	359.12	---
HEAD ROOM AREA	---	---	---	78.24	---	78.24
BLOCK 3 (BOYS HOSTEL)						
GROUND FLOOR AREA	---	---	634.29	---	634.29	---
FIRST FLOOR AREA	---	---	573.62	---	573.62	---
HEAD ROOM AREA	---	---	---	53.22	---	53.22
BLOCK 4 (STAFF QUARTERS III)						
GROUND FLOOR AREA	---	---	519.07	---	519.07	---
FIRST FLOOR AREA	---	---	519.07	---	519.07	---
BLOCK 5 (GIRLS HOSTEL)						
GROUND FLOOR AREA	---	---	634.29	---	634.29	---
FIRST FLOOR AREA	---	---	573.62	---	573.62	---
HEAD ROOM AREA	---	---	---	53.22	---	53.22
BLOCK 6 (WORKSHOP)						
GROUND FLOOR AREA	568.00	---	189.95	---	757.95	---
BLOCK 7 (STAFF QUARTERS II)						
GROUND FLOOR AREA	247.66	---	---	---	247.66	---
BLOCK 8 (STAFF QUARTERS - I)						
GROUND FLOOR AREA	221.68	---	12.15	---	233.83	---
BLOCK 9 (MEDITATION HALL)						
GROUND FLOOR AREA	375.12	---	---	---	375.12	---
TOTAL AREA	1412.46	---	8918.92	315.79	10331.38	315.79

FLOOR SPACE INDEX
F.S.I. = 10331.38 = 0.419
24627.00

PARKING CALCULATION
COLLEGE AREA = 6738.43sq.m
100sq.m = 1CAR
6738.43 = 68CAR
100
50sq.m = 1Two wheeler
6738.43 = 135Two wheeler
50
STAFF QUARTERS = 1519.63sq.m
100sq.m = 1CAR
1519.63 = 16CAR + 2visitor = 18CAR
100
HOSTEL 10ROOM = 1Twowheeler
64ROOM = 7Two wheeler
TOTAL REQUIRED
68+18= 86CAR
135+7= 142TWO WHEELER
TOTAL PROVIDED
= 110CAR(Including 10Nos PH Parking)
= 163TWO WHEELER

EXG.BUILDING APPROVED DETAILS:
BLOCK 6 APPROVED DETAILS
Tiruvenkadanathapuram Panchayat Approved Vide
Approval No:2/2005 Date:04.04.2005 (Taxation No:535)
Approval No:1/2011 Date:30.06.2011 (Taxation No:540)
Approval No:4/2013 Date:22.06.2013 (Taxation No:541)
BLOCK 7 APPROVED DETAILS
Tiruvenkadanathapuram Panchayat Approved Vide
Date:1994-1995 Taxation No:528
BLOCK 8 APPROVED DETAILS
Tiruvenkadanathapuram Panchayat Approved Vide
Date:1996-1997 Taxation No:533,534
BLOCK 9 APPROVED DETAILS
Tiruvenkadanathapuram Panchayat Approved Vide
Approval No:4/2005 Date:08/09/2005

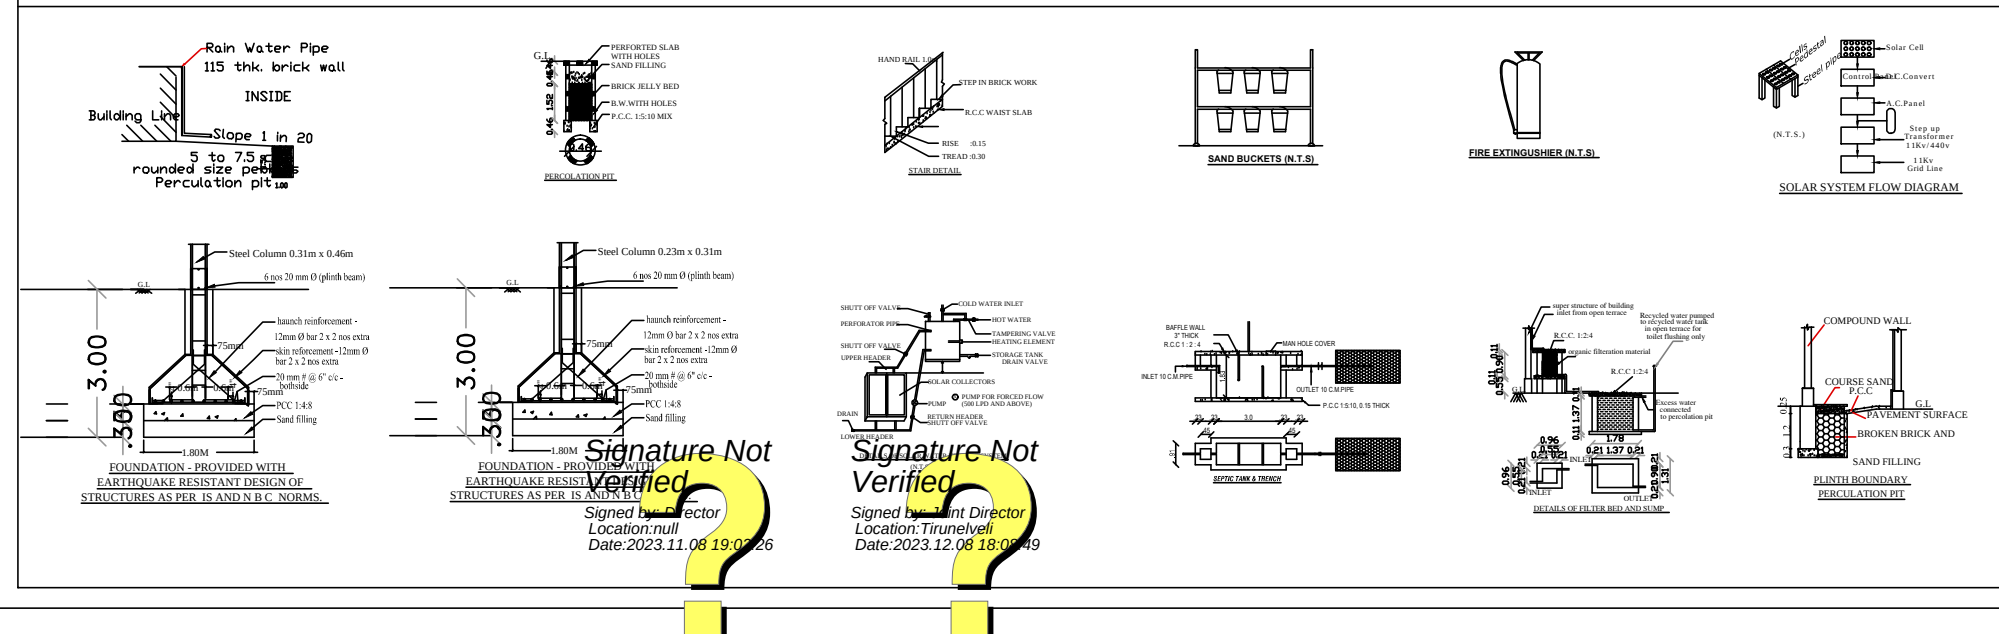

V.K. Ashok Kumaravel, B.E., M.E., AIV, (Pw),
Civil & Structural Engineer
Registered Construction Engineer
Reg.No. RCE/TVL/January/2020/018

CONSTRUCTION ENGINEER

V.K. Ashok Kumaravel, B.E., M.E., AIV, (Pw),
Civil & Structural Engineer
Registered Structural Engineer Grade I
Reg.No. RSE/Gr-I/TVL/January/2020/019

STRUCTURAL ENGINEER

for DAYALBAGH EDUCATIONAL INSTITUTE OFF CAMPUS

CO-ORDINATOR

APPLICANT

Dr. P. K. THAMEEMUL ANSARI B.E.
Reg. No. : RE/Gr-II/TVL/March/2019/006
35 / 13-2, Firthous Complex, Ambai Road,
Melapalayam, (Sub-Registrar Office Building)
Tirunelveli - 627 005. Cell : 9488237454.

REG.ENGINEER