

KEY PLAN [N.T.S]

PLAN SHOWING THE PROPOSED CONSTRUCTION OF INDUSTRIAL BUILDING AT PLOT NO: A-3/2, A-4/1C & A-4/1E IN OLD S.NO:32 / 2(PART) & 33/2A, NEW S.NO:32 / 3, 33 / 3, SIPCOT INDUSTRIAL PARK, THERVOYKANDIGAI VILLAGE, GUMMIDIPPOondi TALUK, THIRUVALLUR DISTRICT - 601202.

CLIENT NAME: M.S. TVS INDEON LIMITED

DRAWING TITLE :

MAIN FACTORY GROUND , MEZZANINE & ROOF , ELEVATION , SECTION PLAN

AREA STATEMENT :-

S.NO	DESCRIPTION	AREA IN SQ.M
1	GROUND FLOOR	3753.40
2	MEZZANINE FLOOR	943.74
	TOTAL	4697.14

SCHEDULE OF JOINERY

TYPE	DESCRIPTION	SIZE IN MM
RS1	ROLLING SHUTTER	4000 x 3500
RS2	ROLLING SHUTTER	3000 x 4000
RS3	GRILLED ROLLING SHUTTER	3000 x 3000
RS4	GRILLED ROLLING SHUTTER	2000 x 3000
FED	FIRE ESCAPE SINGLE LEAF WITH VISION PANEL & PANIC BAR	1200 X 2500
SD1	STEEL DOOR DOUBLE LEAF WITH VISION PANEL	1800 X 2500
SD2	STEEL DOOR DOUBLE LEAF WITH VISION PANEL	1500 X 2500
SD3	STEEL DOOR SINGLE LEAF WITH VISION PANEL	1200 X 2500
FRG1	DOUBLE LEAF SLIDING GLASS DOOR	1800 X 2500
FRG2	SINGLE LEAF SLIDING GLASS DOOR	1800 X 2500
FRG3	SINGLE LEAF SLIDING GLASS DOOR	1200 X 2500
SLD1	SINGLE LEAF SLIDING GLASS DOOR	1800 X 2500
SLD2	DOUBLE LEAF SLIDING GLASS DOOR	1800 X 2500
D1	T.W.FLUSH DOOR SINGLE LEAF WITH VISION PANEL	1000 X 2100
D2	T.W.FLUSH DOOR SINGLE LEAF WITH VISION PANEL	900 X 2100
D3	T.W.FLUSH DOOR SINGLE LEAF WITHOUT VISION PANEL	800 X 2100
D4	T.W.FLUSH DOOR SINGLE LEAF WITHOUT VISION PANEL AND GRILL	750 X 2100
TD	TRAP DOOR SINGLE LEAF	750 X 1500
FG1	FIXED GLASS	5000 X 1500
FG2	FIXED GLASS	2000 X 1500

SCHEDULE OF JOINERY (MEZZANINE FLOOR)

TYPE	DESCRIPTION	SIZE IN MM
FED	FIRE ESCAPE SINGLE LEAF WITH VISION PANEL & PANIC BAR	1200 X 2500
SD1	STEEL DOOR DOUBLE LEAF WITH VISION PANEL	1800 X 2500
SD2	STEEL DOOR DOUBLE LEAF WITH VISION PANEL	1500 X 2500
SD3	STEEL DOOR SINGLE LEAF WITH VISION PANEL	1200 X 2500
D1	T.W.FLUSH DOOR SINGLE LEAF WITH VISION PANEL	1000 X 2100
D3	T.W.FLUSH DOOR SINGLE LEAF WITHOUT VISION PANEL	800 X 2100
D4	T.W.FLUSH DOOR SINGLE LEAF WITHOUT VISION PANEL AND GRILL	750 X 2100
TD	TRAP DOOR SINGLE LEAF	750 X 1500

NOTE:

Scale : All dimension are in meter

Scale : 1:100

COLOUR INDEX :

	PROPOSED
	ROAD
	BOUNDARY

For TVS INDEON LIMITED


M. S. TVS INDEON LIMITED
AUTHORISED SIGNATORY

OWNER SIGNATURE


STRUCTURAL ENGINEER SIGNATURE

ARCHITECT SIGNATURE

S A Constructions & Consultancy Pvt Ltd
NO:41, Winkley Street, VGN Victoria park,
Ambattur, Chennai-600053
(M)-91 9841613506 - 9382161397

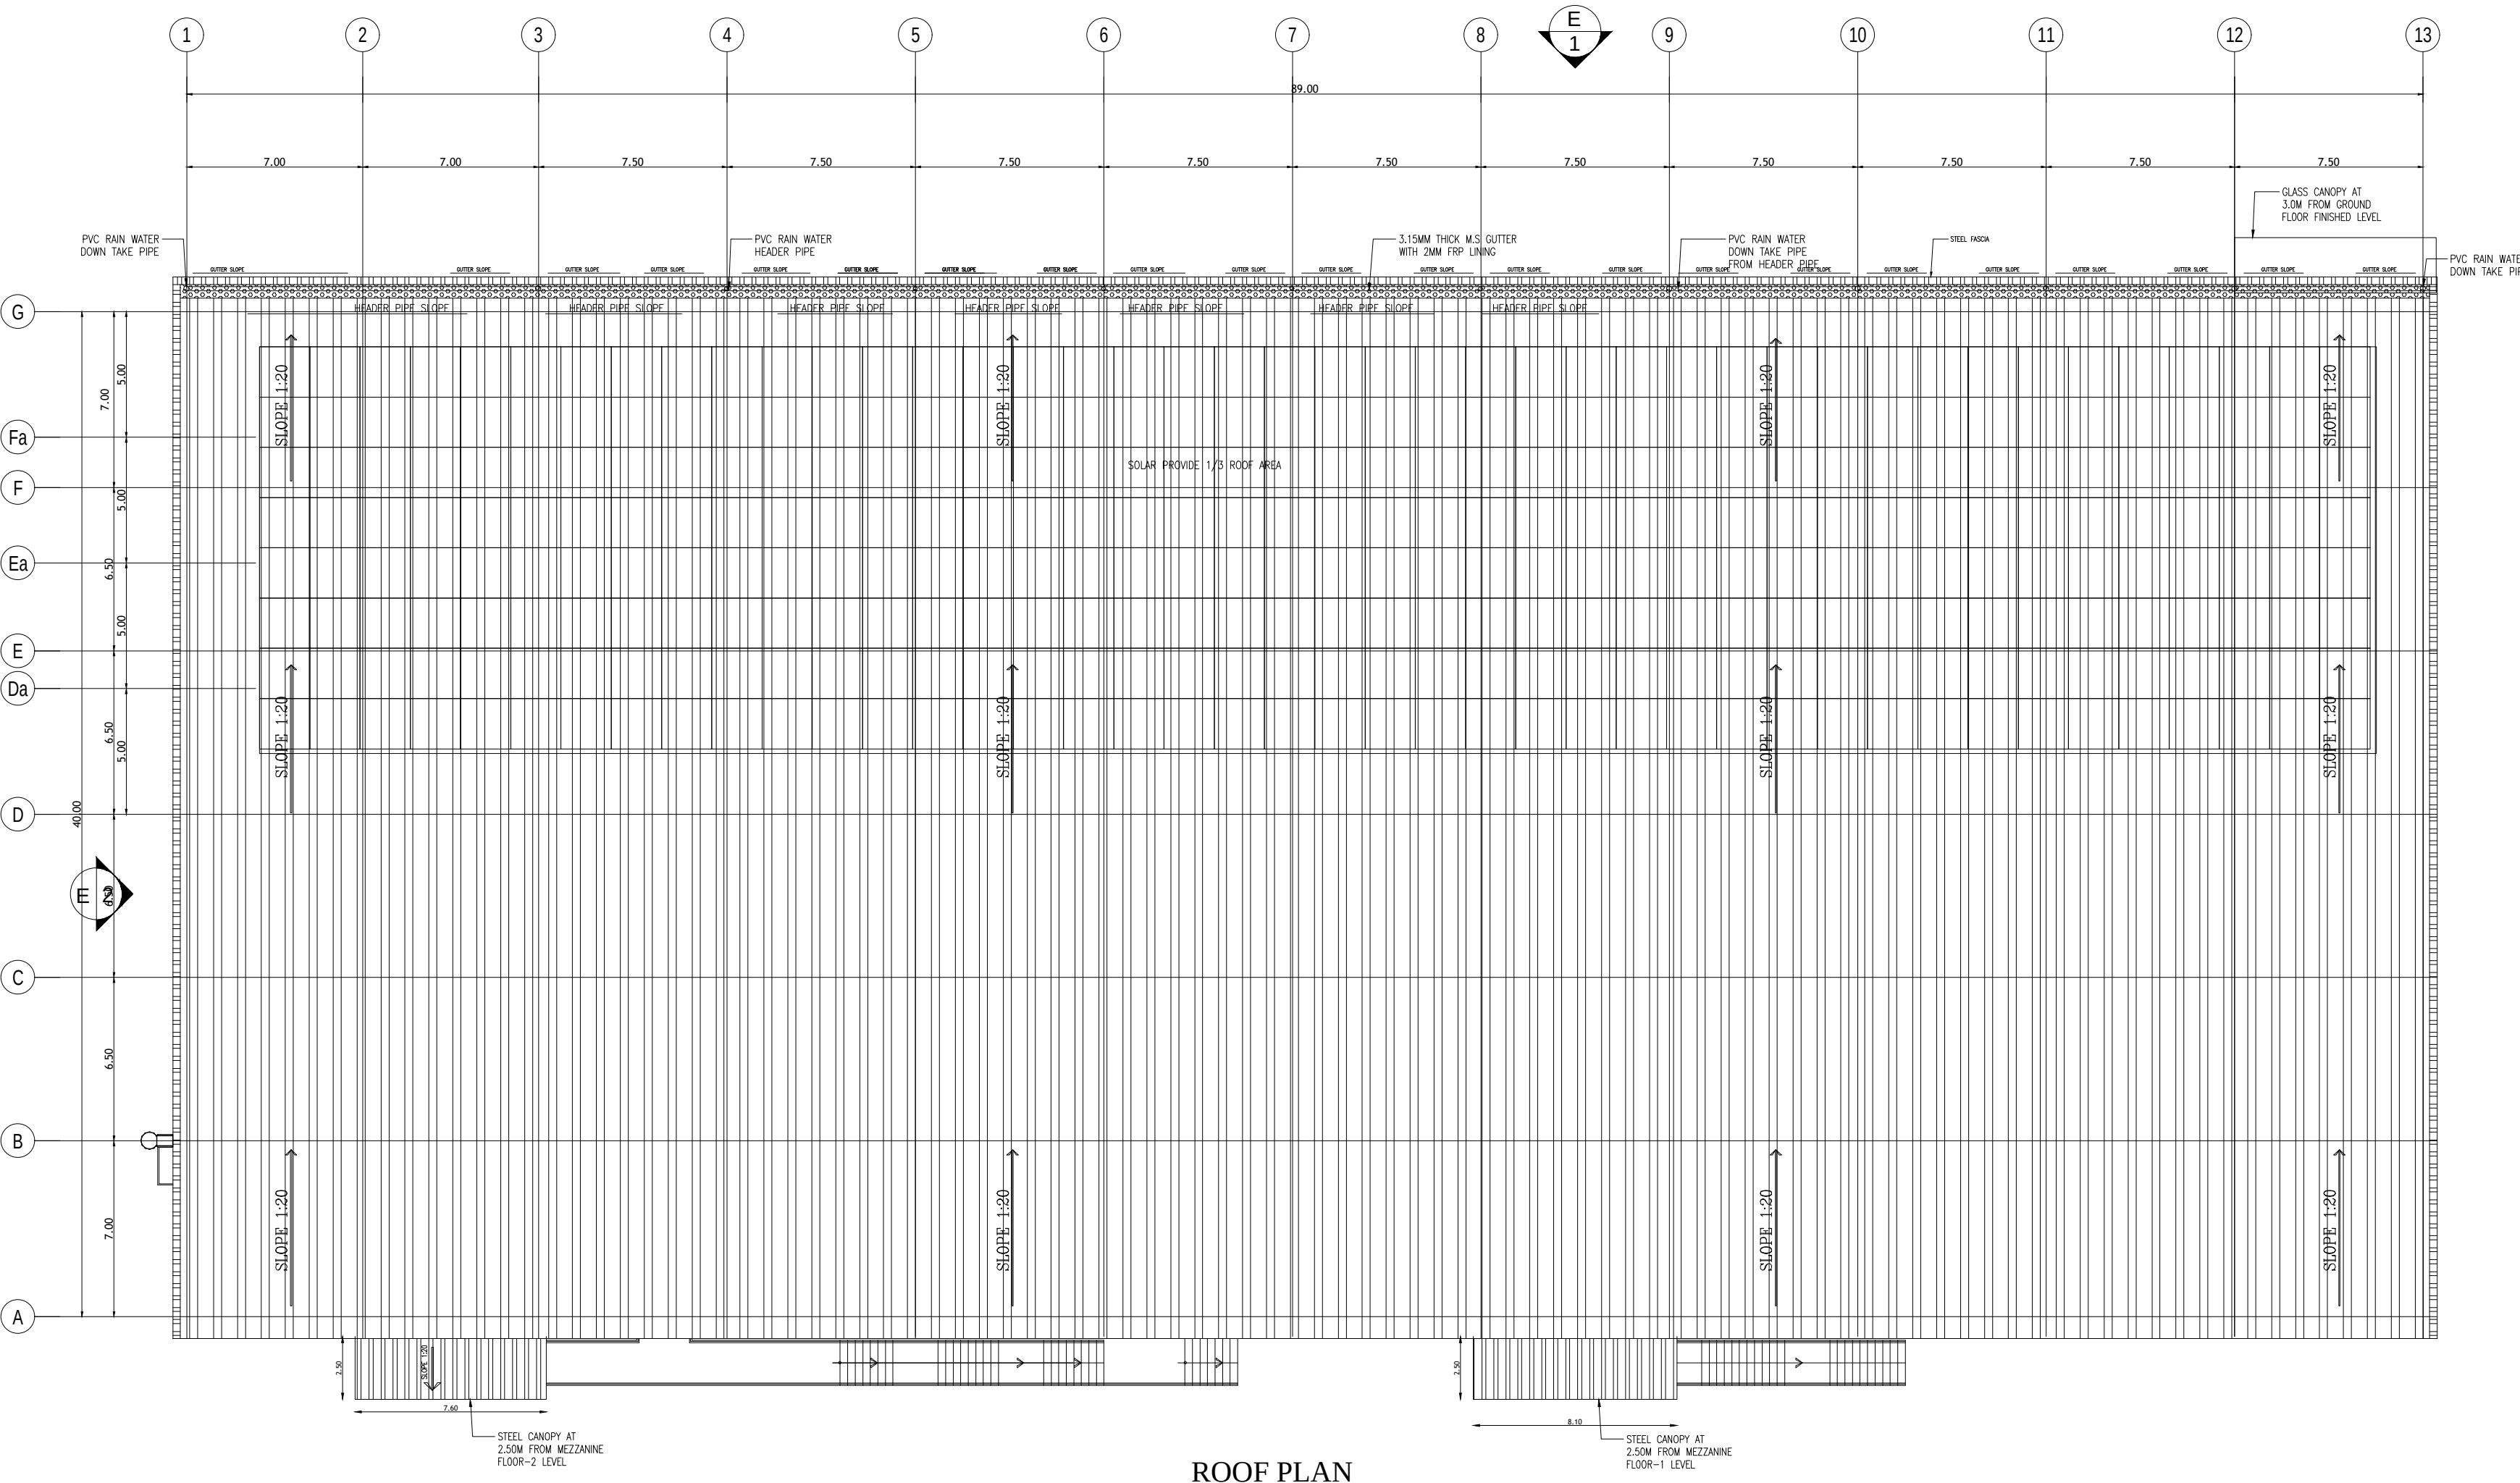


ROOF PLAN

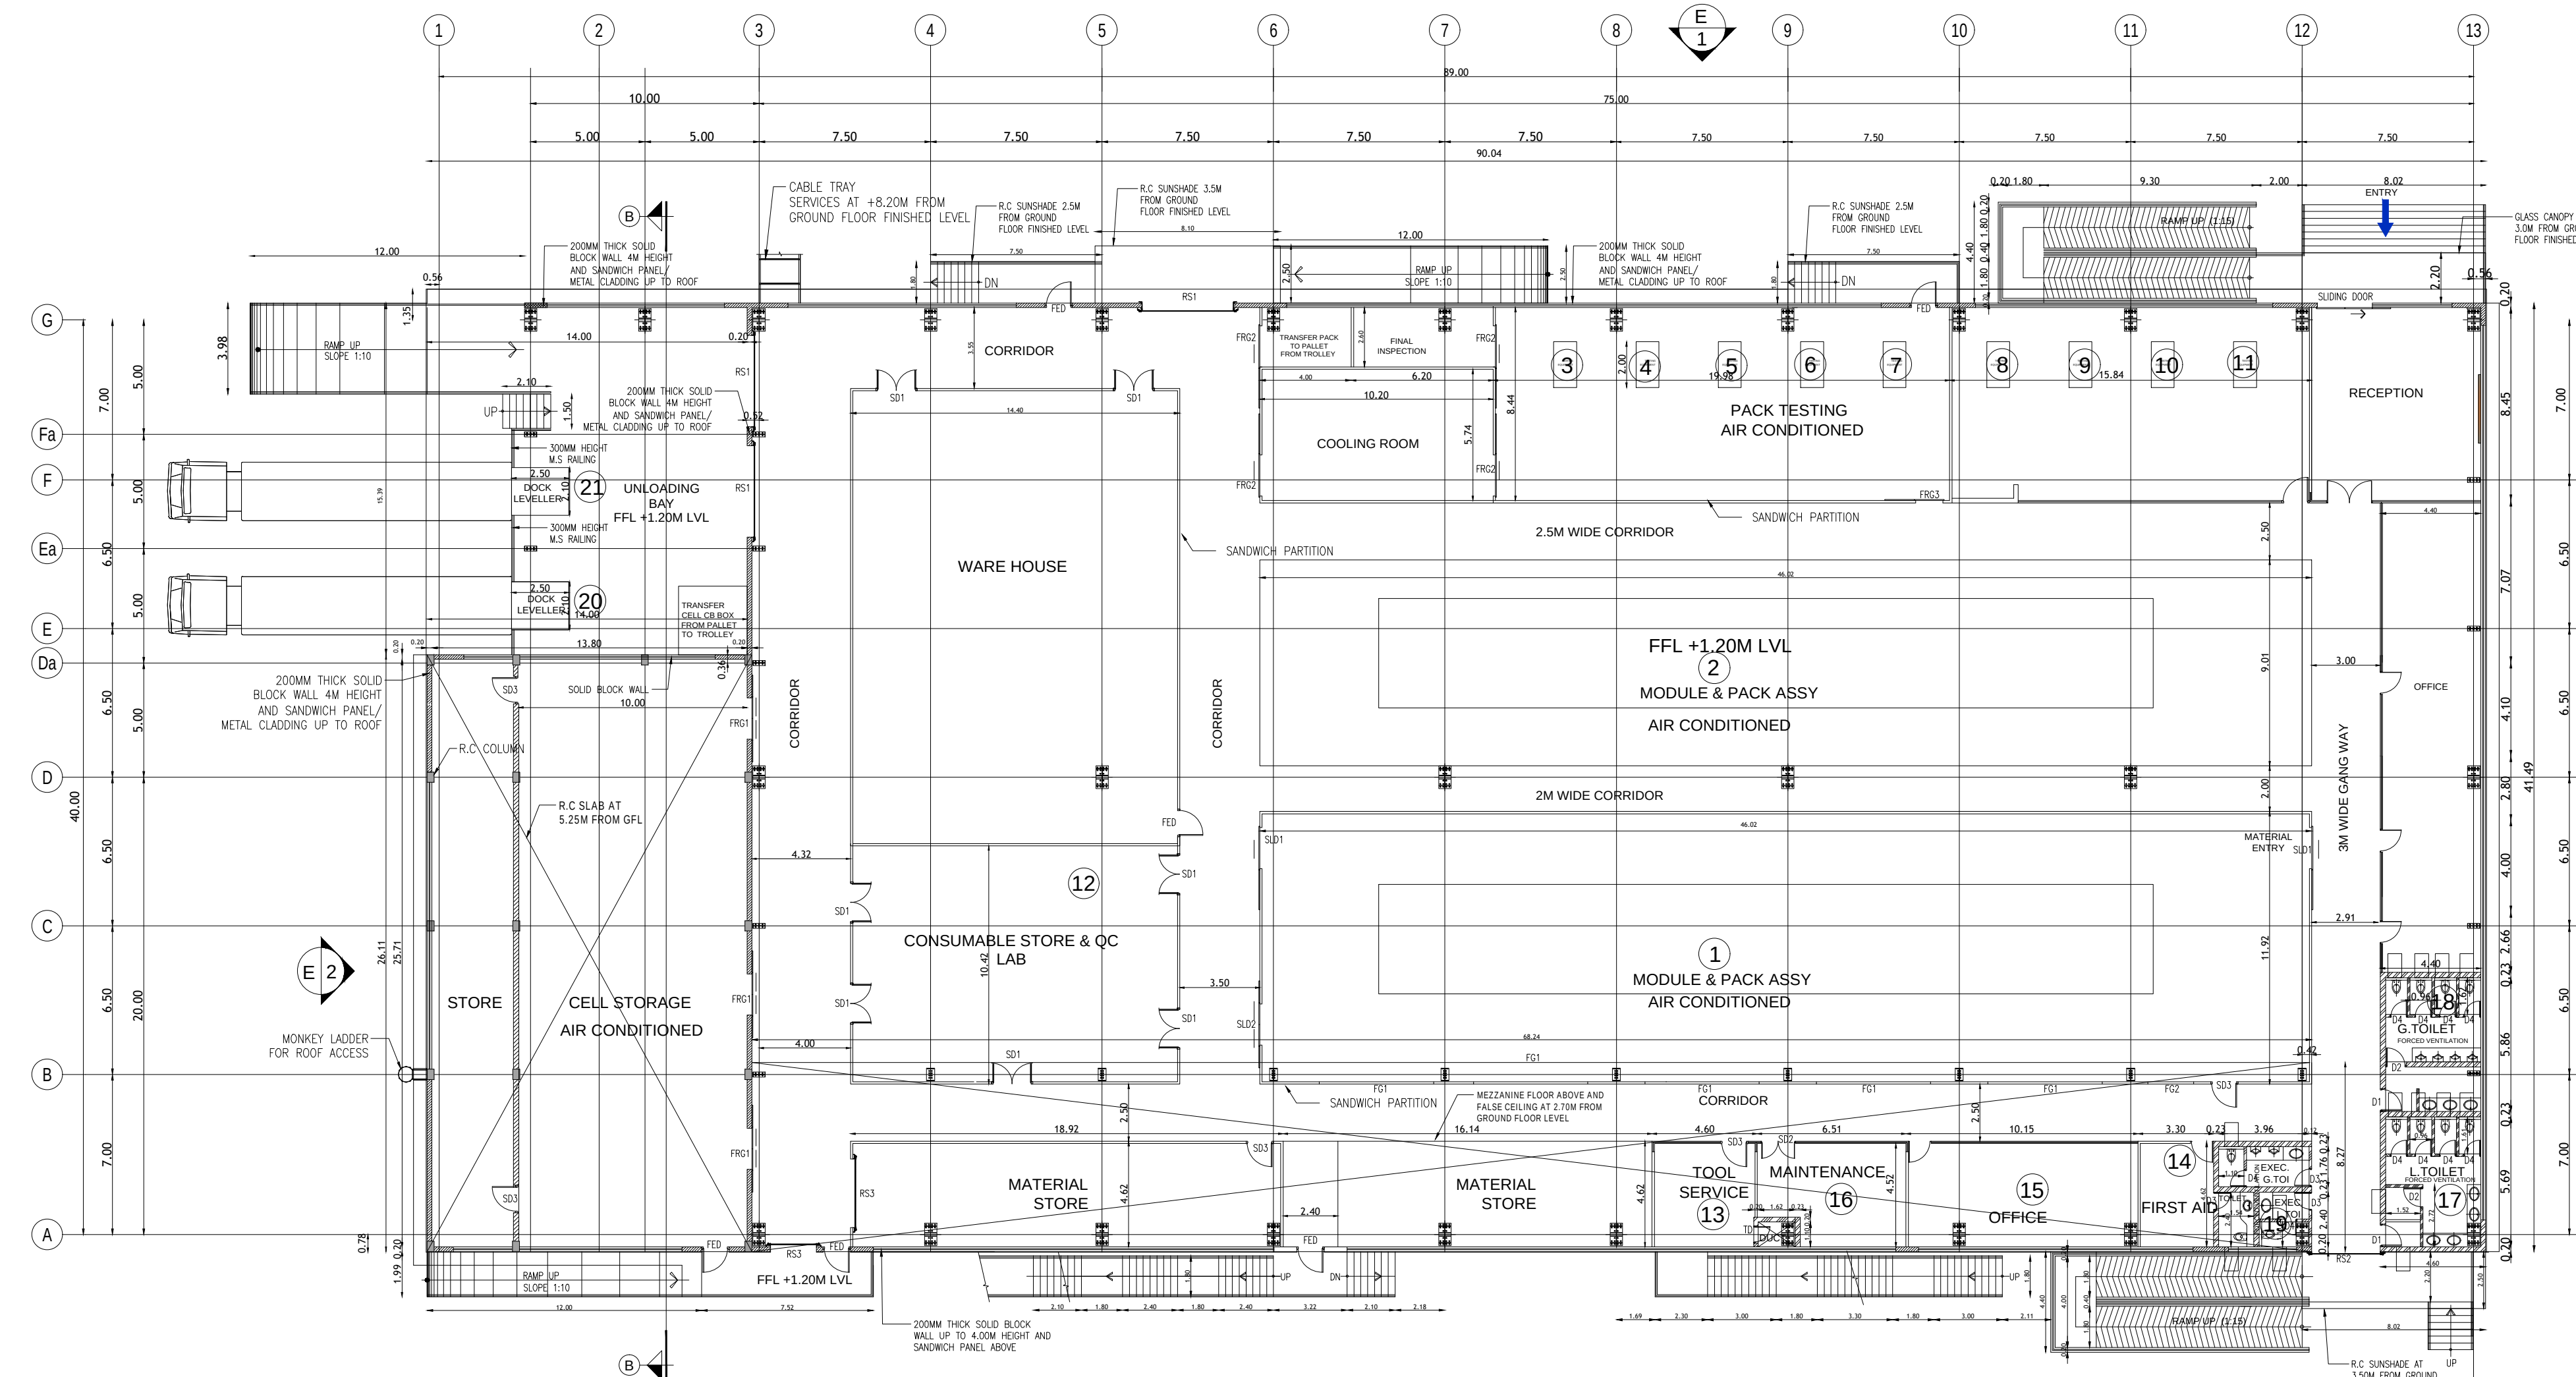


GROUND FLOOR PLAN


SCALE [1:100]

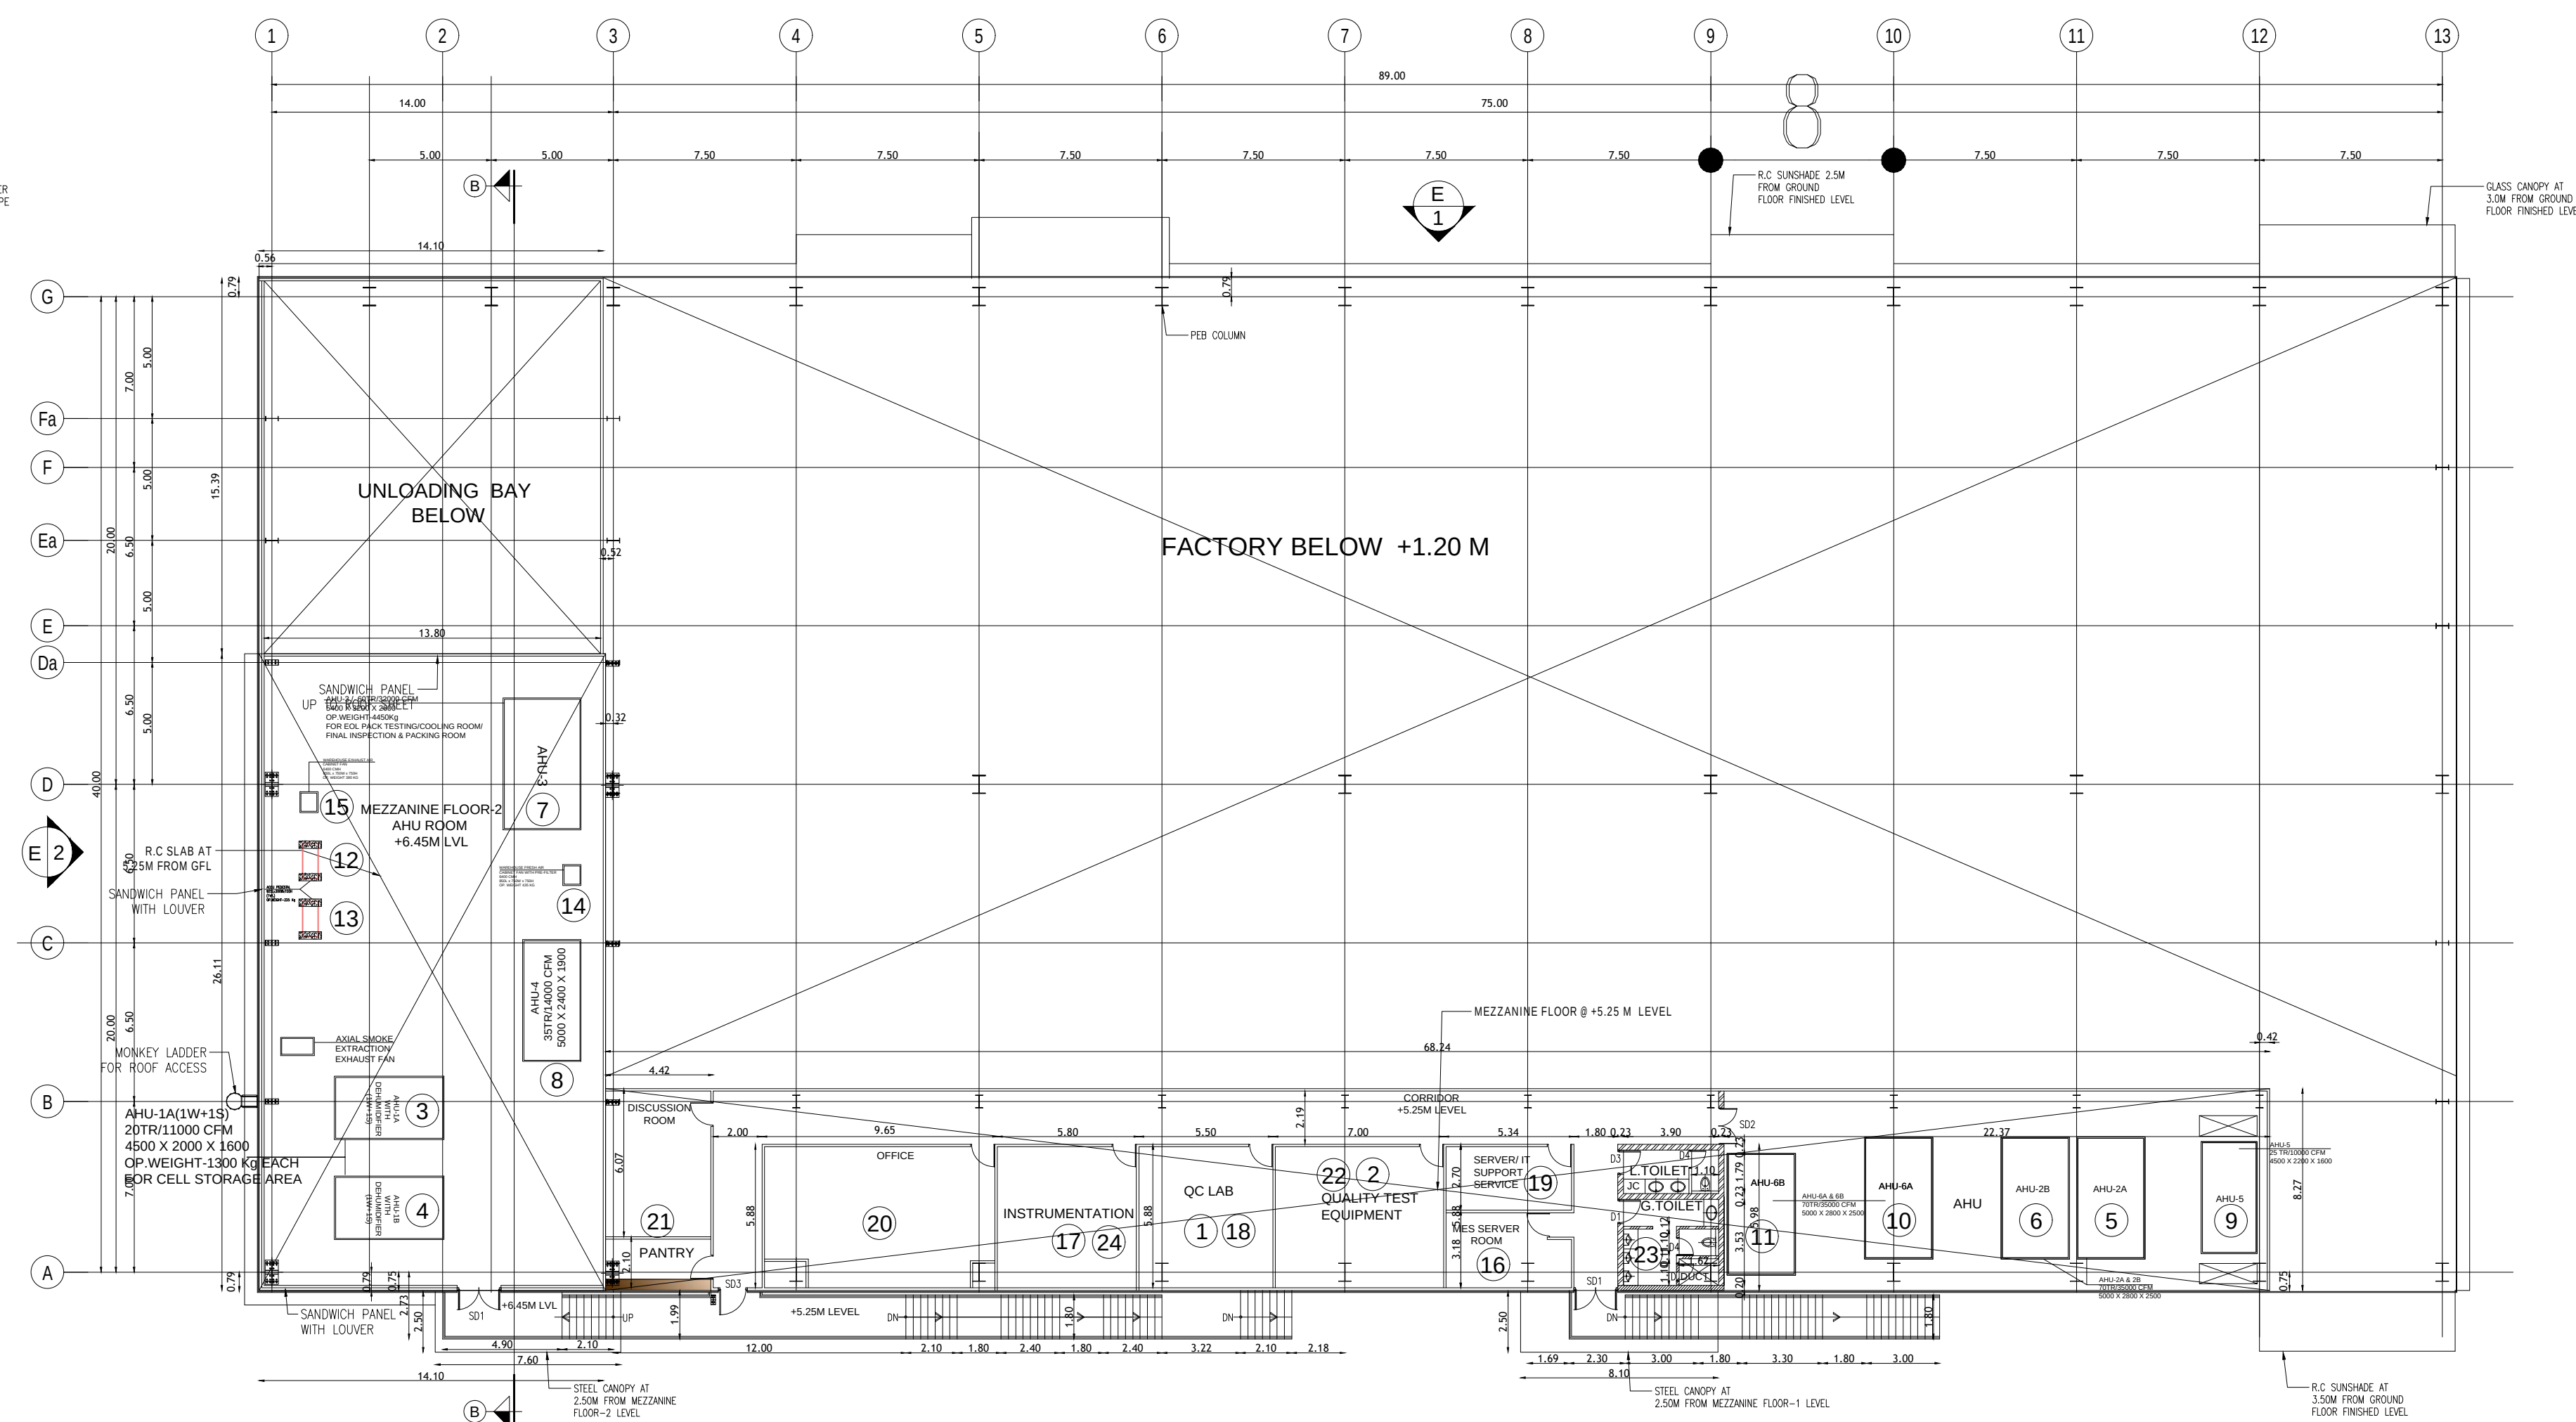

MEZZANINE FLOOR [1:100]

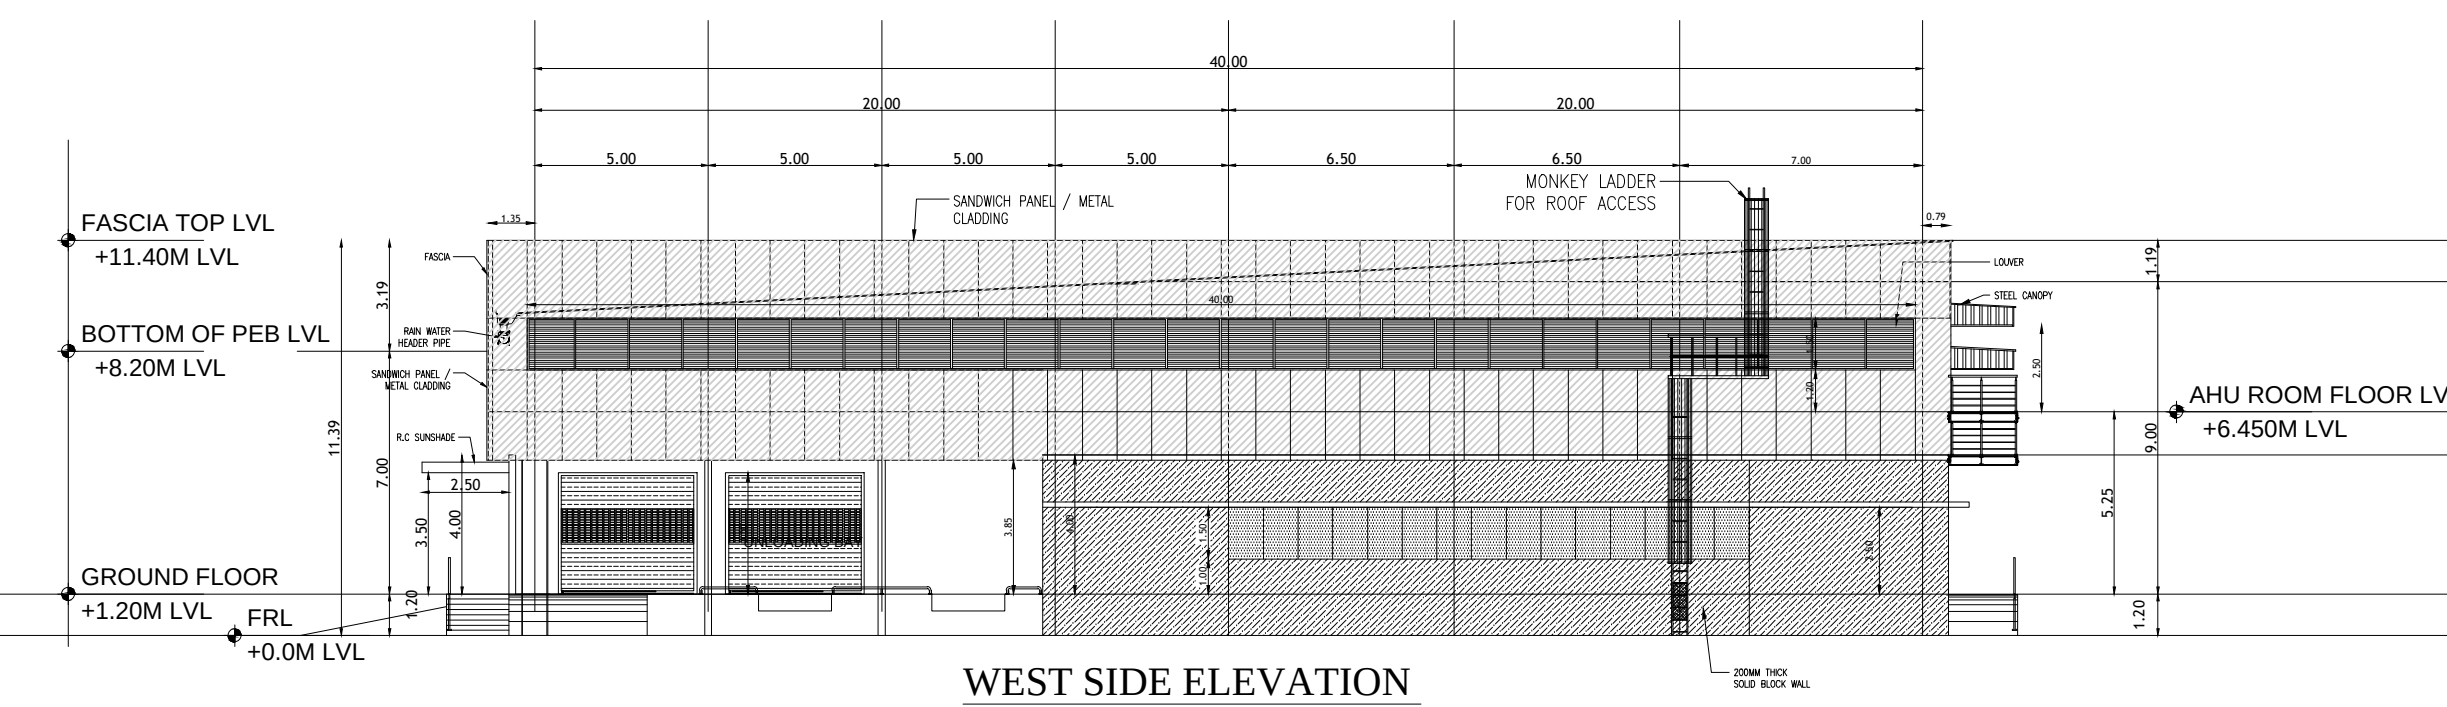

WEST SIDE ELEVATION

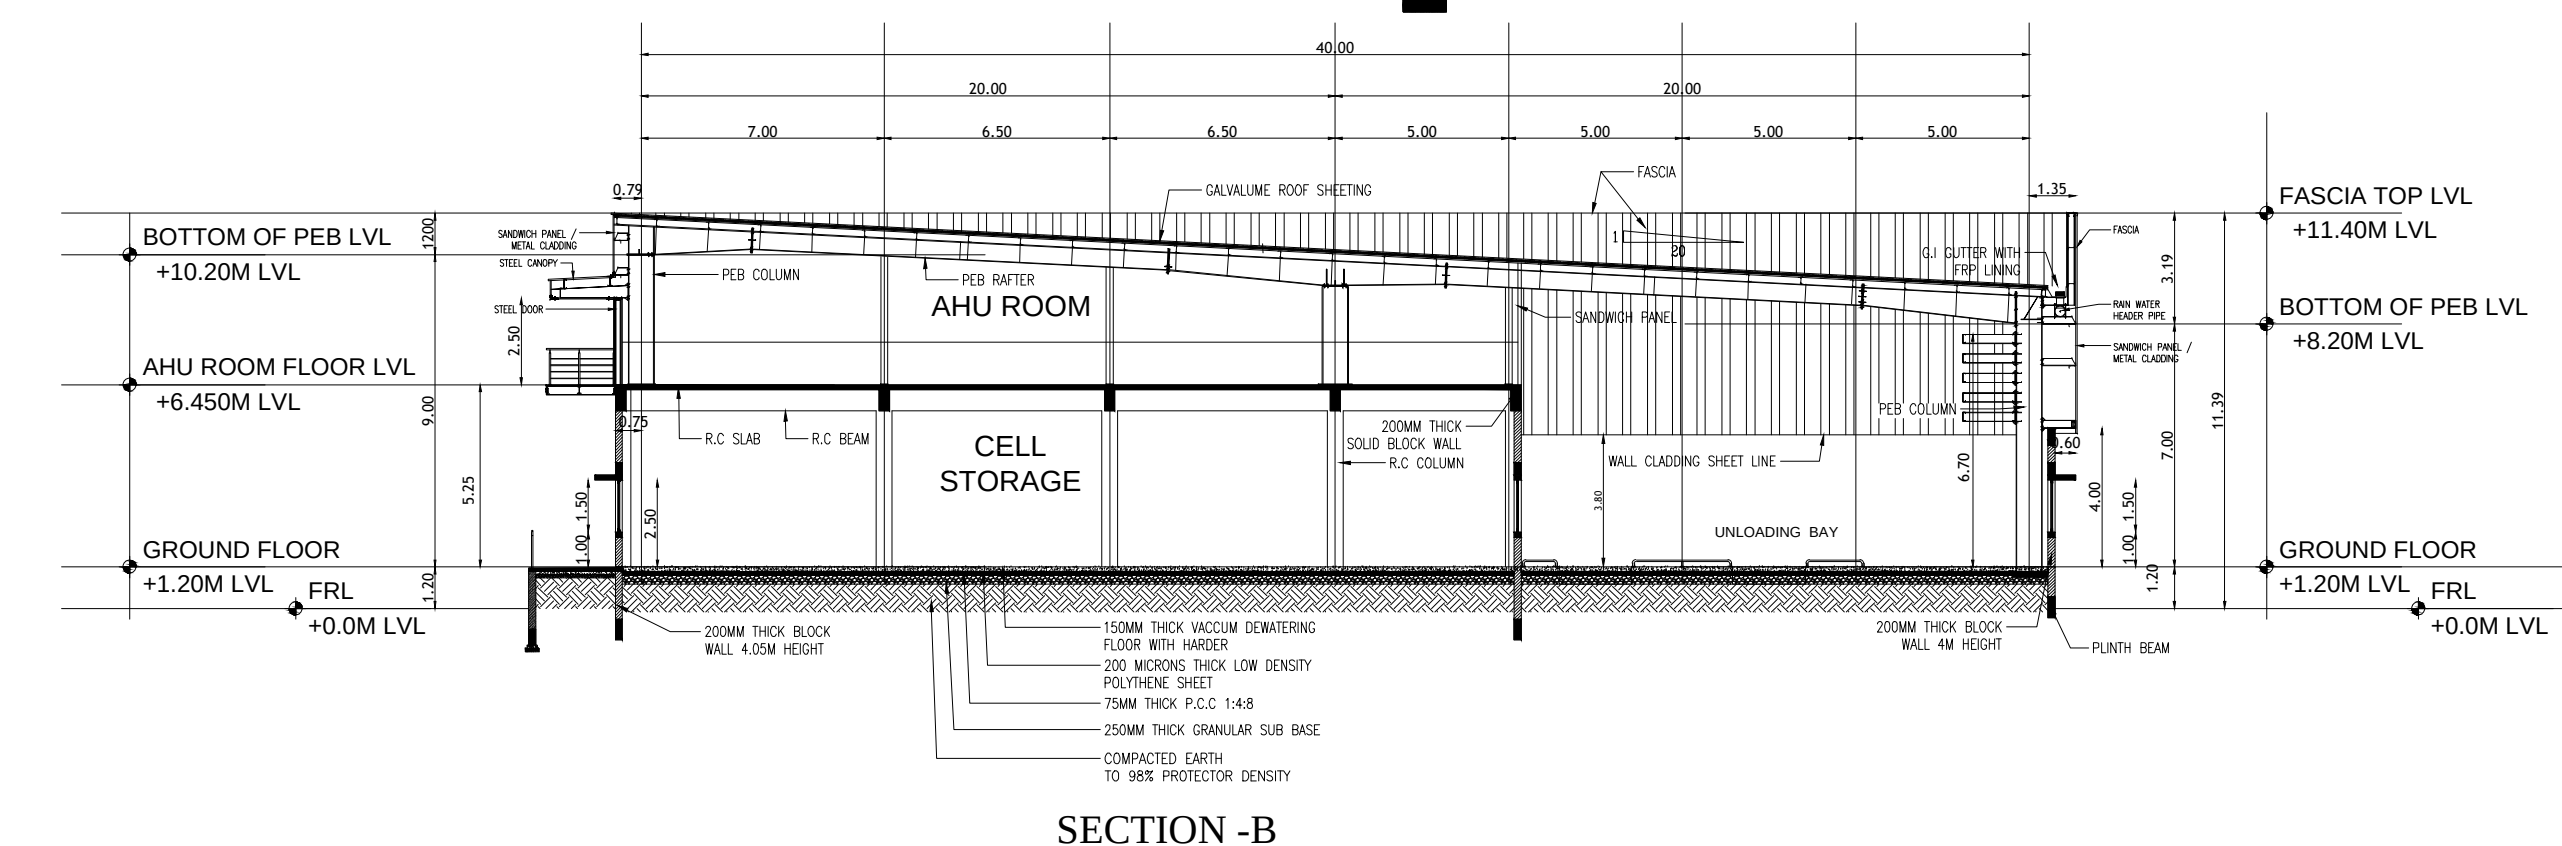


SECTION - B


HP DETAILS :-

Sr no	Equipment	Sub-Equipment	Connected load (kW)
Ground Floor			
1	Process	Module & Pack assembly	400.0
2	Process	Module & Pack assembly	400.0
3	Process	Testing Equipment	27.0
4	Process	Testing Equipment	27.0
5	Process	Testing Equipment	27.0
6	Process	Testing Equipment	27.0
7	Process	Testing Equipment	27.0
8	Process	Testing Equipment	27.0
9	Process	Testing Equipment	27.0
10	Process	Testing Equipment	27.0
11	Process	Testing Equipment	27.0
12	Process	Vibration Testing	35.0
13	HVAC	Tool Service Room- Split AC Unit	1.35
14	HVAC	First Aid Room- Split AC Unit	1.95
15	HVAC	Workstation- Split AC	7.80
16	HVAC	Maintenance Room- Split AC Unit	2.60
17	HVAC	Online Exhaust Fan	0.55
18	HVAC	Online Exhaust Fan	0.55
19	HVAC	Online Exhaust Fan	0.55
20	Process	Dock leveler	3.50
21	Process	Dock leveler	3.50
TOTAL			1276.30

Sr no	Equipment	Sub-Equipment	Connected load (kW)
Mezzanine Floor			
1	Process	QC Lab	10.00
2	Process	Quality Testing Equipment	10.00
3	Process	Quality Testing Equipment	10.00
4	Process	Quality Testing Equipment	10.00
100	Process	Quality Testing Equipment	10.00
TOTAL			885.81

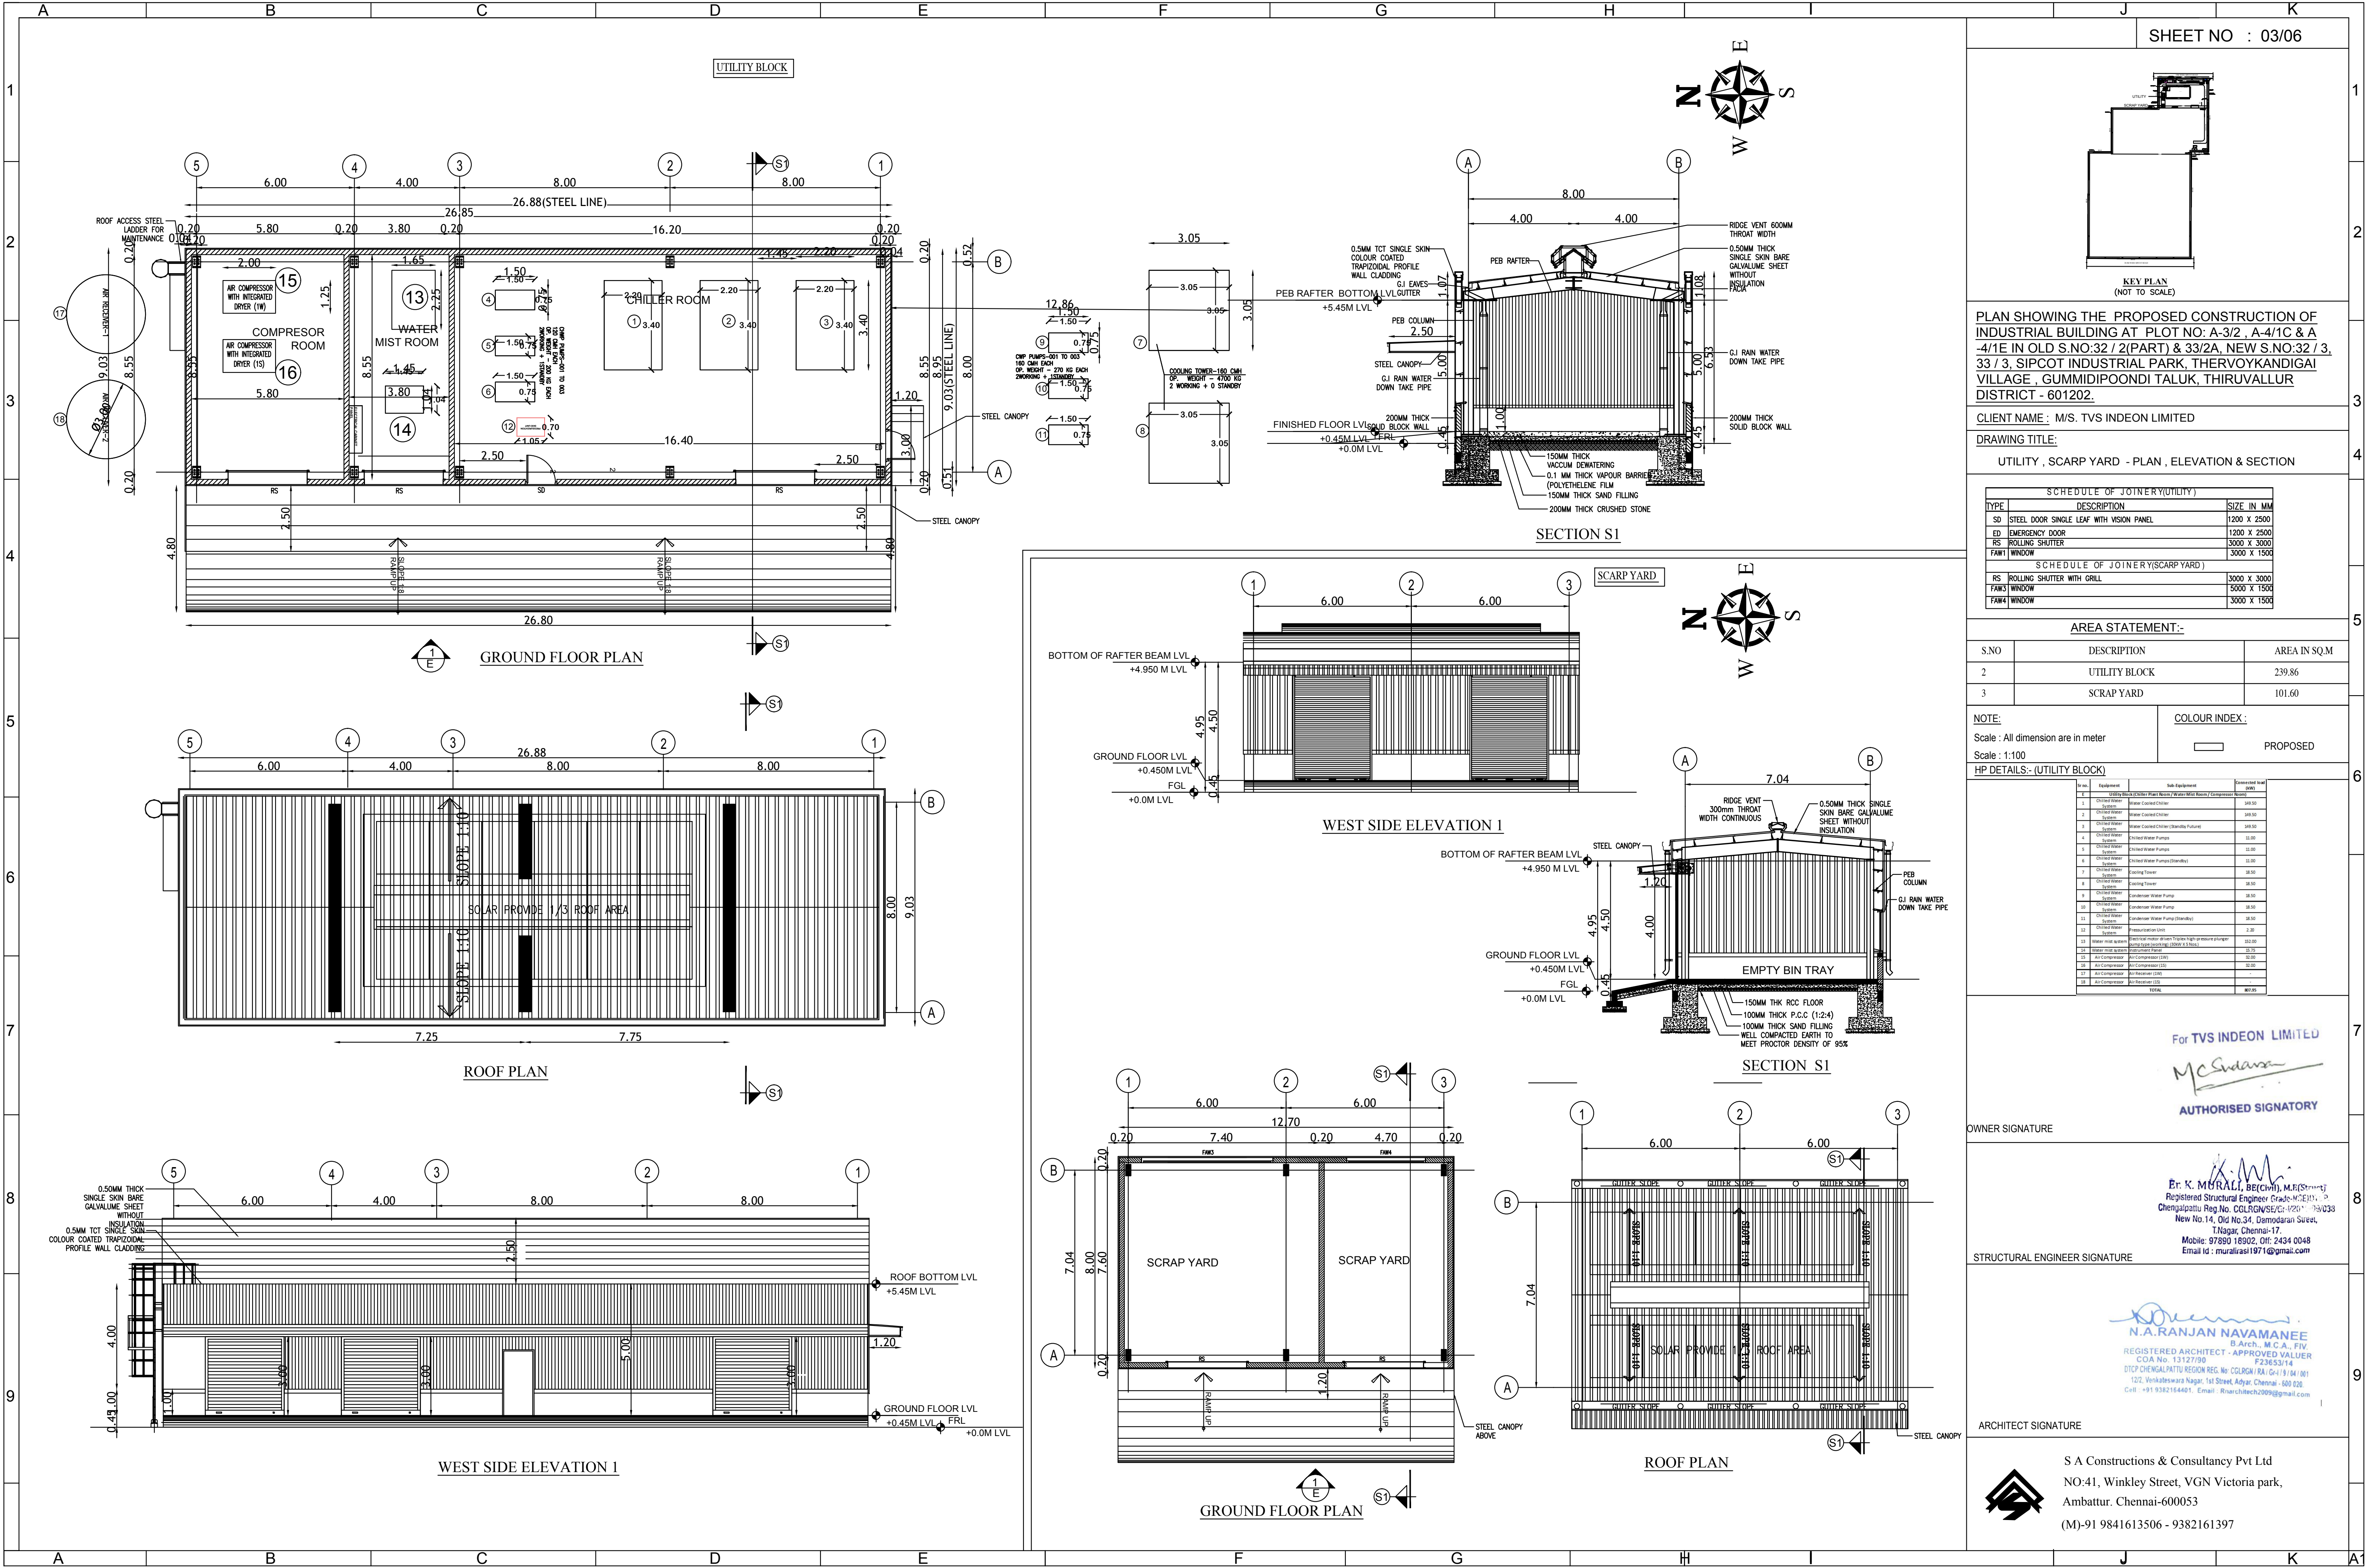

SHEET NO : 03/06

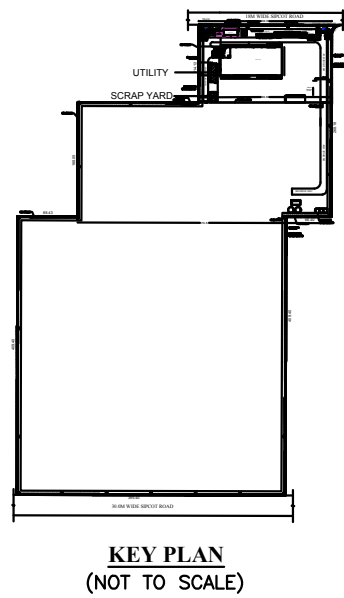

PLAN SHOWING THE PROPOSED CONSTRUCTION OF INDUSTRIAL BUILDING AT PLOT NO: A-3/2, A-4/1C & A-4/1E IN OLD S.NO:32 / 2(PART) & 33/2A, NEW S.NO:32 / 3, 33 / 3, SIPCOT INDUSTRIAL PARK, THERVOYKANDIGAI VILLAGE, GUMMIDIPOONDI TALUK, THIRUVALLUR DISTRICT - 601202.

CLIENT NAME : M/S. TVS INDEON LIMITED

DRAWING TITLE:

UTILITY, SCARP YARD - PLAN, ELEVATION & SECTION

SCHEDULE OF JOINERY(UTILITY)		
TYPE	DESCRIPTION	SIZE IN MM
SD	STEEL DOOR SINGLE LEAF WITH VISION PANEL	1200 X 2500
ED	EMERGENCY DOOR	1200 X 2500
RS	ROLLING SHUTTER	3000 X 3000
FWW1	WINDOW	3000 X 1500

SCHEDULE OF JOINERY(SCARP YARD)		
RS	ROLLING SHUTTER WITH GRILL	3000 X 3000
FWW2	WINDOW	3000 X 1500
FWW4	WINDOW	3000 X 1500

AREA STATEMENT:-

S.NO	DESCRIPTION	AREA IN SQ.M
2	UTILITY BLOCK	239.86
3	SCARP YARD	101.60

NOTE:

Scale : All dimension are in meter
Scale : 1:100

COLOR INDEX :

PROPOSED

HP DETAILS:- (UTILITY BLOCK)

Sl. No.	Equipment	Qty	Unit	Remarks	Connected Load (KW)
1	Utility Block (Electricity Meter Room)	1	Room	Compressor Room	100.00
2	Chiller Room	1	Room	Water Cooled Chiller	100.00
3	Chiller Room	1	Room	Water Cooled Chiller (Standby Future)	100.00
4	Chiller Room	1	Room	Chiller Water Pump	10.00
5	Chiller Room	1	Room	Chiller Water Pump (Standby)	10.00
6	Chiller Room	1	Room	Chiller Water Pump (Standby)	10.00
7	Chiller Room	1	Room	Chiller Water Pump (Standby)	10.00
8	Chiller Room	1	Room	Chiller Water Pump (Standby)	10.00
9	Chiller Room	1	Room	Chiller Water Pump (Standby)	10.00
10	Chiller Room	1	Room	Chiller Water Pump (Standby)	10.00
11	Chiller Room	1	Room	Chiller Water Pump (Standby)	10.00
12	Chiller Room	1	Room	Chiller Water Pump (Standby)	10.00
13	Chiller Room	1	Room	Chiller Water Pump (Standby)	10.00
14	Chiller Room	1	Room	Chiller Water Pump (Standby)	10.00
15	Chiller Room	1	Room	Chiller Water Pump (Standby)	10.00
16	Chiller Room	1	Room	Chiller Water Pump (Standby)	10.00
17	Chiller Room	1	Room	Chiller Water Pump (Standby)	10.00
18	Chiller Room	1	Room	Chiller Water Pump (Standby)	10.00
19	Chiller Room	1	Room	Chiller Water Pump (Standby)	10.00
20	Chiller Room	1	Room	Chiller Water Pump (Standby)	10.00






For TVS INDEON LIMITED
McSudana
AUTHORISED SIGNATORY

OWNER SIGNATURE

STRUCTURAL ENGINEER SIGNATURE

ARCHITECT SIGNATURE

S A Constructions & Consultancy Pvt Ltd
NO:41, Winkley Street, VGN Victoria park,
Ambattur, Chennai-600053
(M)-91 9841613506 - 9382161397

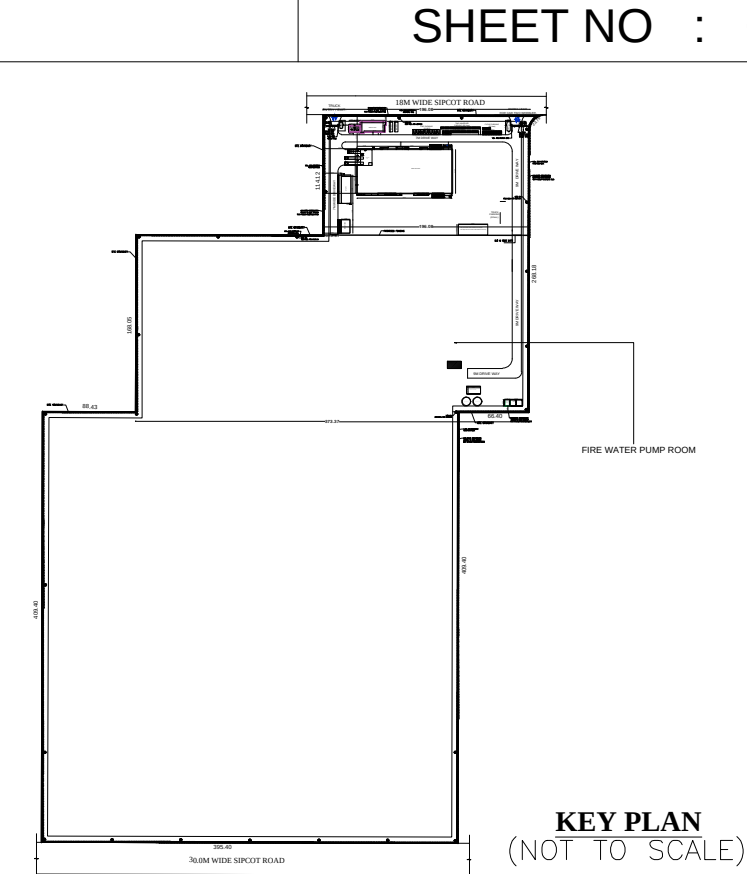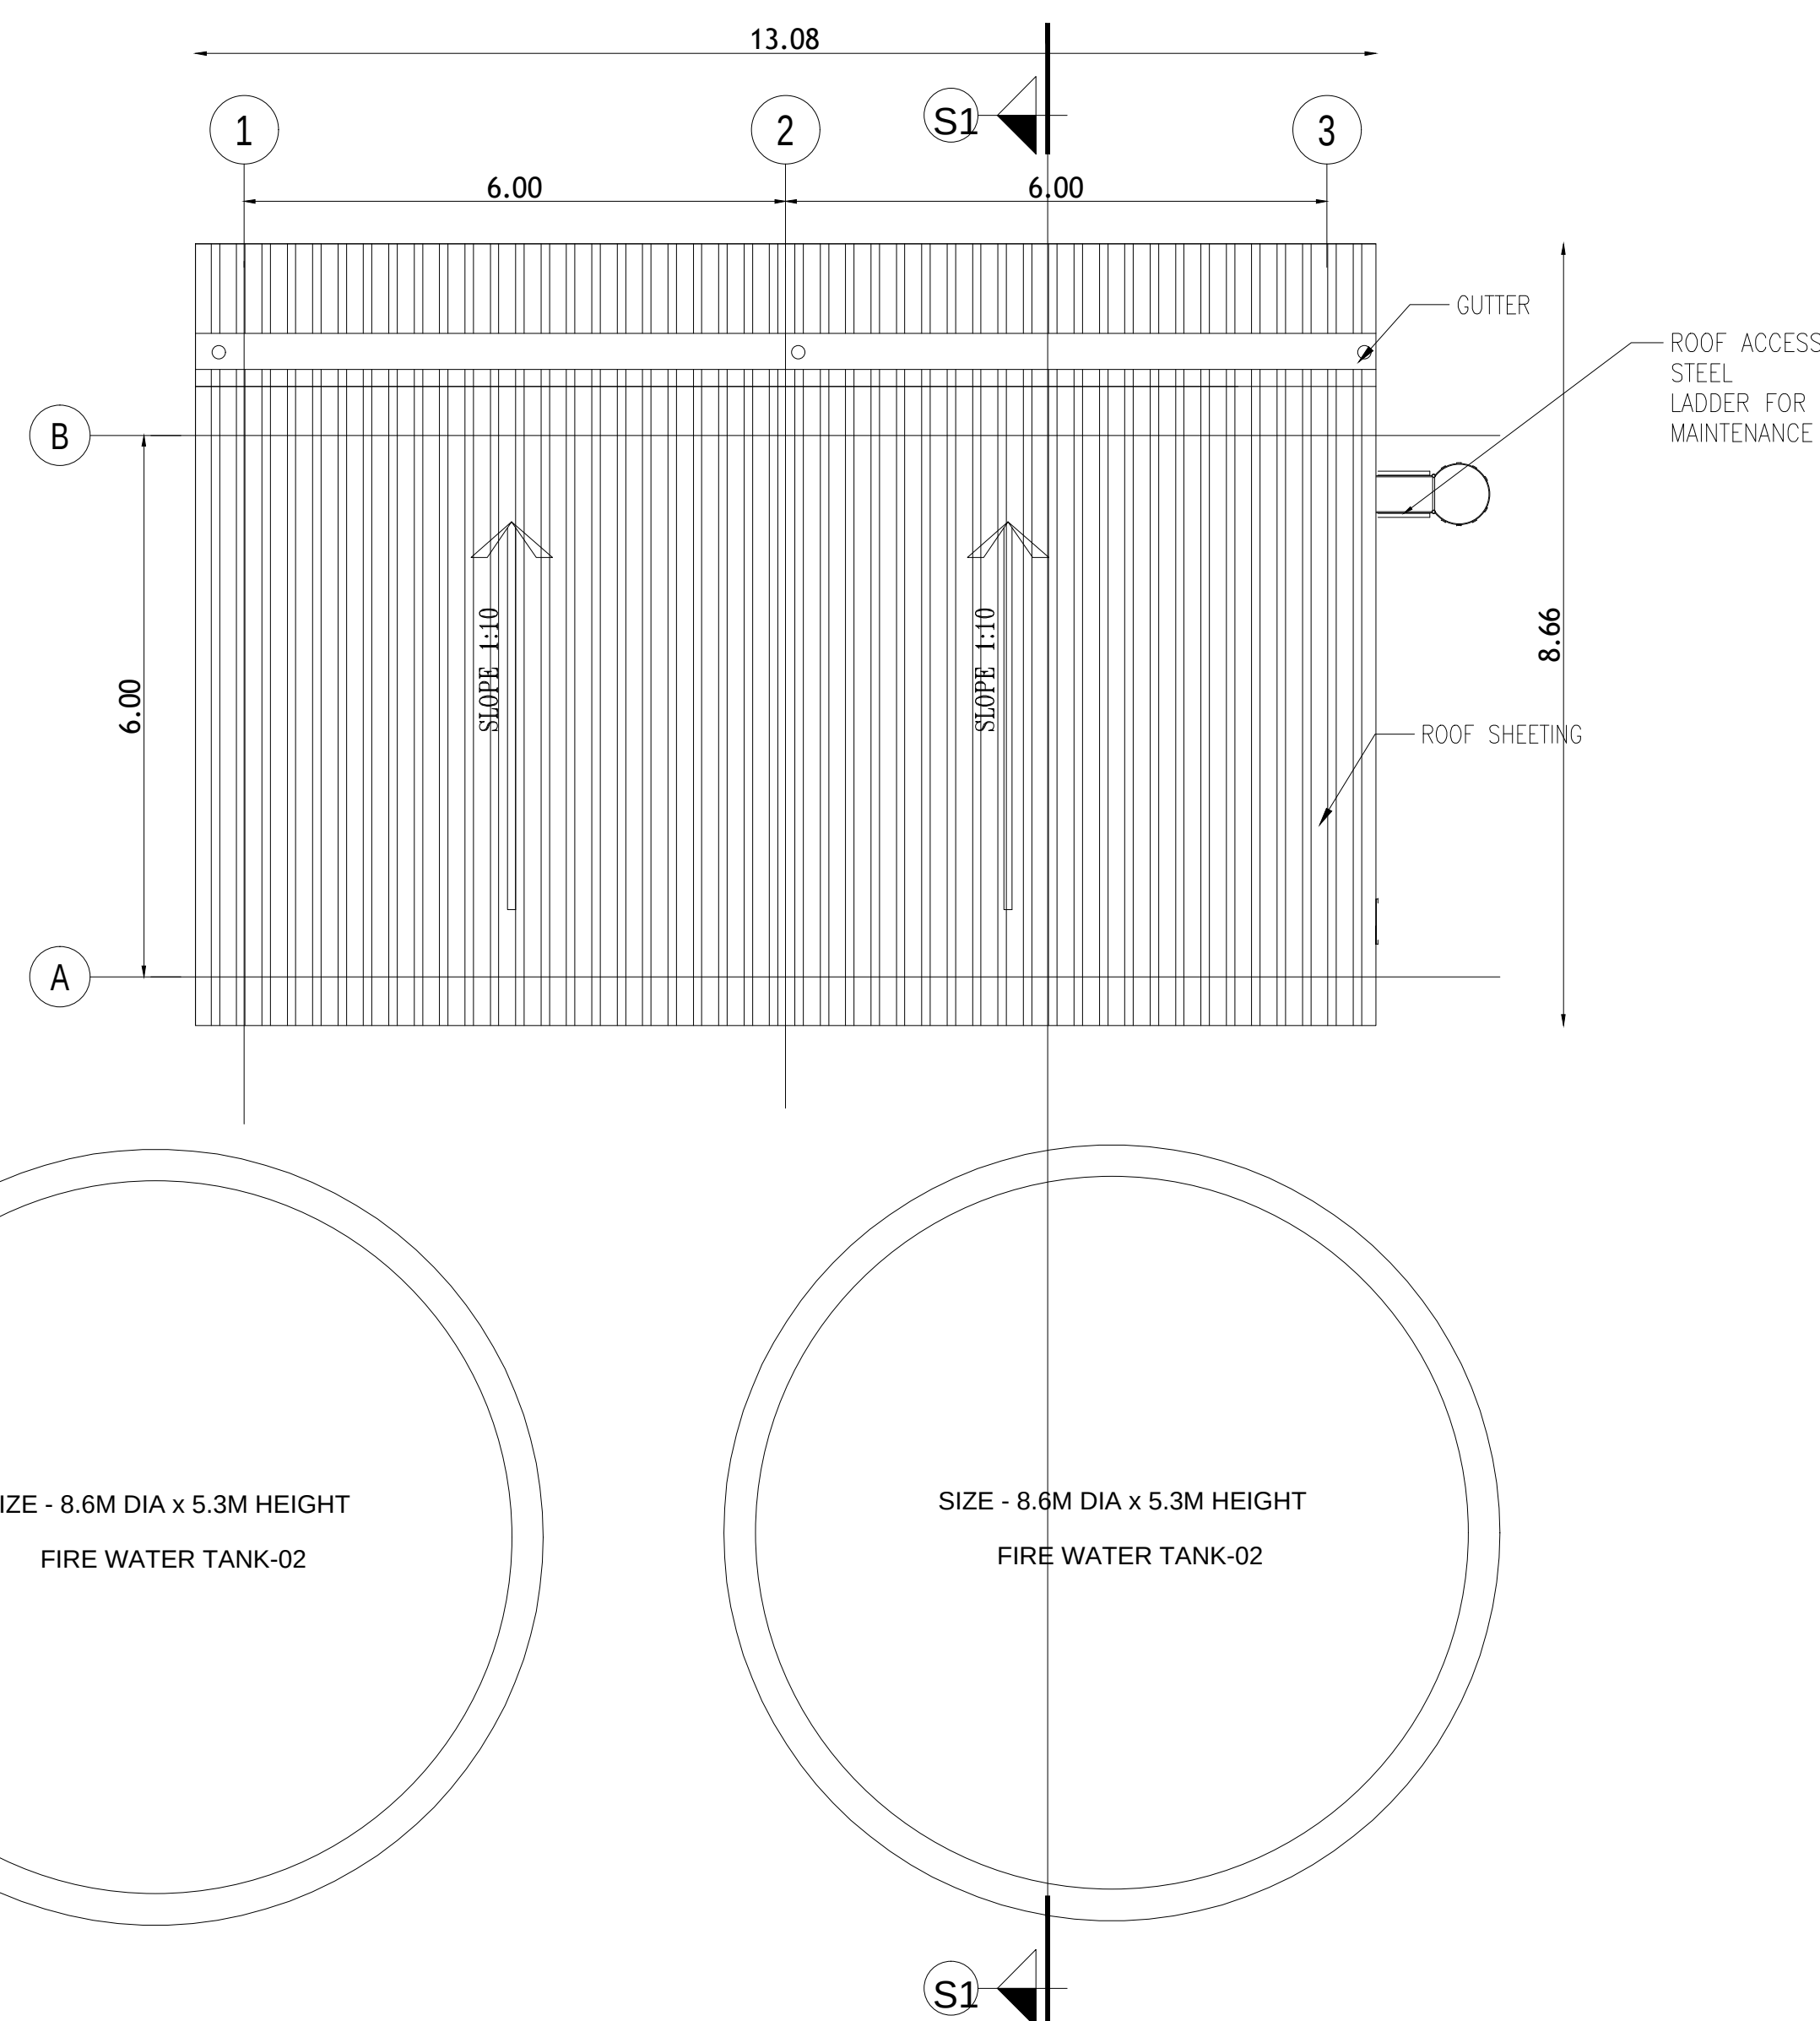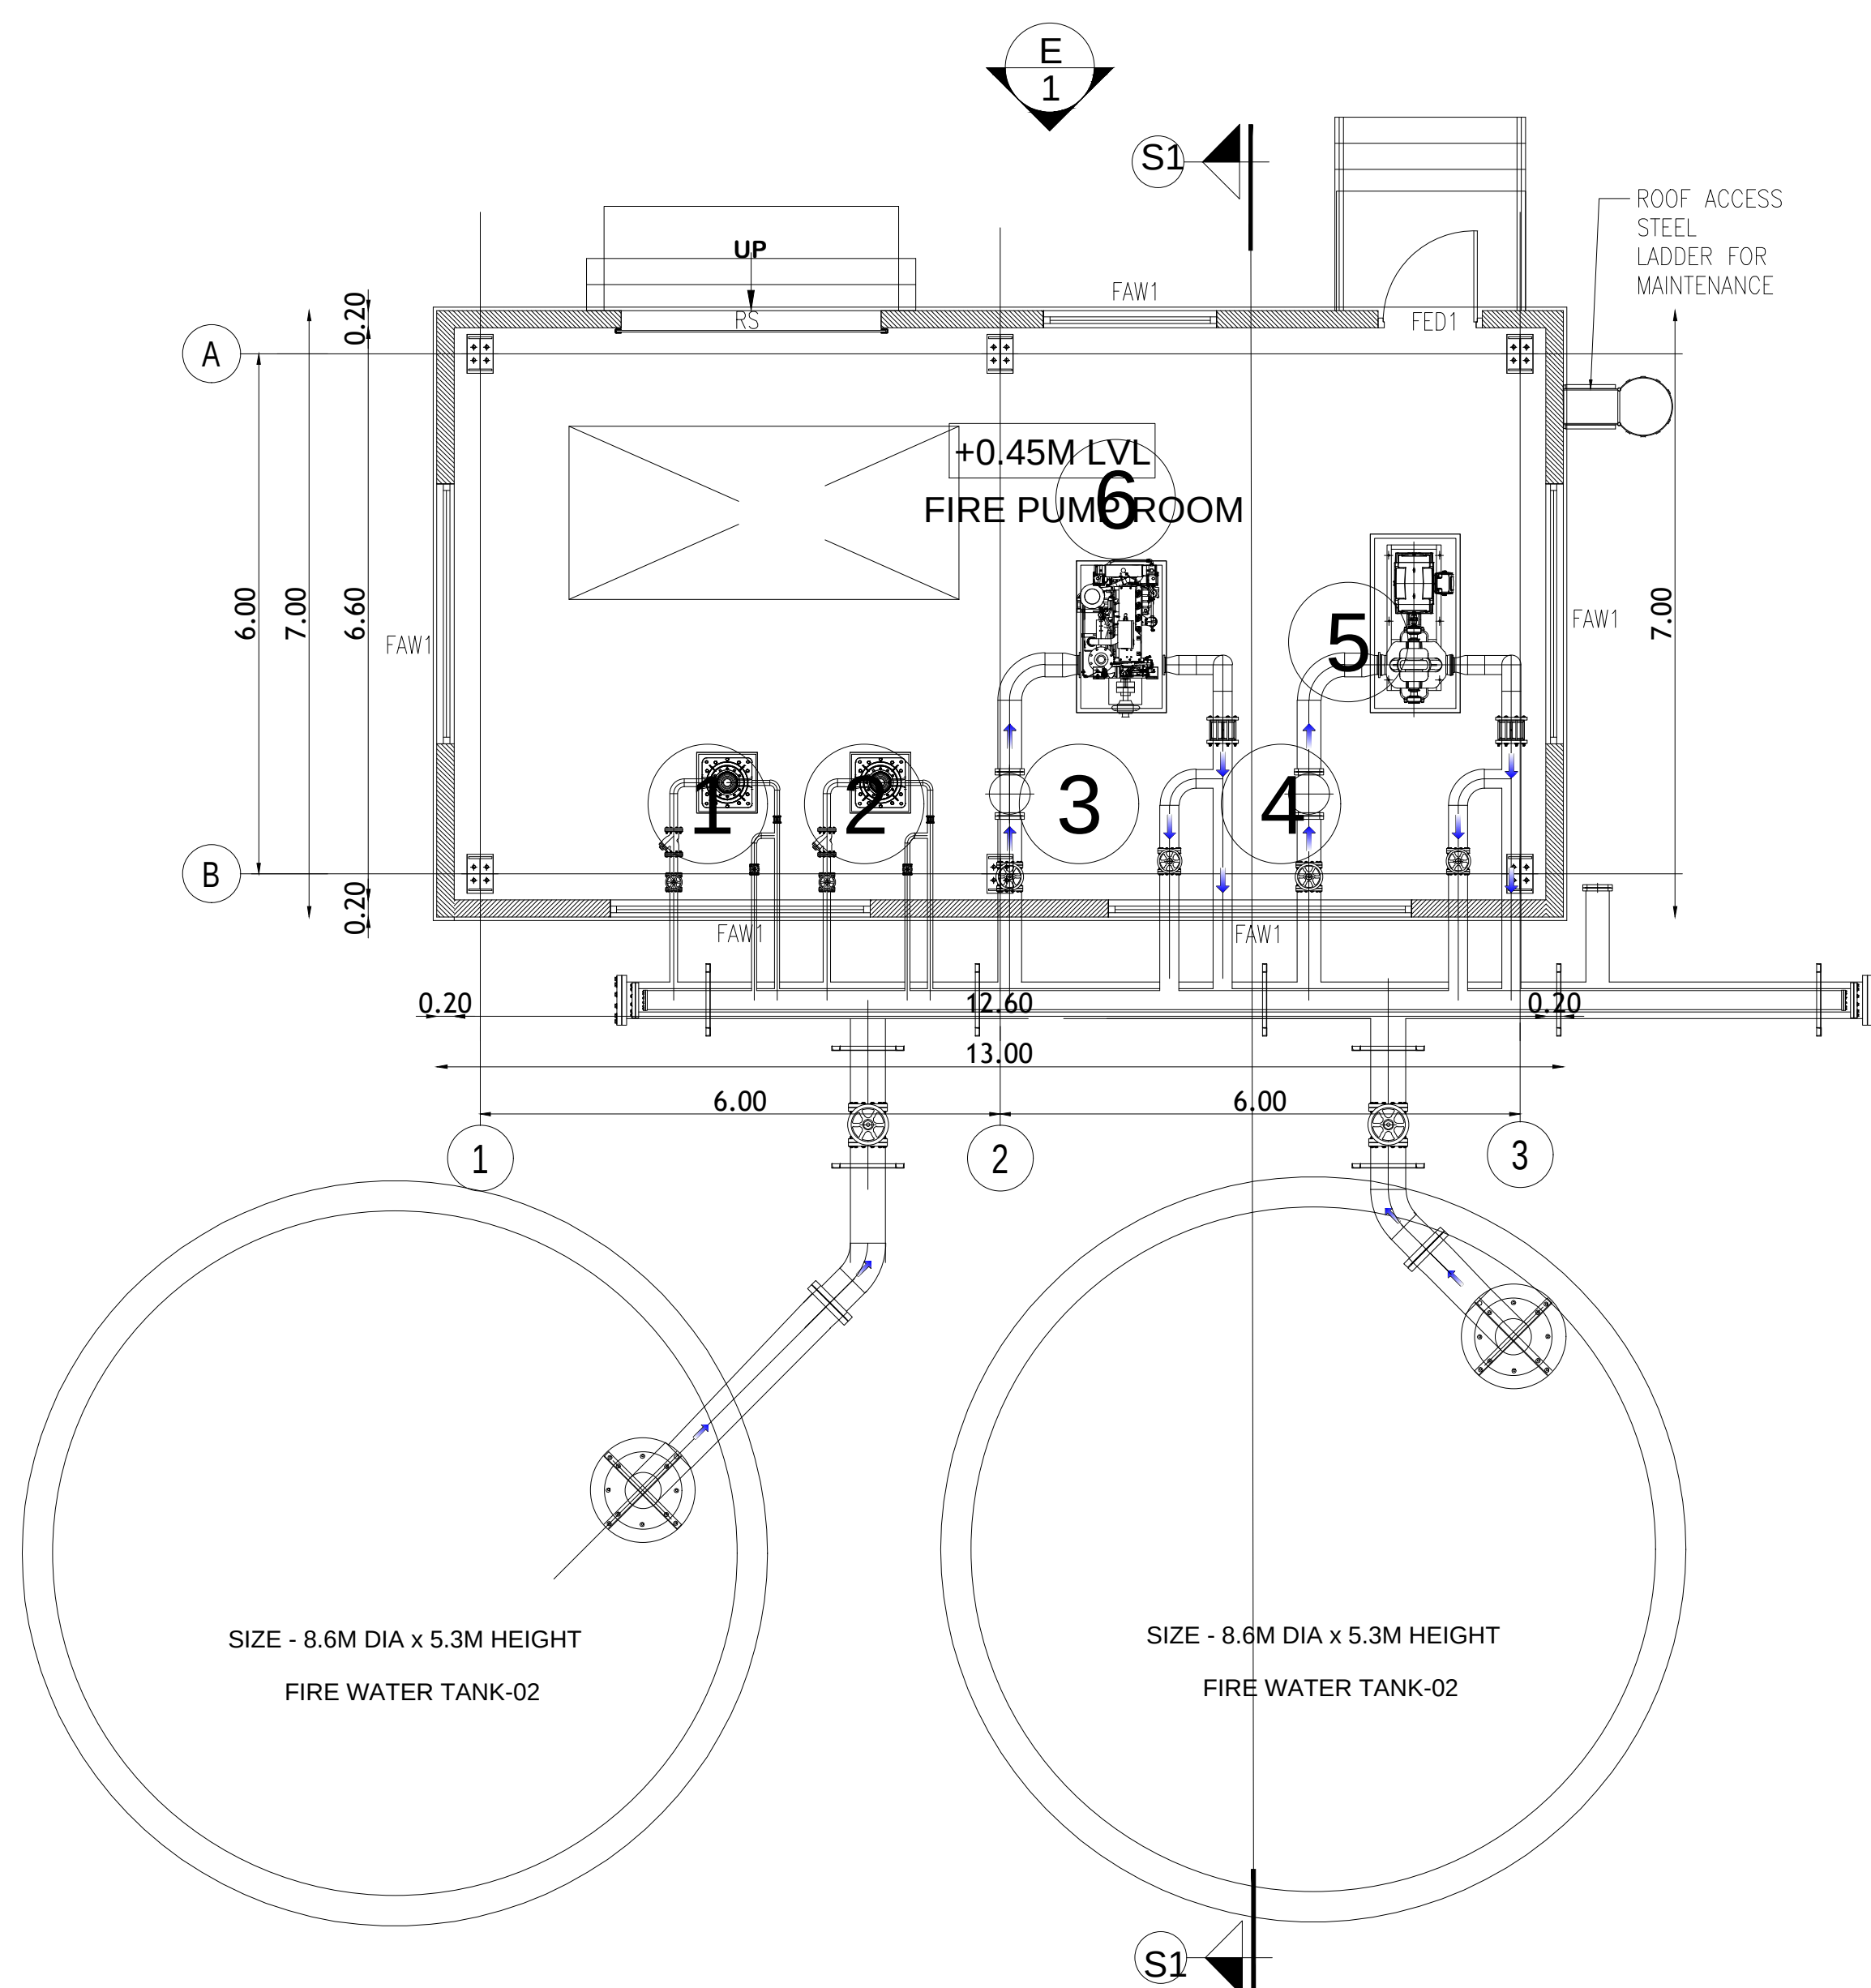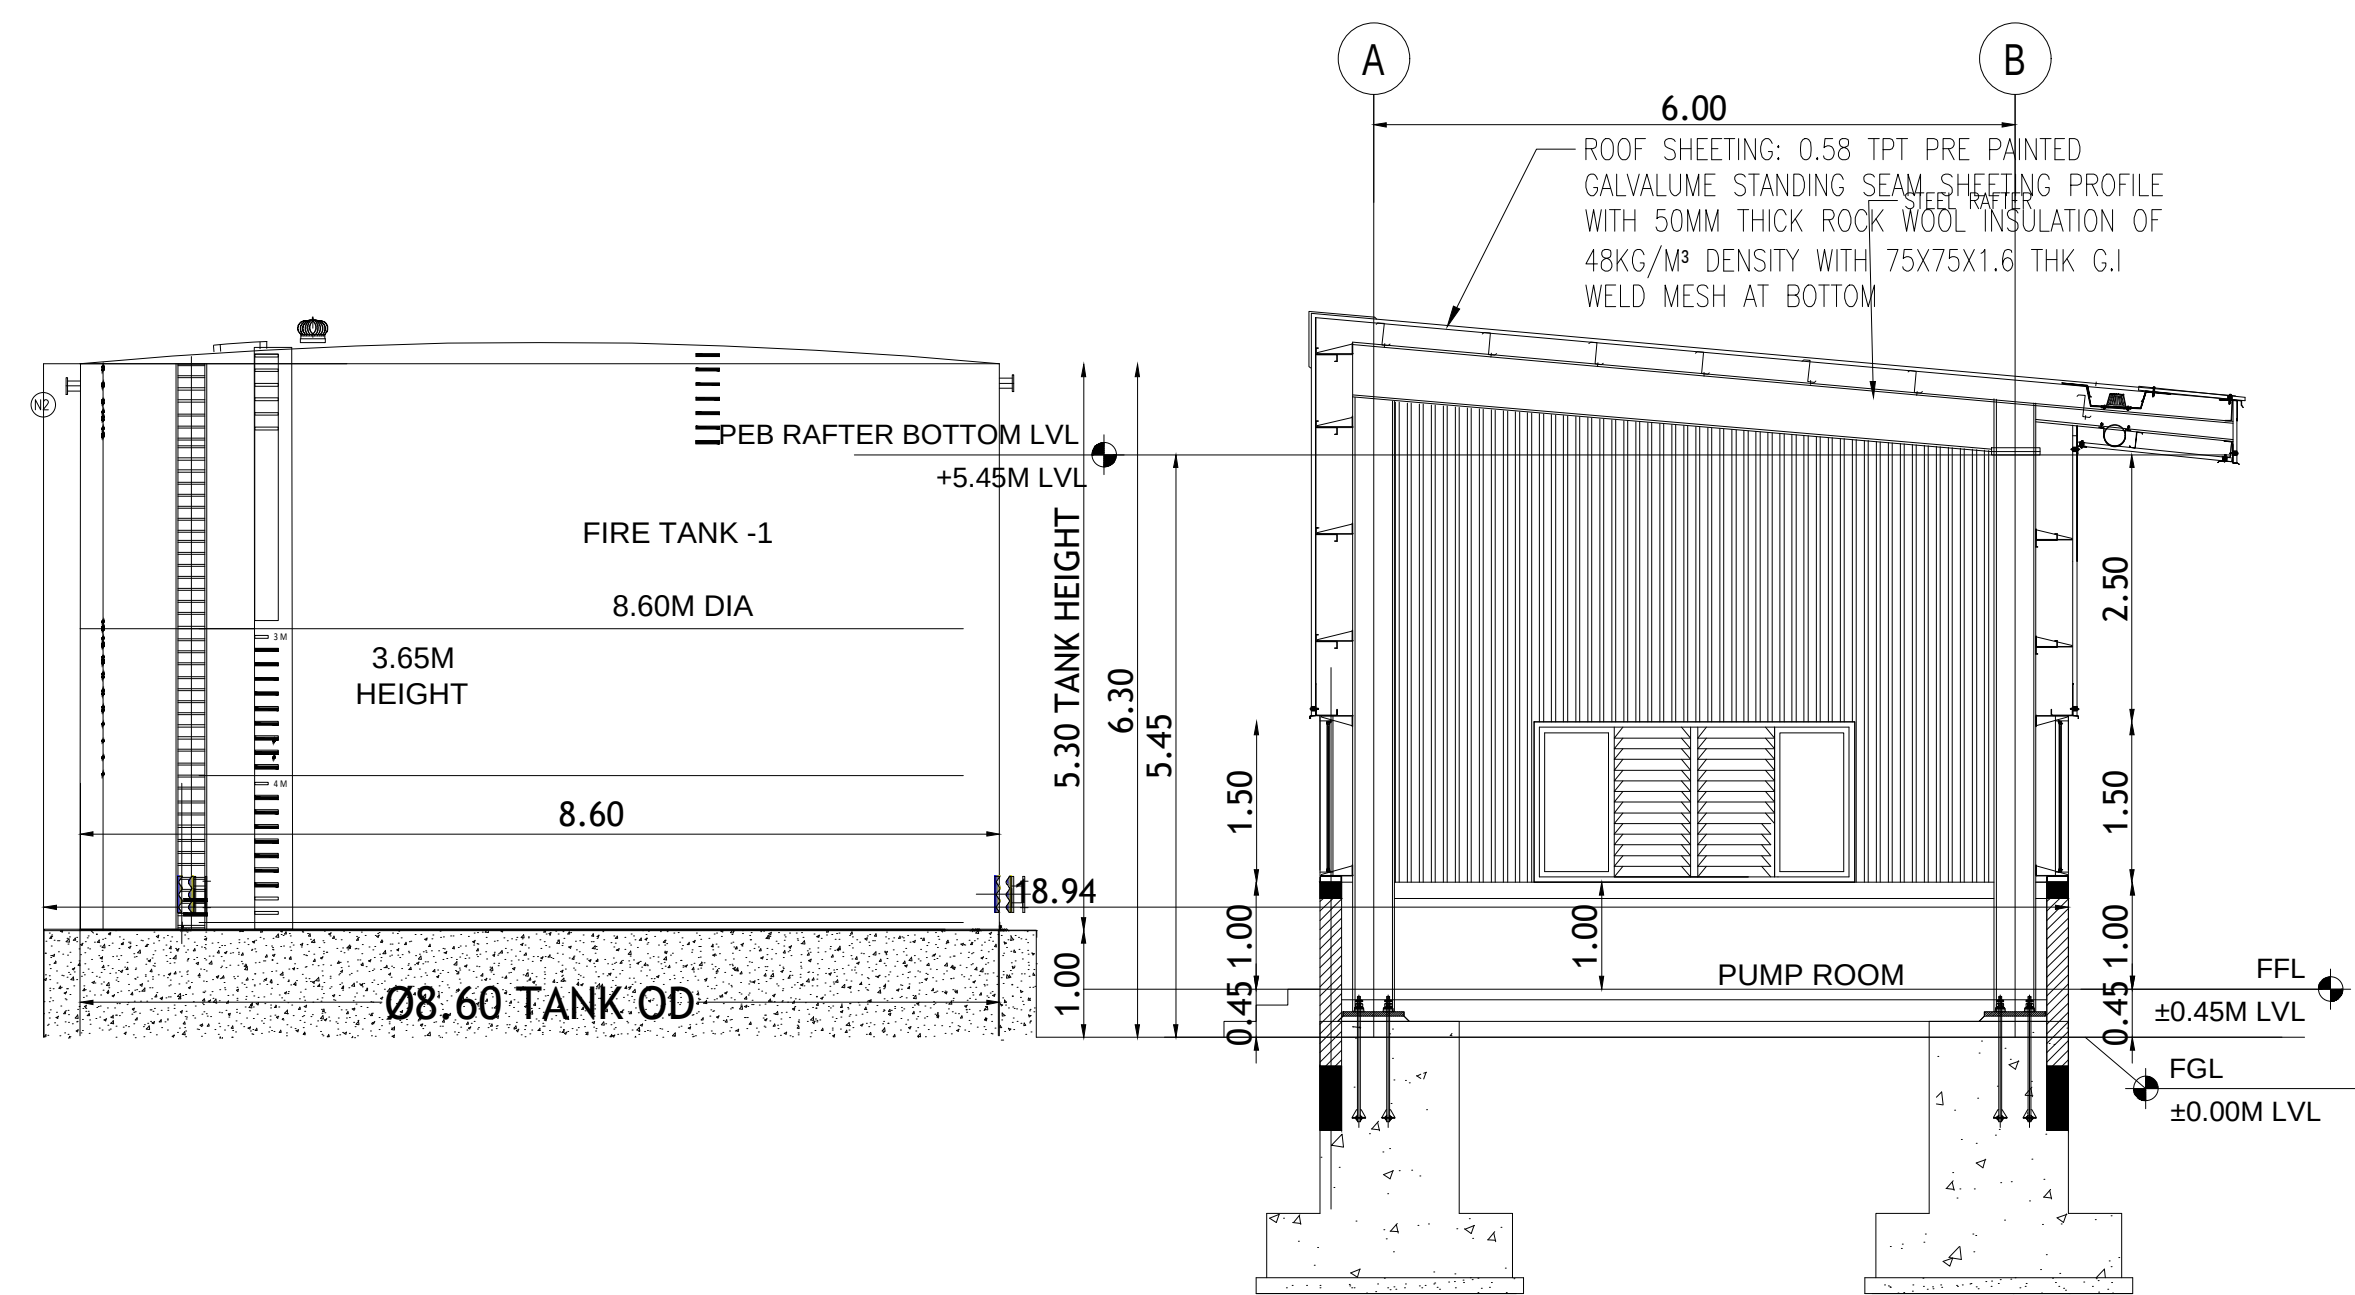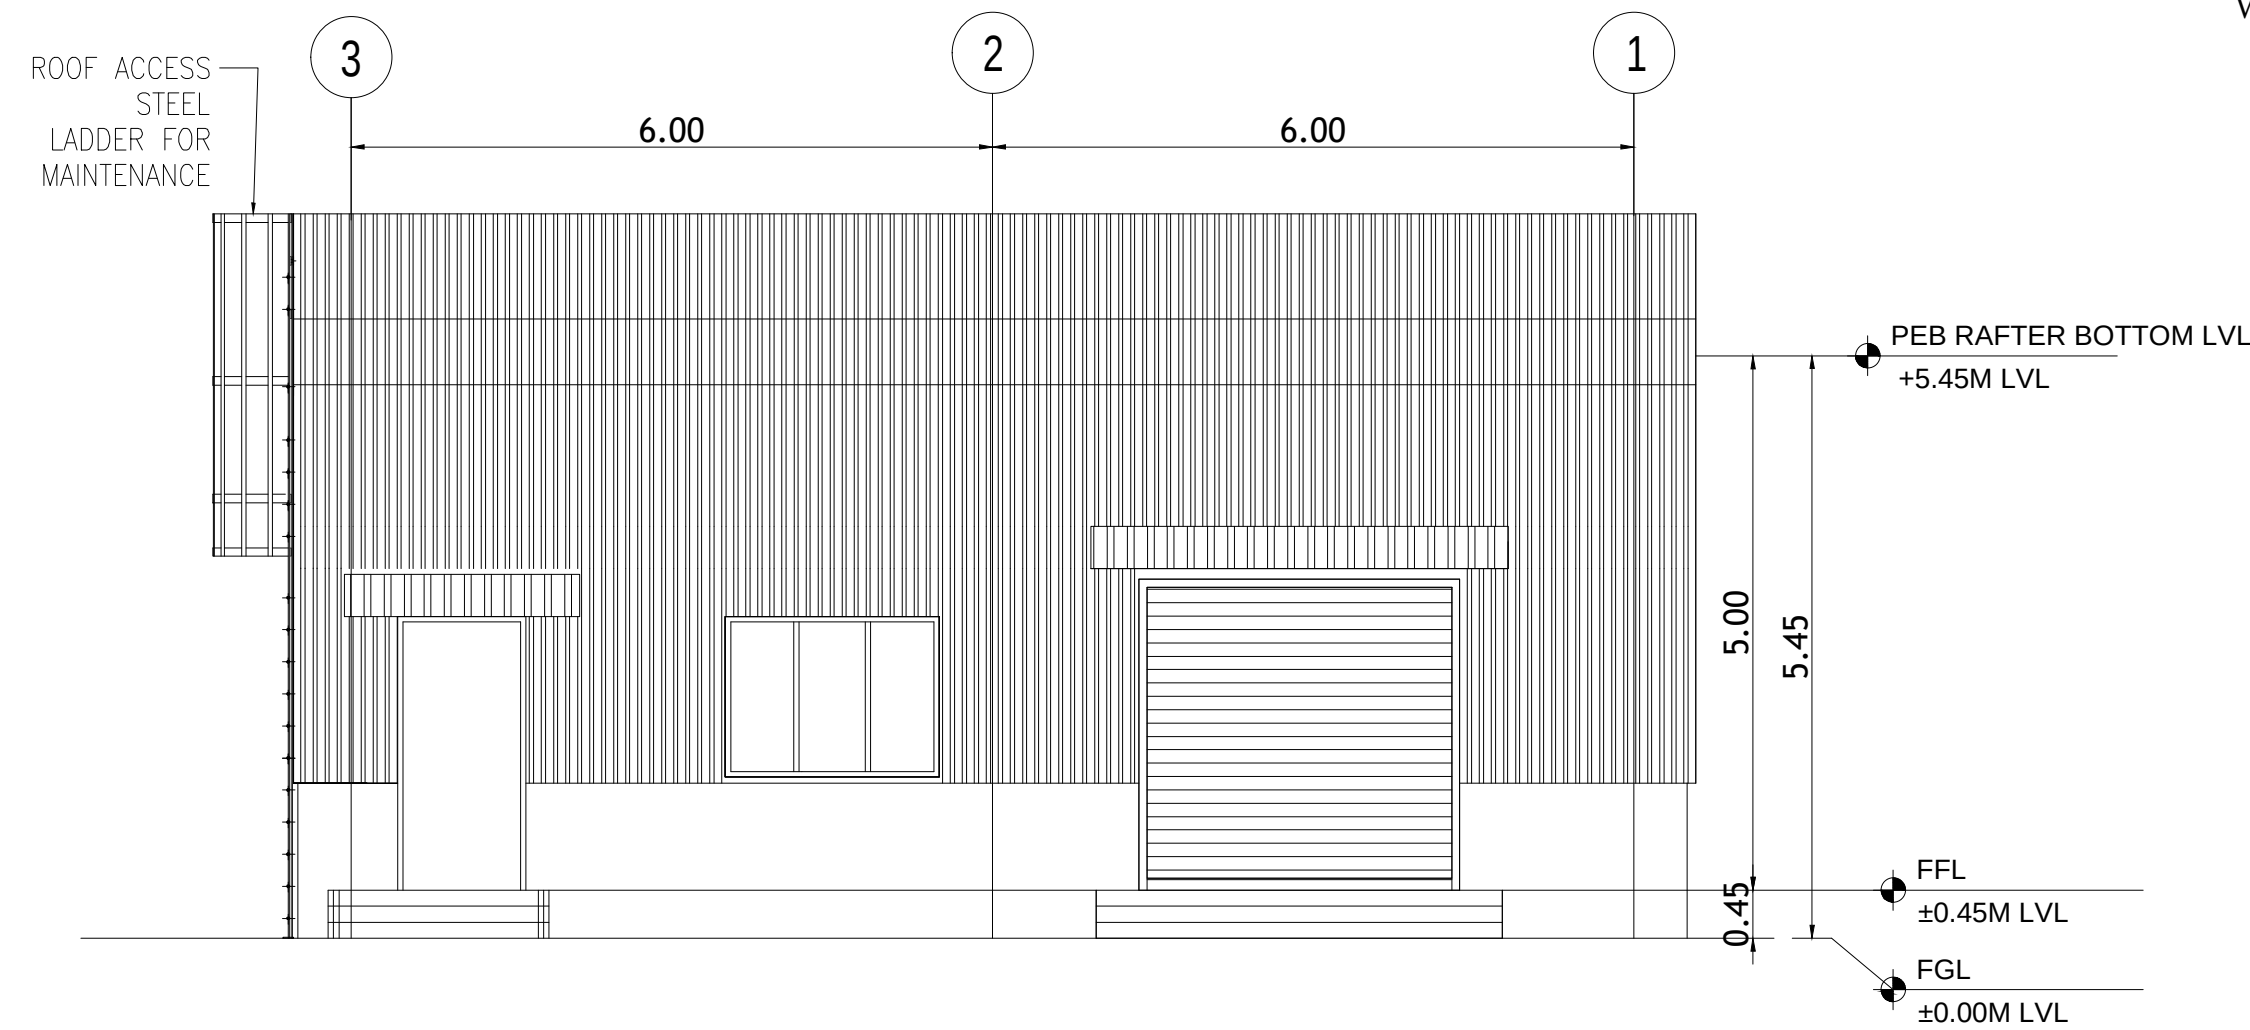

PLAN SHOWING THE PROPOSED
CONSTRUCTION OF INDUSTRIAL BUILDING AT
PLOT NO: A-3/2 , A-4/1C & A -4/1E IN OLD
S.NO:32 / 2(PART) & 33/2A, NEW S.NO:32 / 3, 33 /
3, SIPCOT INDUSTRIAL PARK,
THERVOYKANDIGAI VILLAGE , GUMMIDIPOONDI
TALUK, THIRUVALLUR DISTRICT - 601202.

CLIENT NAME :	M/s.TVS INDEON LIMITED
---------------	------------------------

DRAWING TITLE:
FIRE WATER PUMP ROOM - PLAN, SECTION & ELEVATION.

SCHEDULE OF JOINERIES:-

TYPE	DESCRIPTION	SIZE
RS	ROLLING SHUTTER WITH GRILL	3000 X 4000
FED1	FIRE EMERGENCY DOOR	1200 X 2500
FAW1	WINDOW	3000 X 1500
FAW2	WINDOW	2000 X 1500

PROPOSED AREA DETAILS

<u>S.NO</u>	<u>DESCRIPTION</u>	<u>AREA IN SQ.M</u>
7.	FIRE WATER PUMP ROOM	91.00

NOTE:
Scale : All dimension are in meter
Scale : 1:100

COLOUR INDEX : PROPOSED

HP DETAILS:-

Fire Water Pump Room			
Sr no.	Equipment	Sub-Equipment	Connected (kW)
C	Fire Water Pump House		
1	Fire Water Pump	Electrical Motor driven Main Pump (1W)	150.00
2	Fire Water Pump	Electrical Motor driven Main Pump (1 Future)	150.00
3	Fire Water Pump	Electrical Motor driven Jockey Pump (1W)	7.50
4	Fire Water Pump	Electrical Motor driven Jockey Pump (1S)	7.50
5	Fire Water Pump	Electrical Motor driven Monoblock Pump	18.50
6	Fire Water Pump	Instrumentation panel	33.35
Total			366.85

For TVS INDEON LIMITED
MCSundara
AUTHORISED SIGNATORY

OWNER SIGNATURE


Er. K. MURALI, BE(Civil), M.E(Struct)
 Registered Structural Engineer Grade-III(CE),
 Chengalpattu Reg.No. CGLRGW/SE/Ce-1261/1997
 New No.14, Old No.34, Damodaran Street,
 TNagar, Chennai-17.
 Mobile: 97890 18902, Off: 2434 0048
 Email Id : muralifasi1971@gmail.com


STRUCTURAL ENGINEER SIGNATURE

N.A.RANJAN NAVAMANEE
B.Arch., M.C.A., FIV.
REGISTERED ARCHITECT - APPROVED VALUER
COA No. 13127/90 F23653/14
DTPC CHENGALPATTU REGION REG. No: CGLRGN / RA / G+I / 9 / 64 / 001
12/2, Venkateswara Nagar, 1st Street, Adyar, Chennai - 600 020
Cell: +91 9382164401. Email: Rnarchitect2009@gmail.com

ARCHITECT SIGNATURE



S A Constructions & Consultancy Pvt Ltd
NO:41, Winkley Street, VGN Victoria park,
Ambattur. Chennai-600053
(M)-91 9841613506 - 9382161397

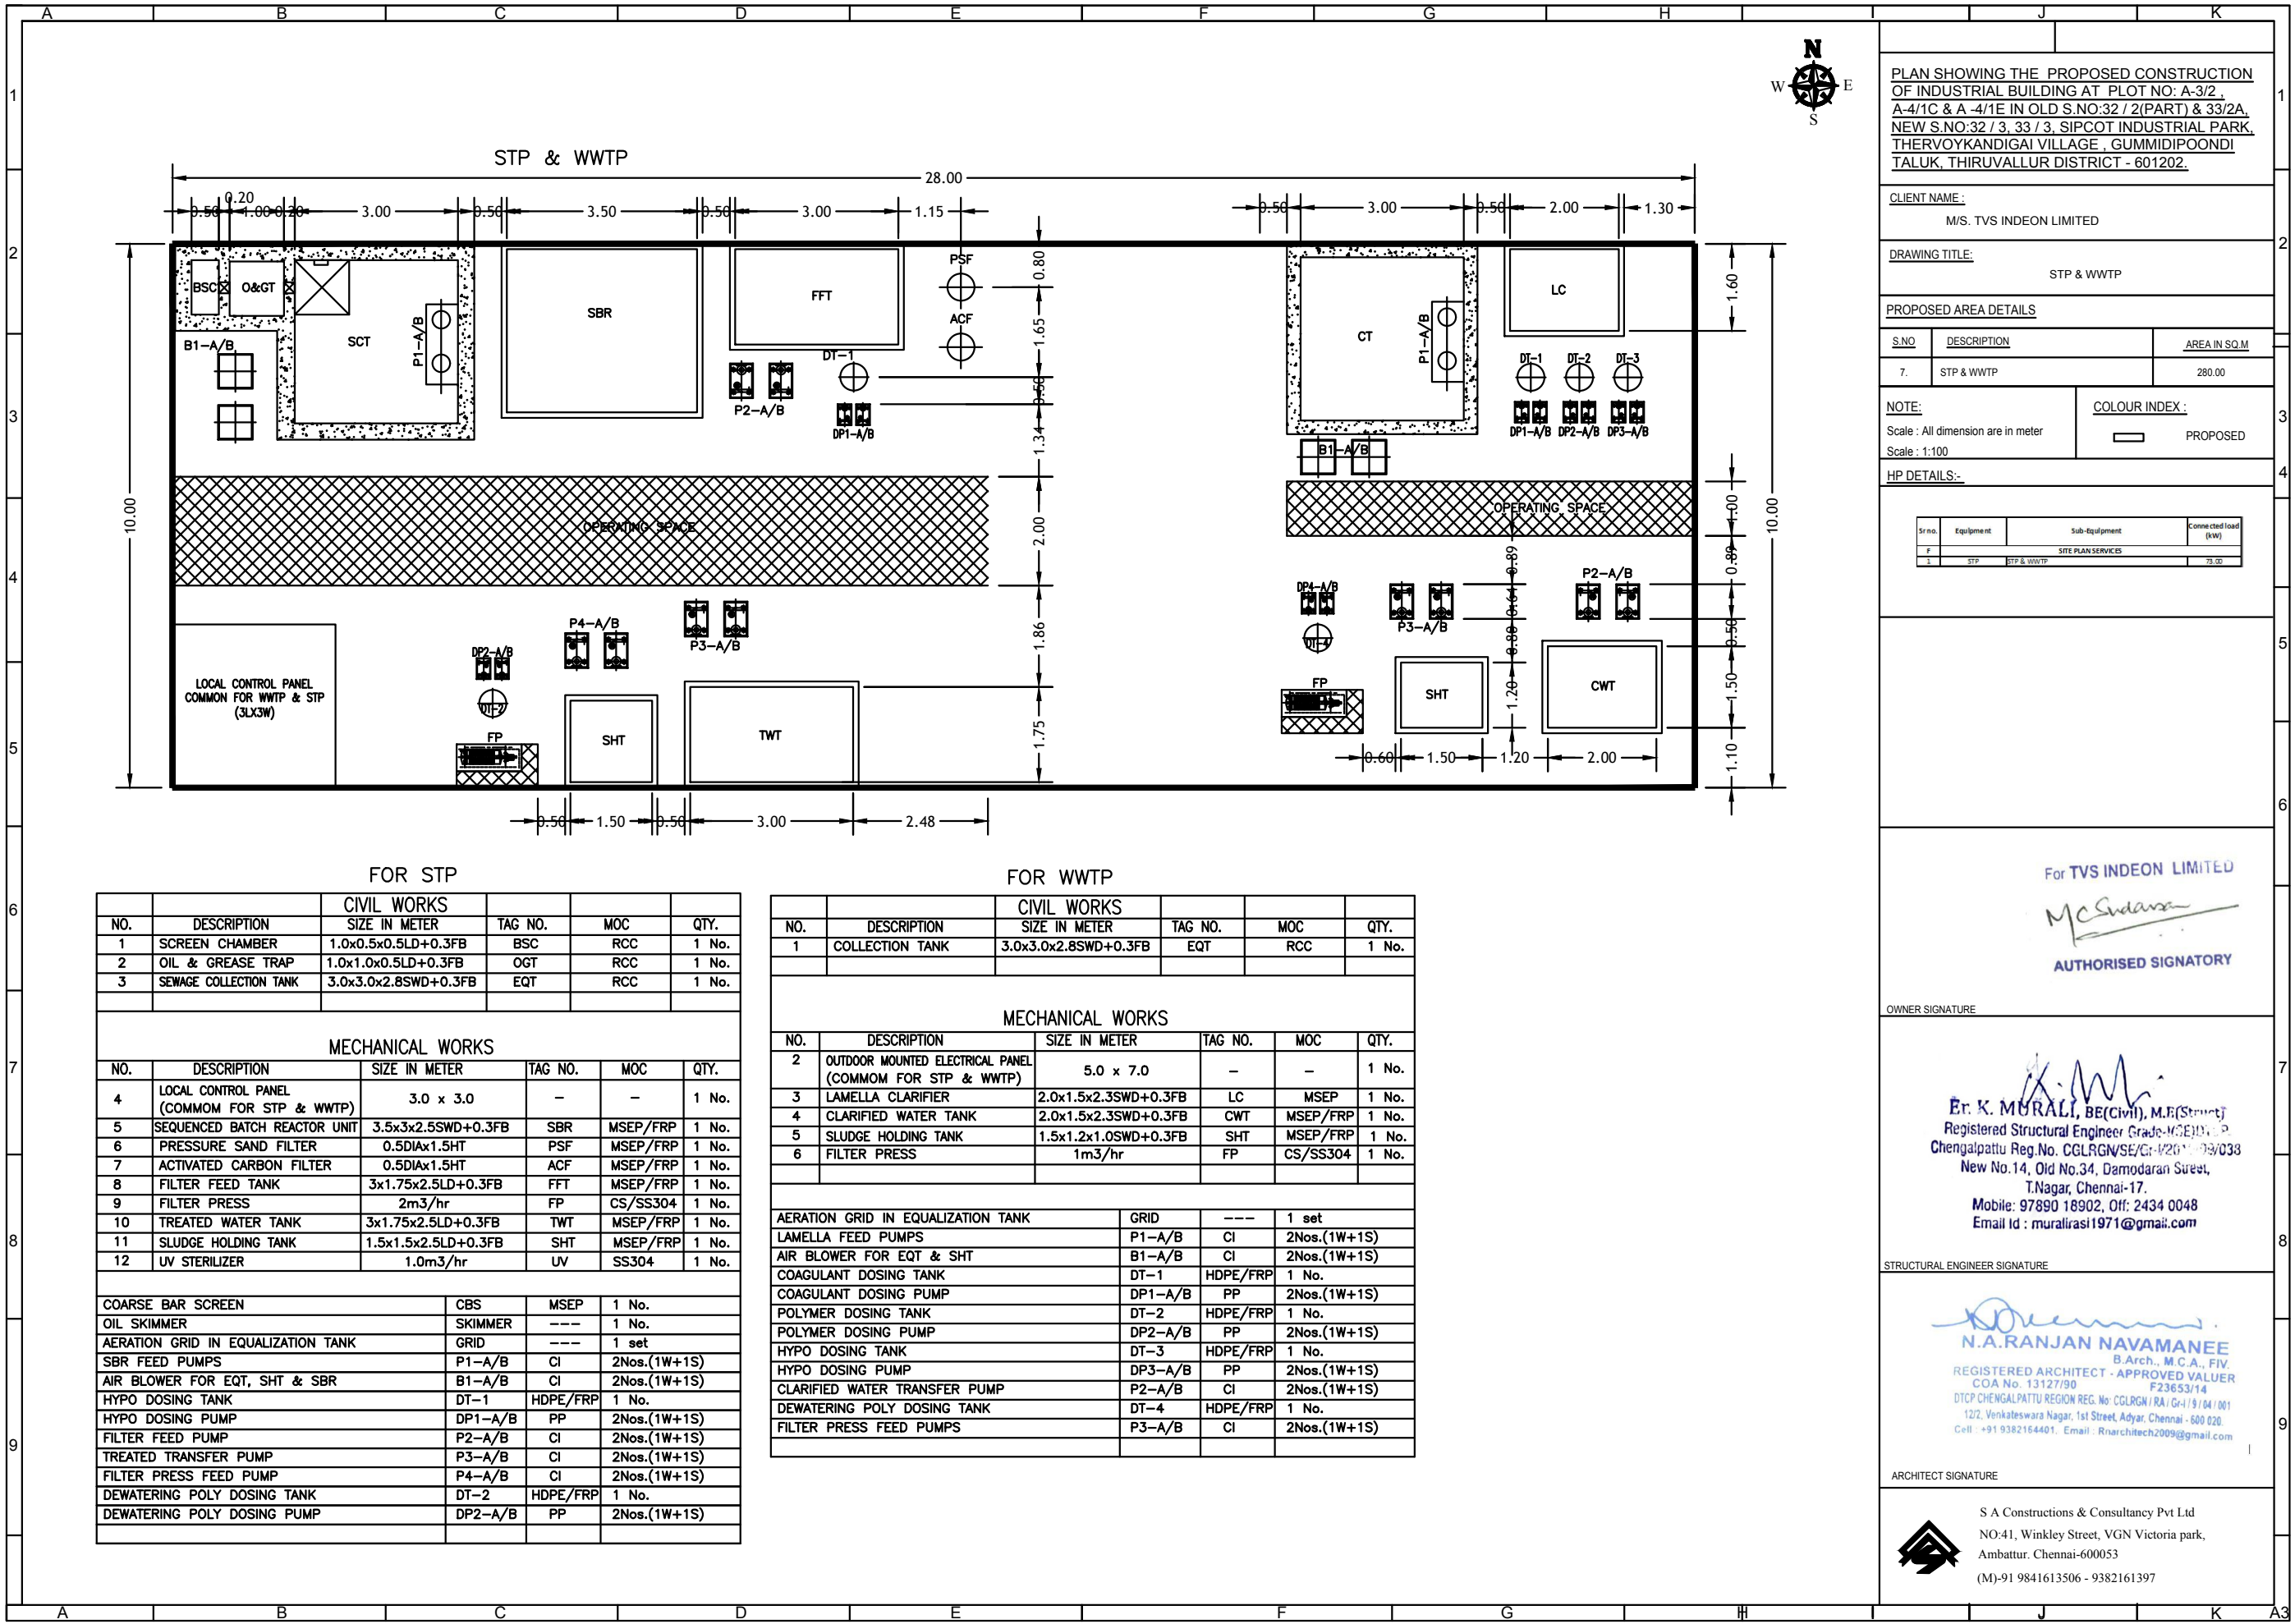

PLAN SHOWING THE PROPOSED CONSTRUCTION OF INDUSTRIAL BUILDING AT PLOT NO: A-3/2, A-4/1C & A-4/1E IN OLD S.NO:32 / 2(PART) & 33/2A, NEW S.NO:32 / 3, 33 / 3, SIPCOT INDUSTRIAL PARK, THERVOYKANDIGAI VILLAGE, GUMMIDIPOONDI TALUK, THIRUVALLUR DISTRICT - 601202.

CLIENT NAME: M/S. TVS INDEON LIMITED

DRAWING TITLE: STP & WWTP

PROPOSED AREA DETAILS

S.NO	DESCRIPTION	AREA IN SQ.M
7.	STP & WWTP	280.00

NOTE: Scale: All dimension are in meter Scale: 1:100

COLOUR INDEX: PROPOSED

HP DETAILS:-

Sr.no	Equipment	Sub-Equipment	Connected load (kW)
F		SITE PLAN SERVICES	
1	STP	STP & WWTP	75.00

For TVS INDEON LIMITED

AUTHORISED SIGNATORY

OWNER SIGNATURE

Er. K. MURALI, BE(Civil), M.E(Struct)
Registered Structural Engineer Grade-MCE/11/P
Chengalpattu Reg.No. CGLRGN/SE/Gr-12011-03/033
New No.14, Old No.34, Damodaran Street,
T.Nagar, Chennai-17.
Mobile: 97890 18902, Of: 2434 0048
Email id : muralirasi1971@gmail.com

STRUCTURAL ENGINEER SIGNATURE

N.A.RANJAN NAVAMANE
B.Arch., M.C.A., FIV.
REGISTERED ARCHITECT - APPROVED VALUER
COA No. 13127/90 F23653/14
DTCP CHENGALPATTU REGION REG. No. CGLRGN/RA/Gr-19/04/001
12/2, Venkateswara Nagar, 1st Street, Adyar, Chennai - 600 020.
Cell : +91 9382154401, Email : Rnarchitech2009@gmail.com

ARCHITECT SIGNATURE

S A Constructions & Consultancy Pvt Ltd
NO:41, Winkley Street, VGN Victoria park,
Ambattur, Chennai-600053
(M)-91 9841613506 - 9382161397

FOR STP

NO.	DESCRIPTION	CIVIL WORKS SIZE IN METER	TAG NO.	MOC	QTY.
1	SCREEN CHAMBER	1.0x0.5x0.5LD+0.3FB	BSC	RCC	1 No.
2	OIL & GREASE TRAP	1.0x1.0x0.5LD+0.3FB	OGT	RCC	1 No.
3	SEWAGE COLLECTION TANK	3.0x3.0x2.8SWD+0.3FB	EQT	RCC	1 No.

MECHANICAL WORKS

NO.	DESCRIPTION	SIZE IN METER	TAG NO.	MOC	QTY.
4	LOCAL CONTROL PANEL (COMMON FOR STP & WWTP)	3.0 x 3.0	-	-	1 No.
5	SEQUENCED BATCH REACTOR UNIT	3.5x3x2.5SWD+0.3FB	SBR	MSEP/FRP	1 No.
6	PRESSURE SAND FILTER	0.5DIAx1.5HT	PSF	MSEP/FRP	1 No.
7	ACTIVATED CARBON FILTER	0.5DIAx1.5HT	ACF	MSEP/FRP	1 No.
8	FILTER FEED TANK	3x1.75x2.5LD+0.3FB	FFT	MSEP/FRP	1 No.
9	FILTER PRESS	2m3/hr	FP	CS/SS304	1 No.
10	TREATED WATER TANK	3x1.75x2.5LD+0.3FB	TWT	MSEP/FRP	1 No.
11	SLUDGE HOLDING TANK	1.5x1.5x2.5LD+0.3FB	SHT	MSEP/FRP	1 No.
12	UV STERILIZER	1.0m3/hr	UV	SS304	1 No.

COARSE BAR SCREEN	CBS	MSEP	1 No.
OIL SKIMMER	SKIMMER	---	1 No.
AERATION GRID IN EQUALIZATION TANK	GRID	---	1 set
SBR FEED PUMPS	P1-A/B	CI	2Nos.(1W+1S)
AIR BLOWER FOR EQT, SHT & SBR	B1-A/B	CI	2Nos.(1W+1S)
HYPO DOSING TANK	DT-1	HDPE/FRP	1 No.
HYPO DOSING PUMP	DP1-A/B	PP	2Nos.(1W+1S)
FILTER FEED PUMP	P2-A/B	CI	2Nos.(1W+1S)
TREATED TRANSFER PUMP	P3-A/B	CI	2Nos.(1W+1S)
FILTER PRESS FEED PUMP	P4-A/B	CI	2Nos.(1W+1S)
DEWATERING POLY DOSING TANK	DT-2	HDPE/FRP	1 No.
DEWATERING POLY DOSING PUMP	DP2-A/B	PP	2Nos.(1W+1S)


FOR WWTP

NO.	DESCRIPTION	CIVIL WORKS SIZE IN METER	TAG NO.	MOC	QTY.
1	COLLECTION TANK	3.0x3.0x2.8SWD+0.3FB	EQT	RCC	1 No.

MECHANICAL WORKS

NO.	DESCRIPTION	SIZE IN METER	TAG NO.	MOC	QTY.
2	OUTDOOR MOUNTED ELECTRICAL PANEL (COMMON FOR STP & WWTP)	5.0 x 7.0	-	-	1 No.
3	LAMELLA CLARIFIER	2.0x1.5x2.3SWD+0.3FB	LC	MSEP	1 No.
4	CLARIFIED WATER TANK	2.0x1.5x2.3SWD+0.3FB	CWT	MSEP/FRP	1 No.
5	SLUDGE HOLDING TANK	1.5x1.2x1.0SWD+0.3FB	SHT	MSEP/FRP	1 No.
6	FILTER PRESS	1m3/hr	FP	CS/SS304	1 No.

AERATION GRID IN EQUALIZATION TANK	GRID	----	1 set
LAMELLA FEED PUMPS	P1-A/B	CI	2Nos.(1W+1S)
AIR BLOWER FOR EQT & SHT	B1-A/B	CI	2Nos.(1W+1S)
COAGULANT DOSING TANK	DT-1	HDPE/FRP	1 No.
COAGULANT DOSING PUMP	DP1-A/B	PP	2Nos.(1W+1S)
POLYMER DOSING TANK	DT-2	HDPE/FRP	1 No.
POLYMER DOSING PUMP	DP2-A/B	PP	2Nos.(1W+1S)
HYPO DOSING TANK	DT-3	HDPE/FRP	1 No.
HYPO DOSING PUMP	DP3-A/B	PP	2Nos.(1W+1S)
CLARIFIED WATER TRANSFER PUMP	P2-A/B	CI	2Nos.(1W+1S)
DEWATERING POLY DOSING TANK	DT-4	HDPE/FRP	1 No.
FILTER PRESS FEED PUMPS	P3-A/B	CI	2Nos.(1W+1S)

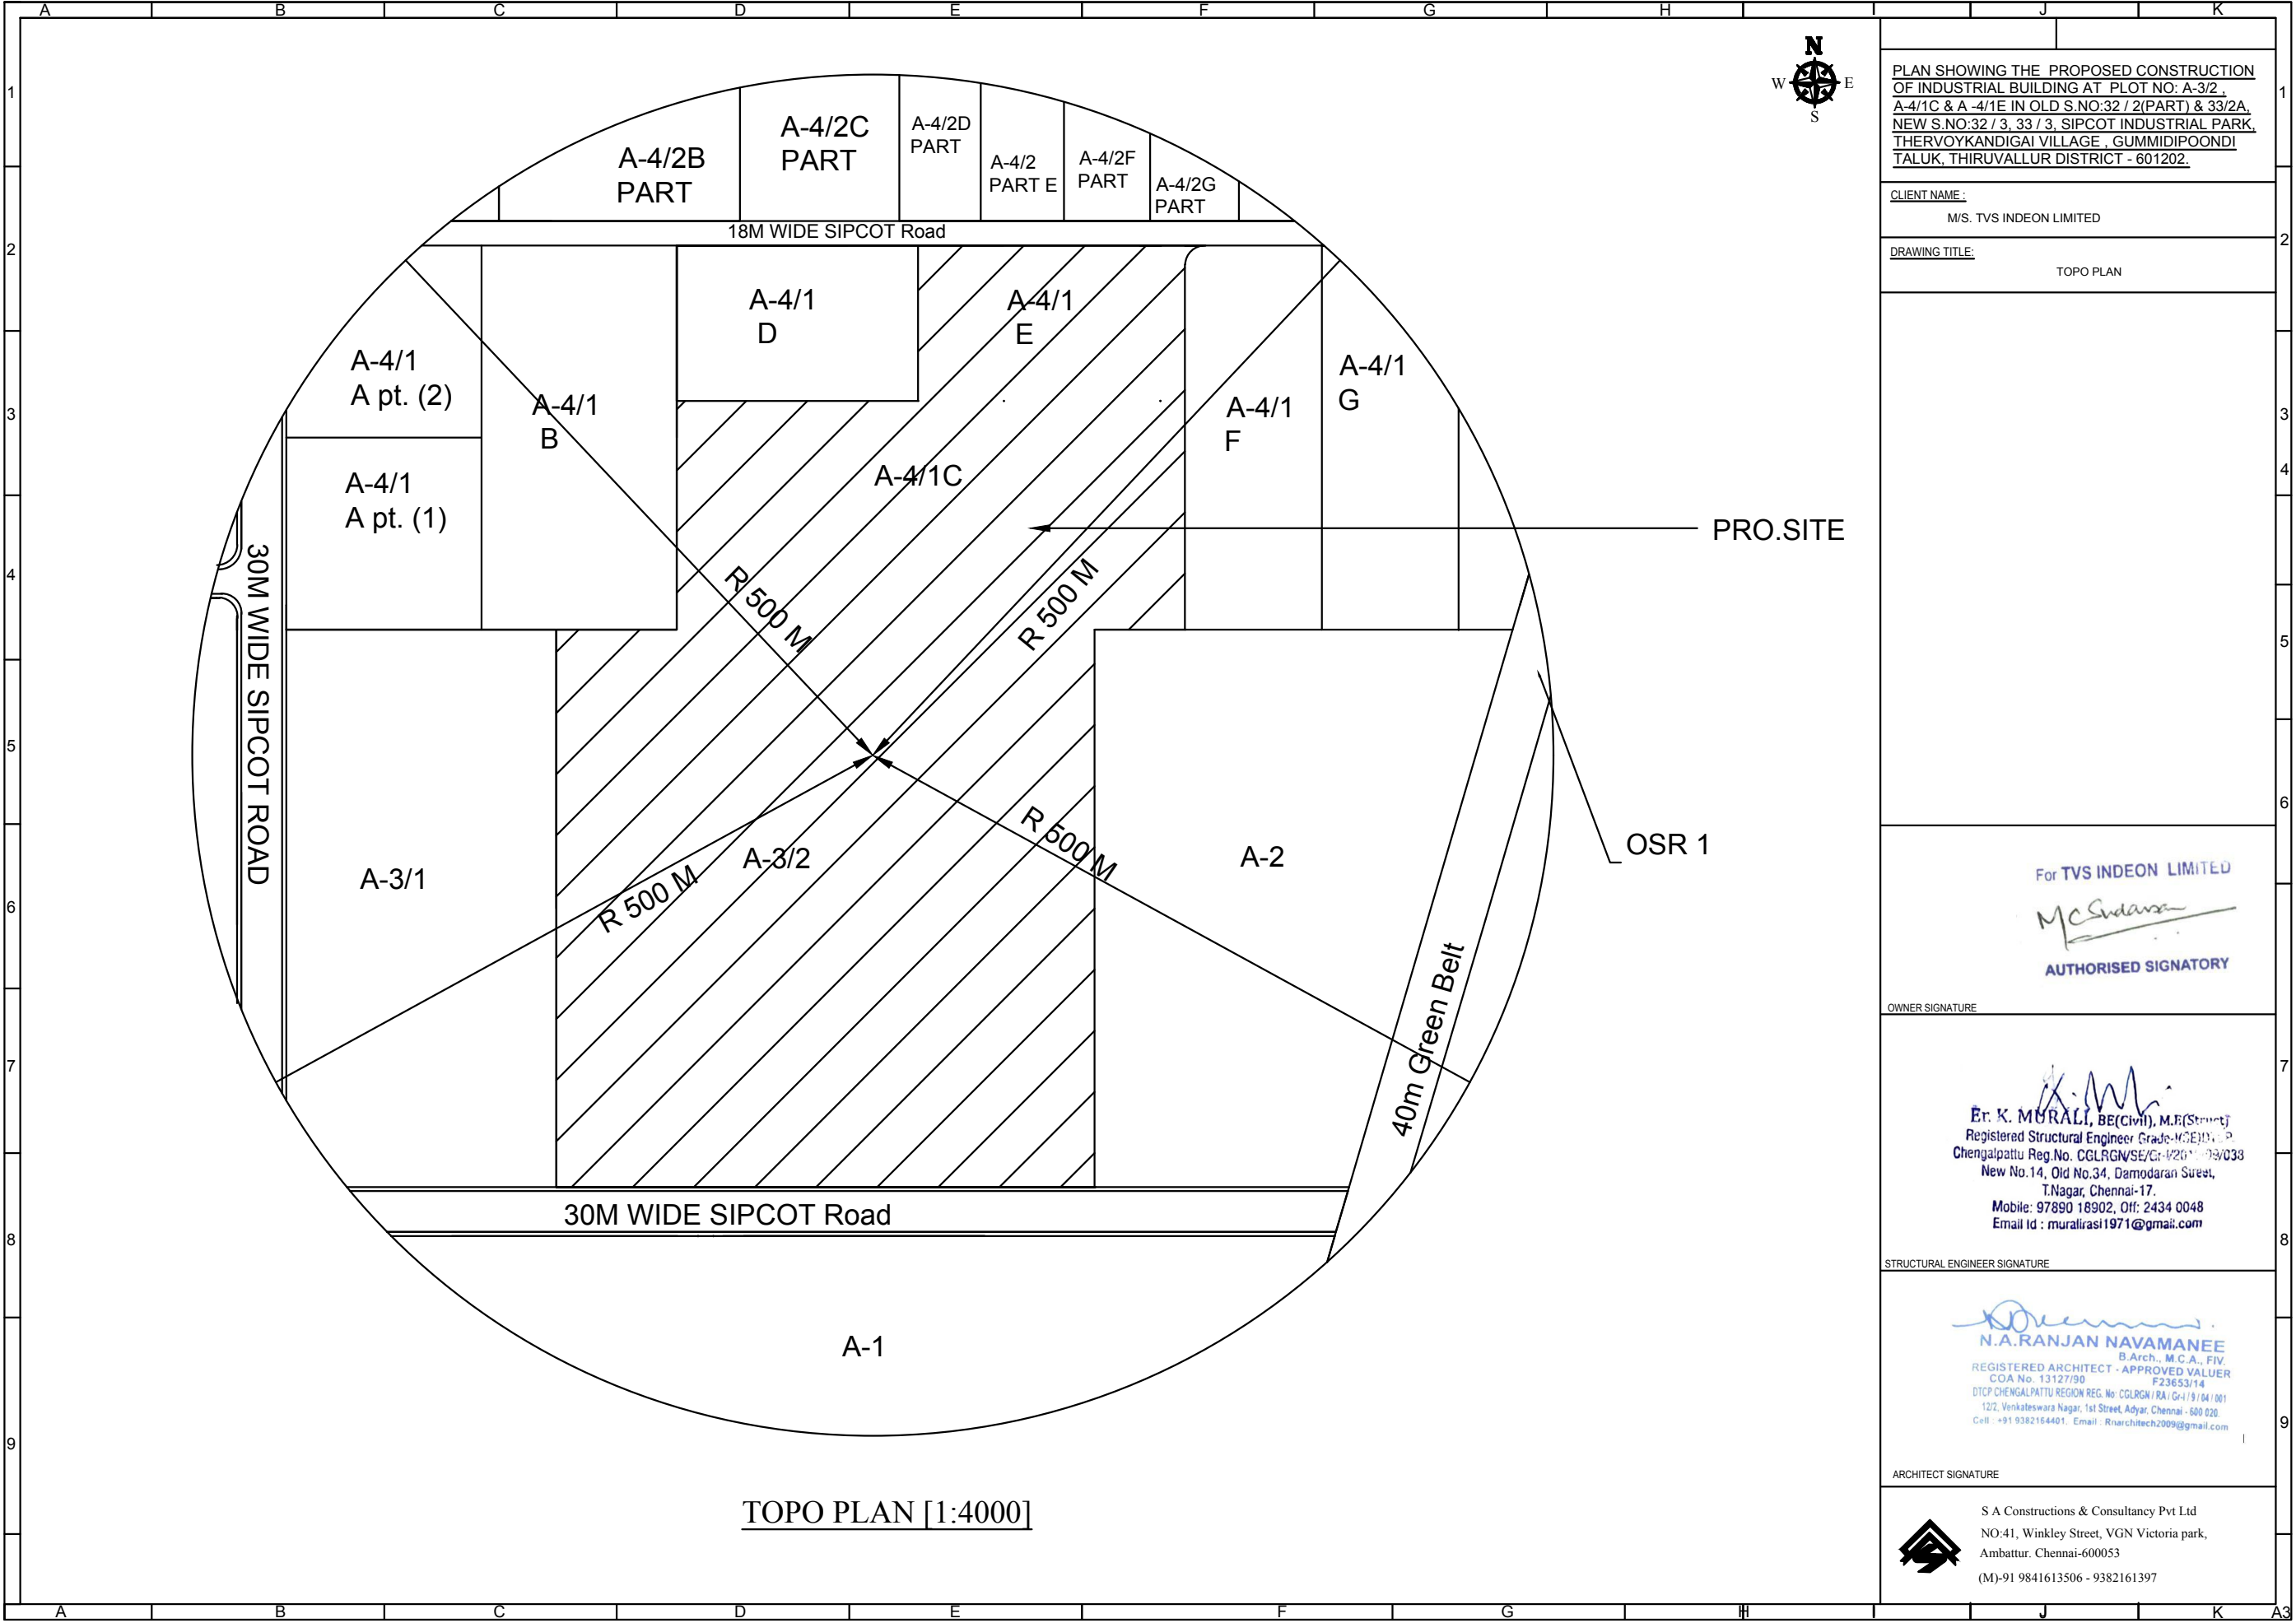

PLAN SHOWING THE PROPOSED CONSTRUCTION OF INDUSTRIAL BUILDING AT PLOT NO: A-3/2, A-4/1C & A-4/1E IN OLD S.NO:32 / 2(PART) & 33/2A, NEW S.NO:32 / 3, 33 / 3, SIPCOT INDUSTRIAL PARK, THERVOYKANDIGAI VILLAGE, GUMMIDIPOONDI TALUK, THIRUVALLUR DISTRICT - 601202.

CLIENT NAME:
M/S. TVS INDEON LIMITED

DRAWING TITLE:
TOPO PLAN

For TVS INDEON LIMITED

McSudama

AUTHORISED SIGNATORY

OWNER SIGNATURE

K. Murali
Er. K. MURALI, BE(Civil), M.E(Struct)
Registered Structural Engineer Grade-MCE/D-1
Chengalpattu Reg.No. CGLRGN/SE/Gr-4/2011-03/038
New No.14, Old No.34, Damodaran Street,
T.Nagar, Chennai-17.
Mobile: 97890 18902, Off: 2434 0048
Email Id : muralirasi1971@gmail.com

STRUCTURAL ENGINEER SIGNATURE

N.A. Ranjan Navamane
N.A.RANJAN NAVAMANE
B.Arch., M.C.A., FIV
REGISTERED ARCHITECT - APPROVED VALUER
COA No. 13127/90 F23653/14
DTCP CHENGALPATTU REGION REG. No. CGLRGN/RA/Gr-1/9/94/001
122, Venkateswara Nagar, 1st Street, Adyar, Chennai - 600 020.
Cell : +91 9382164401, Email : Rnarchitech2009@gmail.com

ARCHITECT SIGNATURE



S A Constructions & Consultancy Pvt Ltd
NO:41, Winkley Street, VGN Victoria park,
Ambattur, Chennai-600053
(M)-91 9841613506 - 9382161397

