

PLAN SHOWING THE PROPOSED CONSTRUCTION OF
HOSPITAL BUILDING IN SURVEY NO: 849/ 3A, IN
PUDHUPALAYAM VILLAGE / PANCHAYAT,
RAJAPALAYAM TALUK, VIRUDHUNAGAR DISTRICT.
(SCALE 1:100)

JOINERY DETAILS:

MD	MAIN DOOR	1.83 x 2.10
MD1	MAIN DOOR	1.63 x 2.10
MD2	MAIN DOOR	1.47 x 2.10
D	DOOR	1.37 x 2.10
D1	DOOR	1.07 x 2.10
D2	DOOR	1.22 x 2.10
D3	DOOR	0.76 x 2.10
D4	DOOR	1.63 x 2.10
D5	DOOR	0.76 x 2.10
D6	DOOR	0.91 x 2.10
LD	LIFT DOOR	1.20 x 2.00
W	WINDOW	1.22 x 1.52
W1	WINDOW	2.44 x 1.52
W2	WINDOW	1.83 x 1.52
W3	WINDOW	2.00 x 1.52
W4	WINDOW	0.91 x 1.52
W5	WINDOW	3.05 x 1.52
W6	WINDOW	4.27 x 1.52
W7	WINDOW	1.63 x 1.52
W8	WINDOW	1.35 x 1.52
W9	WINDOW	1.35 x 1.52
W10	WINDOW	4.88 x 1.52
V	VENTILATOR	0.91 x 0.76
V1	VENTILATOR	0.61 x 0.76
J	JOLLI	4.27 x 1.35
LW	Lower Window	2.44 x 1.52
LW1	Lower Window	2.13 x 1.52


AREA DETAILS

Descriptions	Non FSI	FSI	Total Area
Area of the Ground Floor		1731.80	1731.80
Area of the First Floor		1590.66	1590.66
Area of the Second Floor		1673.77	1673.77
Area of the Third Floor		1597.34	1597.34
Area of the Terrace Floor	284.75		284.75
Total Area	284.75	6593.57	6878.32

NOTE:

FE - FIRE EXTINGUISHER
FA - FIRE ALARM

CONSTRUCTION ENGINEER	 S. VIJAYAN, M.E. STRUCTURAL CONSULTANT CMDA: SE / GR 1 / 2022 / 11 / 1346 No. 58, Second Floor, M.R. High Road, Moolakadai, Chennai - 600 090. Ph: 044-48067852, 6841363910 Email: gransmithprivateindia@gmail.com	 E. K. SHANKAR NARAYANAN, B.E. M.Tech. Registered Geotech Engineer REGTE 001 / 2022 VARAHA GEOTECHNICAL WORKS RAJAPALAYAM - 626 117.
	 M. MURALI, M.Arch. (MC Gill-Canada) Registered Architect CA No: CA-65/9551 142, Second Street, Kamaraj Avenue, Adyar, Chennai - 600 020 Phone: 044 - 24914226, 24413230	 E. T. BABU, B.E. PLAN CENTER Registration No: PE-016/2019 (Grade-I) No.25, South Street, Near Amma Mess Tallakulam, Madurai - 2, Ph: 8220044943, 9786948414
STRUCTURAL ENGINEER	ARCHITECT	
APPLICANT	ENGINEER	

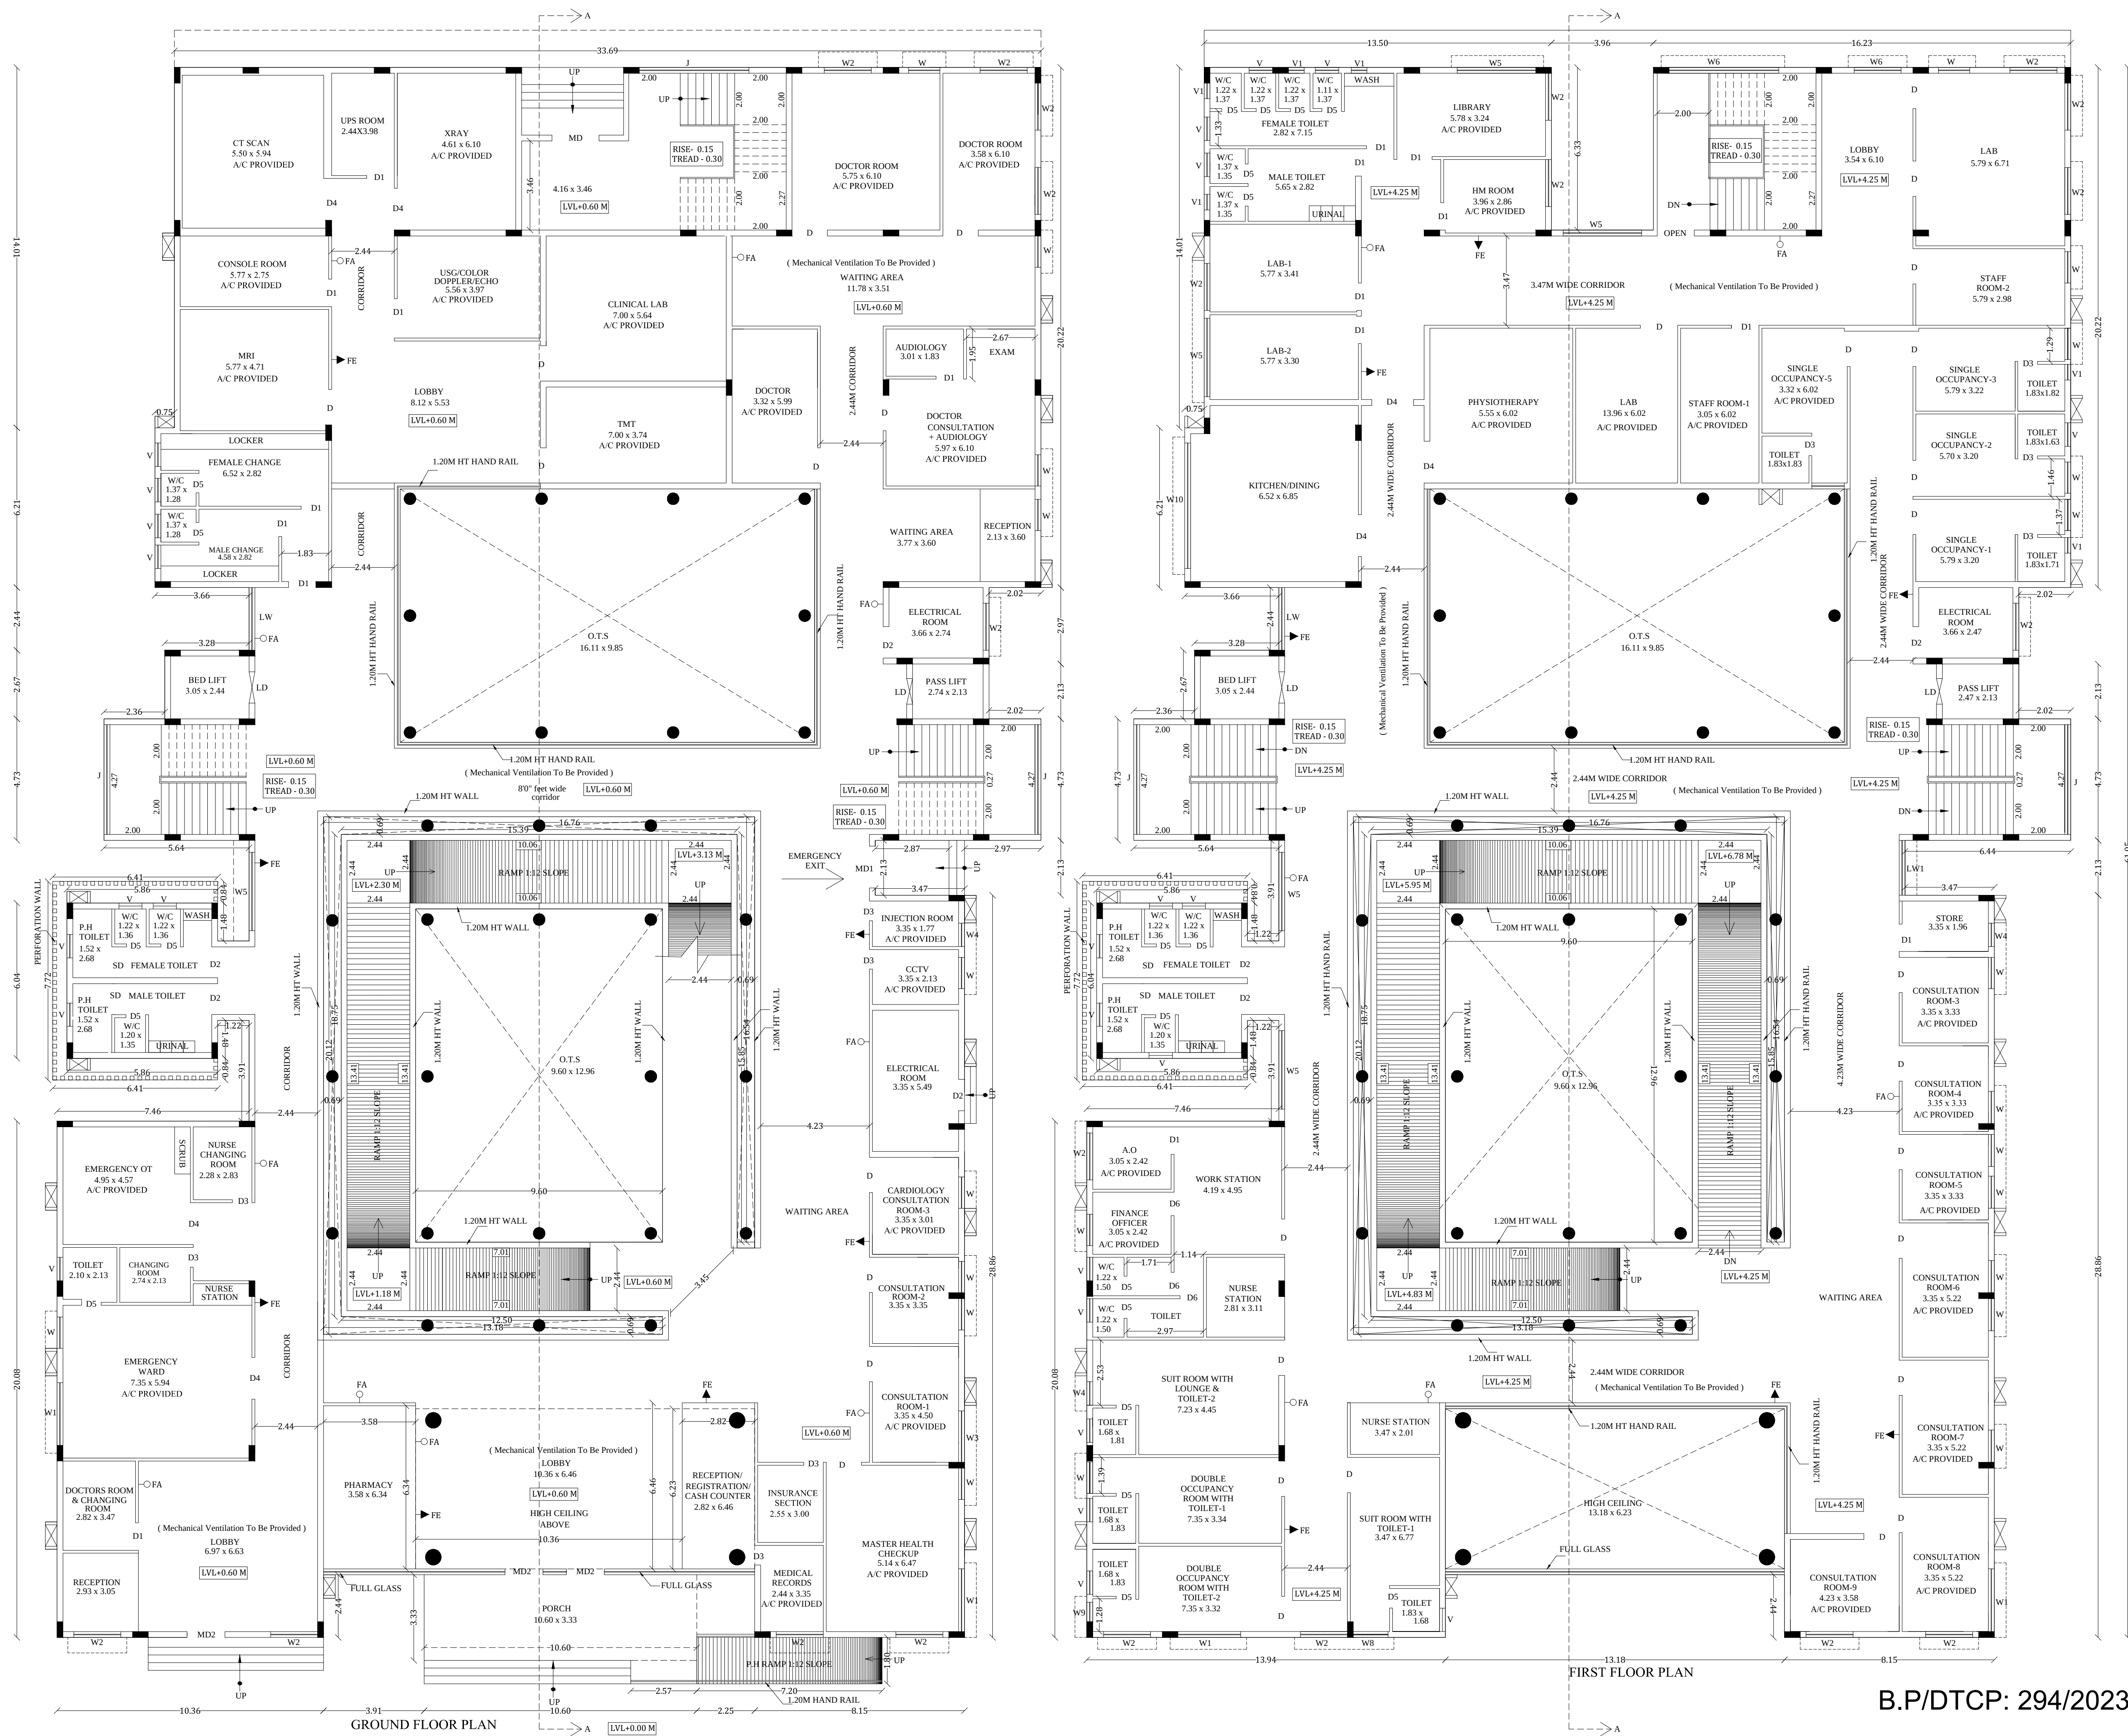

B.P/DTCP: 294/2023

PLAN SHOWING THE PROPOSED CONSTRUCTION OF
HOSPITAL BUILDING IN SURVEY NO: 849/ 3A, IN
PUDHUPALAYAM VILLAGE / PANCHAYAT,
RAJAPALAYAM TALUK, VIRUDHUNAGAR DISTRICT.
(SCALE 1:100)

JOINERY DETAILS:

MD	MAIN DOOR	1.83 x 2.10
MD1	MAIN DOOR	1.63 x 2.10
MD2	MAIN DOOR	1.47 x 2.10
D	DOOR	1.37 x 2.10
D1	DOOR	1.07 x 2.10
D2	DOOR	1.22 x 2.10
D3	DOOR	0.76 x 2.10
D4	DOOR	1.63 x 2.10
D5	DOOR	0.76 x 2.10
D6	DOOR	0.91 x 2.10
LD	LIFT DOOR	1.20 x 2.00
W	WINDOW	1.22 x 1.52
W1	WINDOW	2.44 x 1.52
W2	WINDOW	1.83 x 1.52
W3	WINDOW	2.00 x 1.52
W4	WINDOW	0.91 x 1.52
W5	WINDOW	3.05 x 1.52
W6	WINDOW	4.27 x 1.52
W7	WINDOW	1.63 x 1.52
W8	WINDOW	1.35 x 1.52
W9	WINDOW	1.35 x 1.52
W10	WINDOW	4.88 x 1.52
V	VENTILATOR	0.91 x 0.76
V1	VENTILATOR	0.61 x 0.76
J	JOLLI	4.27 x 1.35
LW	Lower Window	2.44 x 1.52
LW1	Lower Window	2.13 x 1.52

AREA DETAILS

Descriptions	Non FSI	FSI	Total Area
Area of the Ground Floor		1731.80	1731.80
Area of the First Floor		1590.66	1590.66
Area of the Second Floor		1673.77	1673.77
Area of the Third Floor		1597.34	1597.34
Area of the Terrace Floor	284.75		284.75
Total Area	284.75	6593.57	6878.32

NOTE:

FE - FIRE EXTINGUISHER
FA - FIRE ALARM

CONSTRUCTION
ENGINEER

S. VIJAYAN, M.E.
STRUCTURAL CONSULTANT
CMAA: SE / GR 1 / 2022 / 1 / 1346
No. 55, Second Floor M.R. High Road,
Moolakadai, Chennai - 600 050.
Ph: 044-48067852, 9841363910
Email: gramesmithprivatelimited@gmail.com

STRUCTURAL ENGINEER

Dr. K. THANGAMANI, M.B.B.S., D.L.O.,
Reg. No. 36441
HARVEY CLINIC
KAMARAJ NAGAR,
RAJAPALAYAM 626 117.

APPLICANT


GEO-TECH ENGINEER

M. MURALI, M.Arch. (MCI GC-Canada)
Registered Architect CA No: CA-85/9551
142, Second Street, Kamaraj Avenue,
Adyar, Chennai - 600 020
Phone: 044 - 24914226, 24413230


ARCHITECT

Er. T. BABU, B.E.,
PLAN CENTER
Registration No: RE-0162019 (Grade-I)
No.25, South Street, Near Amma Mess
Tallakulam, Madurai - 2,
Ph: 8220044943, 9786948414

ENGINEER

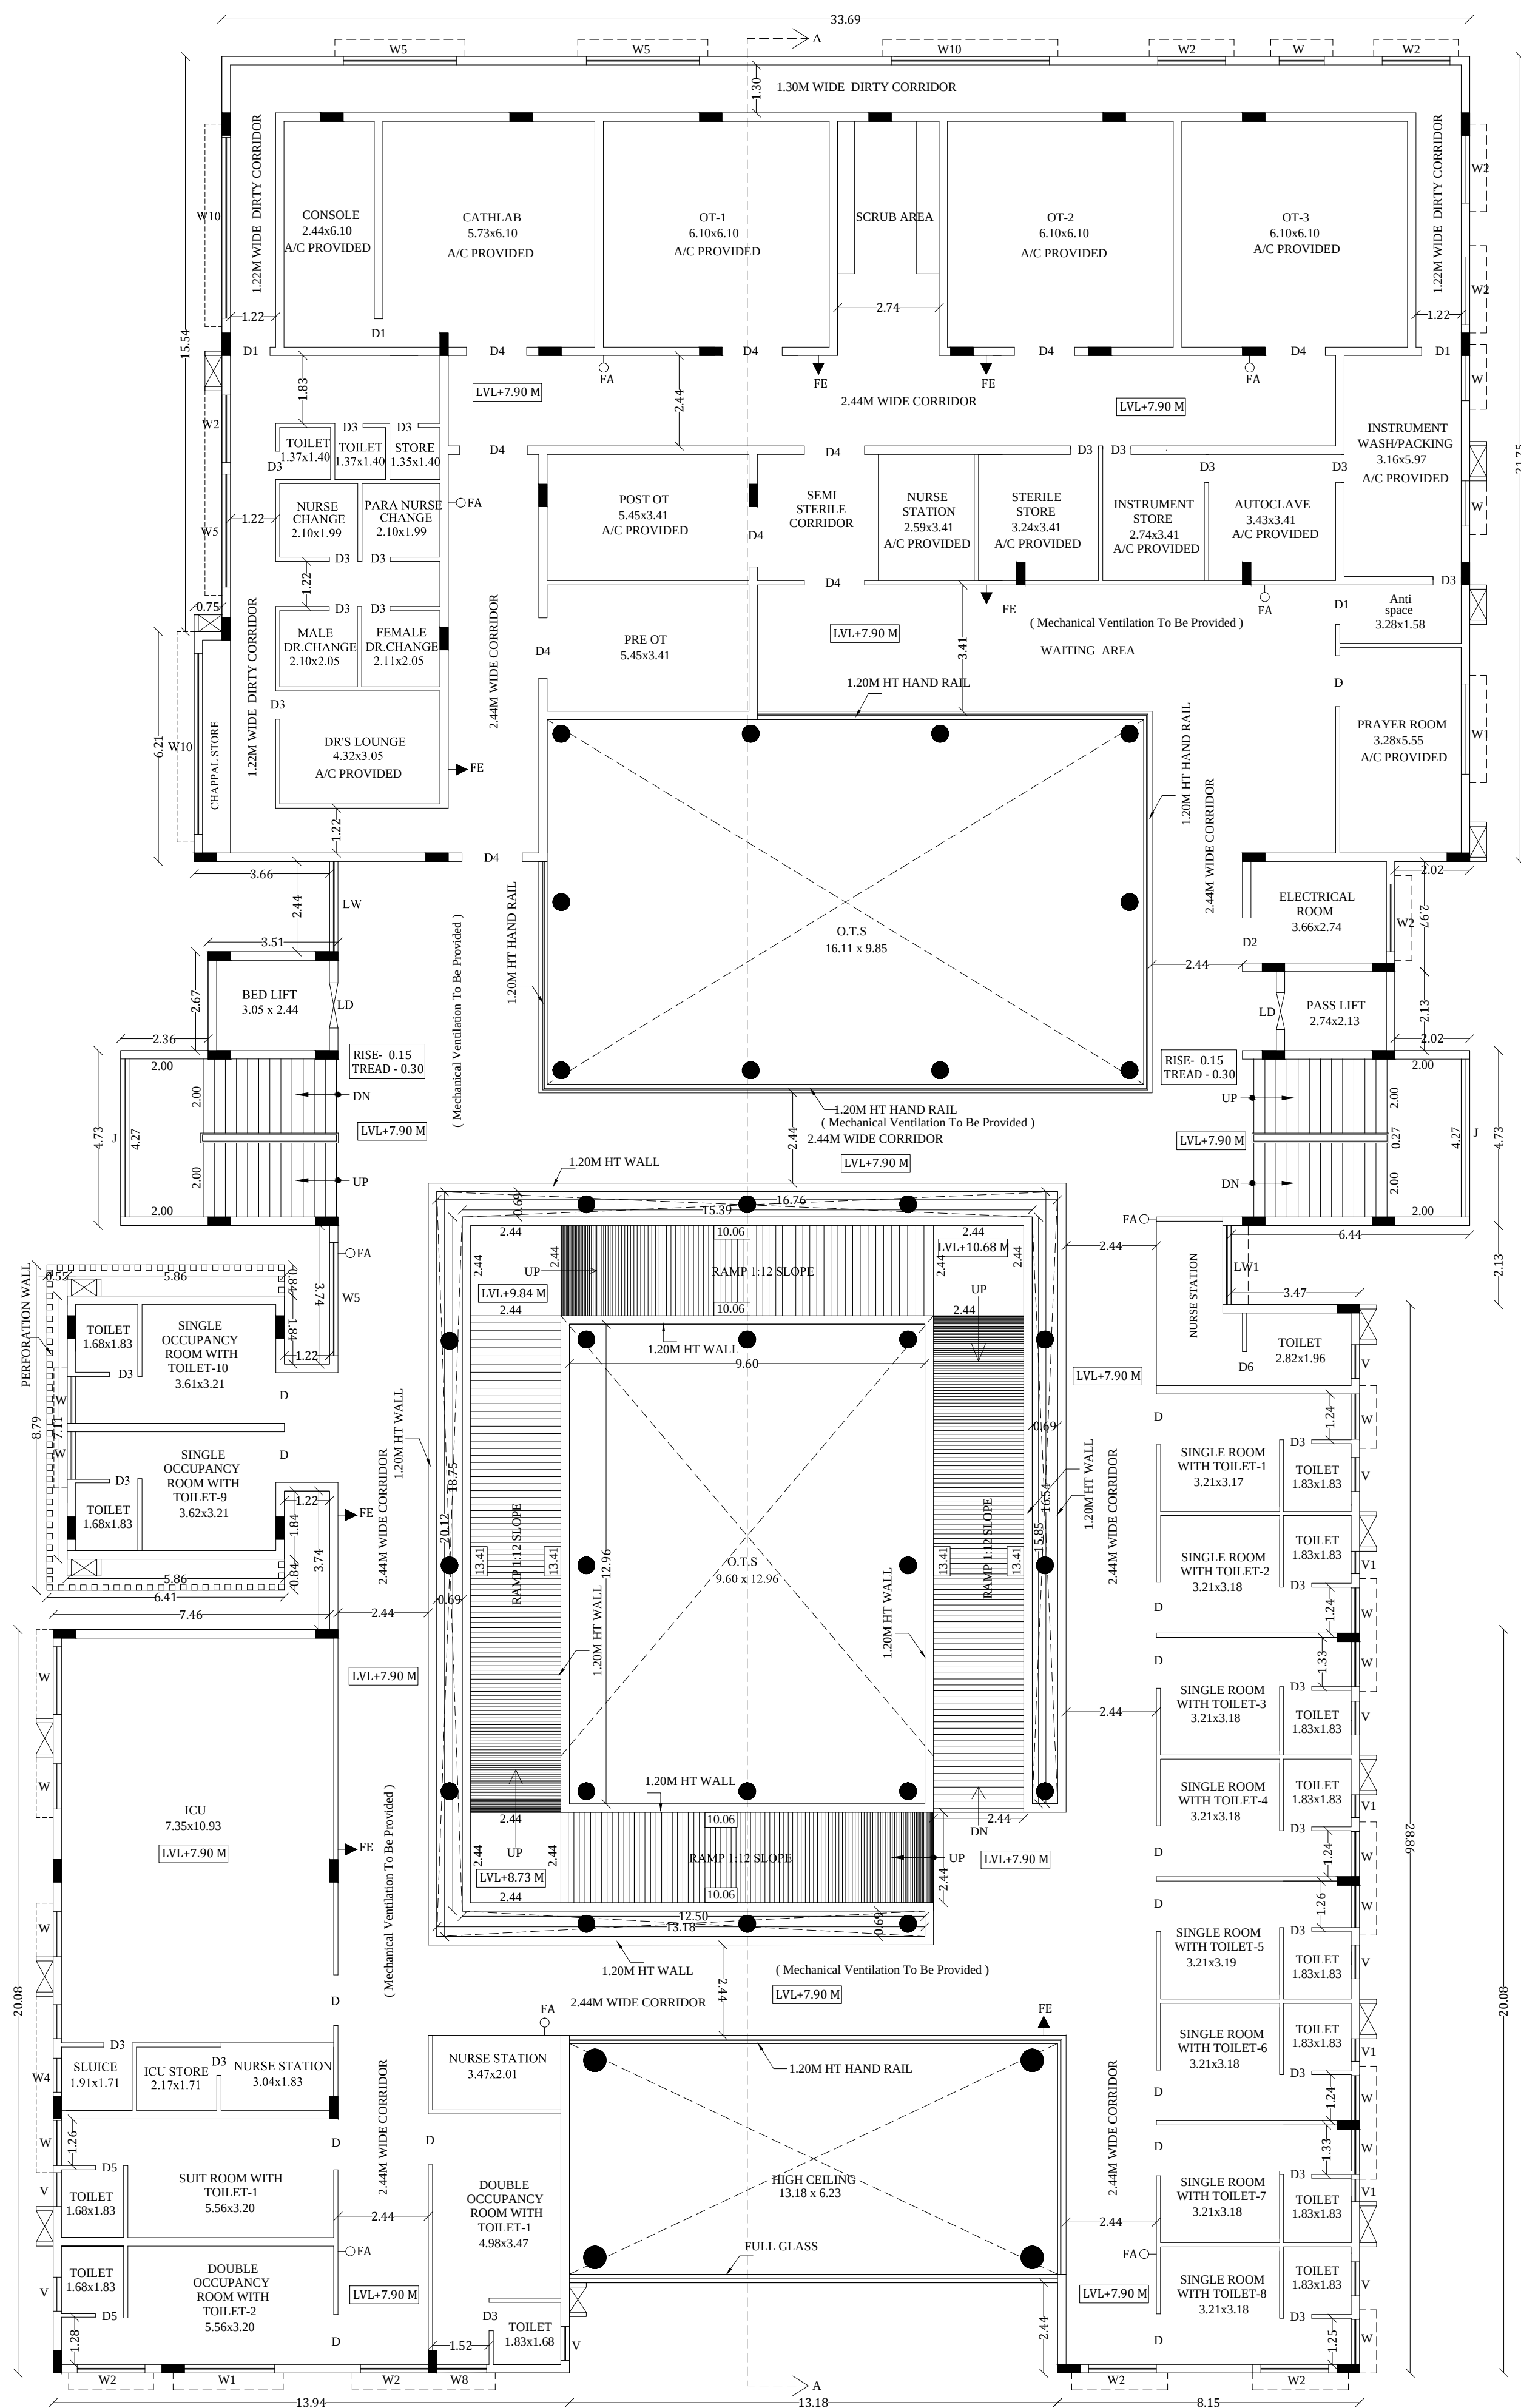

SECOND FLOOR PLAN

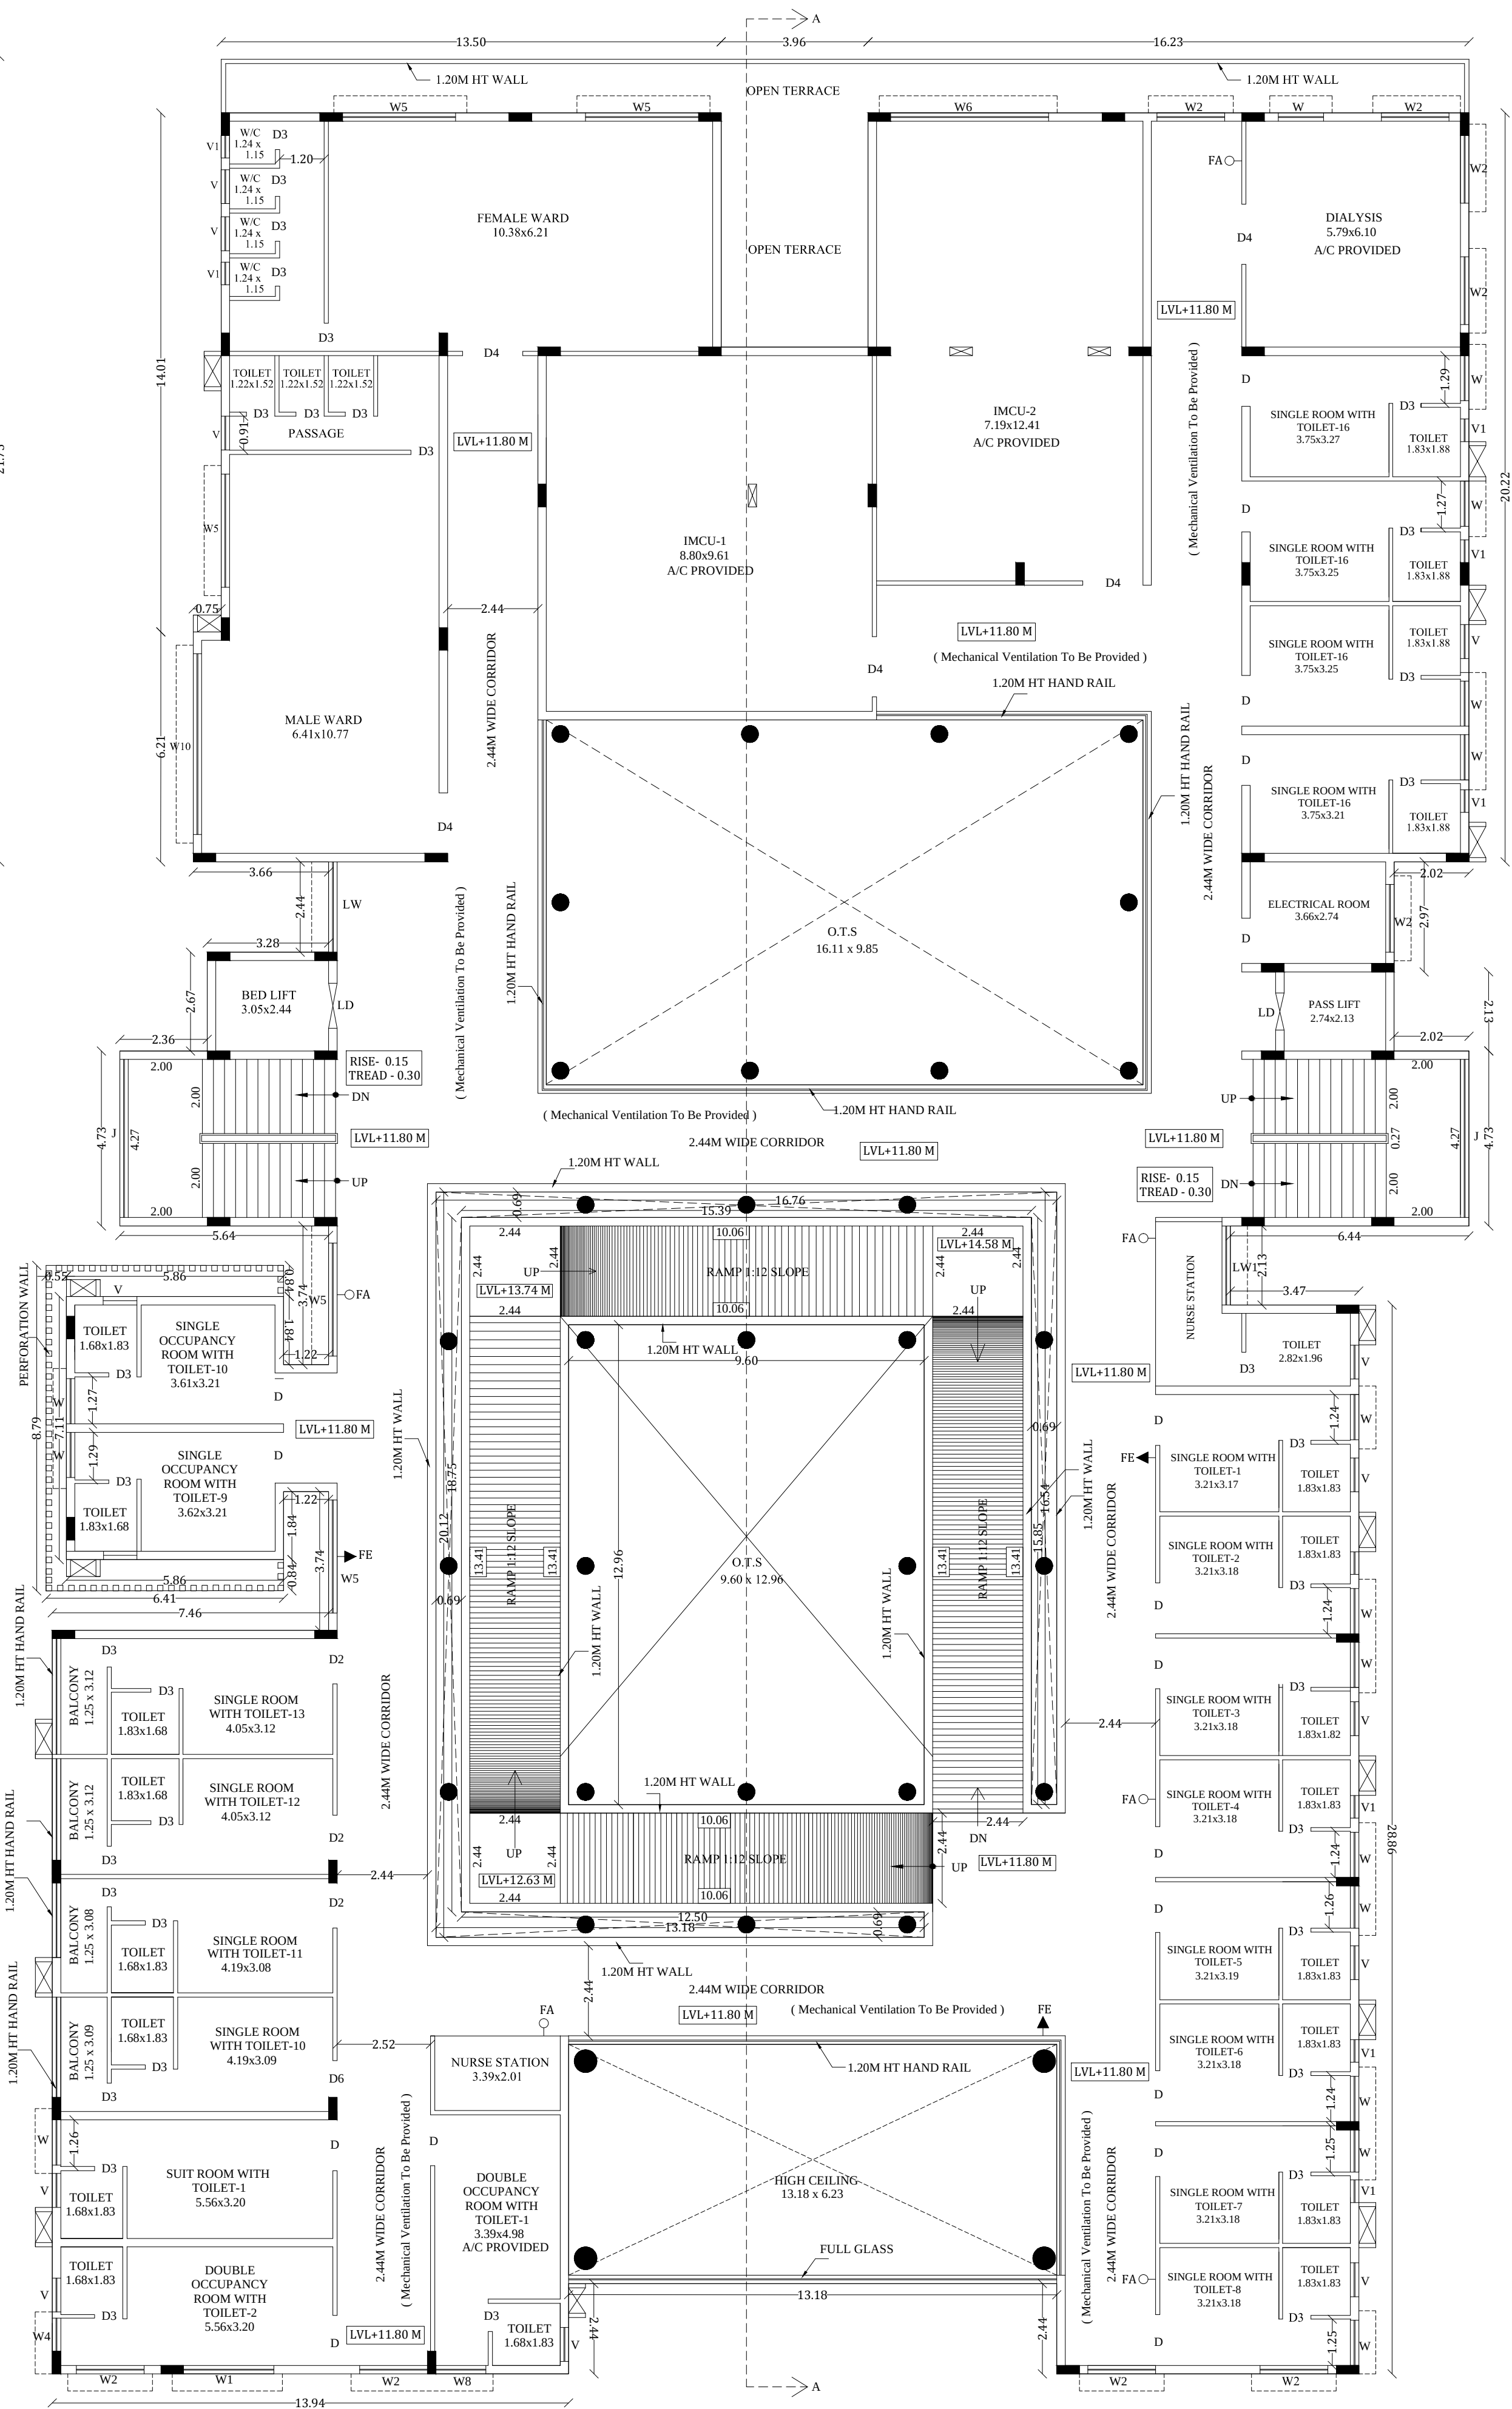









THIRD FLOOR PLAN

B.P/DTCP: 294/2023







The image displays three architectural drawings of a building terrace:

- TERRACE FLOOR PLAN:** A detailed plan view of the terrace. It features a central rectangular area with a diagonal cross-section labeled 'O.T.S. 16.11 x 9.85'. Surrounding this are various rooms and areas, including 'MACHINE ROOM 3.05 x 2.44', 'PHYSIOTHERAPY', 'LOBBY', 'USG/COLOR DOPPLER/ECHO', 'POST OT', 'PRE OT', and 'IMCU-1'. The plan includes numerous 'Solar Energy System' units, '1.20M HT PARAPET WALL', and '1.20M HT WALL'. It also shows 'OPEN TERRACE' areas and 'RAMP' structures. Dimensions and levels (e.g., LVL+15.70 M, LVL+15.83 M) are indicated throughout.
- SECTION-AA:** A vertical cross-section of the terrace. It shows the internal structure, including the 'RAMP ROOF', 'LIGHTNING ARRESTER', and 'FULL GLASS' walls. The section includes labels for 'OPEN TERRACE', 'IMCU-1', 'OT-1', 'PHYSIOTHERAPY', 'LOBBY', and 'USG/COLOR DOPPLER/ECHO'. It also shows '8'0" feet wide corridor' and 'CLUTOUT' areas. The section is labeled 'SECTION-AA' and 'GL'.
- ELEVATION:** A perspective view of the terrace facade. It shows the building's exterior, including the 'RAMP ROOF', 'LIGHTNING ARRESTER', and 'FULL GLASS' walls. The elevation is labeled 'ELEVATION' and 'GL'.



[illegible][illegible][illegible][illegible][illegible]

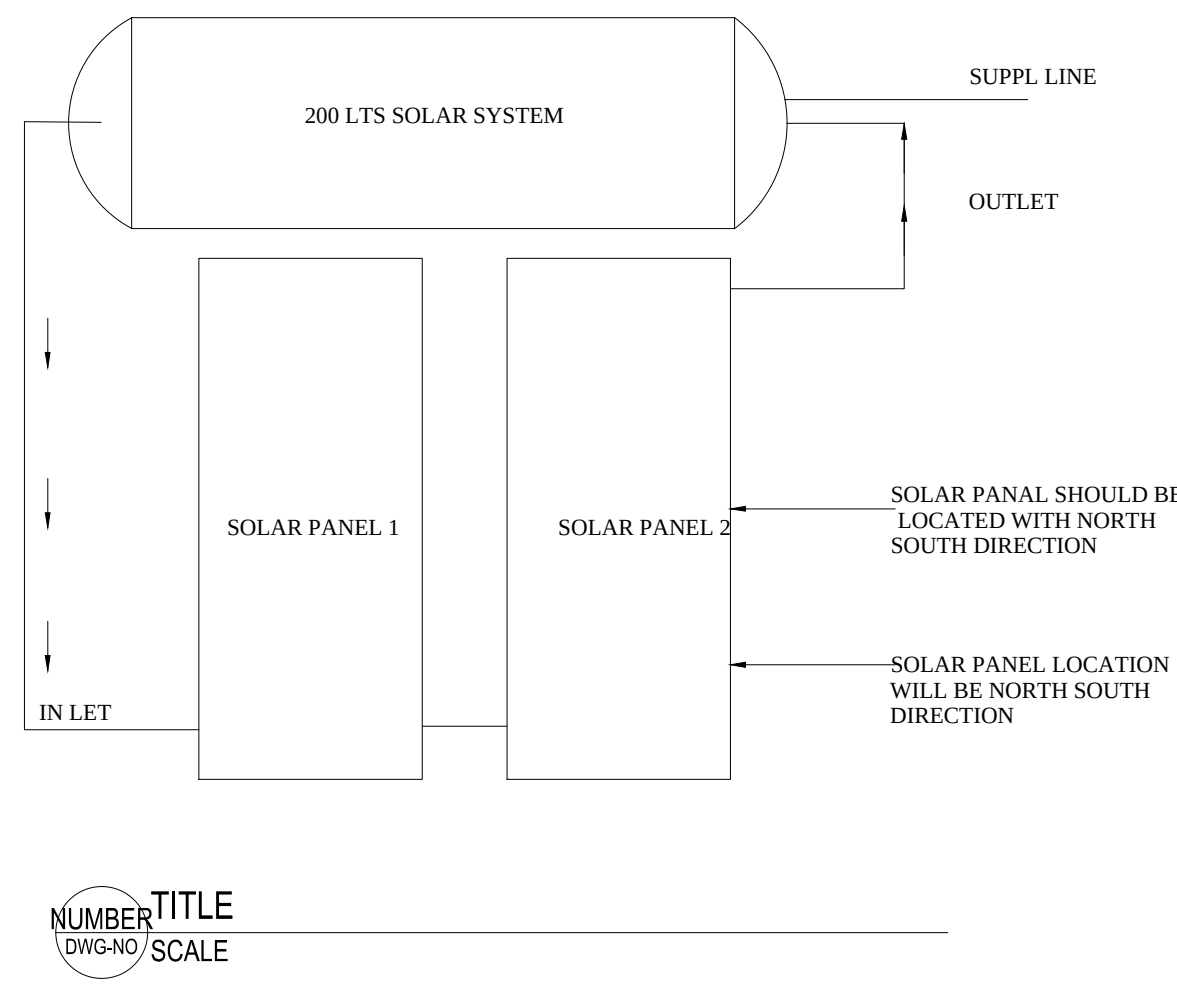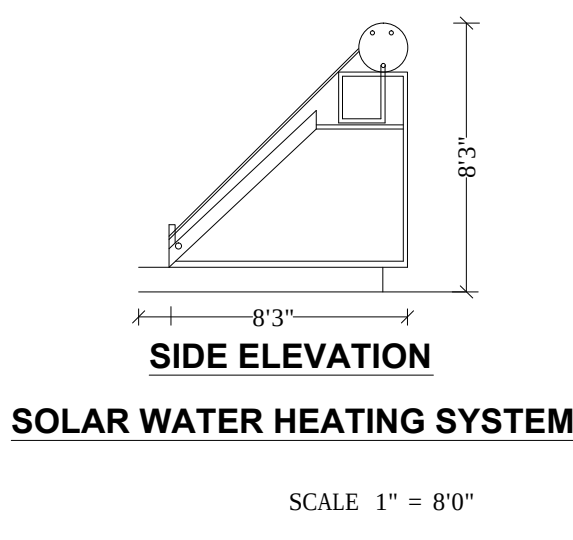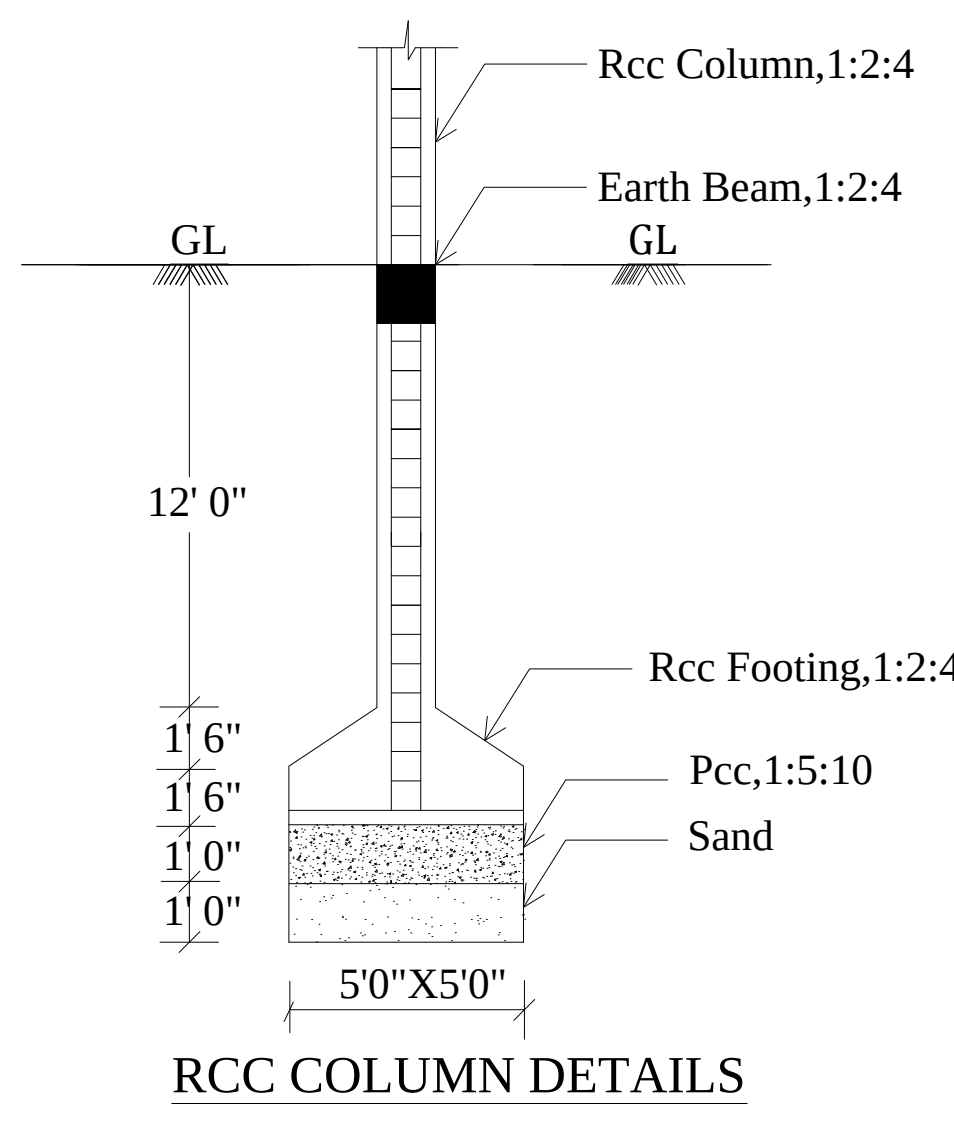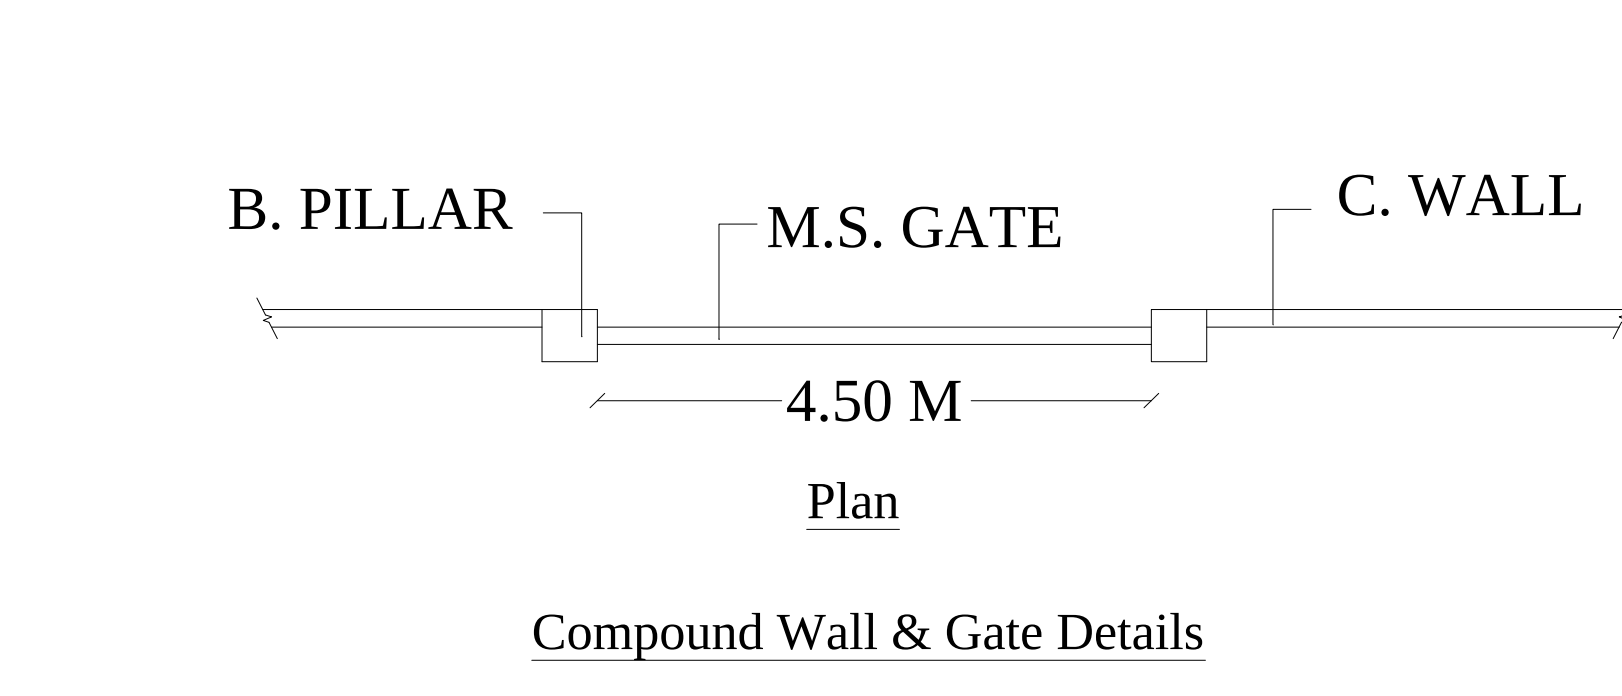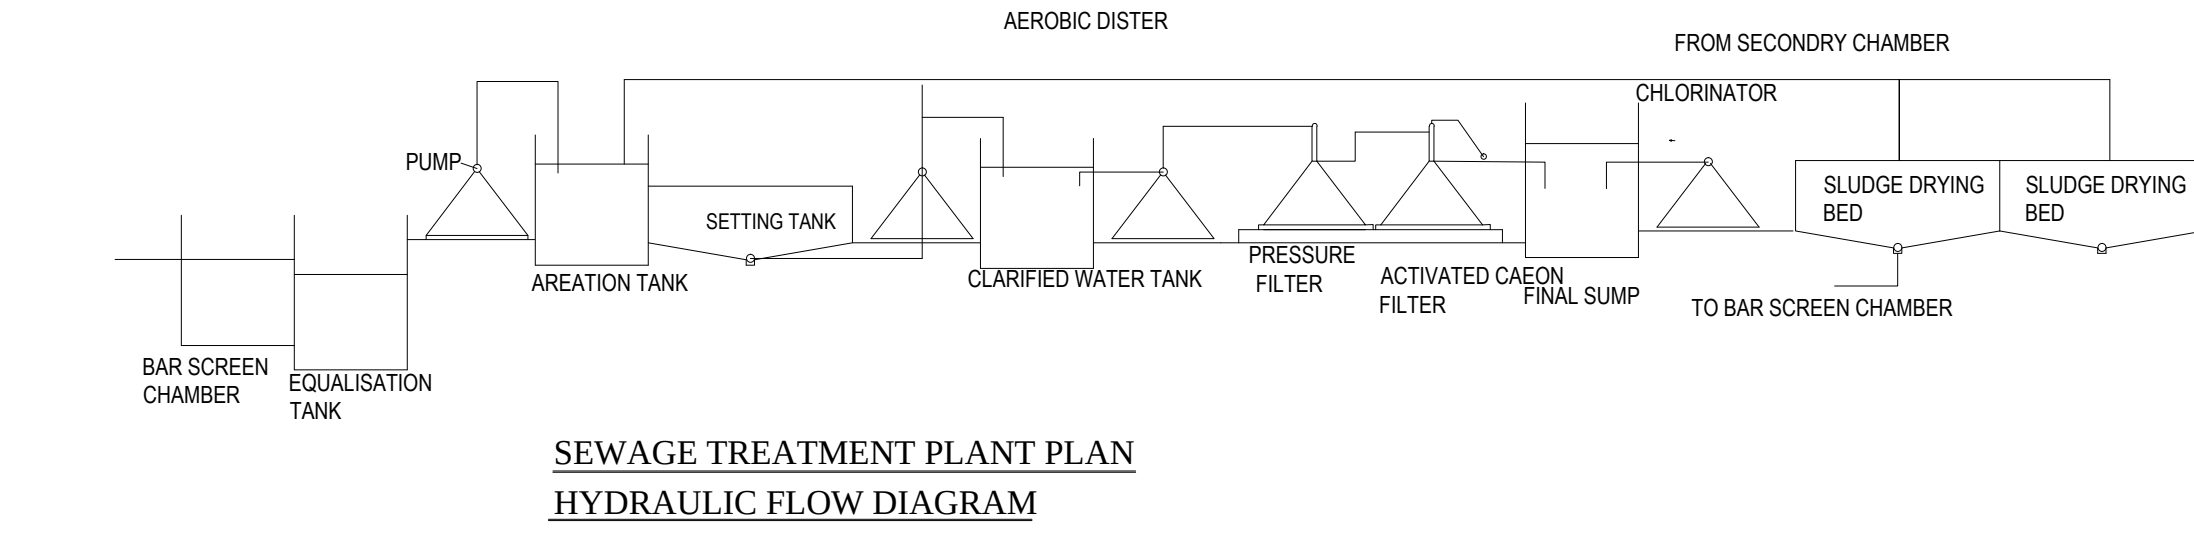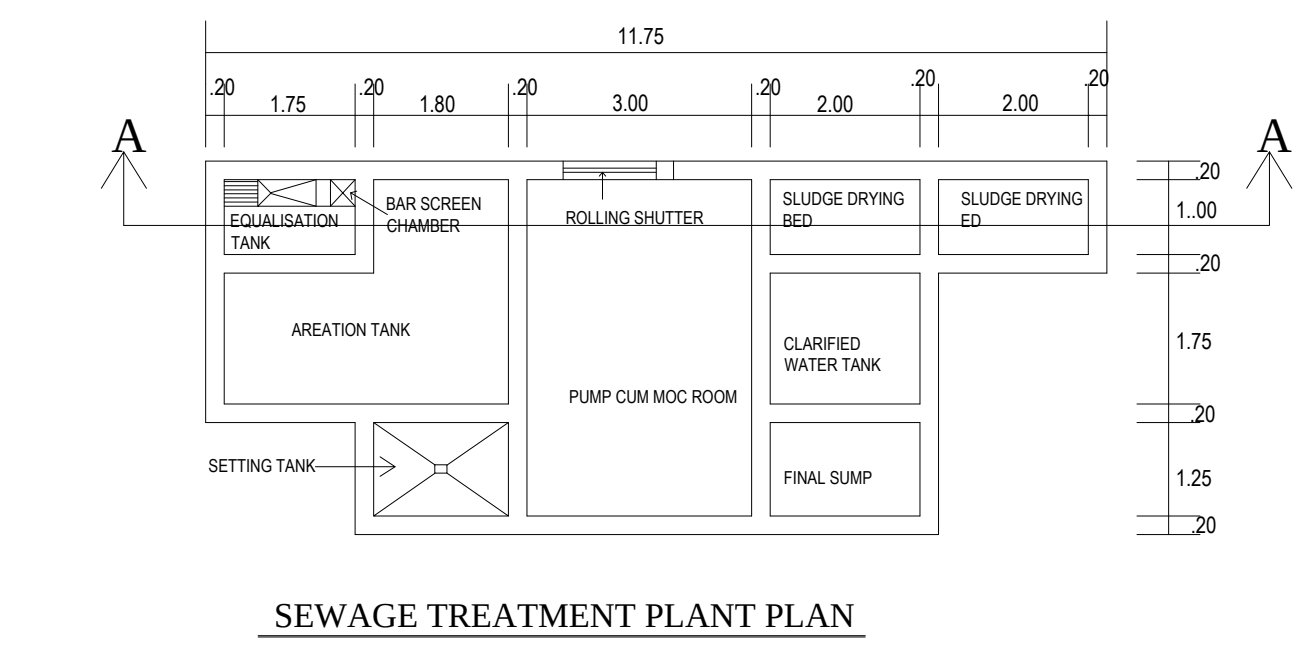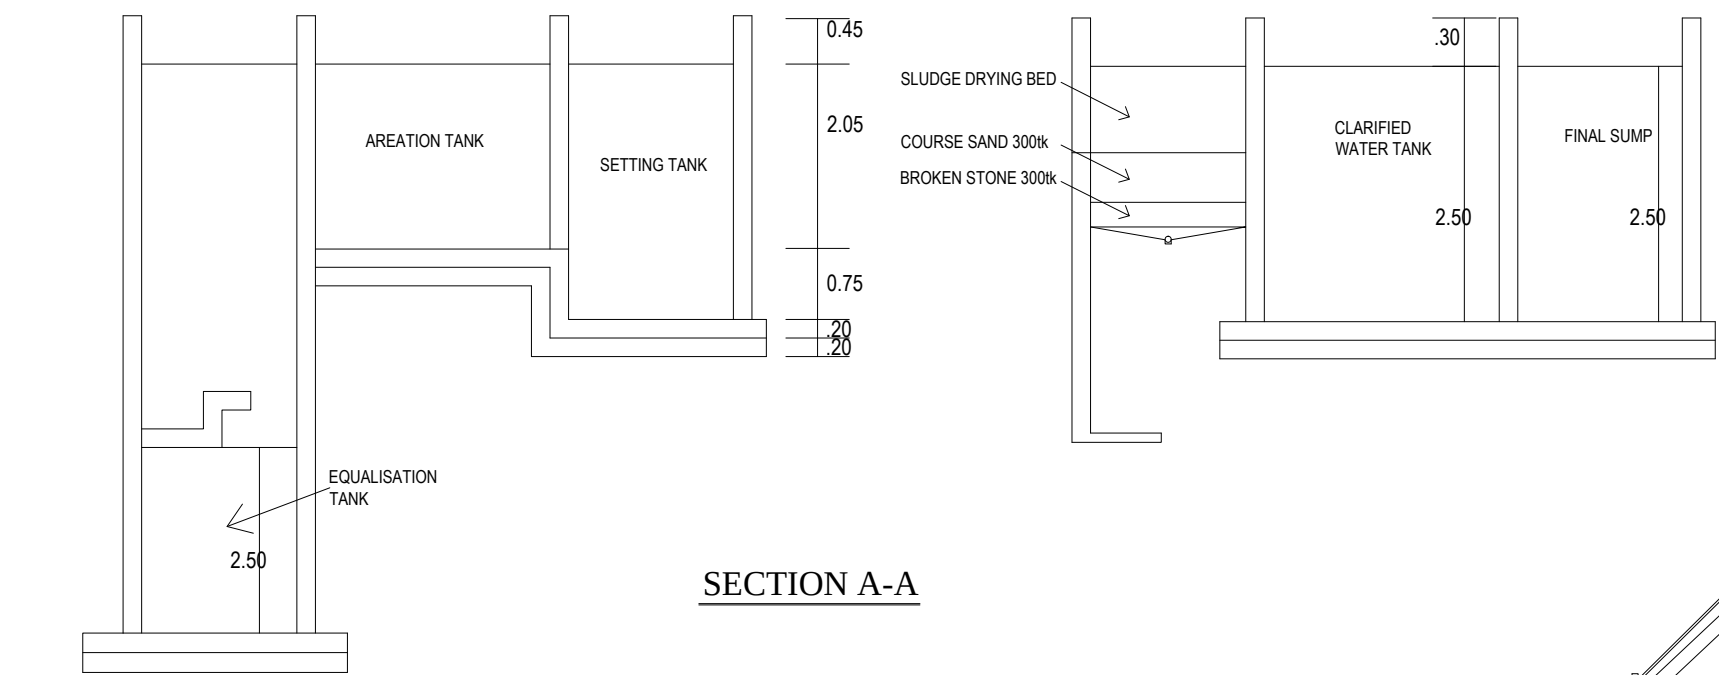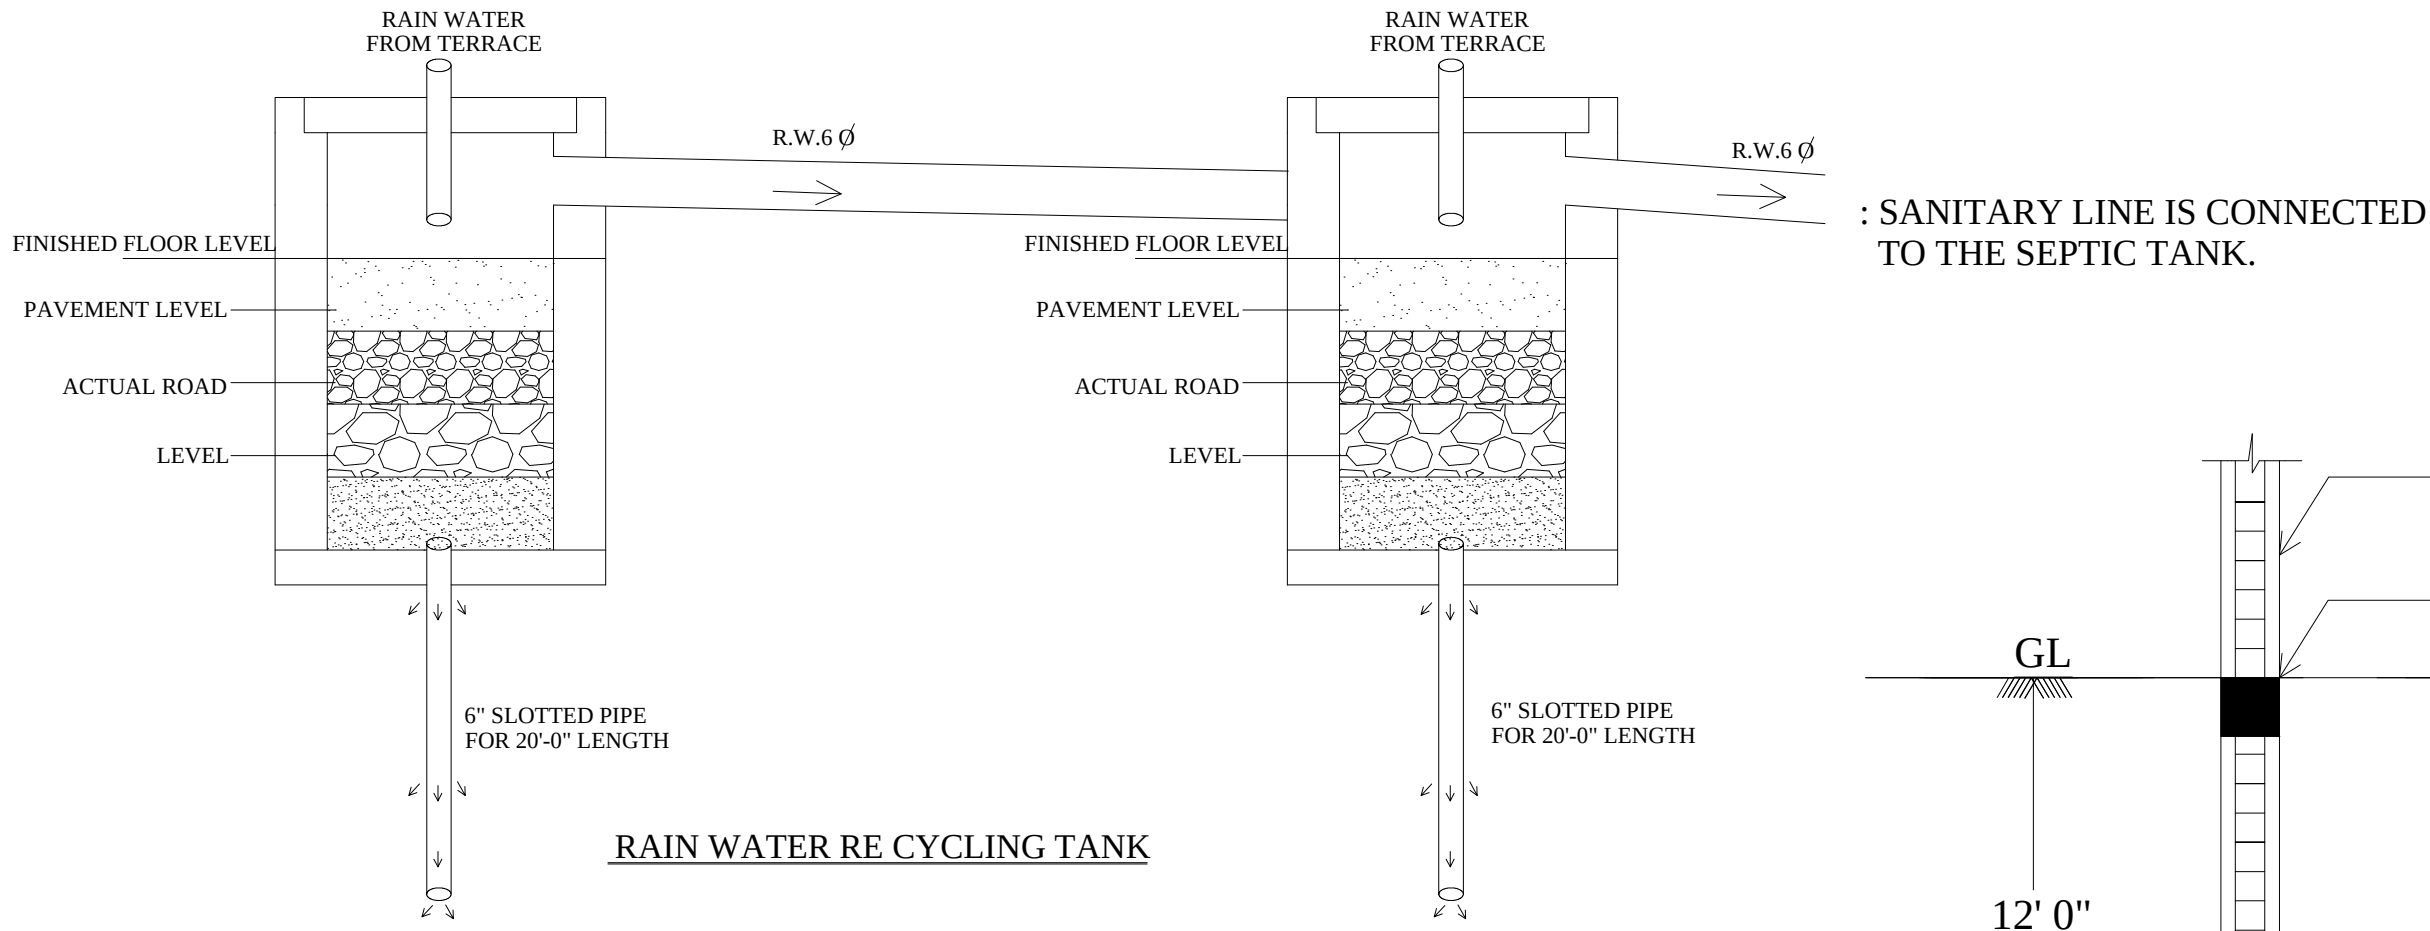

PLAN SHOWING THE R.W.H ,SOLAR SEPTIC TANK , AND S.T.P DETAILS FOR PROPOSED CONSTRUCTION OF HOSPITAL BUILDING IN SURVEY NO: 849/ 3A, IN PUDHUPALAYAM VILLAGE / PANCHAYAT, RAJAPALAYAM TALUK, VIRUDHUNAGAR DISTRICT.

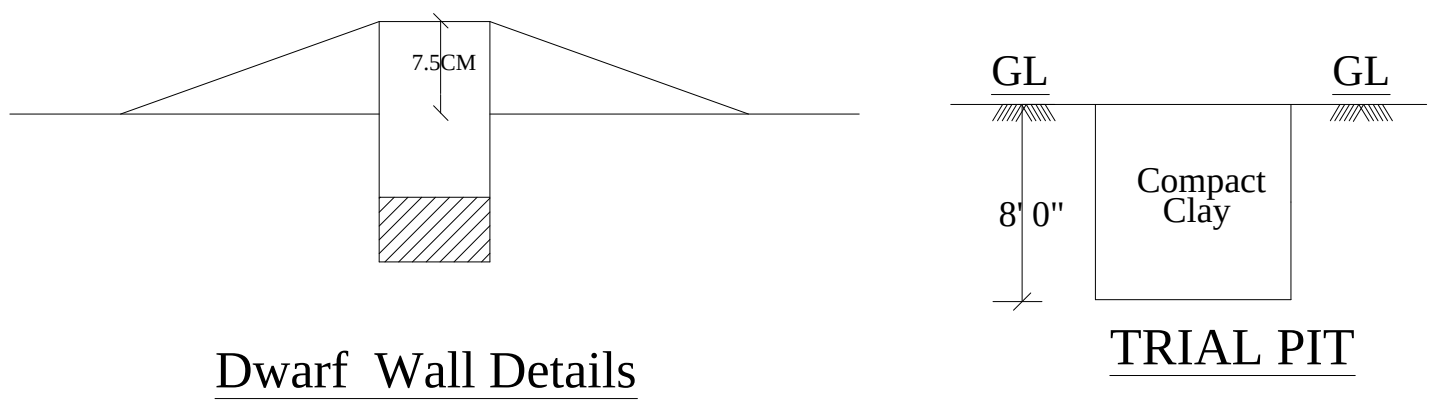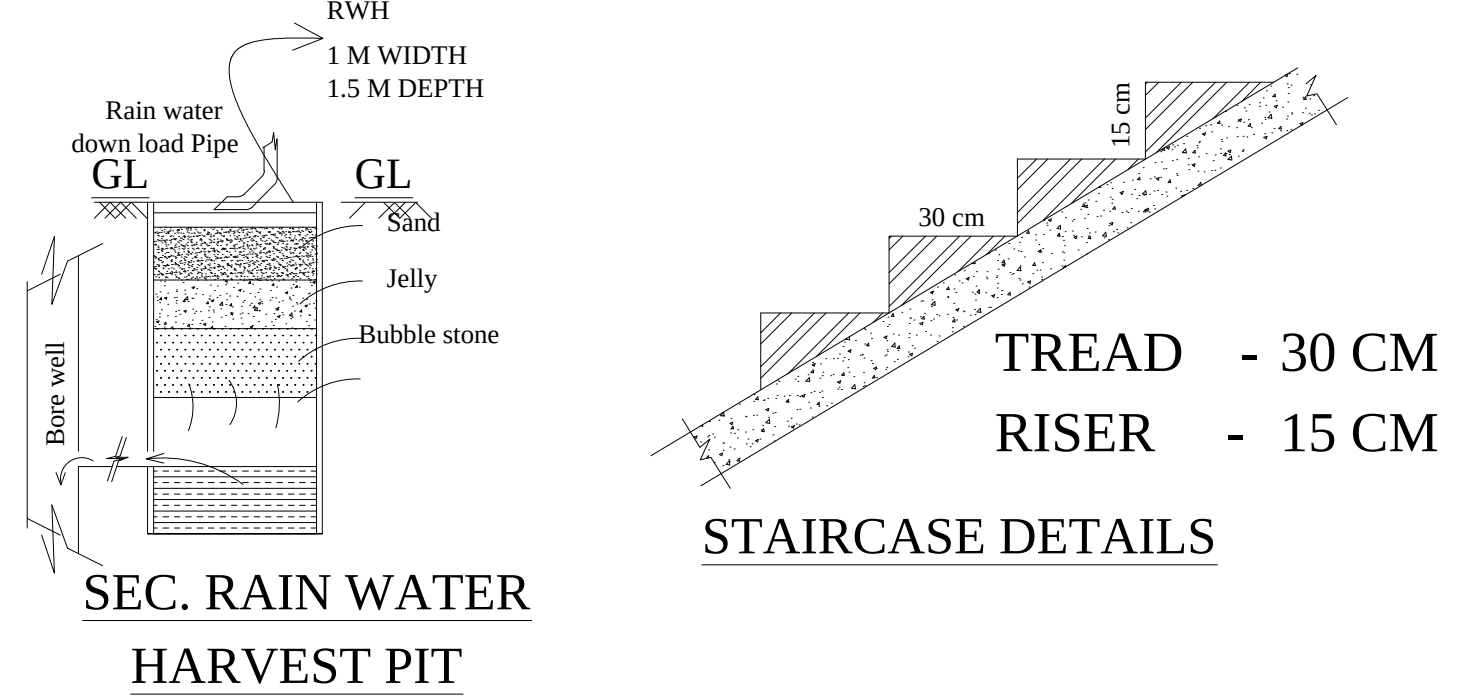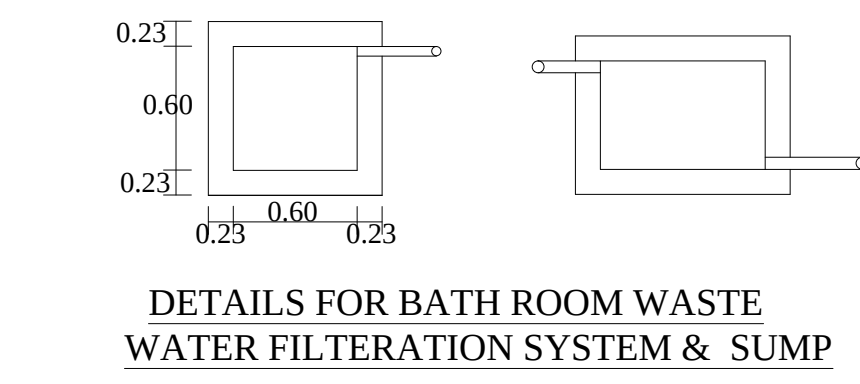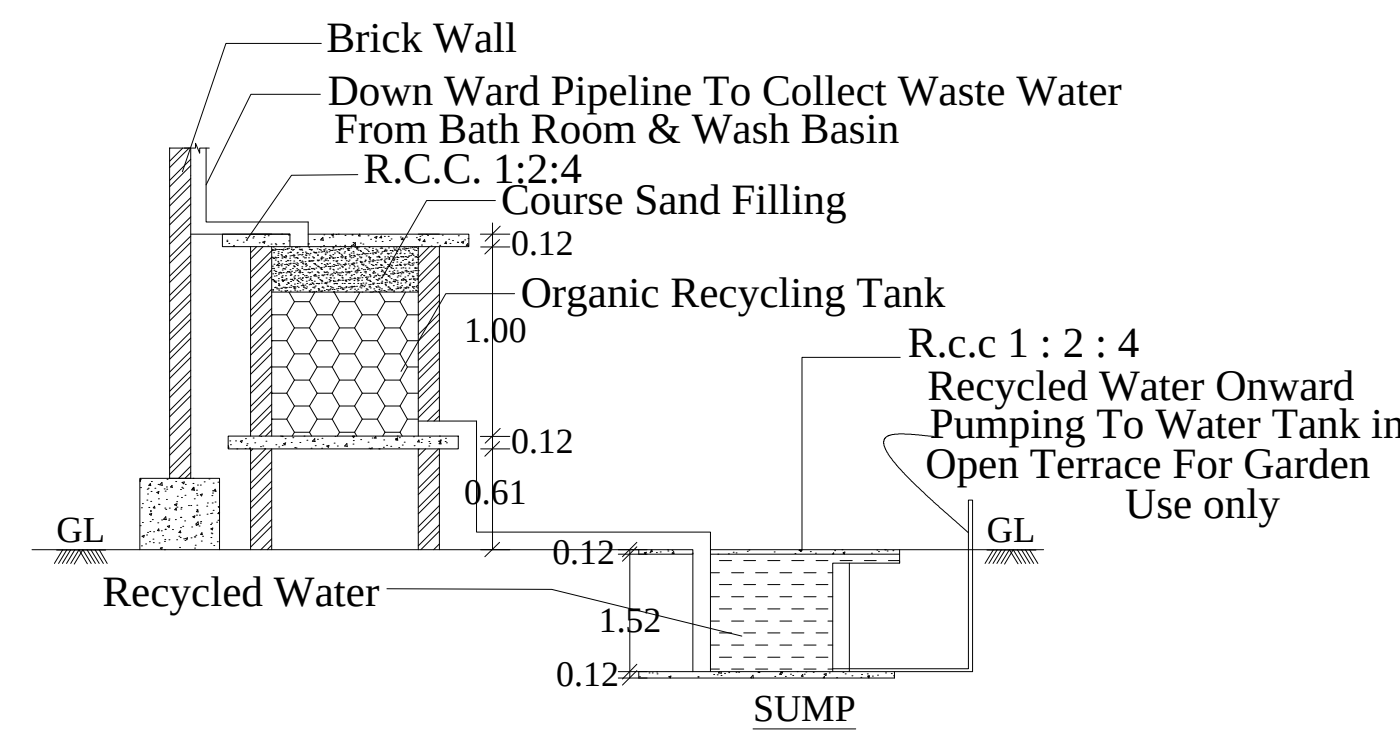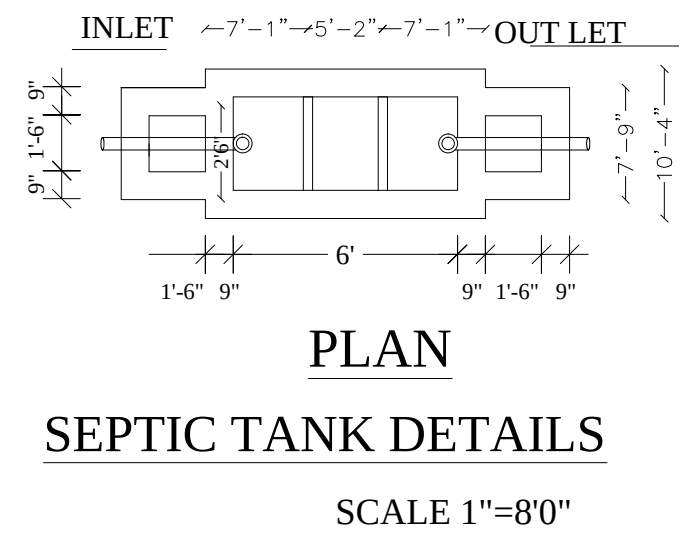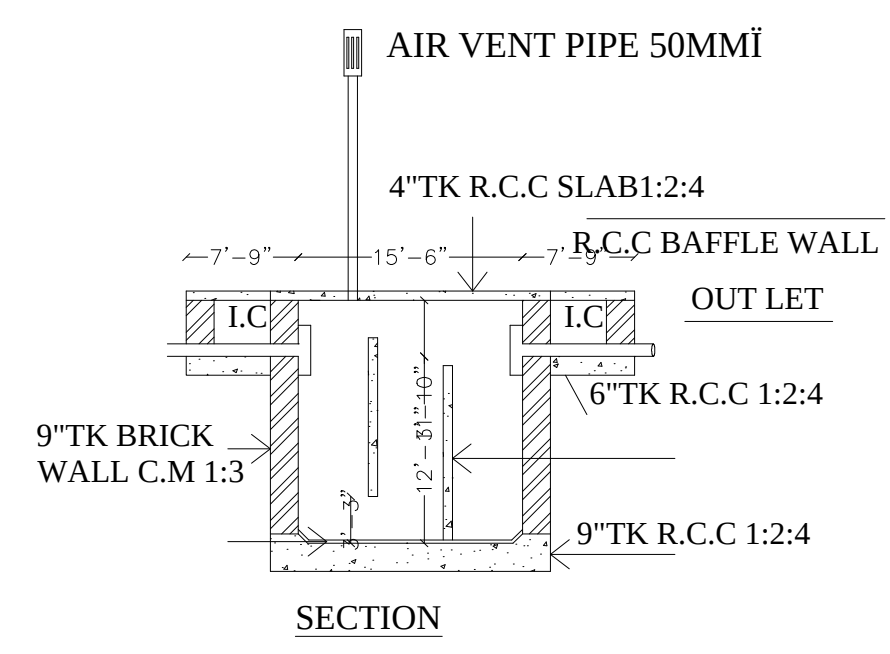

B.P/DTCP: 294/2023

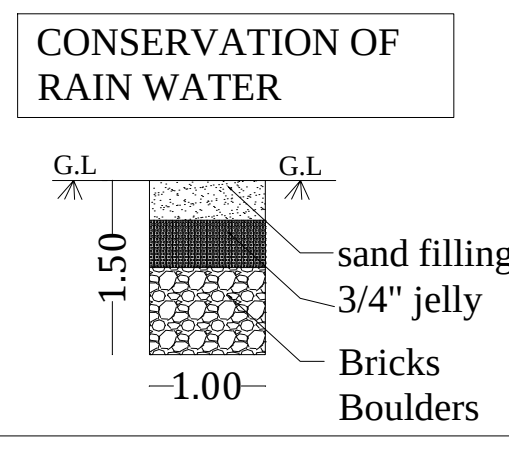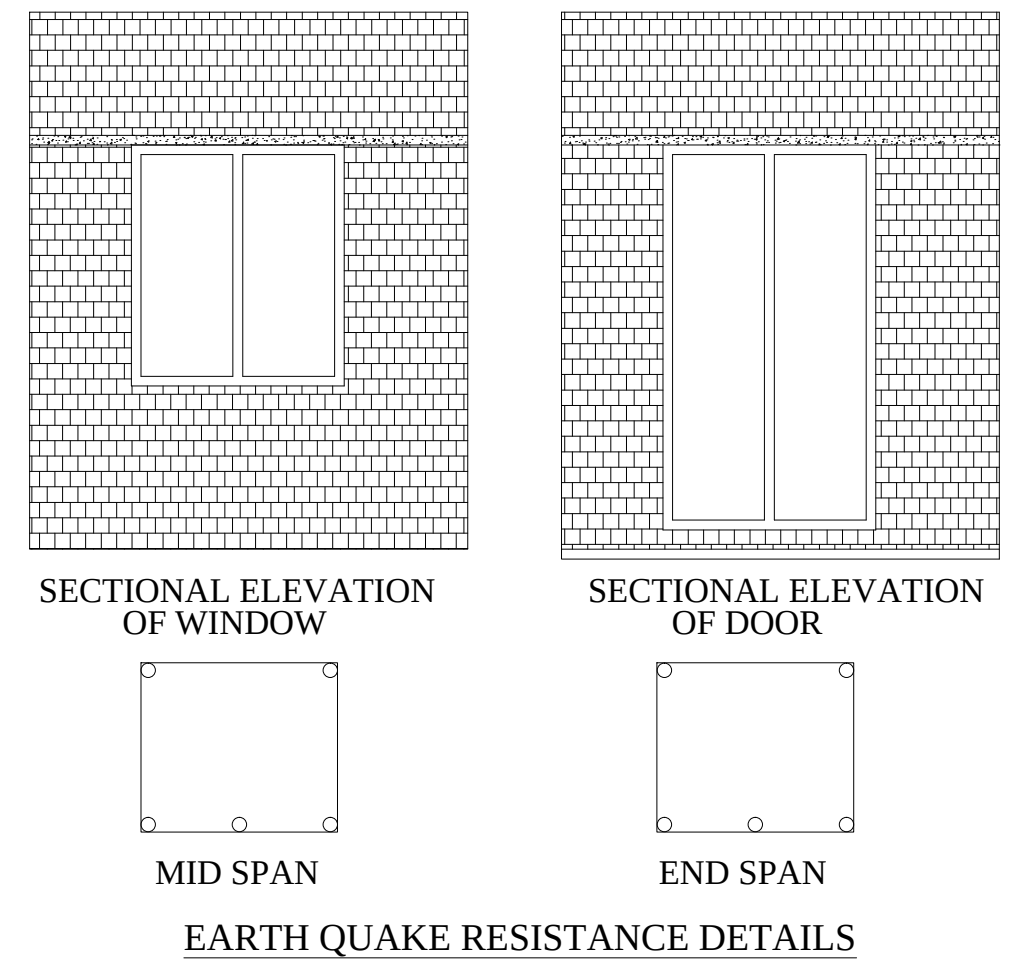

Dr. K. THANGAMANI, M.B.B.S., D.L.O.,
Reg. No. 38441
HARVEY CLINIC
KAMARAJ NAGAR,
RAJAPALAYAM 626 117.

M. MURALI, M.Arch., (MC Gill-Canada)
Registered Architect CA No: CA/85/9551
142, Second Street, Kamaraj Avenue,
Adyar, Chennai - 600 020.
Phone: 044 - 24914226, 24413230

Er. K. SHANKAR NARAYANAN, B.E., M.Tech.,
Registered Geotech Engineer
RGTE 001 / 2022
VARAHA GEOTECHNICAL WORKS
RAJAPALAYAM - 626 117.

Er. N. BALACHANDER, DCE
PLAN CENTER
Registered Construction Engineer No: CE 06/2019
No.25, South Street, Near Amma Mess
Tallakulam, Madurai - 2
Ph: 0452-486943, 4365043, 8220014843

S. VIJAYAN, M.E.,
STRUCTURAL CONSULTANT
CMDA : SE / GR 1 / 2022 / 11 / 346
No. 68, Second Floor M.R. High Road,
Moolakadai, Chennai - 600 030.
Ph : 044-48067852, 9841363910
Email : grandesmithprivatelimited@gmail.com

Er. T. BABU, B.E.,
PLAN CENTER
Registration No: RE 016/2019 (Grade.I)
No.25, South Street, Near Amma Mess
Tallakulam, Madurai - 2
Ph: 8220044943, 9786948414

